


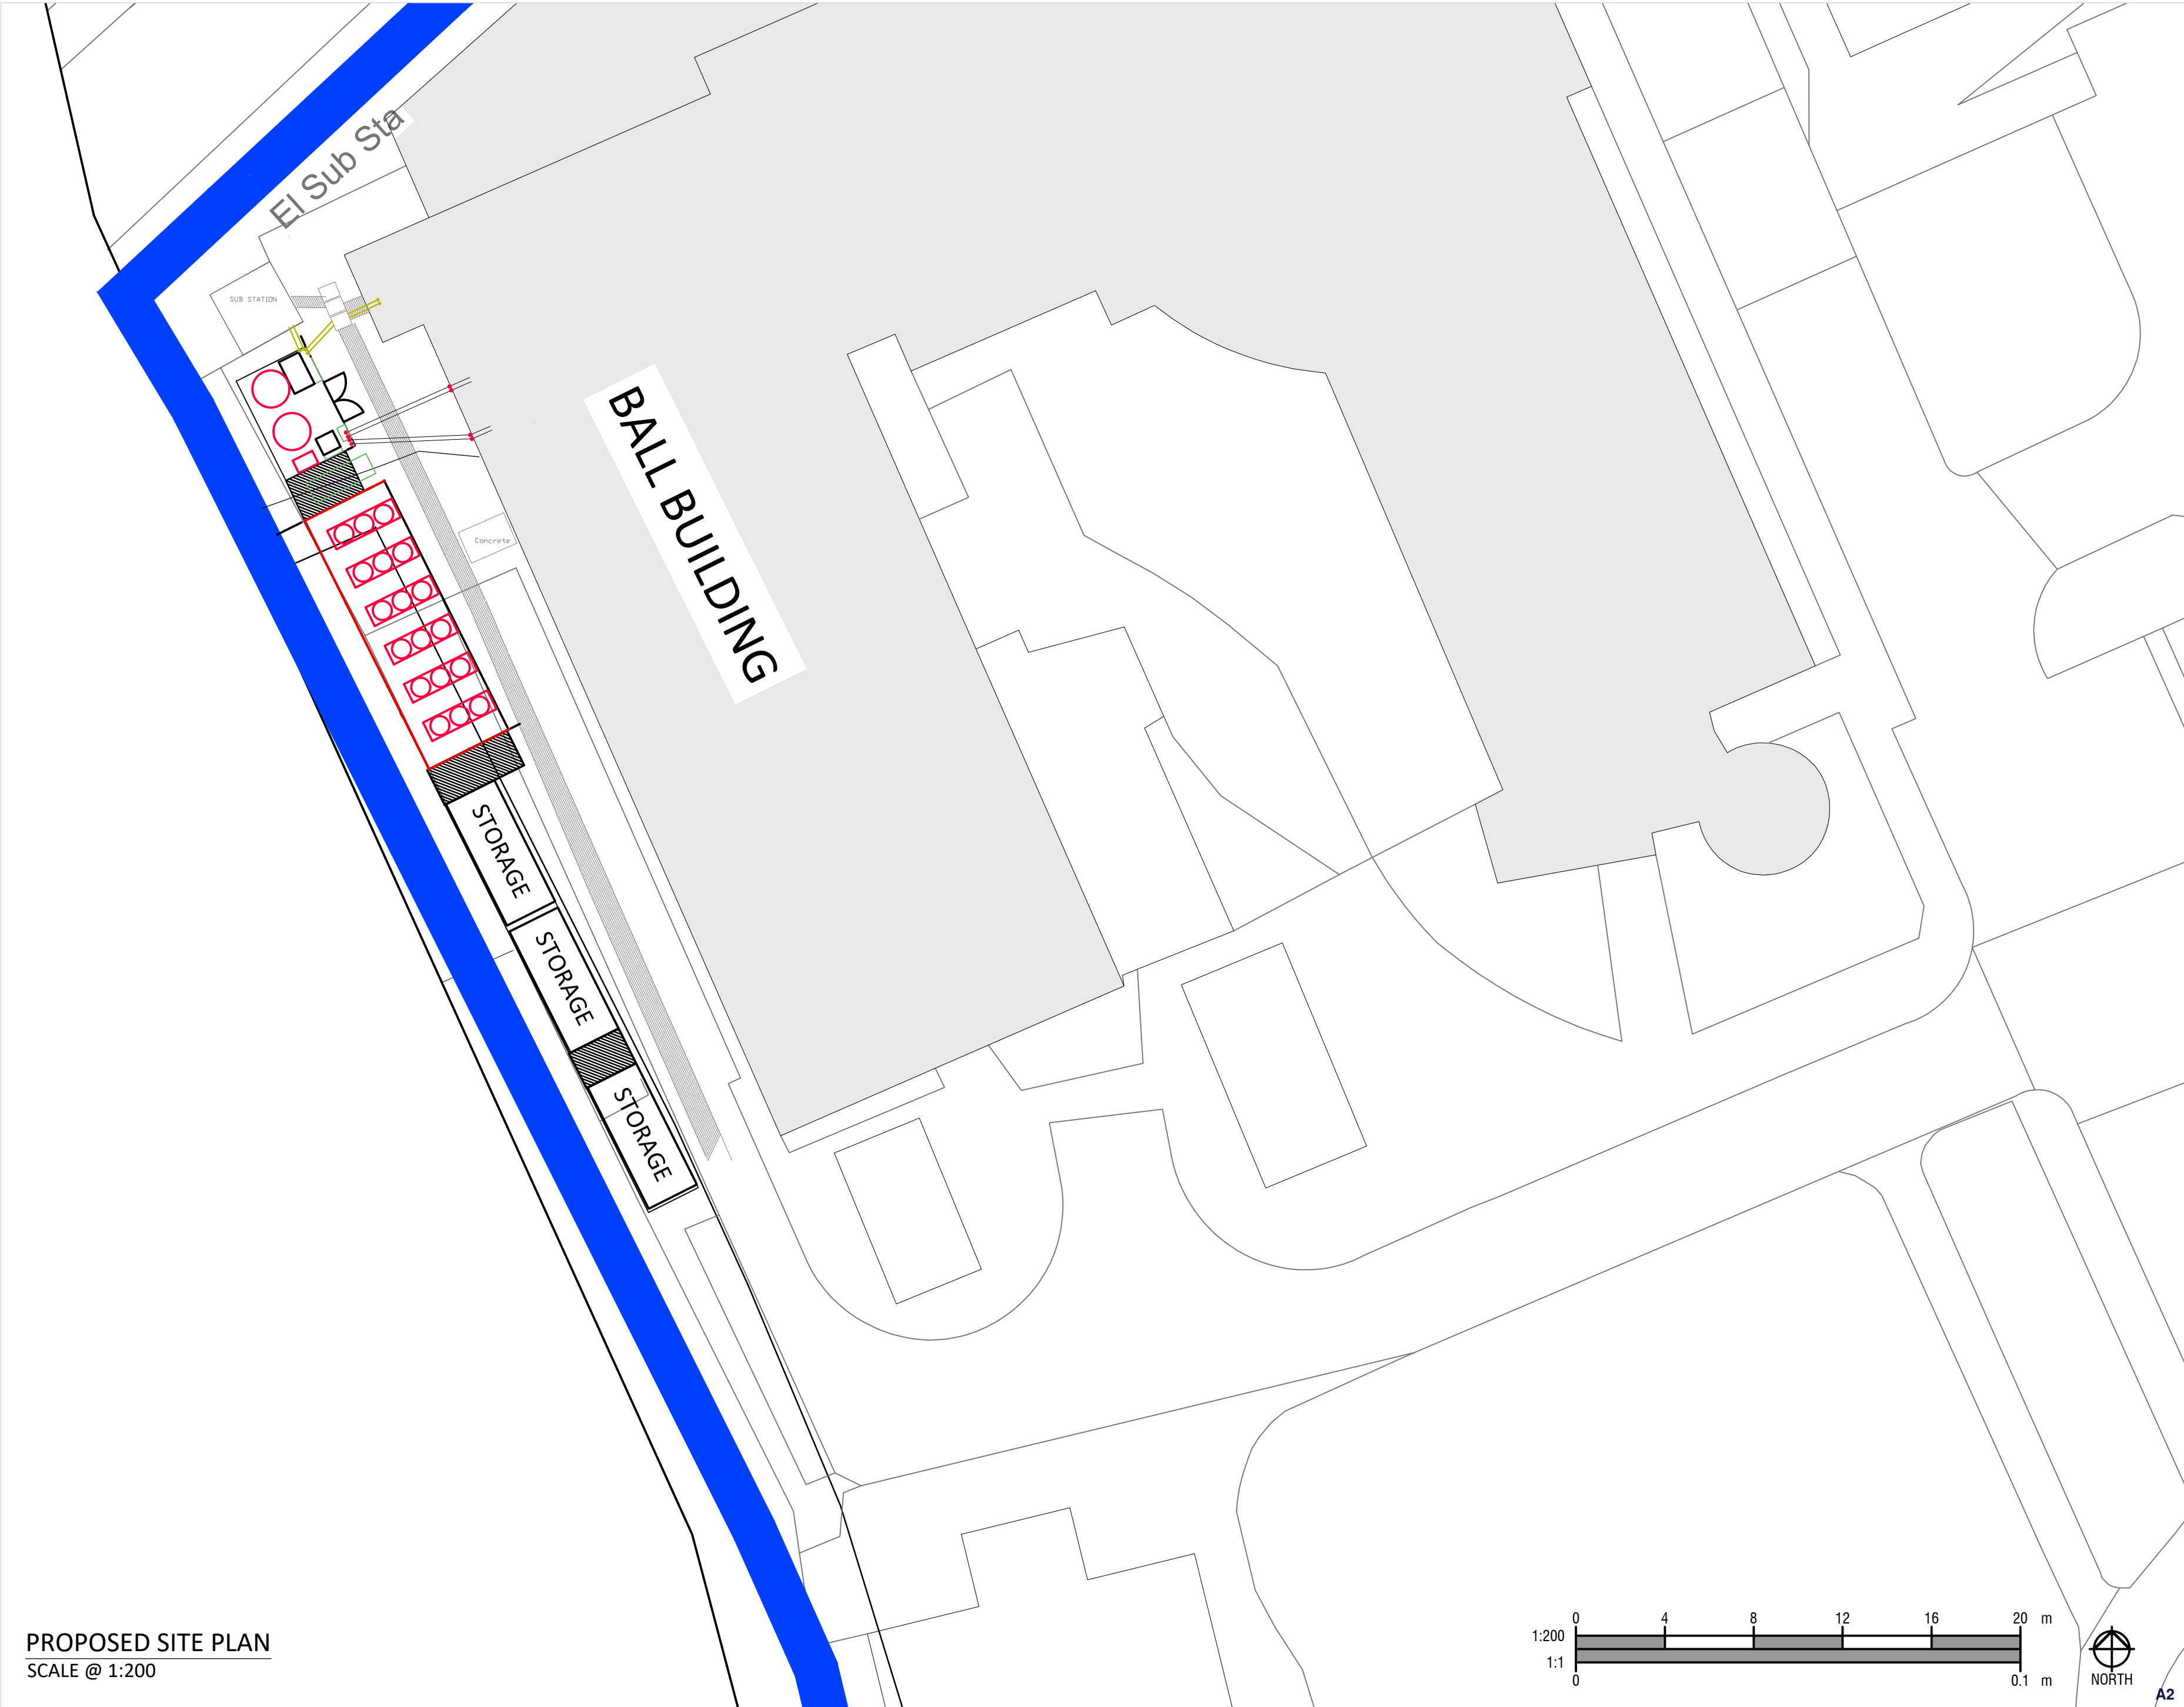

PROPOSED SITE PLAN  
SCALE @ 1:200

Notes:  
  
TO BE READ IN CONIUNCTION WITH  
MECHANICAL ENGINEERS, ELECTRICAL  
ENGINEERS, AND STRUCTURAL ENGINEERS  
DRAWINGS.

Copyright: All rights reserved. This drawing must not be reproduced without permission from AA Projects Ltd. Do not scale off this drawing. All dimensions are to be checked on site by contractor / sub contractor. Any discrepancies to be reported to AA Projects Ltd.

| Rev | Date | Revision notes | By | Check |
|-----|------|----------------|----|-------|
|     |      |                |    |       |

No.1 Aire Street  
Leeds  
LS1 4PR  
Tel: 0113 457 0027

Office Locations  
Birmingham, Leeds, Liverpool, London, Manchester, Oxford, Rugby, Newcastle  
www.aaprojects.co.uk

|                          |                |                                     |  |
|--------------------------|----------------|-------------------------------------|--|
| Client<br>Loreto College |                | Drawing Title<br>Proposed Site Plan |  |
| Project Title<br>ASHP    | Drawn<br>JHS   | Date<br>04/07/23                    |  |
|                          | Checked<br>TM  | Date<br>04/07/23                    |  |
| DWG No.<br>22087.002     | Scale<br>1:200 | Revision                            |  |

