



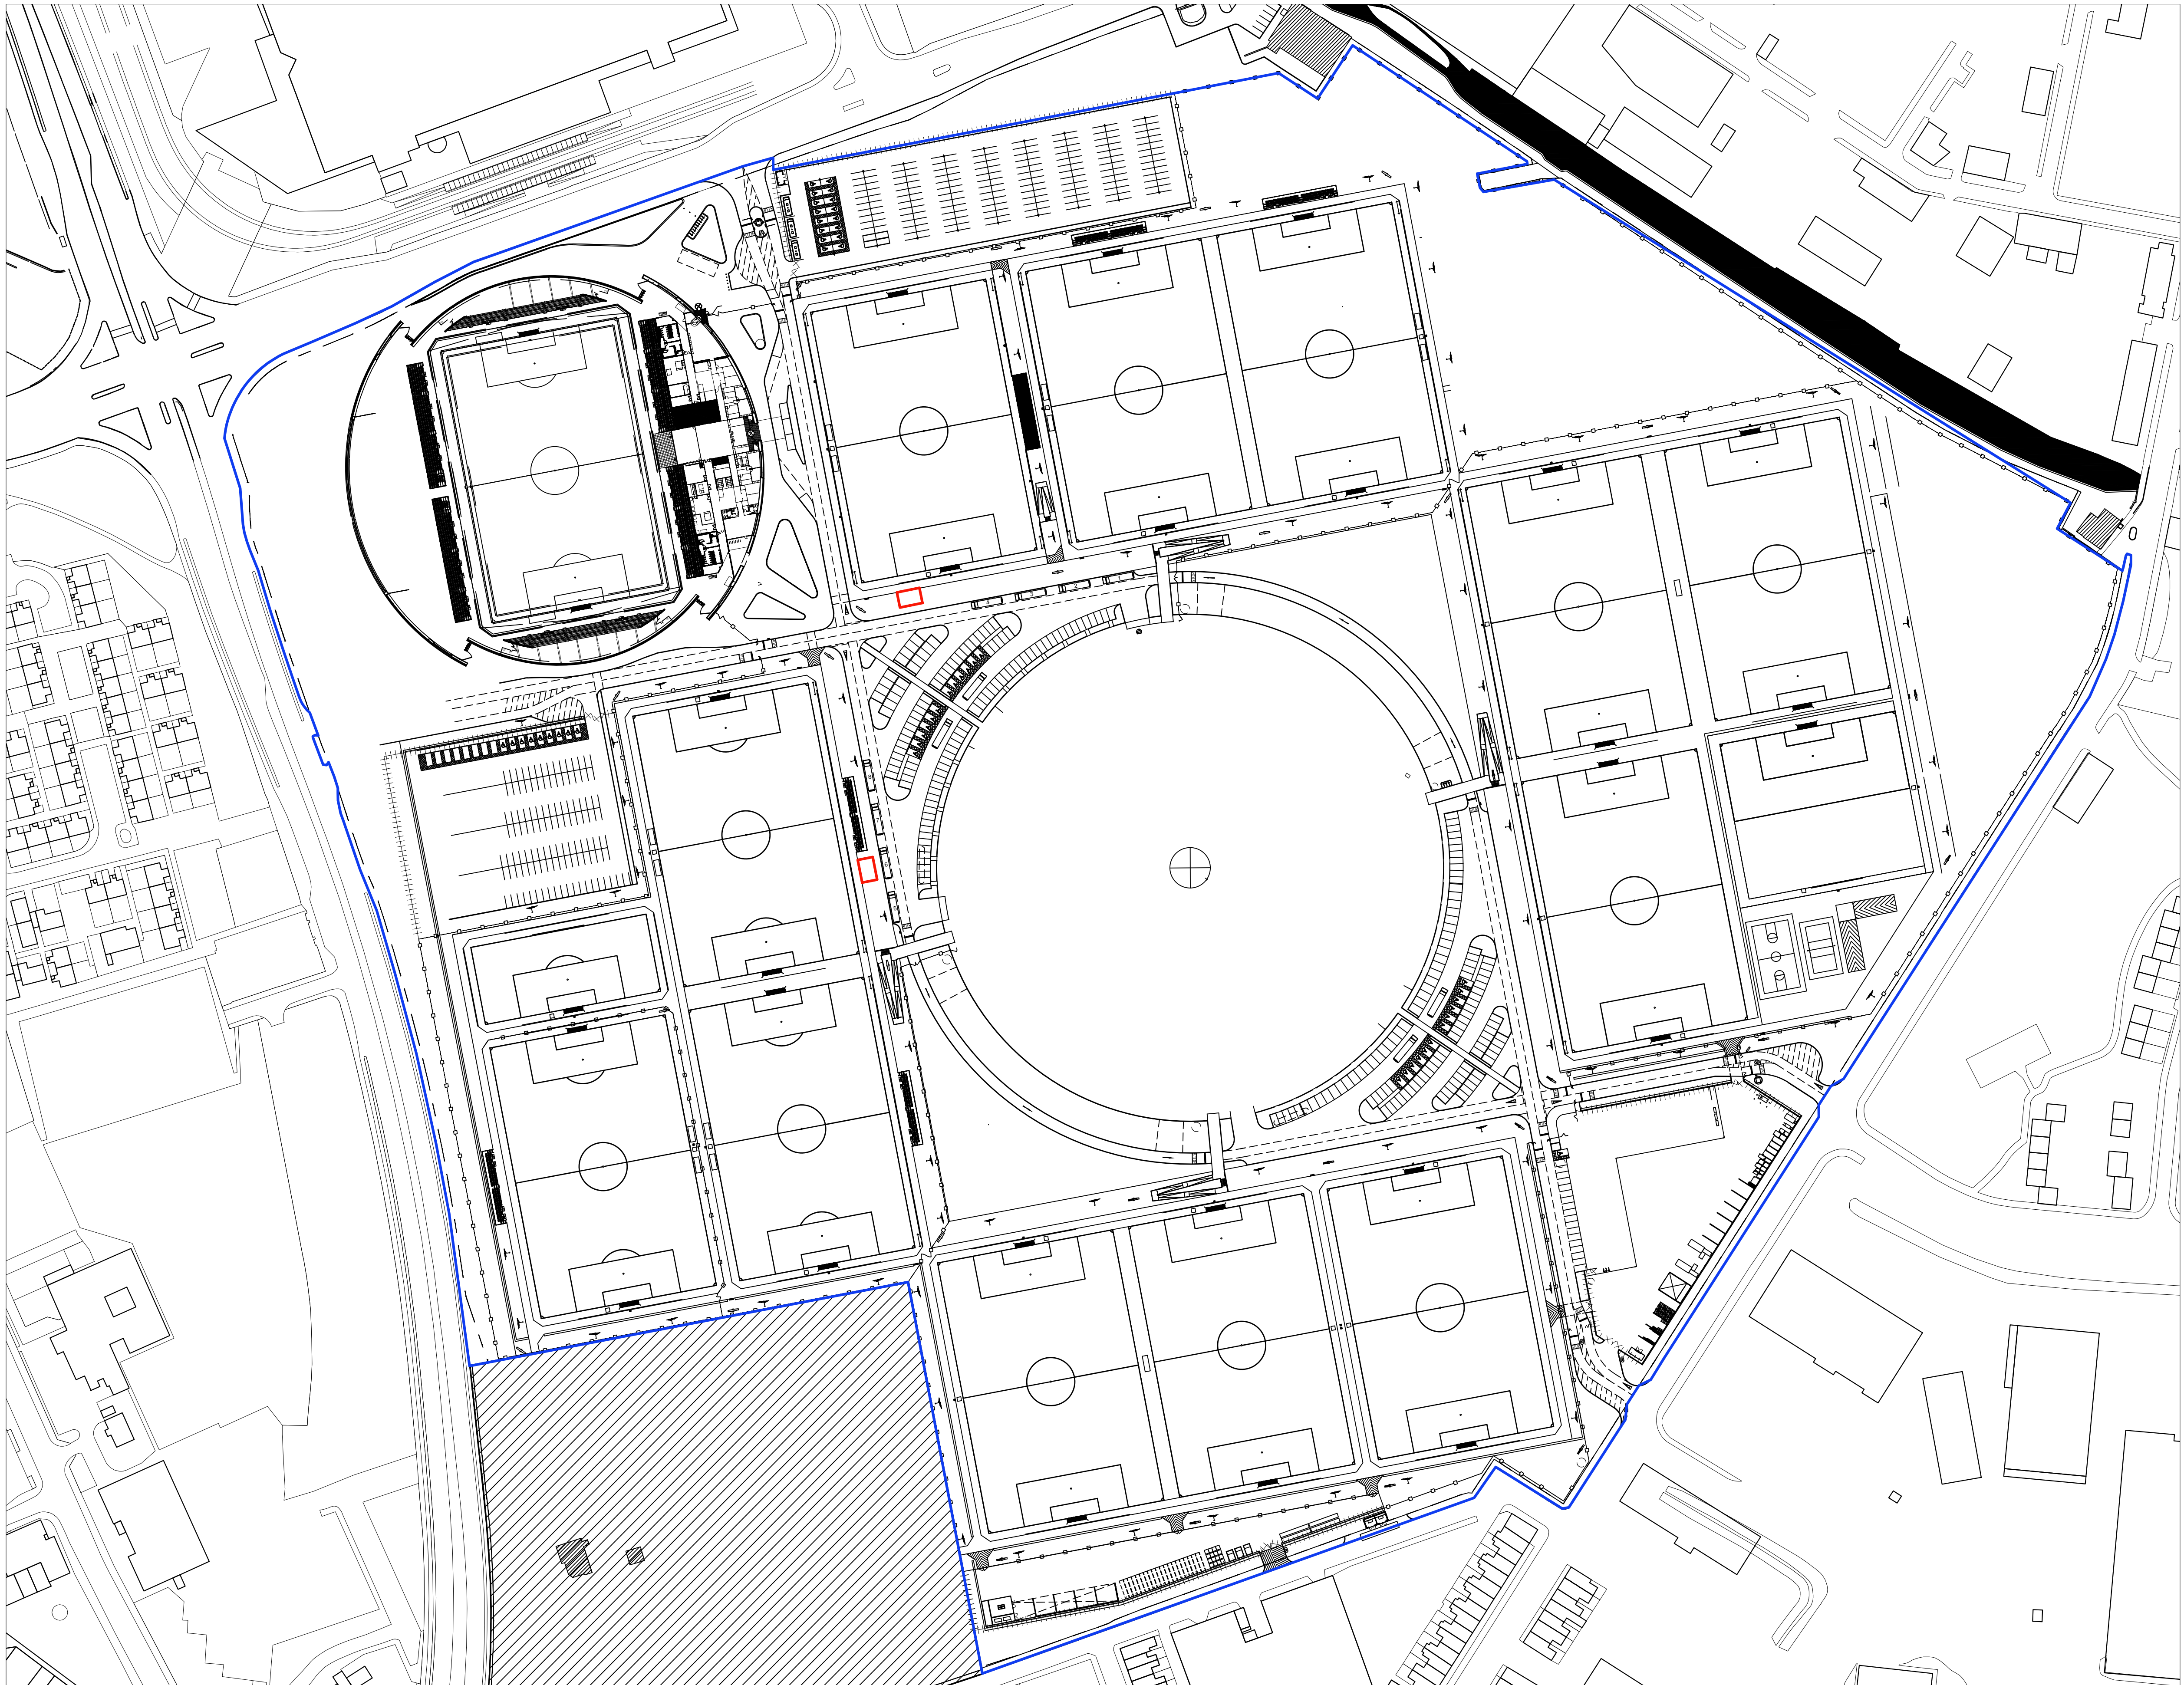

City Football Academy - Location Plan
scale 1:1250

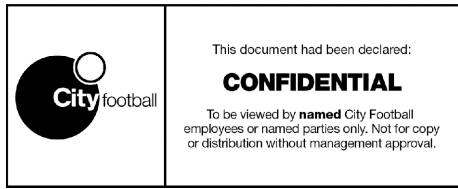

Project Title

CFA WC Blocks

Drawing Title

SITE PLAN
WC Block Locations

Drawn by:	Initials ID	Date 12/09/2023
Approved by:		

Scale 1:1250 @ A1	Revision 01
----------------------	----------------

Drawing code	Drawing number
CFA-WC	01

