


Notes


1. This drawing to be read in conjunction with all mechanical, electrical & public health drawings for this contract.
2. All services work to be carried out in accordance with the relevant Engineering Specification for this contract.

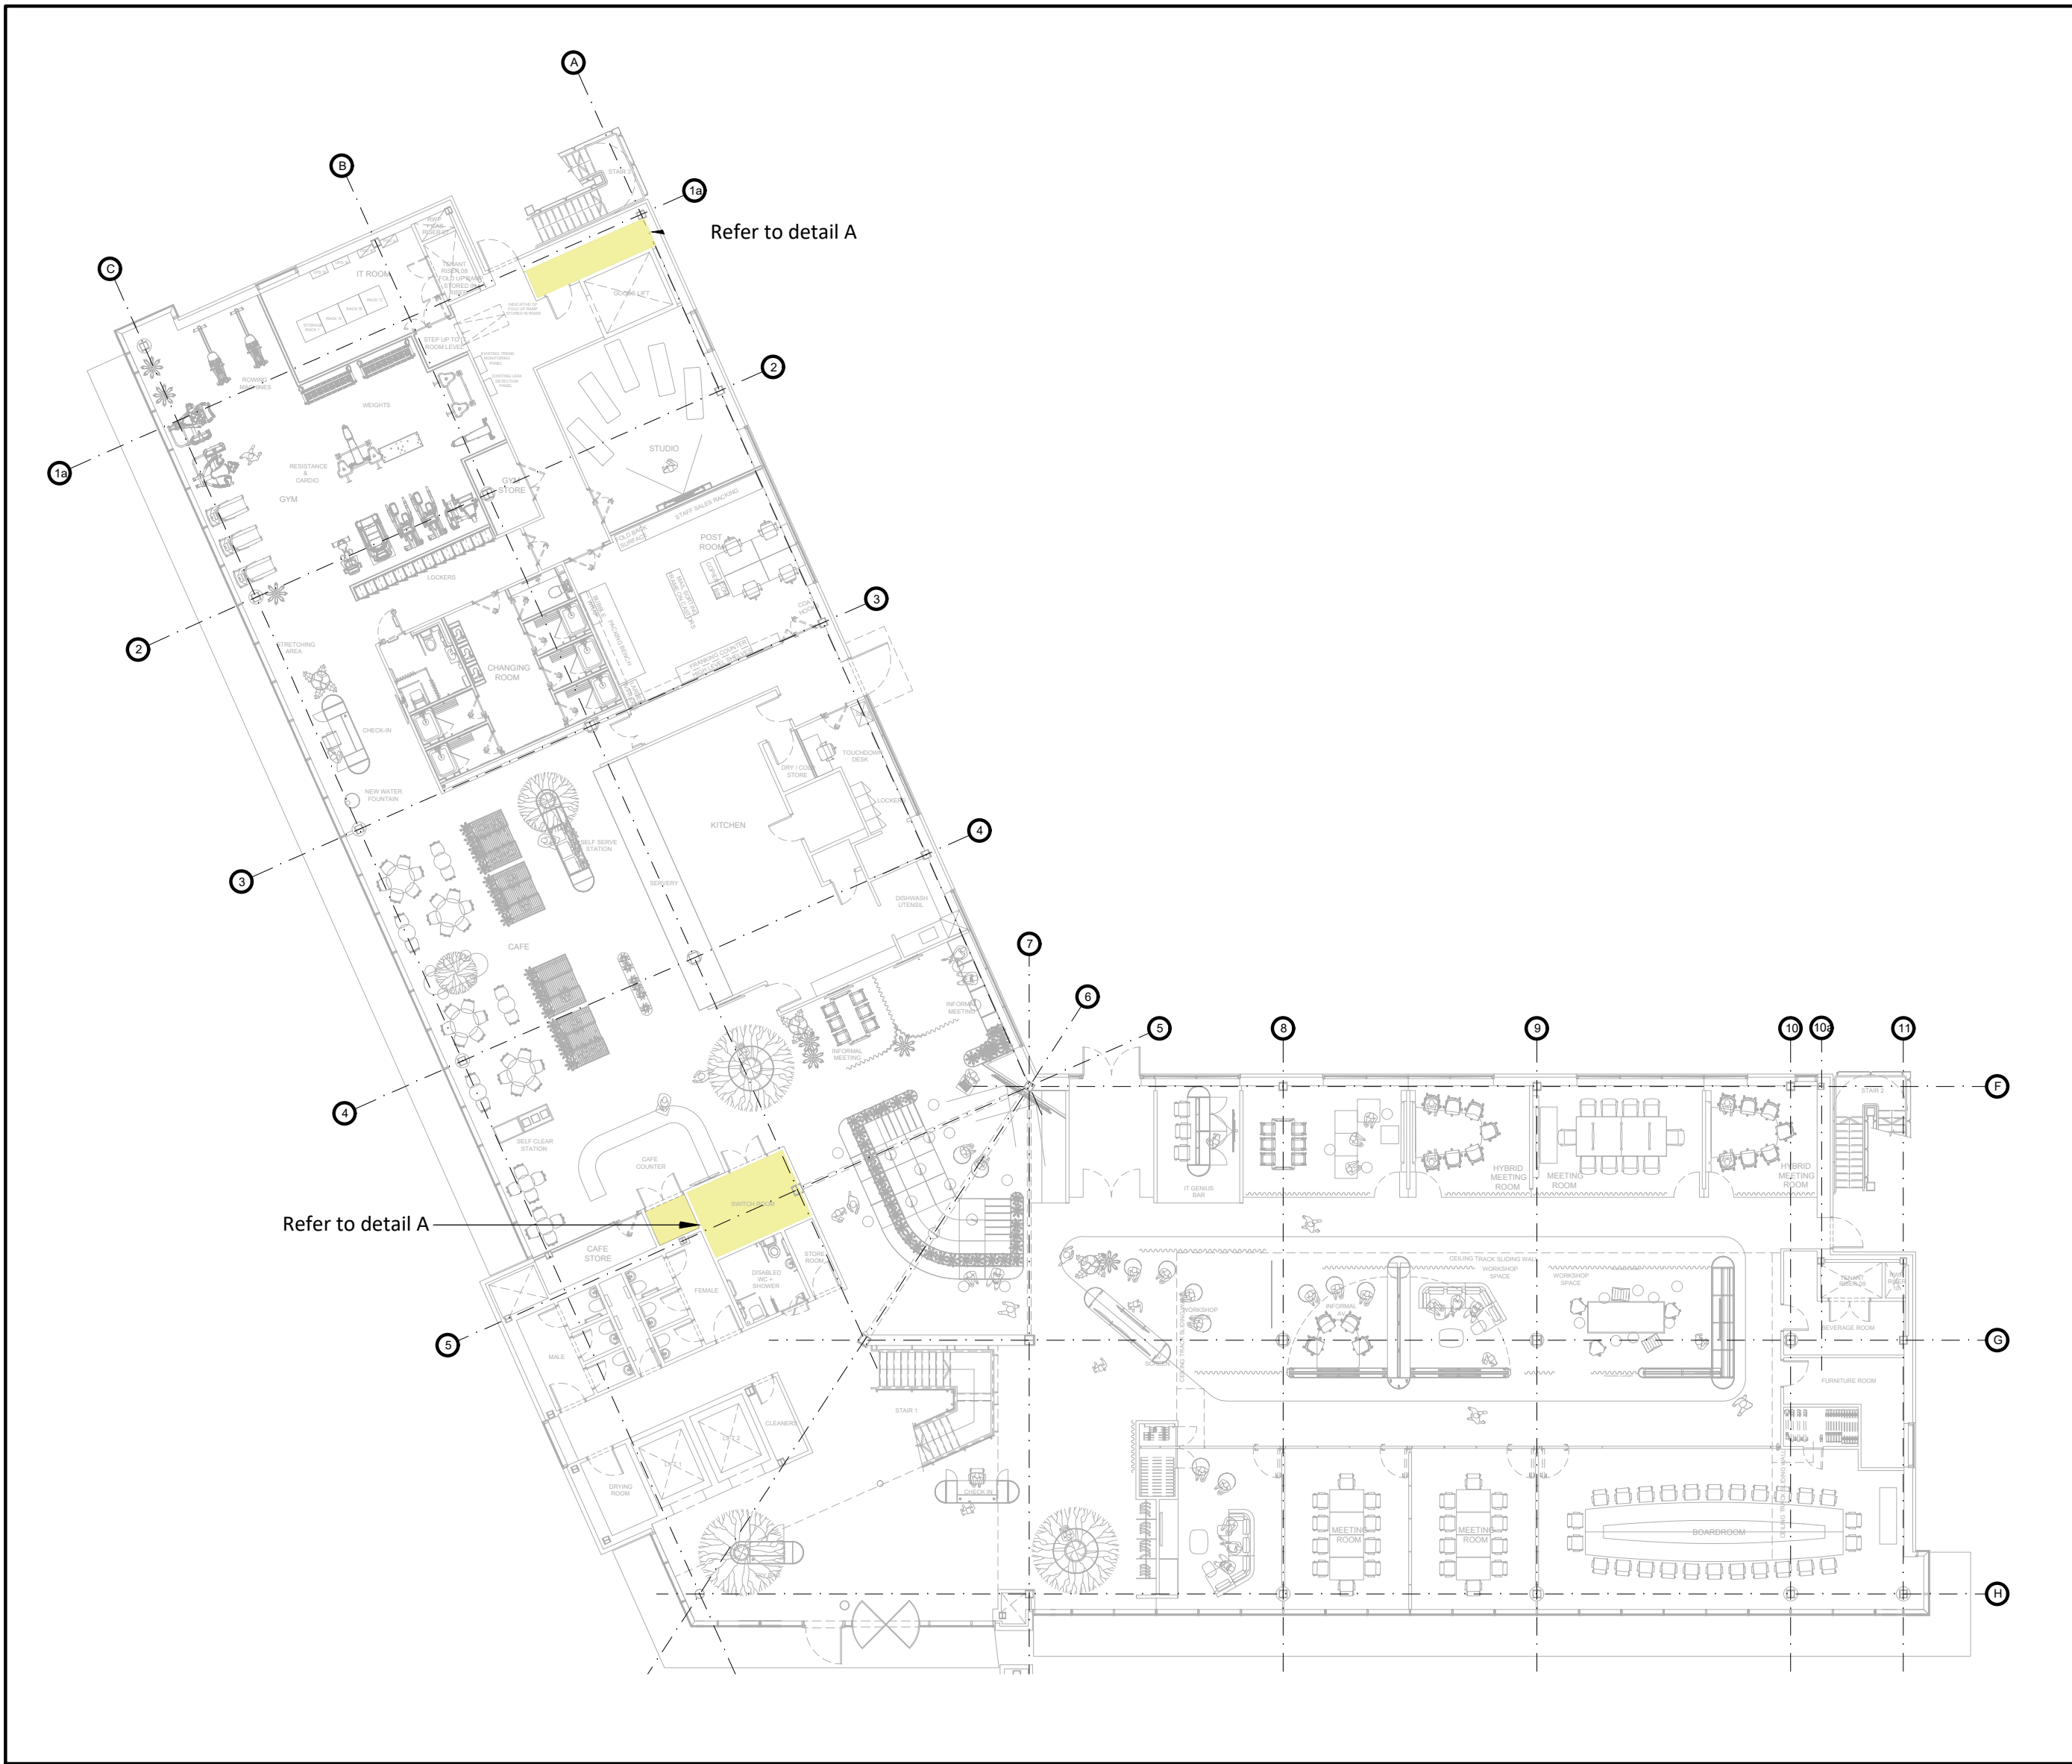

Ground Floor Plan
(1:200)



Existing electrical riser located on ground floor

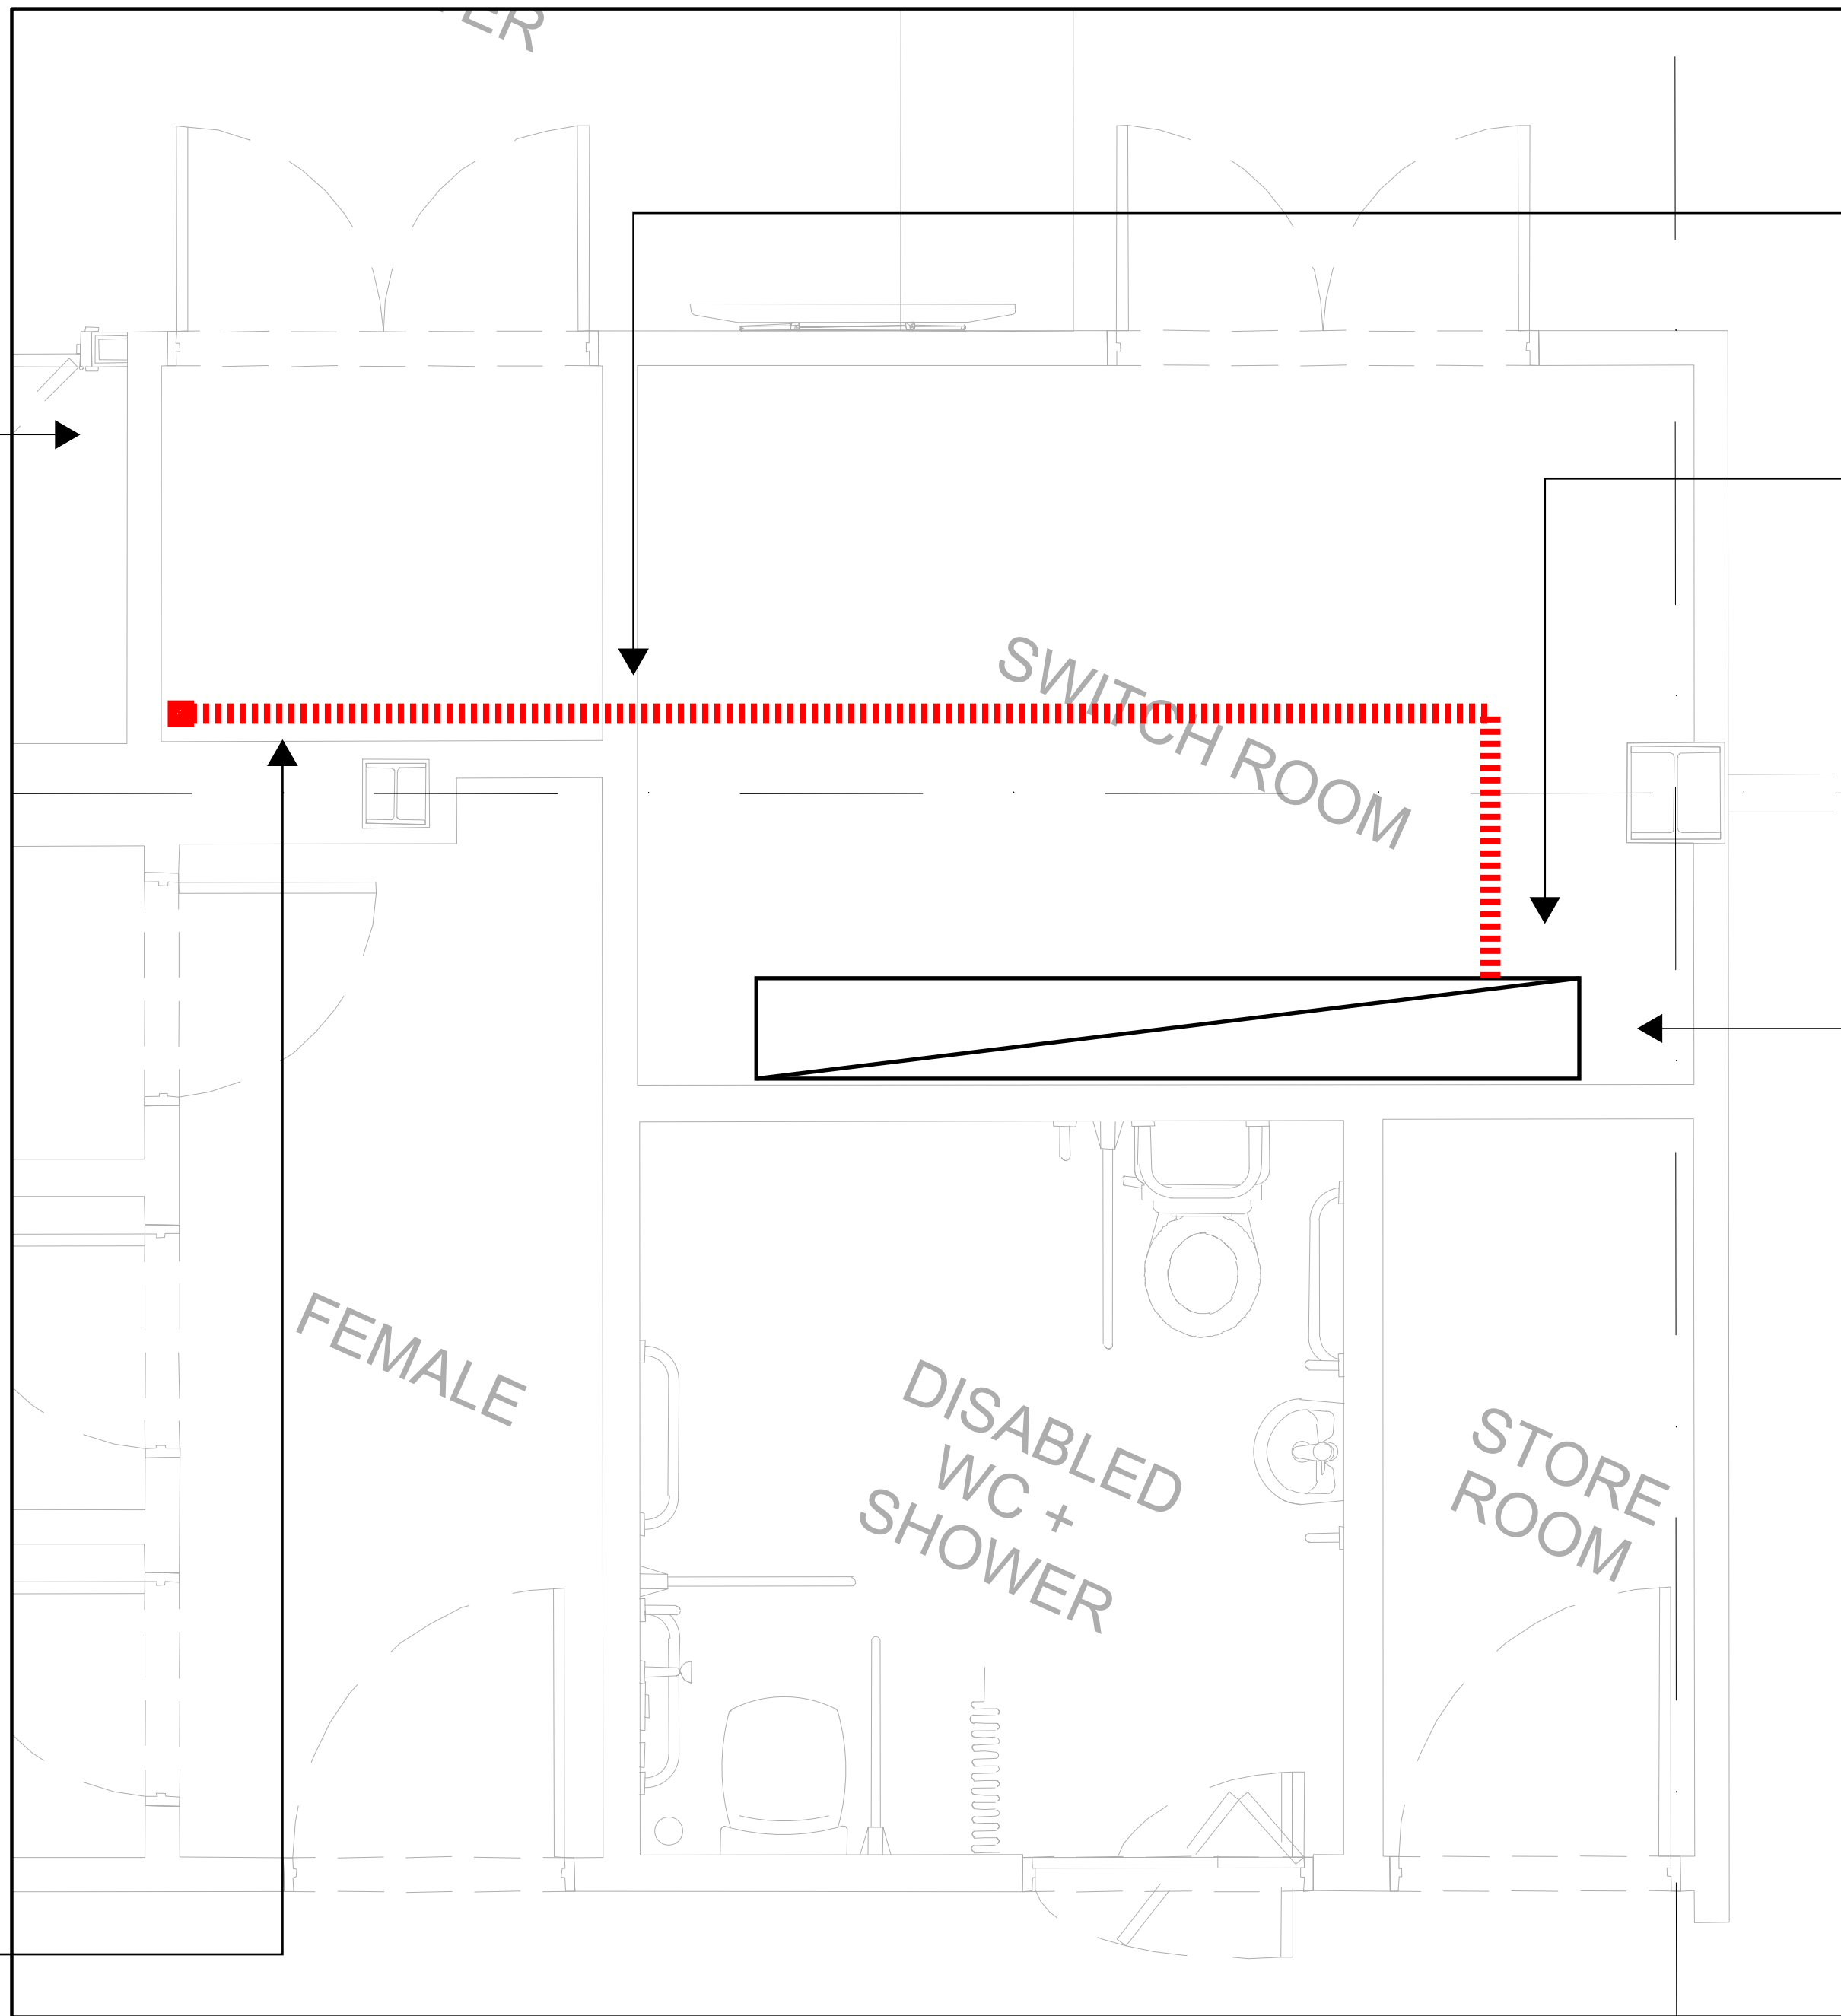

Detail A - Electrical Riser & Switchroom
(1:50)

Fire stopping required where containment penetrates riser.

Existing spare way to be utilised for new PV distribution board located in roof level plantroom.

For spare way refer to drawing:
30676-HML-XX-XX-DR-E-181001



Existing MSP located on ground floor

New 50mm wide medium duty galvanised steel cable for new sub-mains cabling supplying PV Distribution board located in trunking rising to roof level plant room.

P02	27/04/23	Contract Issue	MW	RF
P01	07/02/23	For Tender.	MW	RF
Revision	Date	Description	Drawn	Checked



hilsonmoran.com info@hilsonmoran.com

Client
PZ Cussons
Manchester Business Park
3500 Aviator Way
Manchester, M22 5TG

Project
PZ Cussons
Photovoltaics

Drawing Title
Electrical Services
Ground Floor
Small Power
General Arrangement

Scale	Sheet Size	Checked	Approved
As Stated	A0	RF	SR

Status
Hilson Moran Project No.

CONTRACT ISSUE 30676

Drawing No. Rev
30676-HML-XX-GR-DR-E-182001 P02