



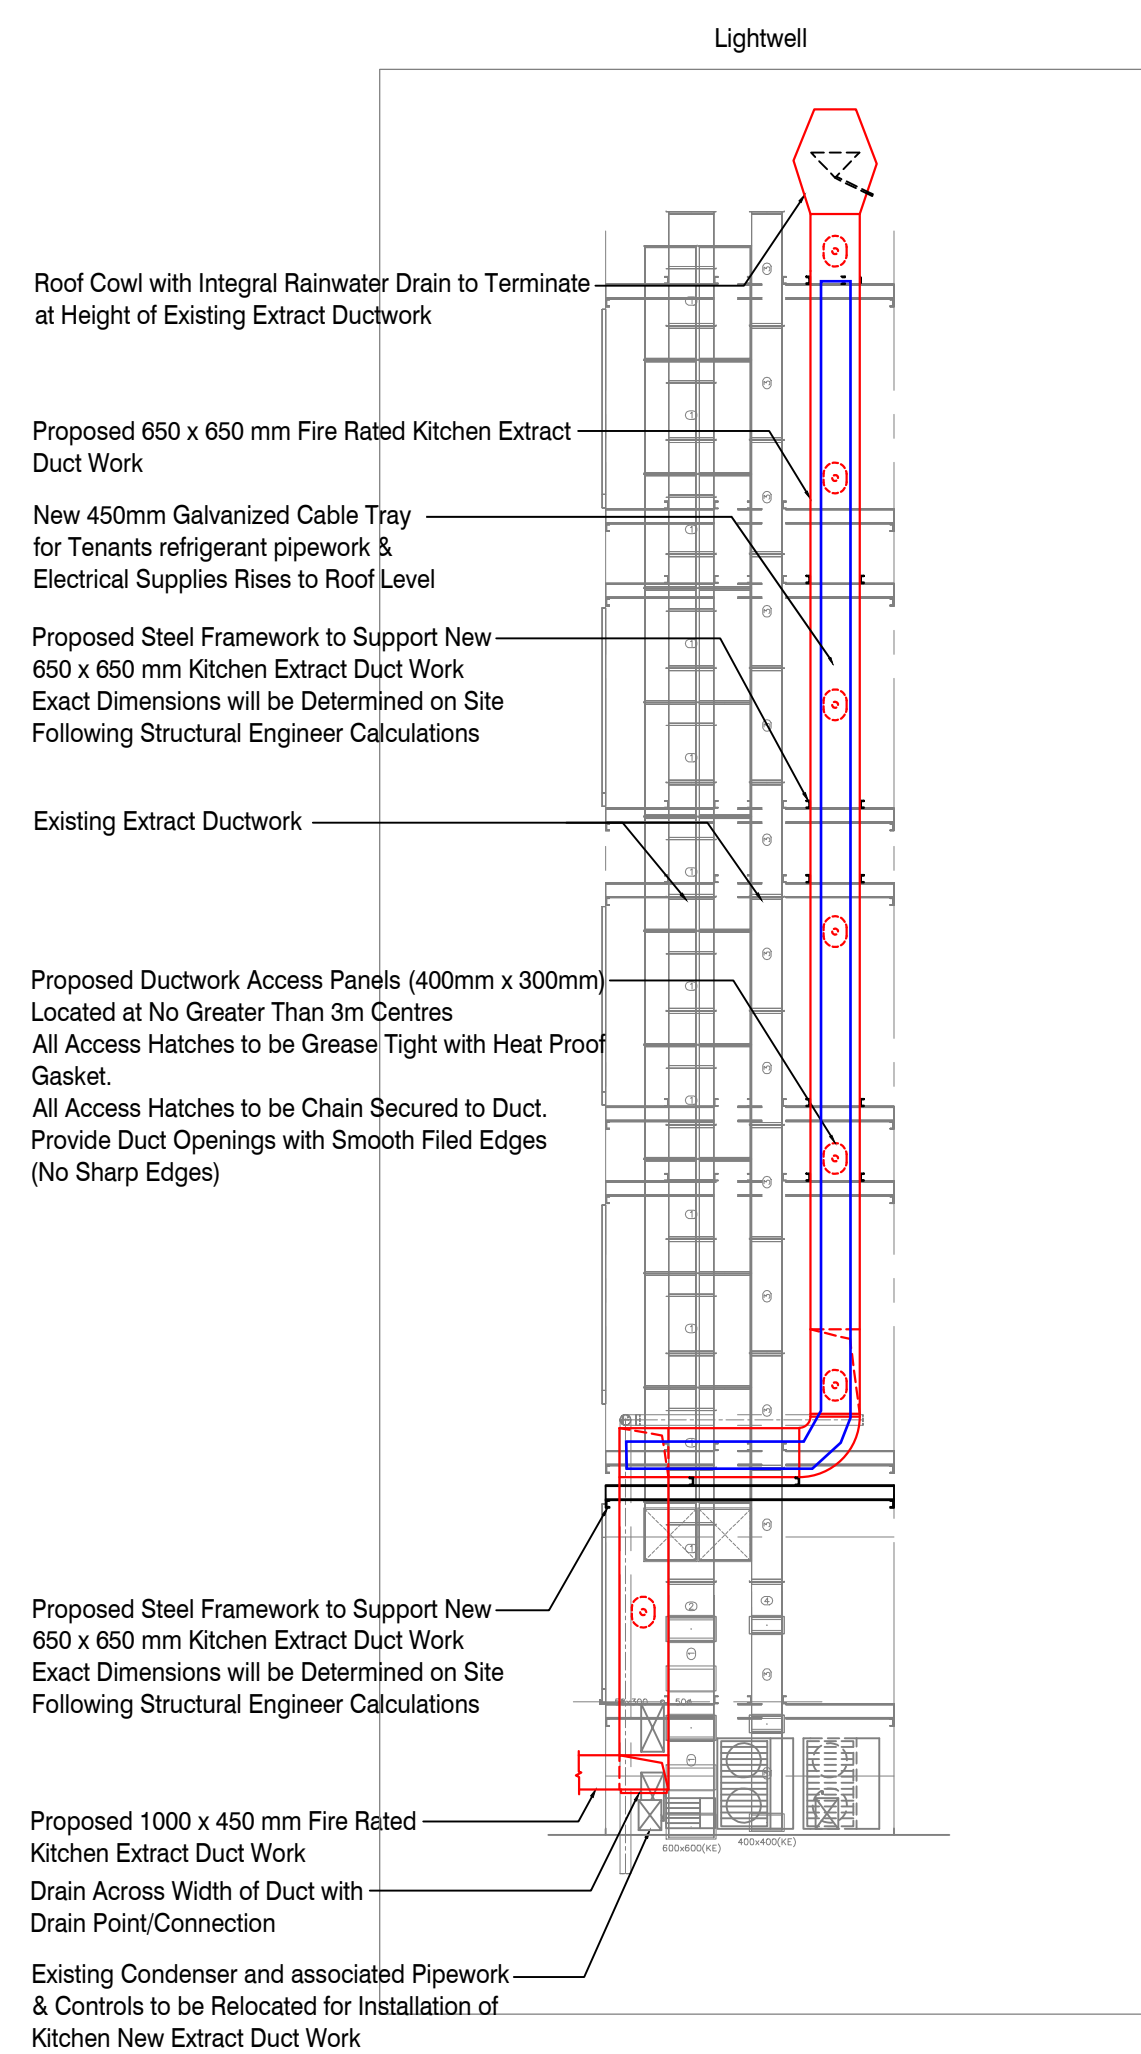

Section B-B (Front View) Existing View
Photograph 001

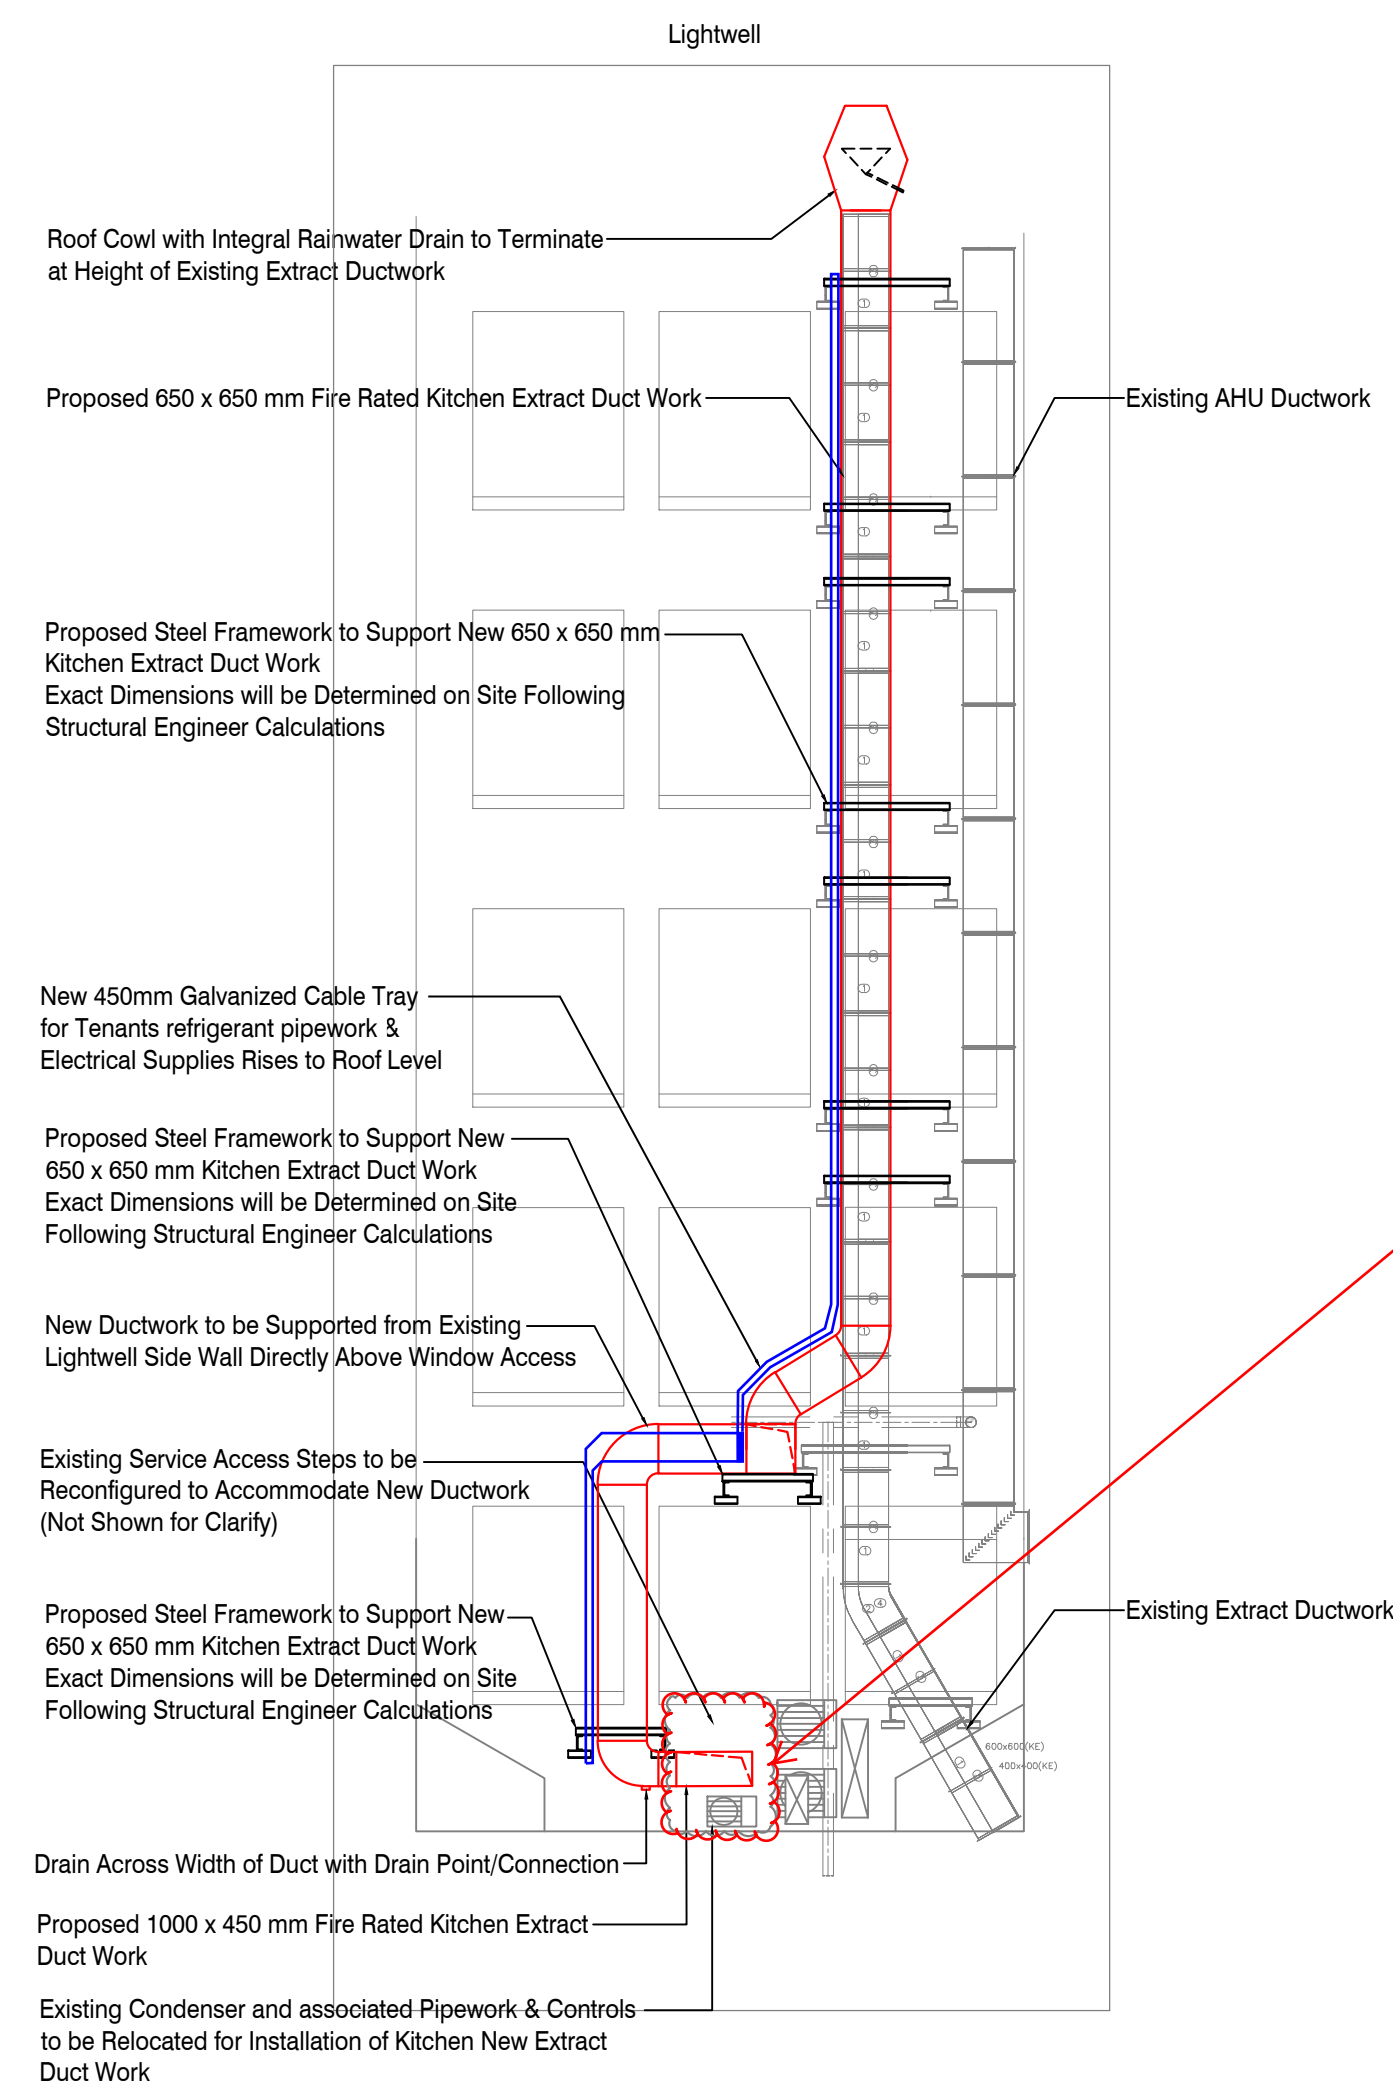


Section A-A (Side View)
Scale - 1:100



Section A-A (Side View) Existing View
Photograph 002

Indicative location of Penetration 2 1000 x 450mm through brickwork from ground floor reception ceiling void

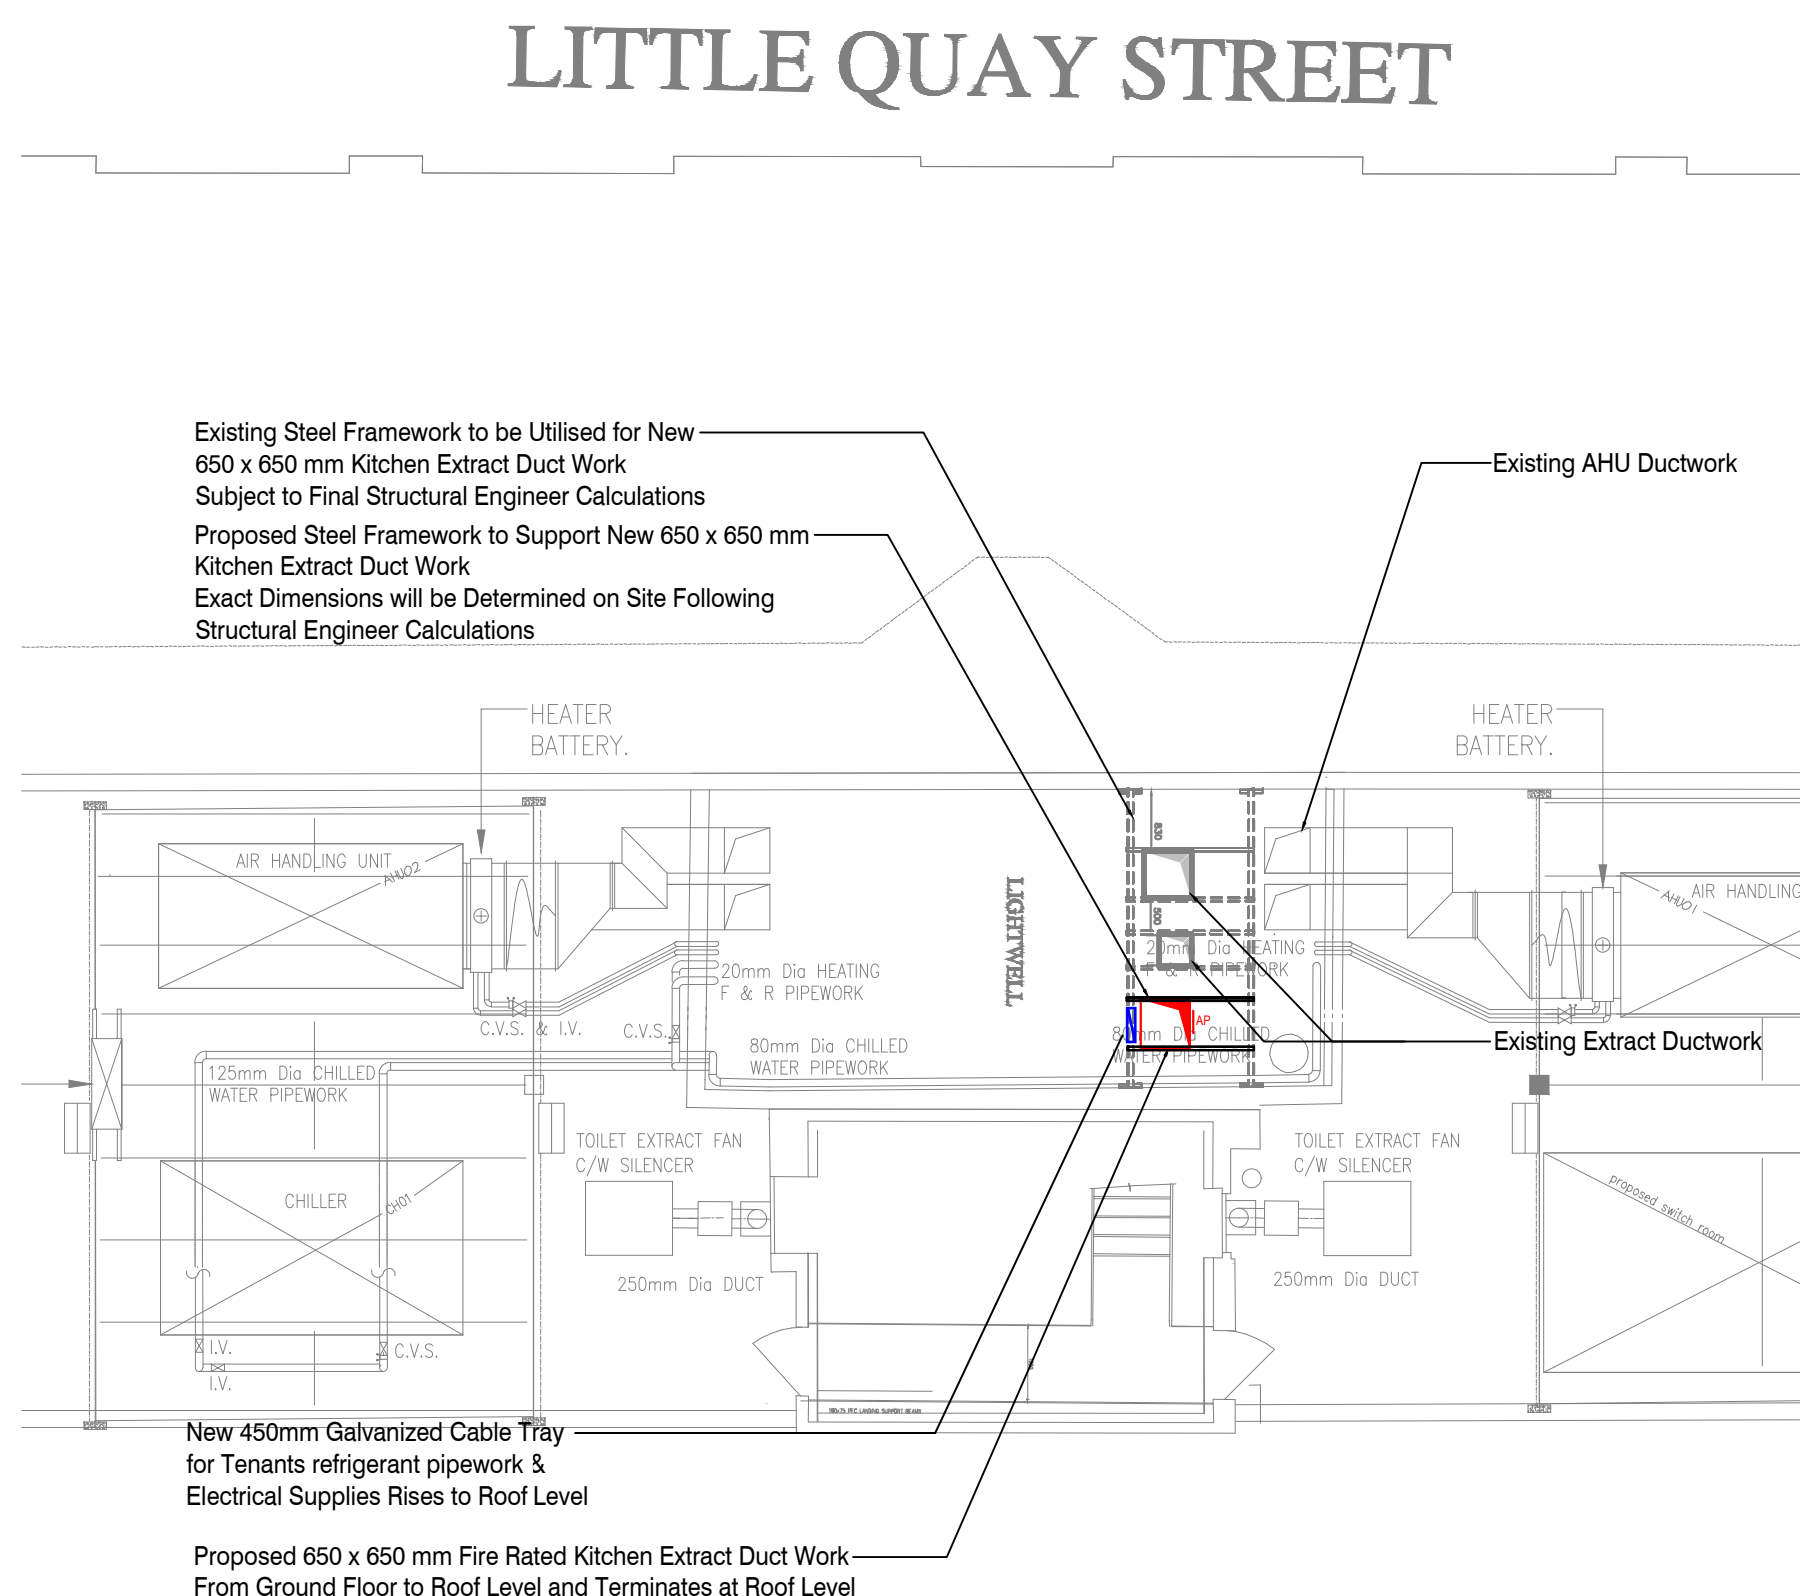

Roof Plan
Scale - 1:100



Roof Existing View
Photograph 003

			
JOB DESCRIPTION 200-204 DEANSGATE, MANCHESTER			
TITLE: Kitchen Extract Ventilation System Extract Route Drawing			
AREA: .		SCALE: NTS	
DRN. & DATE PMG 07/AUGUST/2023			
CHKD: AF 07/AUGUST/2023			SIZE -
DRG. No. CEG/EXTRACT/01			REV: