


Fire escape route



Proposed Brewers weather station equipment to be relocated to the Schuster Building roof.

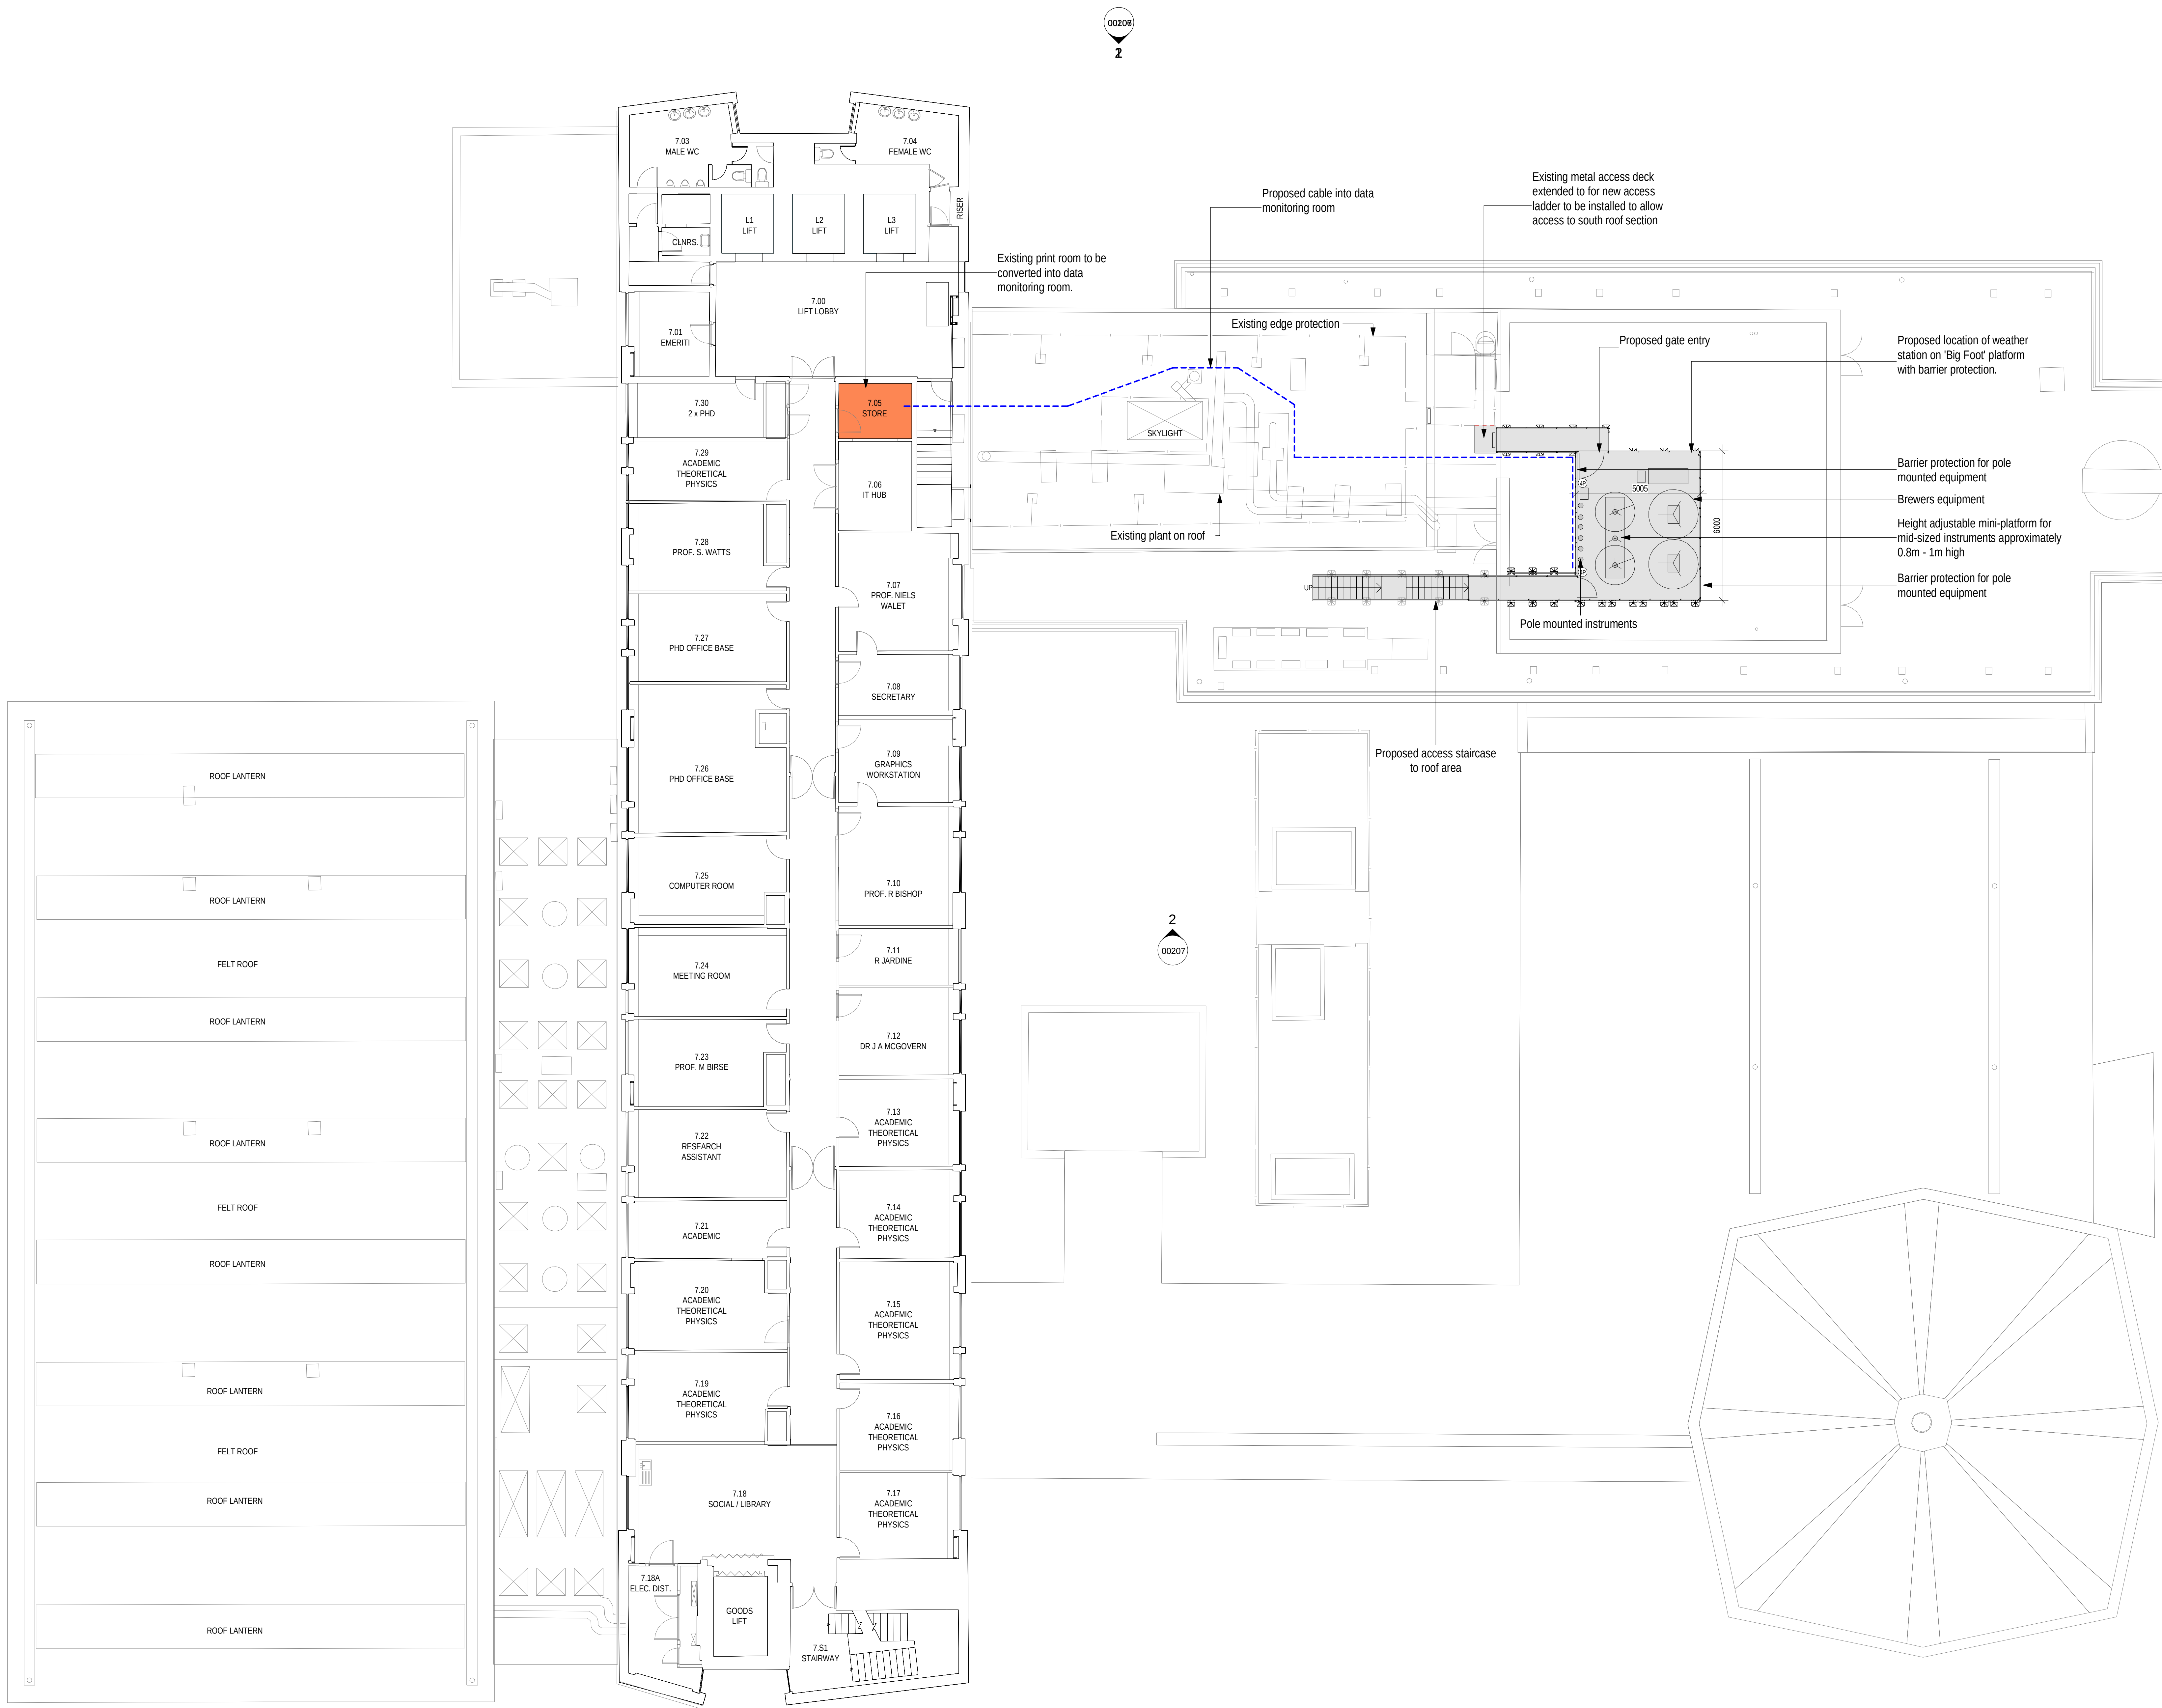

1 Level 7 Proposed
1:100 @ A1

P1	Issued for Planning	30.06.2023	SA	GW
PLANNING				
Revision	Description	Date	Drawn	Checked
Halliday Meecham Architects Limited				
111 Piccadilly Manchester M1 2HY +44 (0)161 661 5566				
4 Devonshire Street London W1W 5DT +44 (0)203 440 5175				
hma@hallidaymeecham.com www.hallidaymeecham.com				
Client: University of Manchester				
Project: Schuster Weather Station				
Phase/ Location: Schuster Building, Brunswick Street, Manchester, M13 9PL				
Drawing: Proposed 7th Floor Plan				
Scale @ A0	Scale @ A3	Date	Drawn	Checked
MIS	30.06.2023	SA	GW	5654
Job No. 5654				Drawing No. 00203
Drawing Ref. 5654-HMA-SB-L7-DR-A-00203				Revision P1