

NOTES
All dimensions and levels to be checked on site
Any discrepancies are to be reported to the Architect before any work commences
This drawing shall not be scaled to ascertain any dimensions, work to figured dimensions only
This drawing shall not be reproduced without express written permission from AFL Architects Ltd.

DISCLAIMER
When this drawing is issued in CAD, it is an uncontrolled version issued for information only, to enable the recipient to prepare their own documents/drawings for which they are solely responsible.

SOFTWARE INTEROPERABILITY
AFL prepared this drawing using Autodesk REVIT Architecture.
AFL does not accept liability for any loss or degradation of any information held in the drawing resulting from the translation from the original file format to any other file format or from the recipients reading of it in any other programme.

T1	04.08.23	JG	Tender Issue
P5	06.07.23	JG	Issued for approval.
P4	19.05.23	AS/JG	Stage 3 Issue
P3	10.05.23	AS	Draft Issue for Stage 3 co-ordination
P2	14.02.23	AS	Stage 2 initial Issue
P1	06.02.23	AS	First Issue, Draft

rev no.	rev date	rev by	description
project			

National Breast Imaging Academy

location

Wythenshawe Hospital

Employer

client

Manchester University NHS Foundation Trust

AFL Architects
1st Floor
St Georges House
56 Peter Street
Manchester M2 3NQ

t: +44(0)161 236 6263
f: +44(0)161 236 6484

w: www.afl-architects.com
e: mail@afl-uk.com

twitter.com/AFLArchitects

key plan




drawing title

Proposed Roof Layout

AFL job number	scale @ A1	drawn AS	checked MM
223196		rev date	04.08.23

draw purpose	status	rev
Information		T1

bim project origin zone level type role 5-digit no.
BIA-AFL-01-01-DR-A-20102

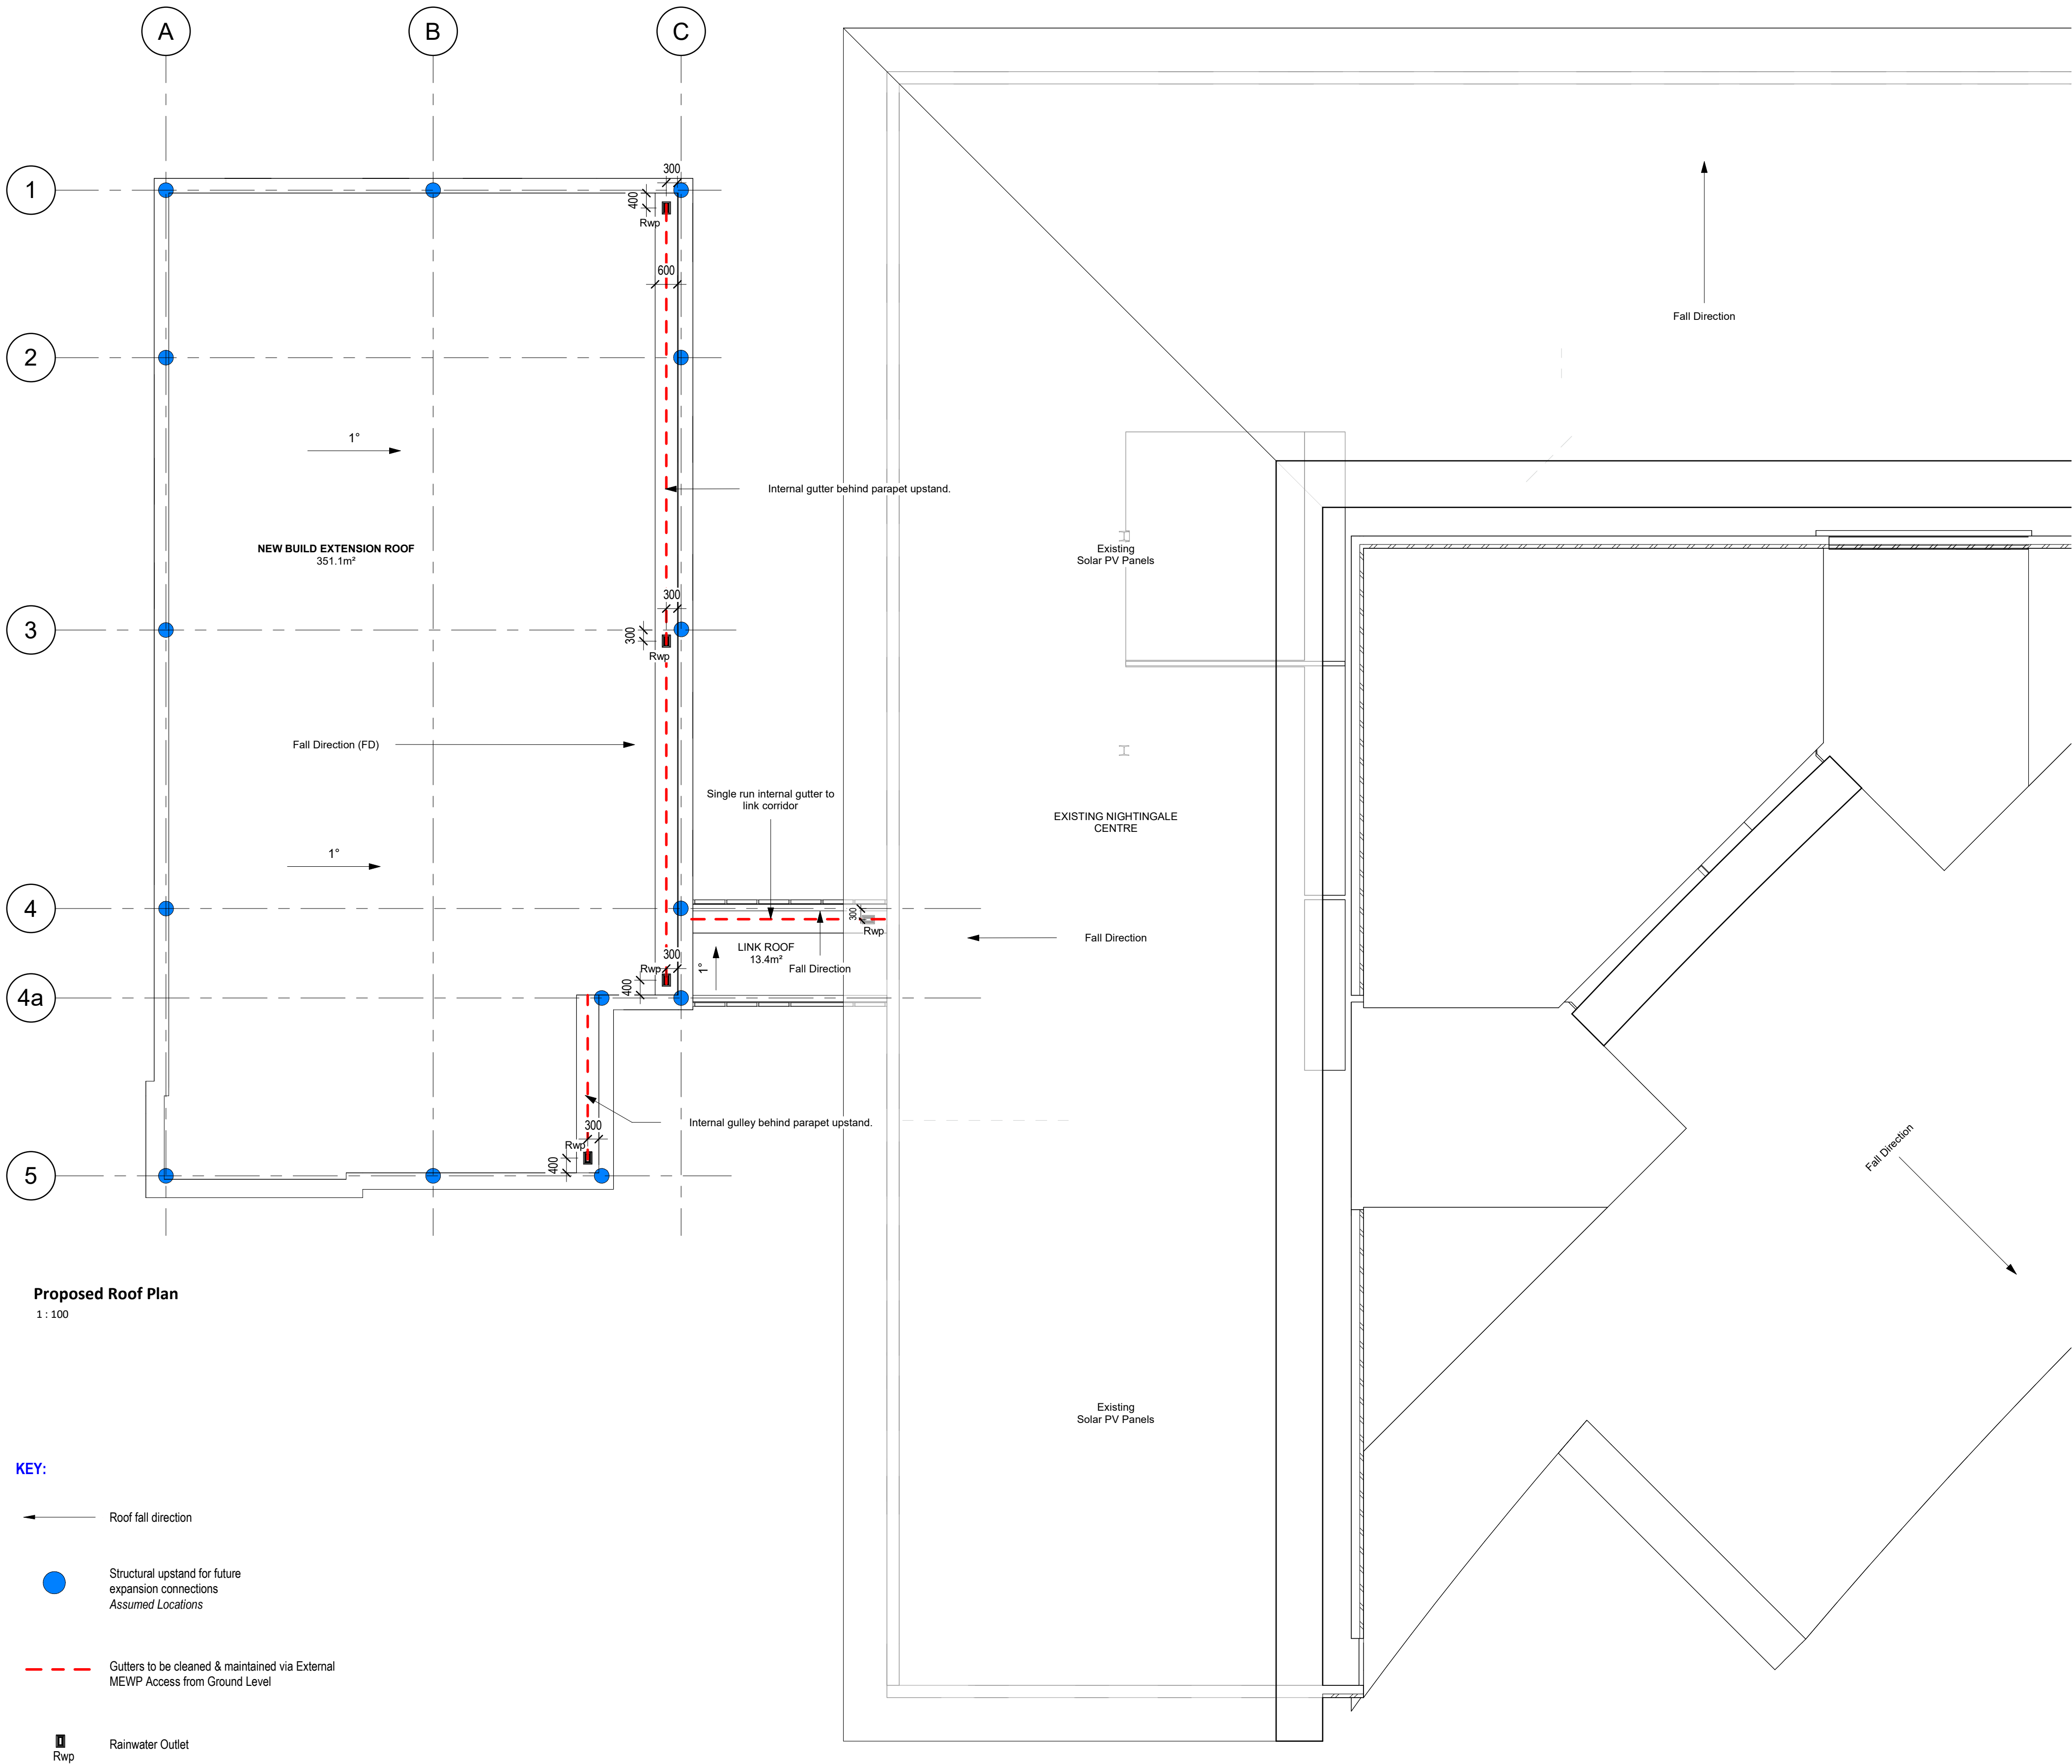

Proposed Roof Plan
1:100

KEY:

- Roof fall direction
- Structural upstand for future expansion connections
Assumed Locations
- Gutters to be cleaned & maintained via External MEWP Access from Ground Level
- Rwp Rainwater Outlet