


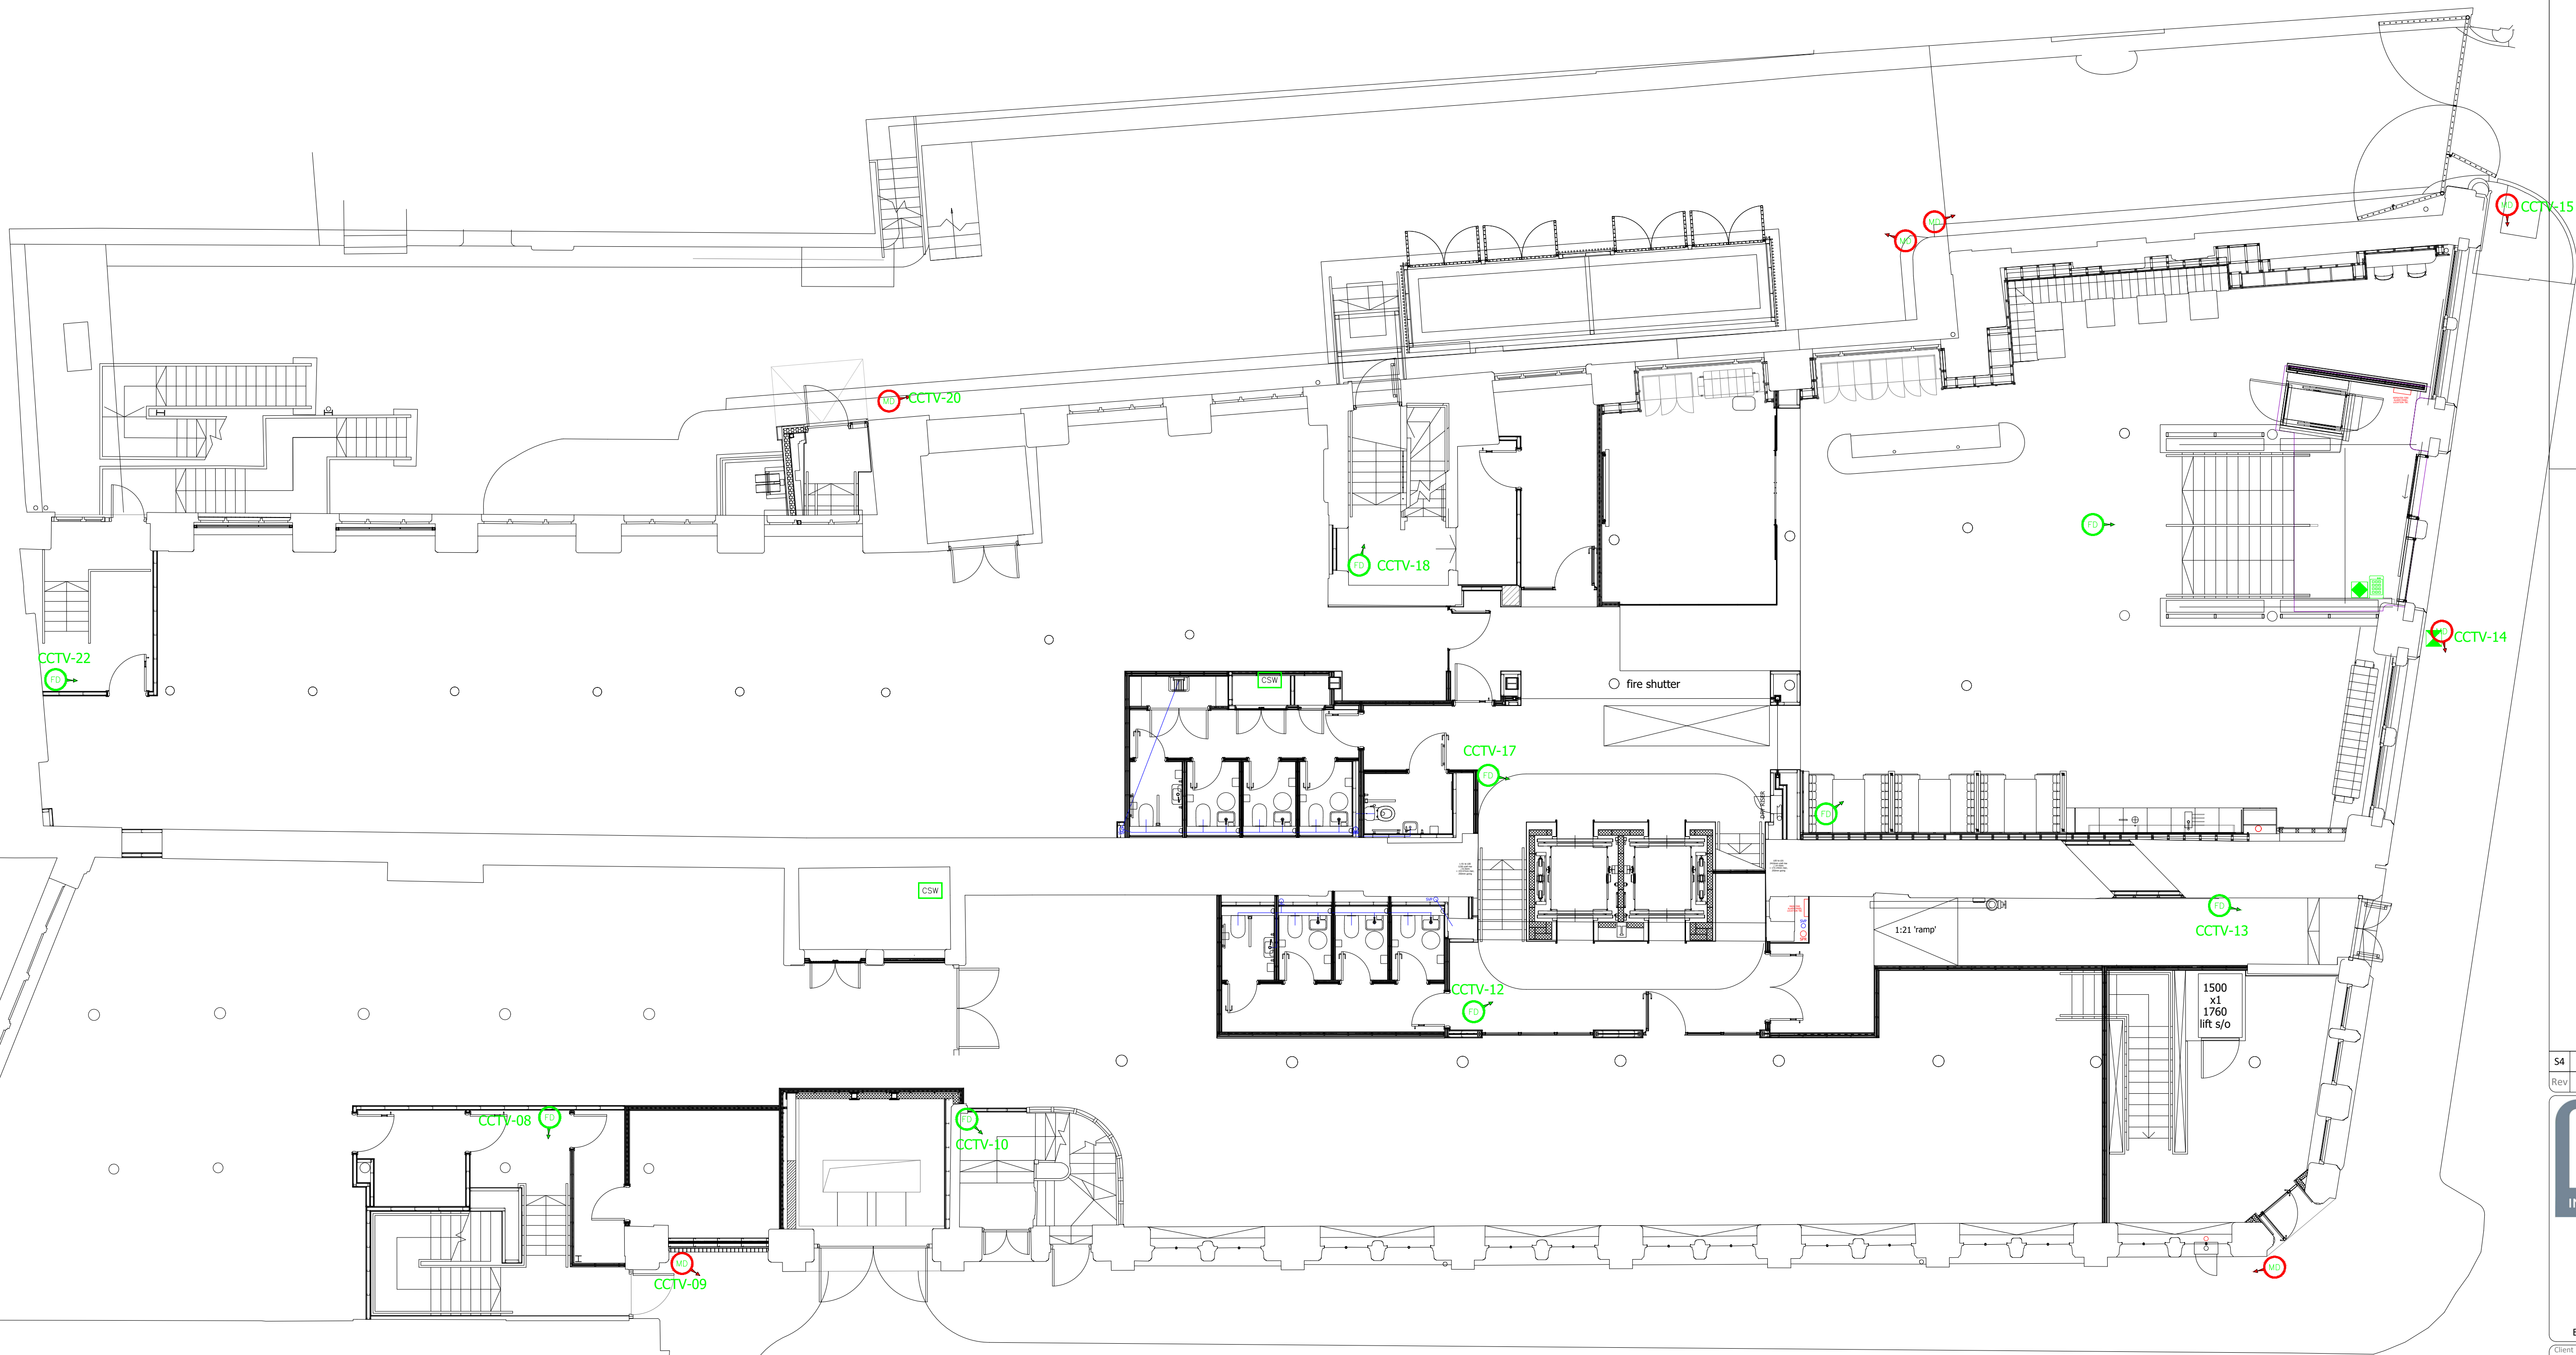

- MONITOR
- DIGITAL RECORDER
- INTERNAL FIXED DOME CAMERA
- INTERNAL FIXED DOME CAMERA

S4	STAGE 4	04/04/22
Rev	Amendment	Date



HEAD OFFICE
KEY INTEGRATED SERVICES LTD
UNIT 2 BOLLIN COURT
MILL LANE
LYMM
CHESHIRE
WA13 9SX
T: 01925 759948 F: 01925 758400
E: info@keyis.com W: www.keyis.com

Client
CUBIC WORKS

Project Title
40 PRINCESS STREET
MANCHESTER

Drawing Title
-01 & 00 FLOOR
CCTV LAYOUT

Drawn By CM	Checked By	Designed By	Scale @ A1 1:100
----------------	------------	-------------	---------------------

B51192 Document Number C1150-KEY-XX-DR-E-69-003	RIBA Stage STAGE 4
--	-----------------------

Status STAGE 4	Revision S4
-------------------	----------------

THIS DRAWING IS THE COPYRIGHT© OF KEY IS.
IT MUST NOT BE REPRODUCED OR USED FOR ANY PURPOSE WITHOUT PRIOR
CONSENT. DO NOT SCALE FROM THIS DRAWING. WORK TO FIGURED DIMENSIONS
ONLY. ALL DIMENSIONS ARE IN MILLIMETRES UNLESS STATED OTHERWISE. THIS
DRAWING SHALL BE READ IN CONJUNCTION WITH ALL OTHER MECHANICAL,
ELECTRICAL & PUBLIC HEALTH DRAWINGS, SPECIFICATIONS AND SCHEDULES.