

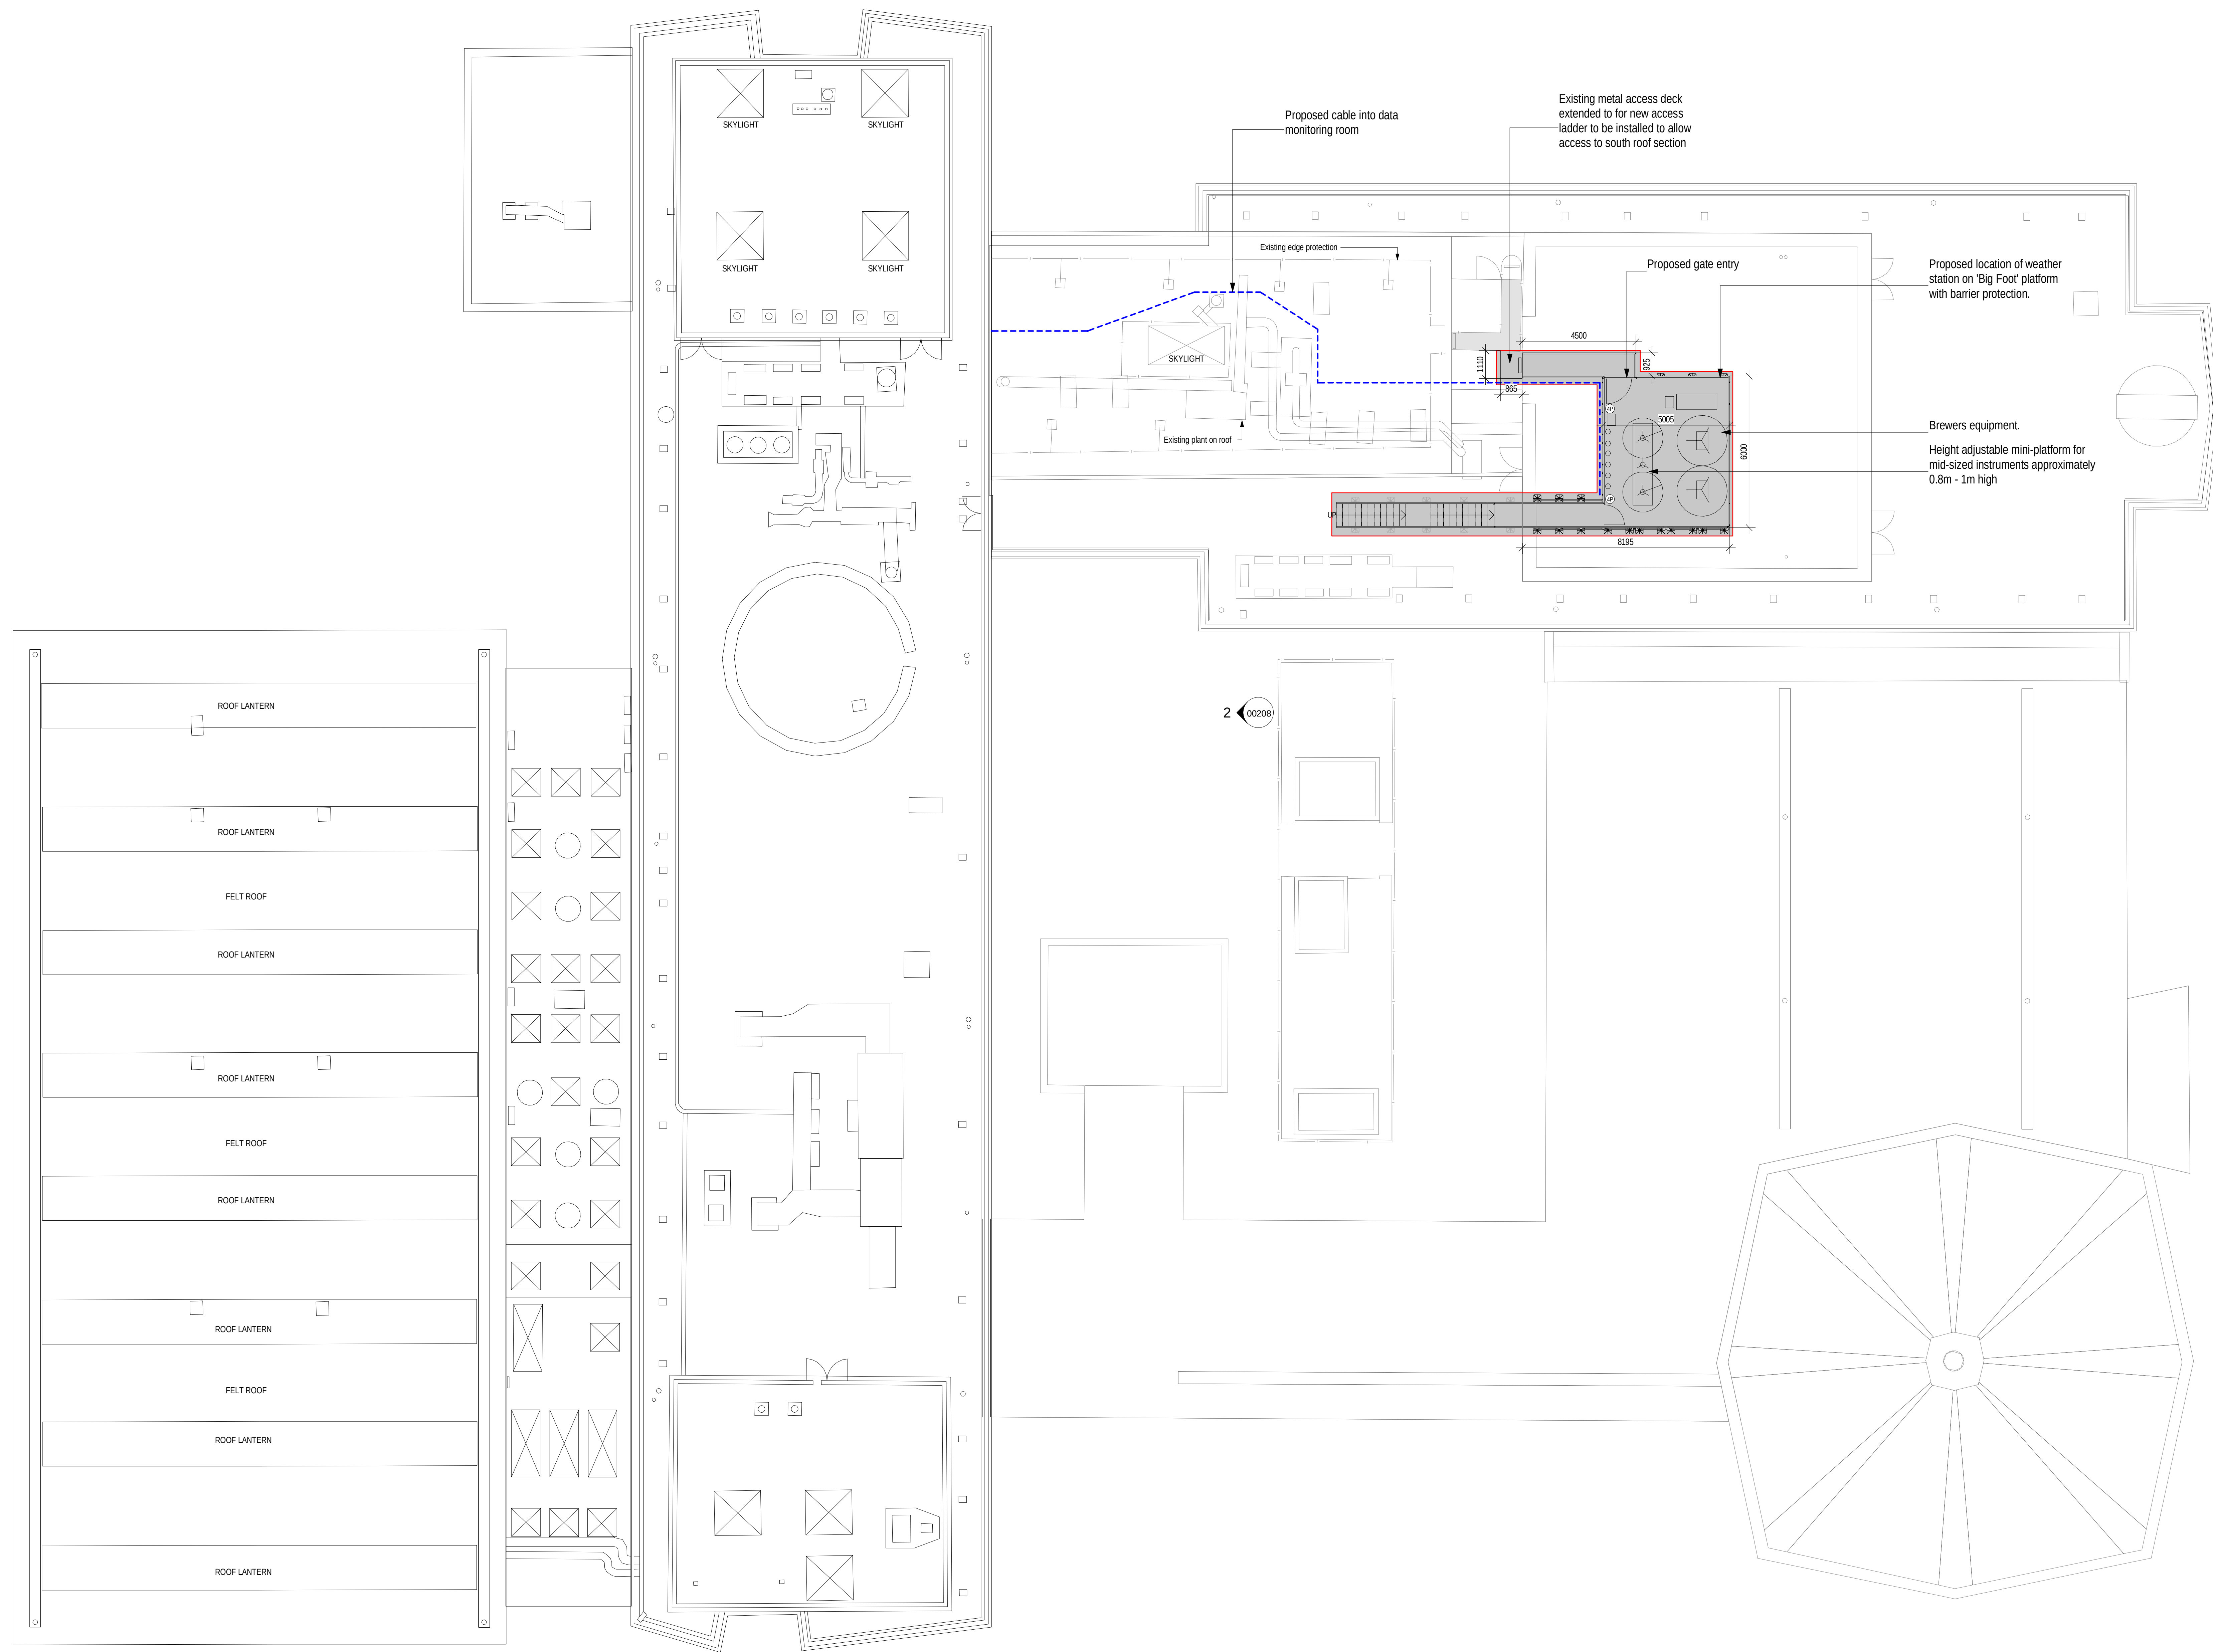


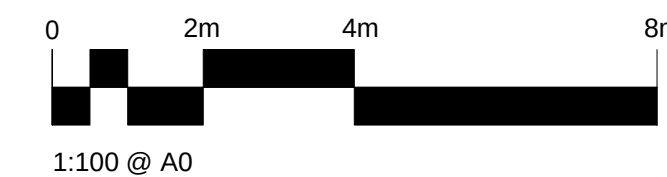

1 Roof Plan Proposed
1: 100 @ A1

P1	Issued for Planning	30.06.2023	SA	GW
PLANNING				
Revision	Description	Date	Drawn	Checked
Halliday Meecham Architects Limited				
111 Piccadilly Manchester M1 2HY +44 (0)161 661 5566				
4 Devonshire Street London W1W 5DT +44 (0)203 440 5175				
hma@hallidaymeecham.com www.hallidaymeecham.com				
Client: University of Manchester				
Project: Schuster Weather Station				
Phase/ Location: Schuster Building, Brunswick Street, Manchester, M13 9PL				
Drawing: Proposed Roof Plan				
Scale @ A0	Scale @ A3	Date	Drawn	Checked
1:100	M1S	30.06.2023	SA	GW
Job No.	5654	Drawing No.	00204	Revision
5654-HMA-SB-RL-DR-A-00204	P1			

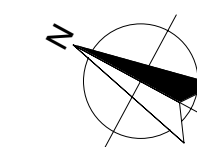