



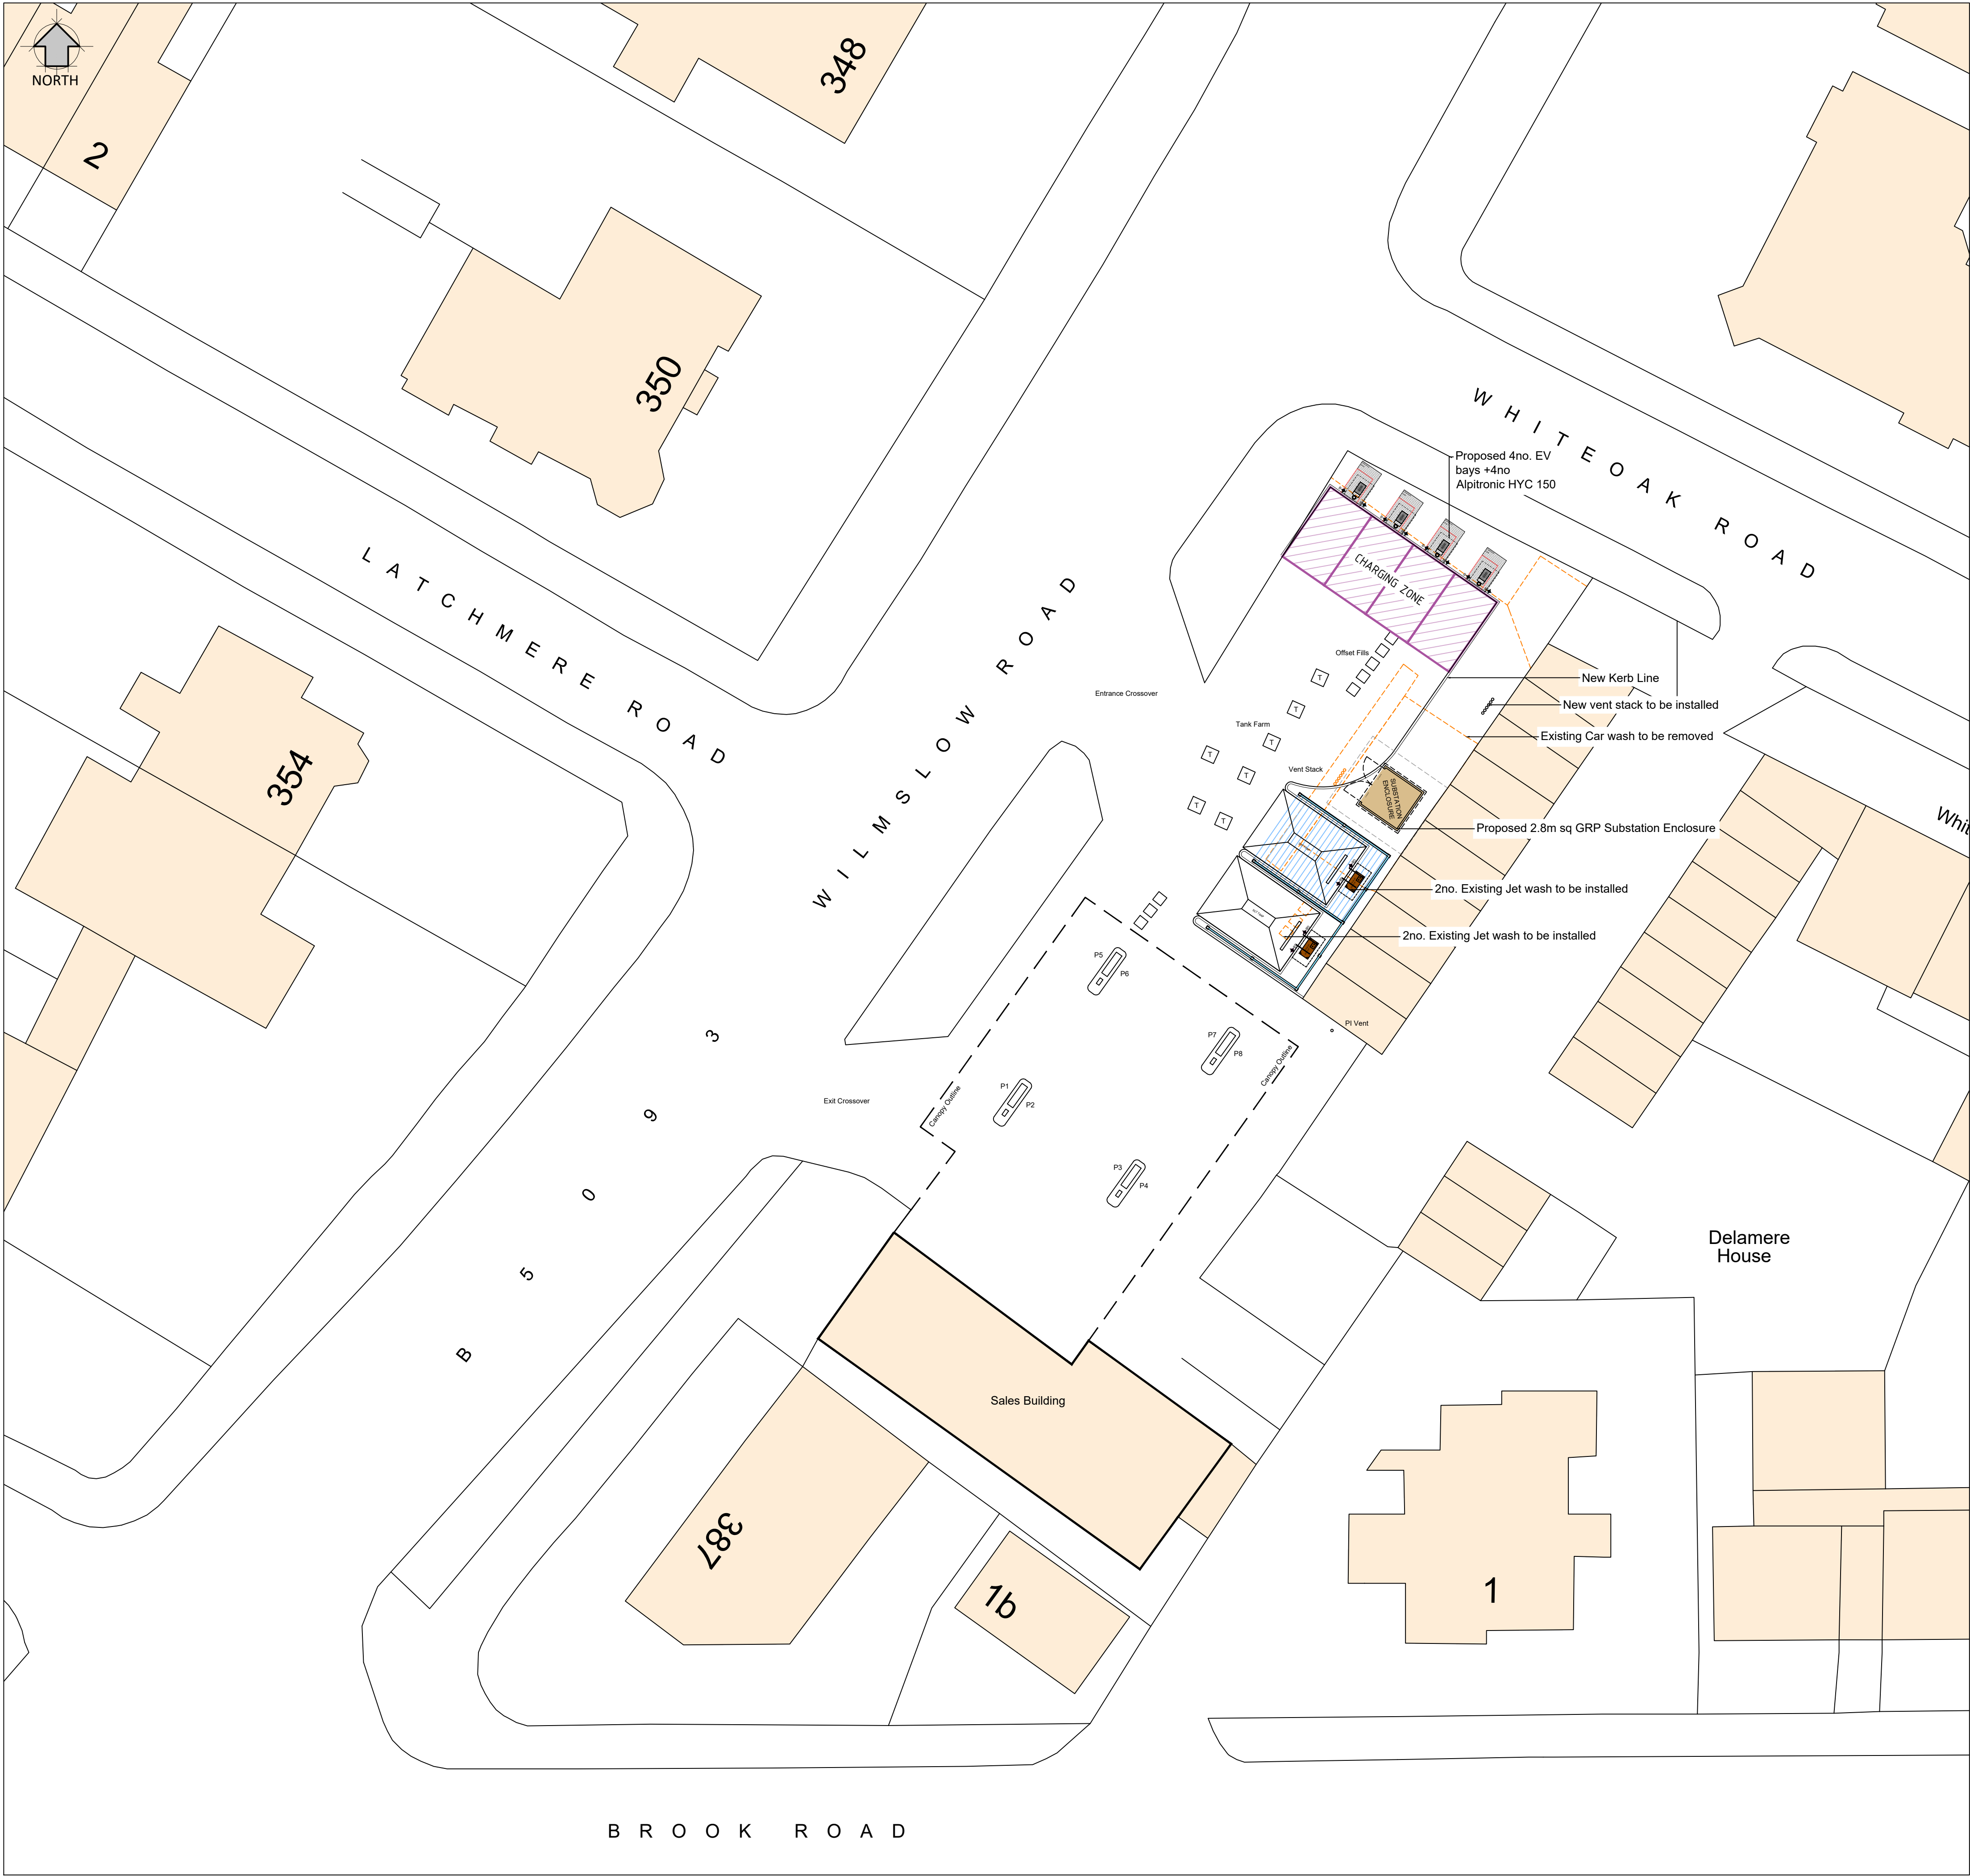


EV DRAWING LEGEND

- EXISTING KERB
- PROPOSED KERB
- PROPOSED DROPPED KERB
- DEMOLISHED
- EXISTING LINE WORK
- PROPOSED LINE WORKS
- PROPOSED EV BOLLARD - RAL 5015
- EXISTING FLOOD LIGHT
- PROPOSED FLOOD LIGHT
- EXISTING FENCE LINE
- PROPOSED FENCE LINE

EV INFRASTRUCTURE LEGEND

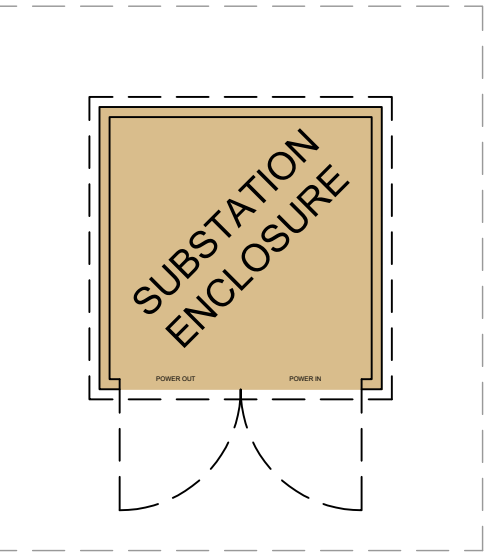

DENOTES DNO HV/LV SUBSTATION
Typical GRP Enclosure 2.8m x 2.8m
All to service provider standard details
TO ICP DETAILS

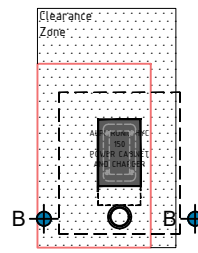

DENOTES CHARGING POST
ALPITRONICS HYC 150

DRAWING NOTES

COPYRIGHT ©
This drawing and the details herein are the copyright of MBH Design Studio Ltd. and must not be reproduced, altered or passed to any third party without prior written consent.

This drawing has been produced for the project listed below, is submitted in support of this application application to the Local Planning Authority and is not intended for use by any other person or for any other purpose.

Every effort has been made to ensure the accuracy of these drawings, however MBH Design Studio Ltd. accept no responsibility for any discrepancies arising from the reuse of survey information and preliminary drawings commissioned by the Applicant from others.

This drawing is an initial feasibility scheme and is subject to technical review and internal approvals. DNO application process may affect feasibility, provide additional information and require further review of scheme. Feasibility may be affected by other factors as the scheme progresses to working drawing stage and may also be compromised by unforeseen elements encountered on site during installation of works

Scheme Based on OS Map Dated 27.09.2022



REV	DATE	DESCRIPTION	DRAWN/CHECKED
REVISION NOTES			

PLANNING



MBH Design Studio Ltd.
Rosemount House, Rosemount Avenue, West Byfleet, Surrey, KT14 6LB
www.mbhstd.com t: 01932 352 727 f: 01932 351 545

CLIENT



PROJECT

FS963 FOLLOWFEILD SERVICE STATION
WILMSLOW ROAD
MANCHESTER, GRT MANCHESTER
M14 6AH

DRAWING TITLE

PROPOSED SITE PLAN

DRAWN BY	DATE	SCALE	PAPER SIZE
RRB	15.02.2023	1:200	A1
CHECKED BY	DRAWING NUMBER	REV.	
JR	13664-963-21	-	