


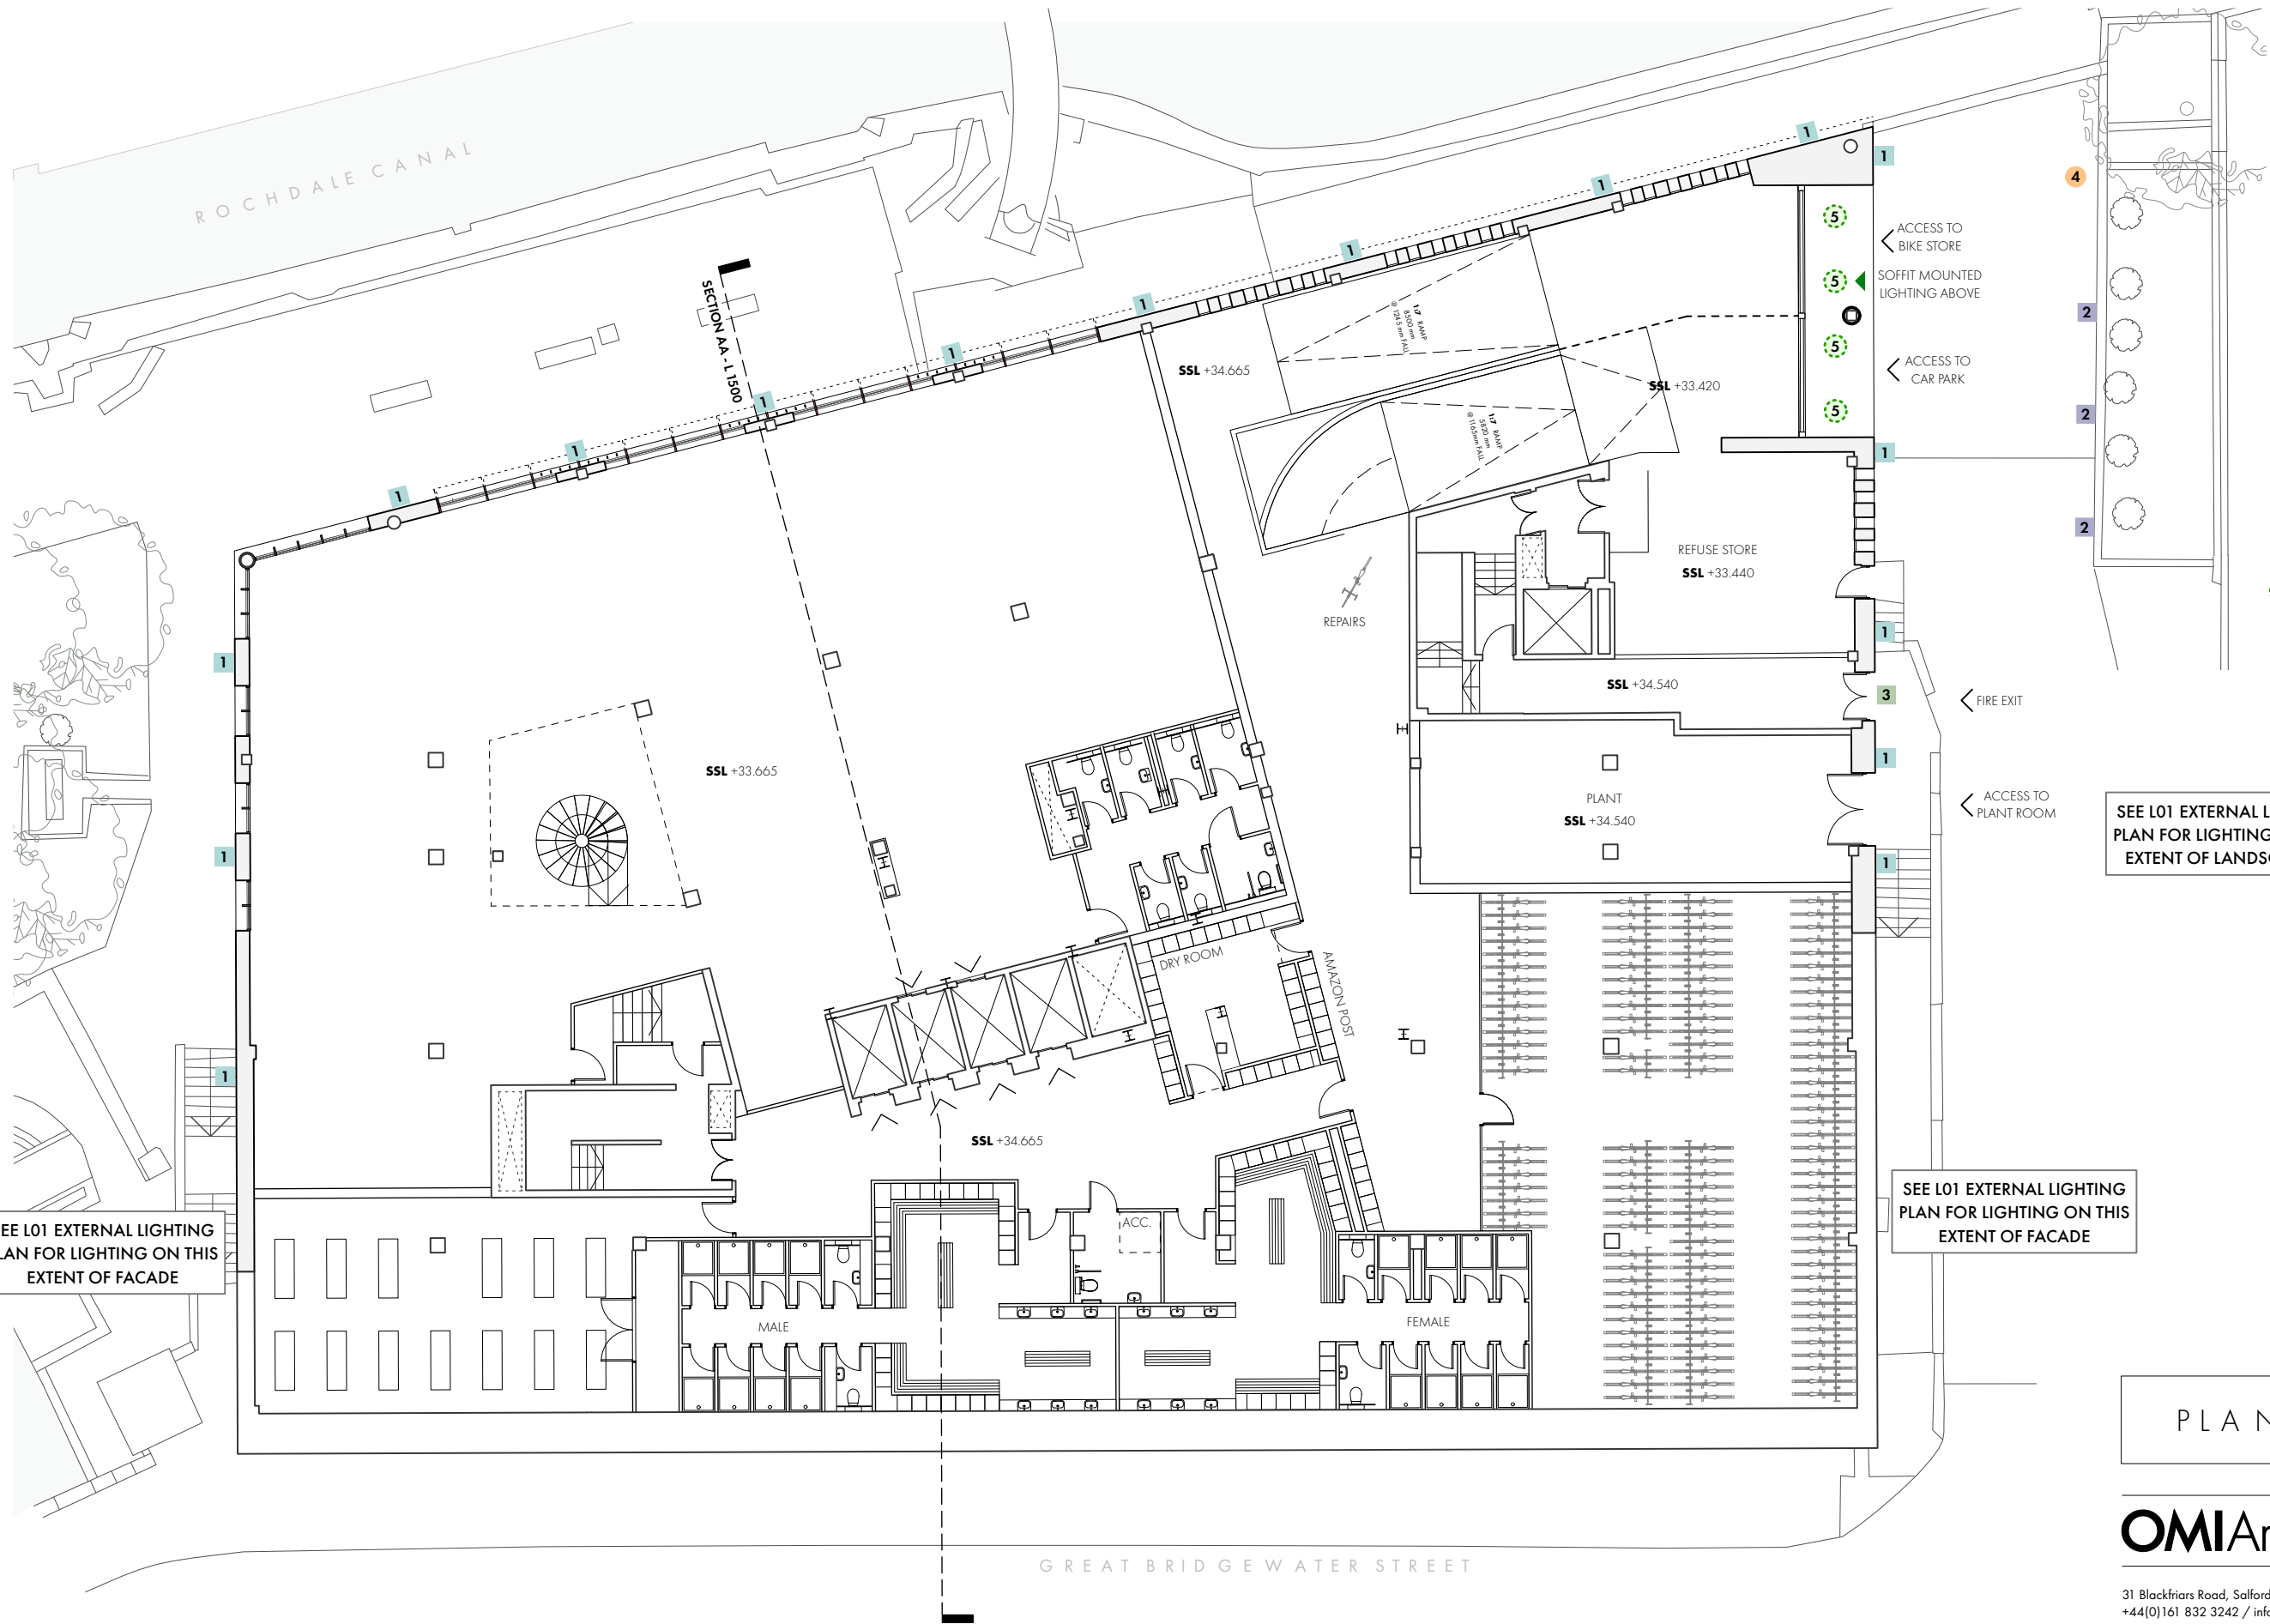


EXTERNAL LIGHTING KEY

- 1 BEGA 24 373 K3 - GRAPHITE (3000K)
- 2 BEGA 22 280 K3 - GRAPHITE (3000K)
- 3 NON-MAINTAINED EMERGENCY DOWNLIGHTER ABOVE EXIT
- 4 THORLUX PASSWAY 11W LED BOLLARD LIGHT 1100mm (3000K)
- 5 BEGA 24 290 K3 - SOFFIT MOUNTED EXTERNAL (3000K)

SEE L01 EXTERNAL LIGHTING PLAN FOR LIGHTING ON THIS EXTENT OF LANDSCAPING

SEE L01 EXTERNAL LIGHTING PLAN FOR LIGHTING ON THIS EXTENT OF FACADE

SEE L01 EXTERNAL LIGHTING PLAN FOR LIGHTING ON THIS EXTENT OF FACADE

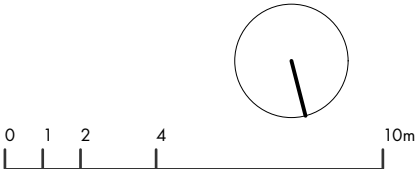

PLANNING ISSUE

OMIArchitects

31 Blackfriars Road, Salford, Manchester, M3 7AQ
+44(0)161 832 3242 / info@omiarchitects.com / www.omiarchitects.com

PROJECT	70 GREAT BRIDGEWATER STREET					
DRAWING	PORPOSED PLAN_LEVEL 00 - EXTERNAL LIGHTING					
DATE	FEB 23	DRAWN BY	LG	SCALE	1:200	@ A3
JOB NO.	1420	DWG.NO.	L 1010			

70 GREAT BRIDGEWATER STREET | PROPOSED PLAN
LEVEL 00

1.200 @ A3