


LEGEND

- "AD" - DENOTES DIMMER
- "ADE" - DENOTES DIMMER
- "A" - SURFACE MOUNTED LUMINAIRE
- "AE" - SURFACE MOUNTED LUMINAIRE
- "BE" - WALL MOUNTED SURFACE LUMINAIRE
- "C" - RECESSED DOWNLIGHT
- "CE" - RECESSED DOWNLIGHT
- "D" - SURFACE MOUNTED LUMINAIRE
- "EX2" - EXTERNAL WALL MOUNTED SURFACE LUMINAIRE
- "F" - PEDANT GLOBE LIGHT
- "G" - BATTEN LAMP HOLDER
- "E1" - EMERGENCY BULKHEAD LIGHT
- "E2" - EMERGENCY EXIT LIGHT
- "H" - SURFACE MOUNTED BULKHEAD (IP RATED)
- "J" - WALL MOUNTED SURFACE LUMINAIRE
- ON / OFF LIGHT SWITCH
- PIR DETECTOR
- MW1 - DIRECTIONAL MICROWAVE DETECTOR
- "G" BATTEN LAMP HOLDER
- "KIKE" WALL MOUNTED FEATURE LIGHT

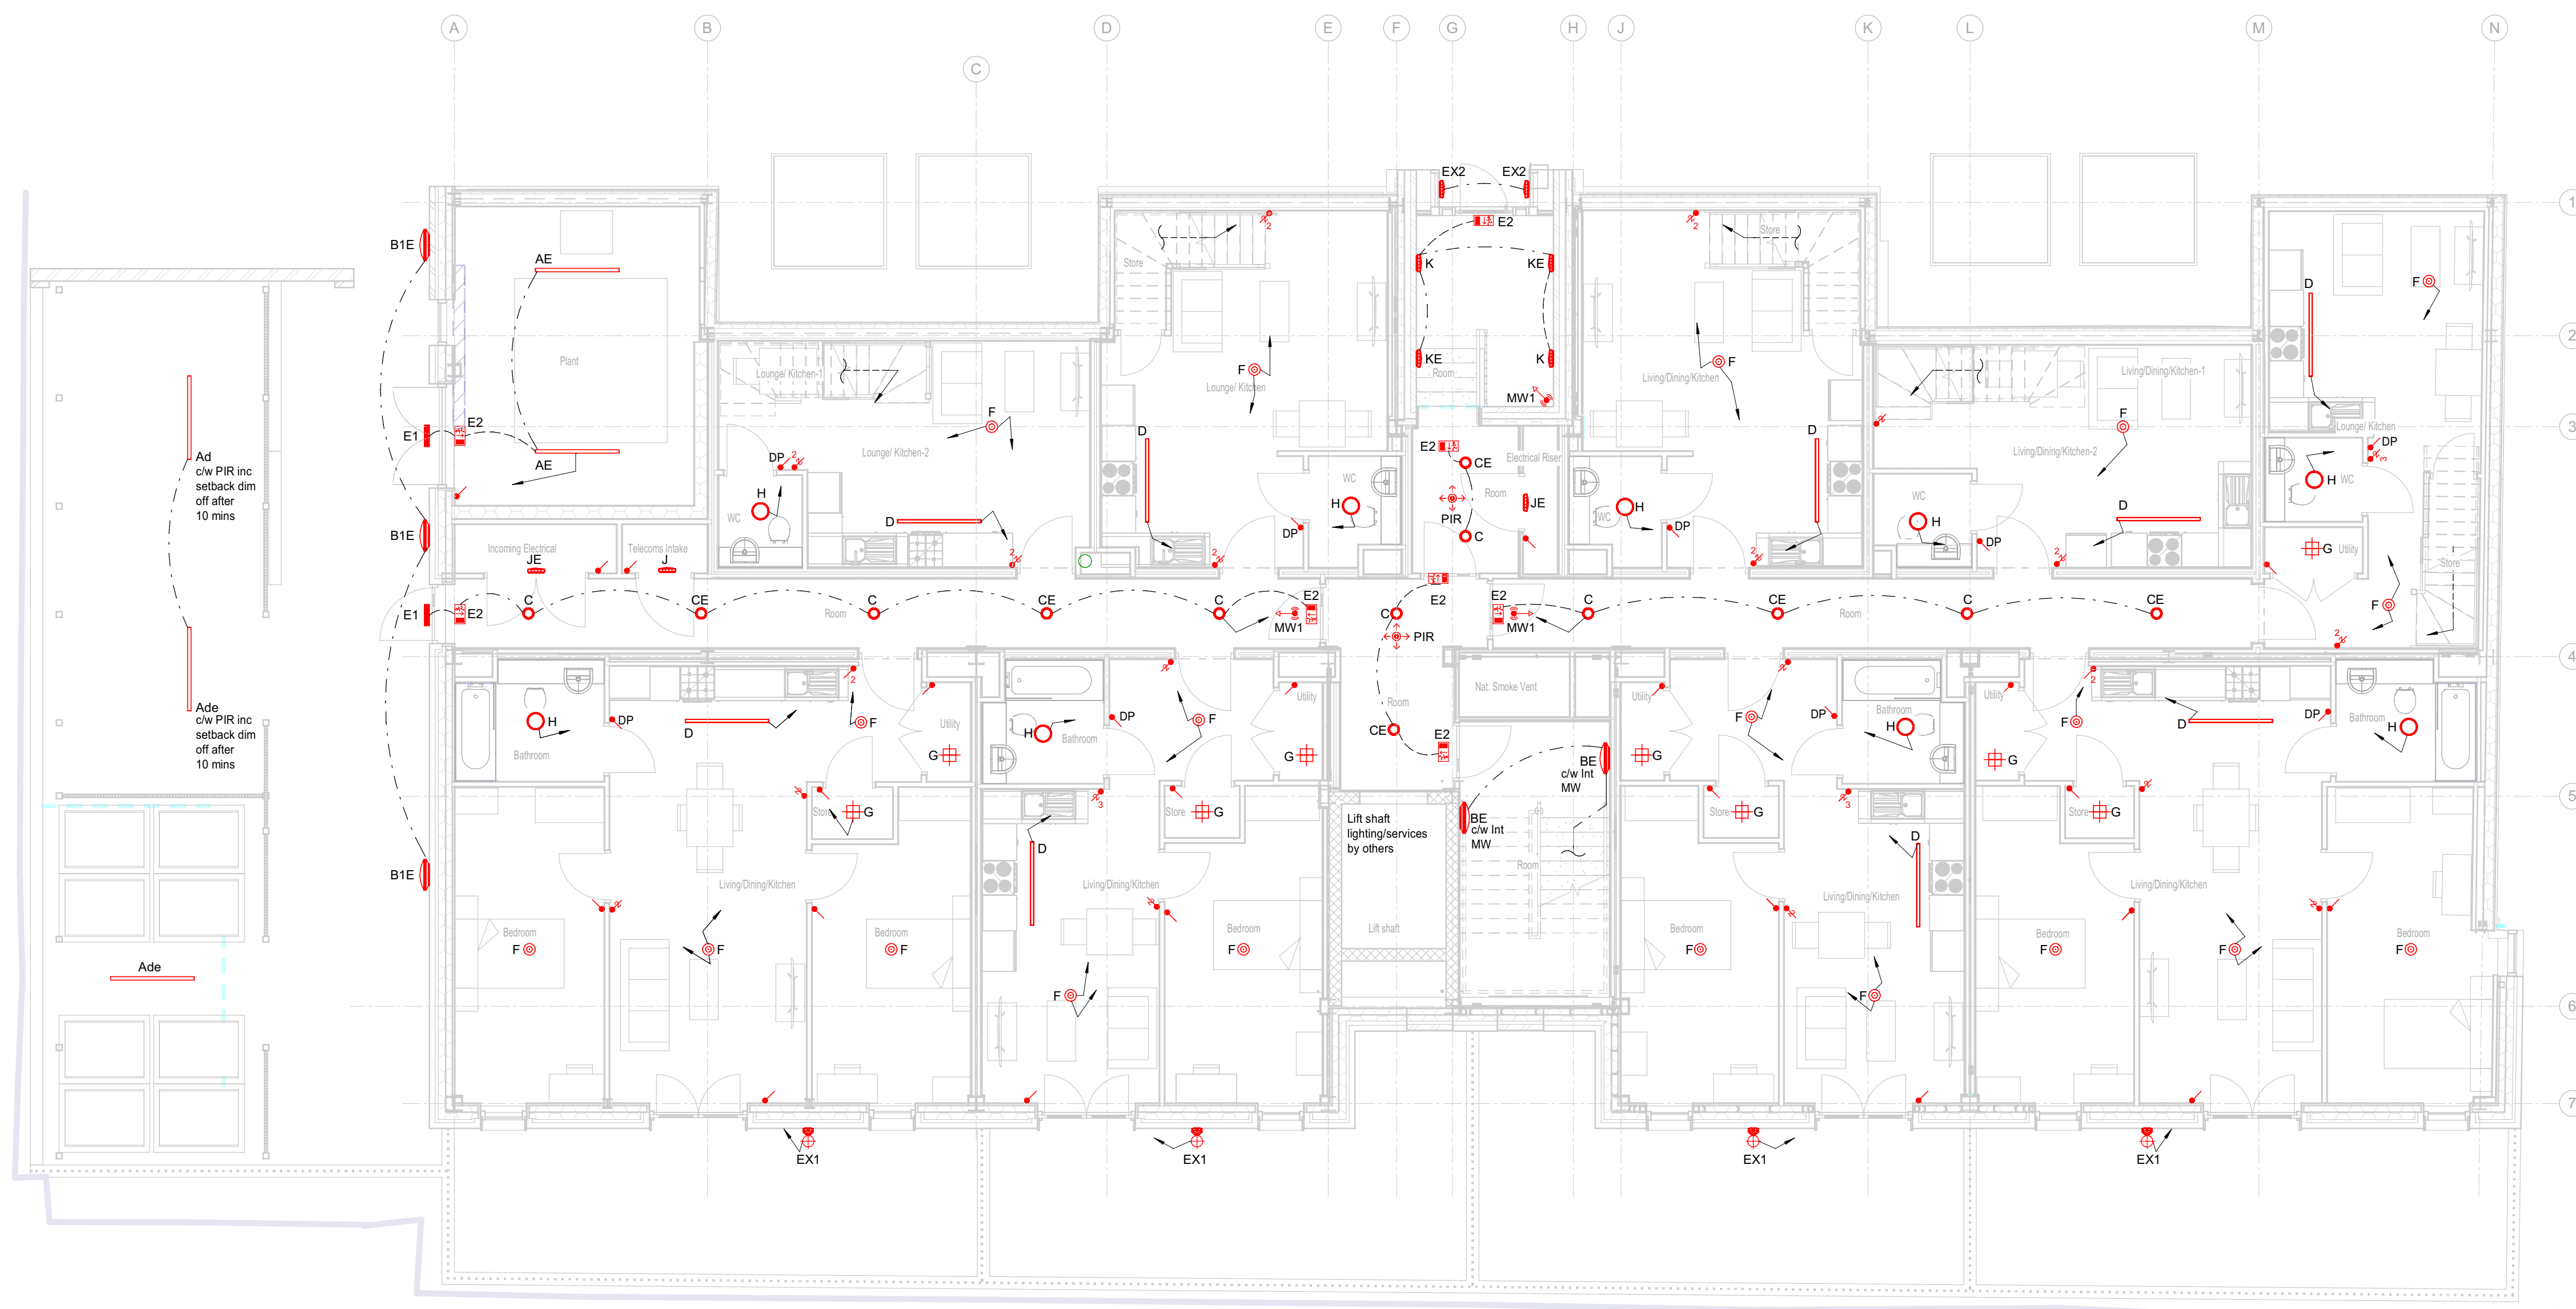

P06	22-09-2022	Updated to clients comments	WLG
P05	20-05-2022	Updated architectural/structural models inc Arc/EWC comments	WLG
P04	19-05-2022	Updated to EWC comments	WLG
P03	29-04-2022	Updated to structural and architectural changes	WLG
P02	14-04-2022	Updated to client comments	WLG
P01	21-03-2022	Preliminary Issue	WLG
Rev	Date	Description	Chk

Preliminary Issue

Client			
Main Contractor			
Project Title	 West Lancs House - Wymfields - Poulton-La-Fylde - Lancashire - FY6 8JX T: 01253 884 501 - e: admin@westlancgroup.co.uk w: www.westlancgroup.co.uk		
Project Title	Ancoats Dispensary	WLG Ref	225
Drawing Title	Lighting Layout - Level 00		
Scale	Date	Design	Checked
1:75@A1	21.03.2022	WLG	YC
Project	Originator	Volume	Level
210005	WLG	XX	00
Type	Role	Number	Rev
DR	E	6301	P06