
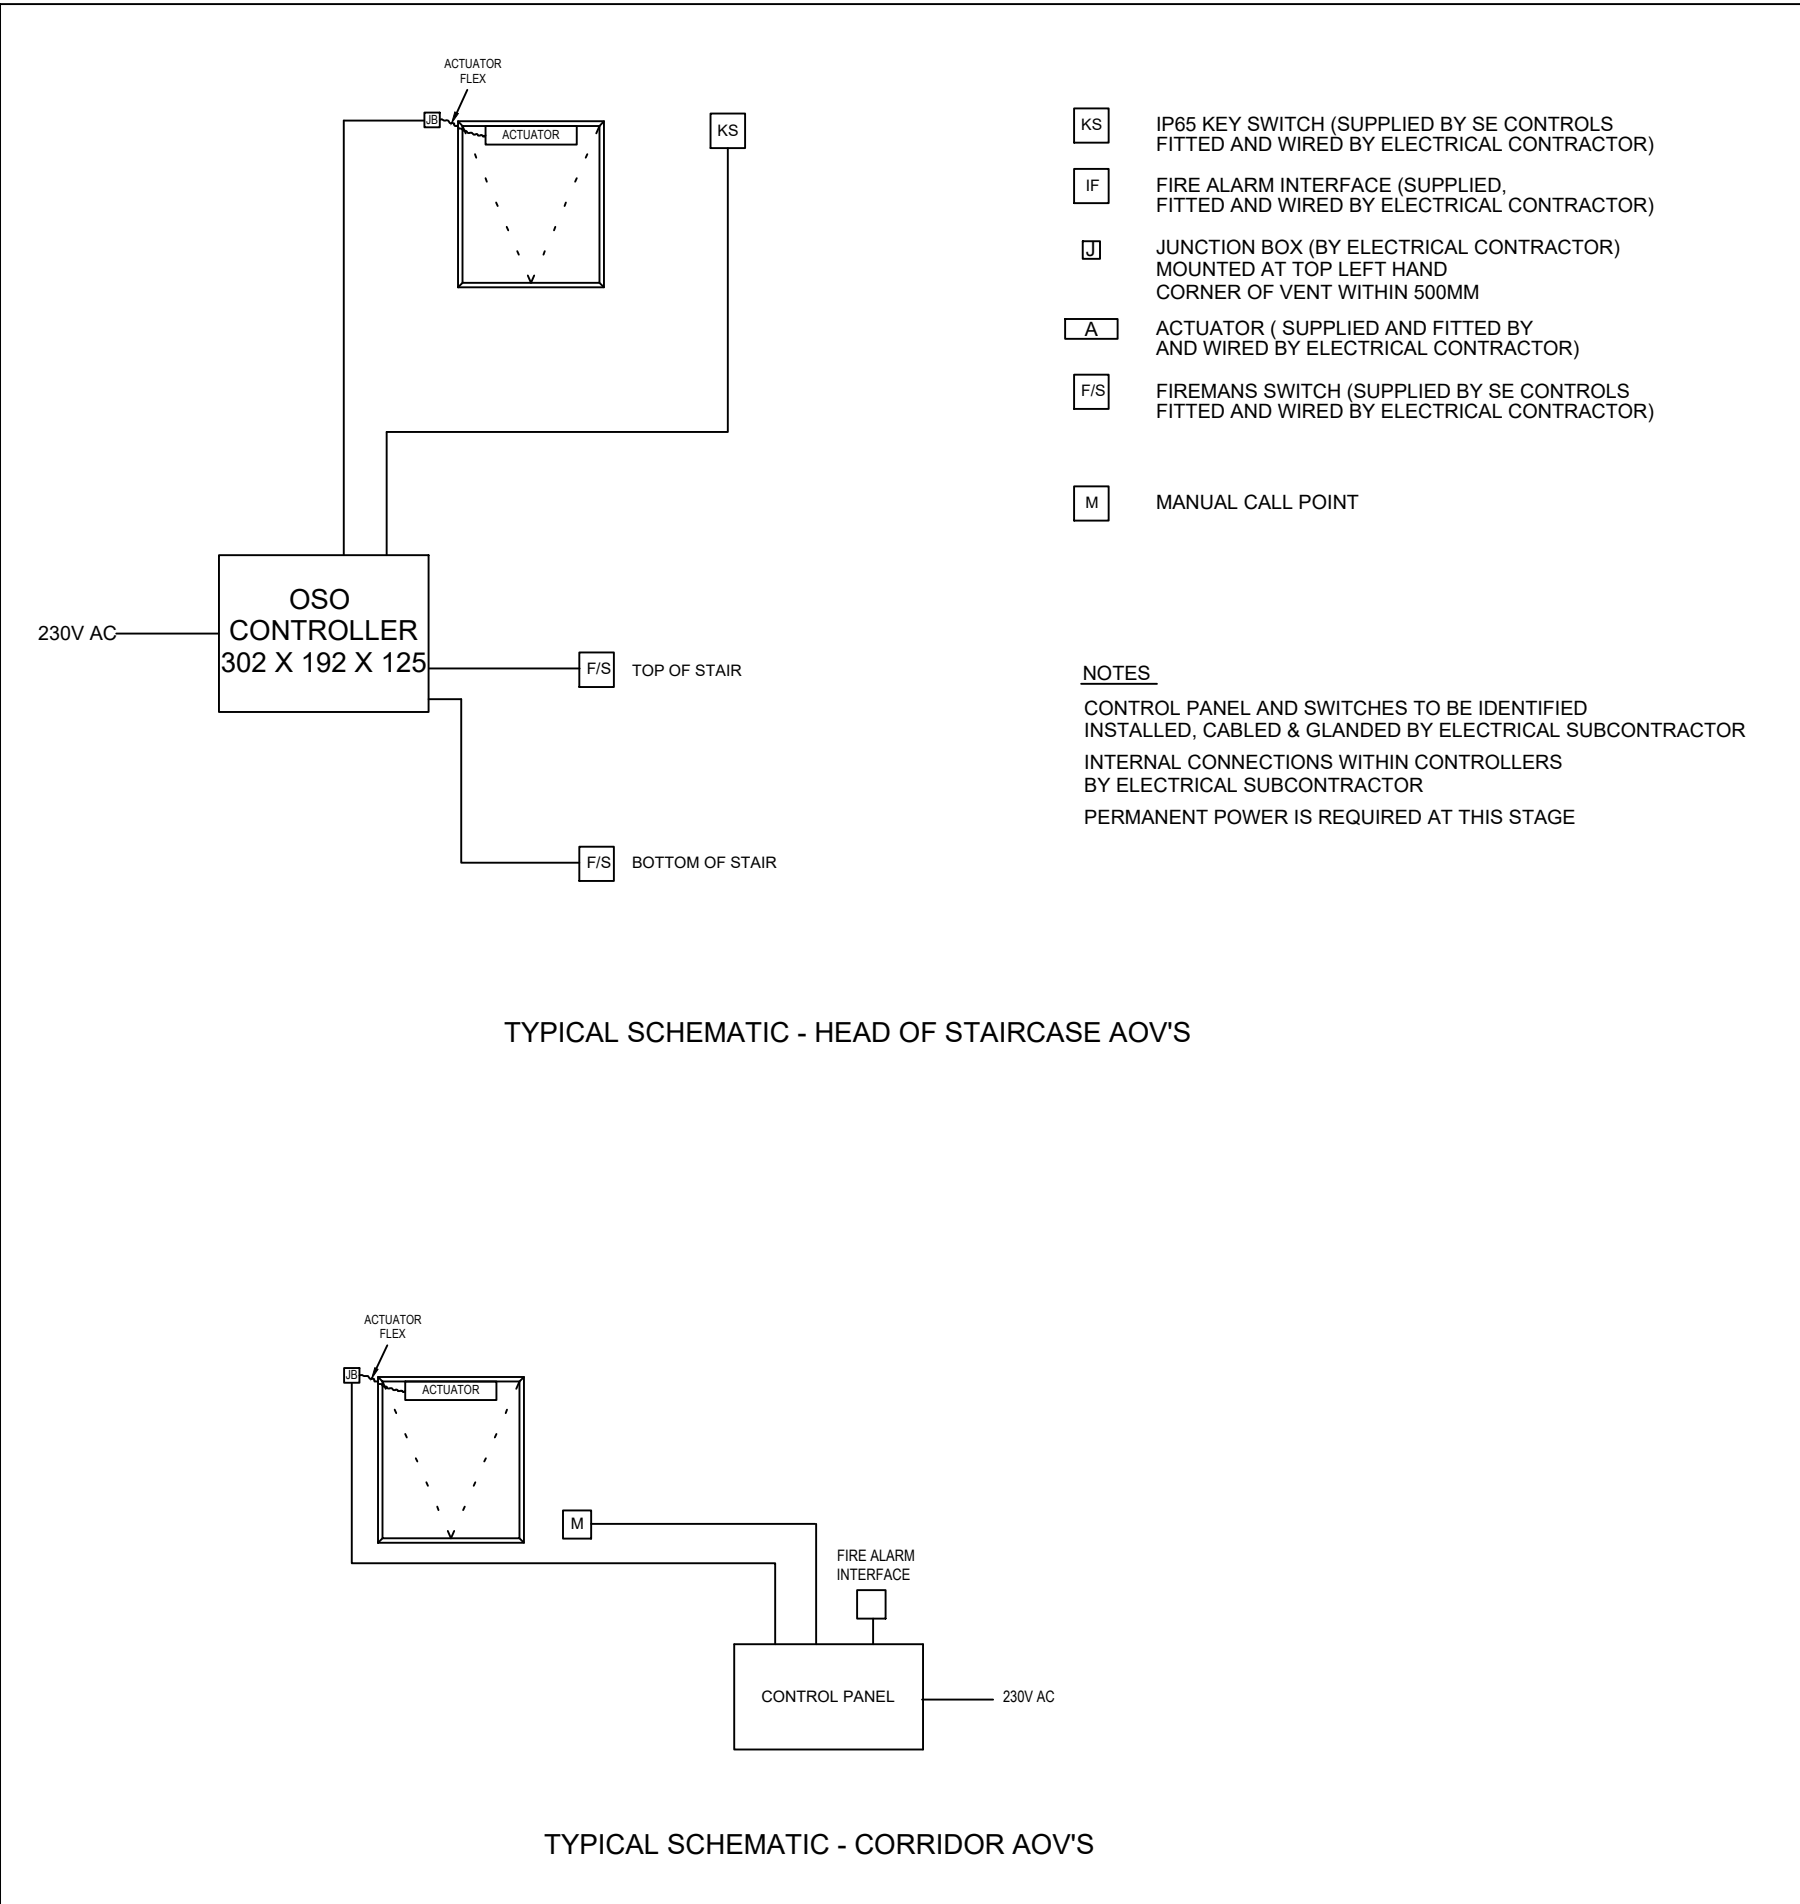
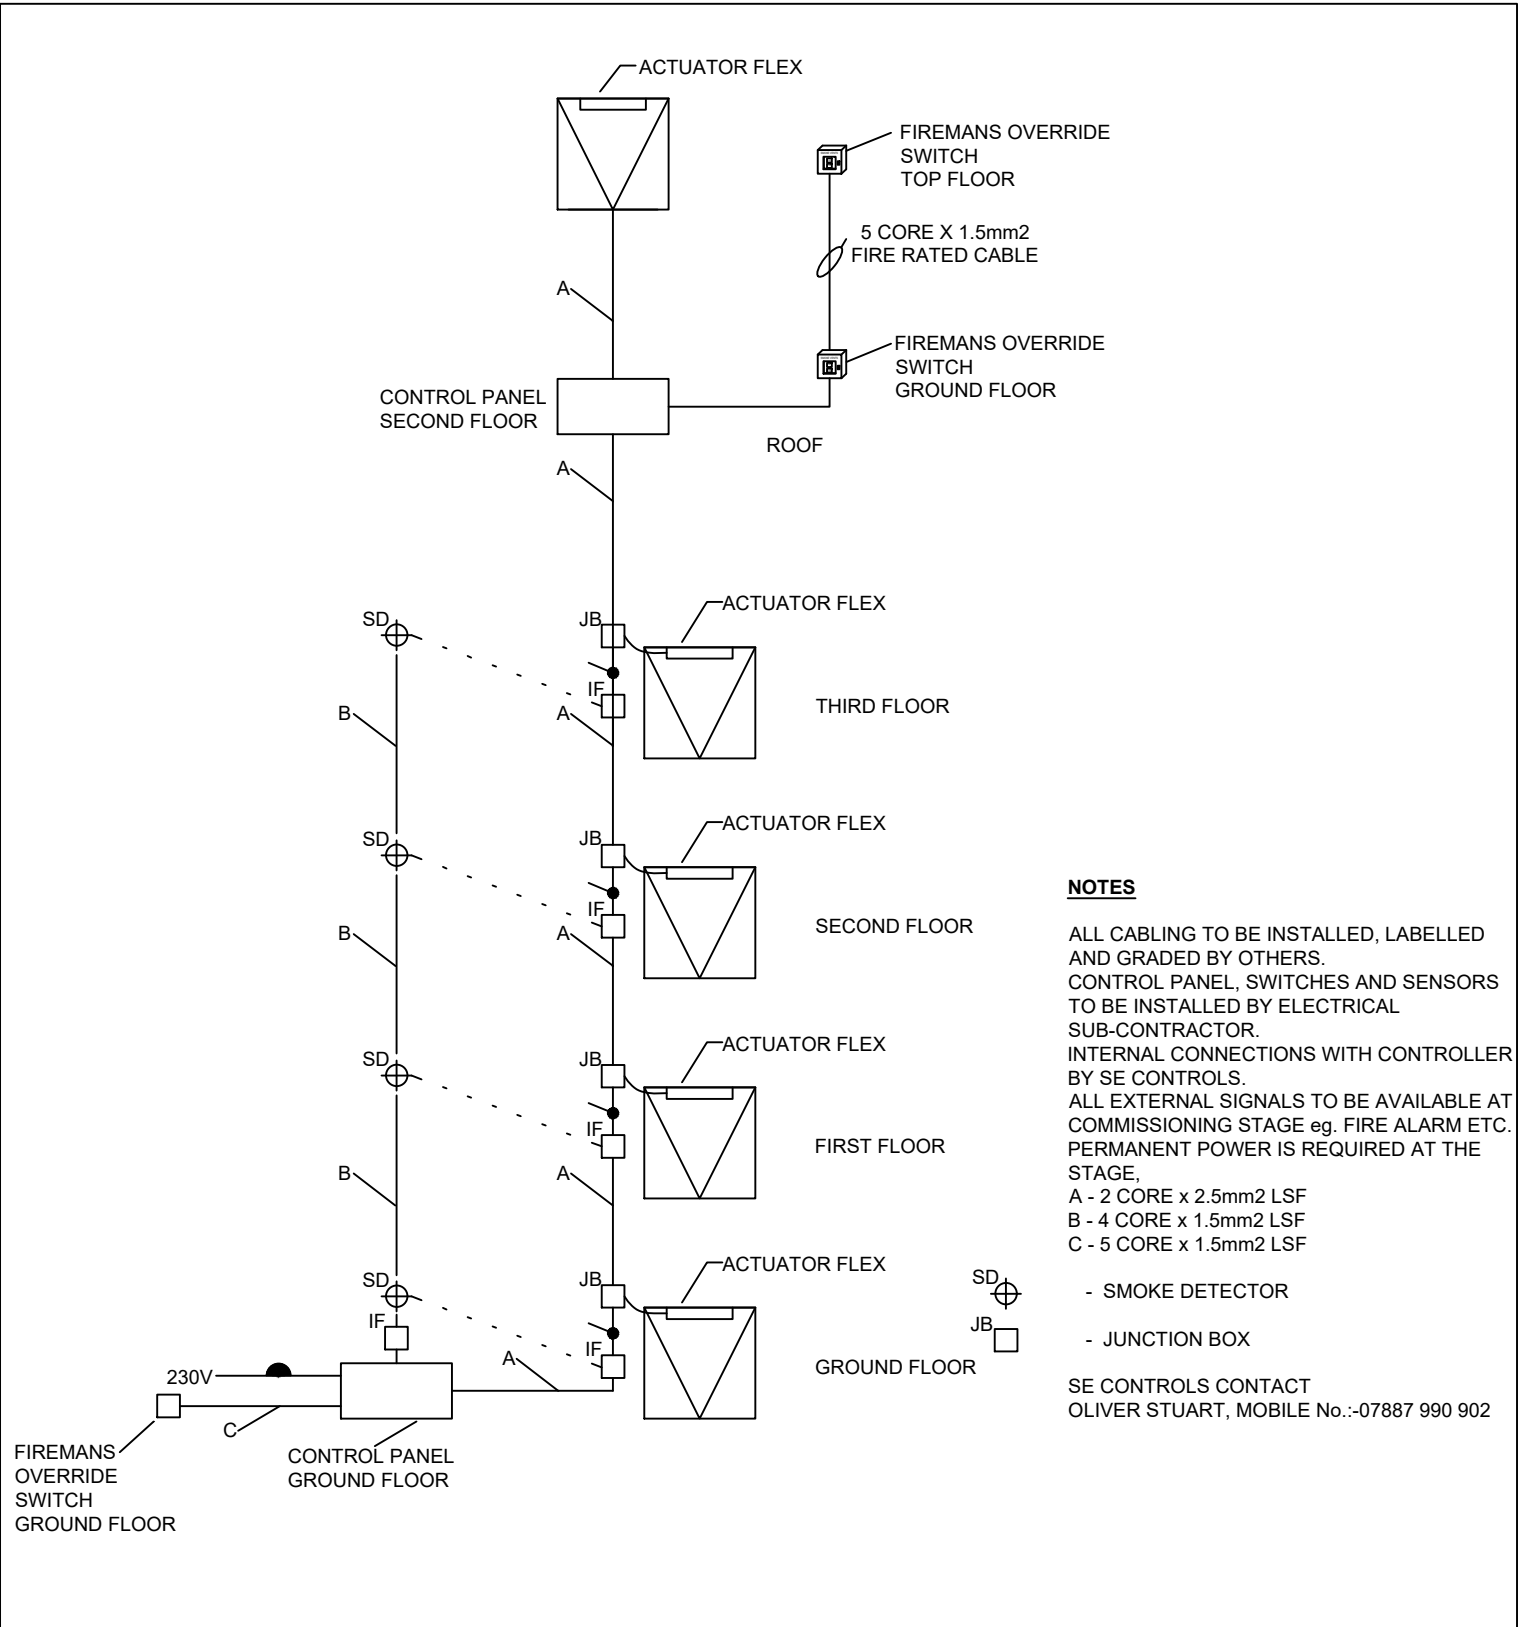
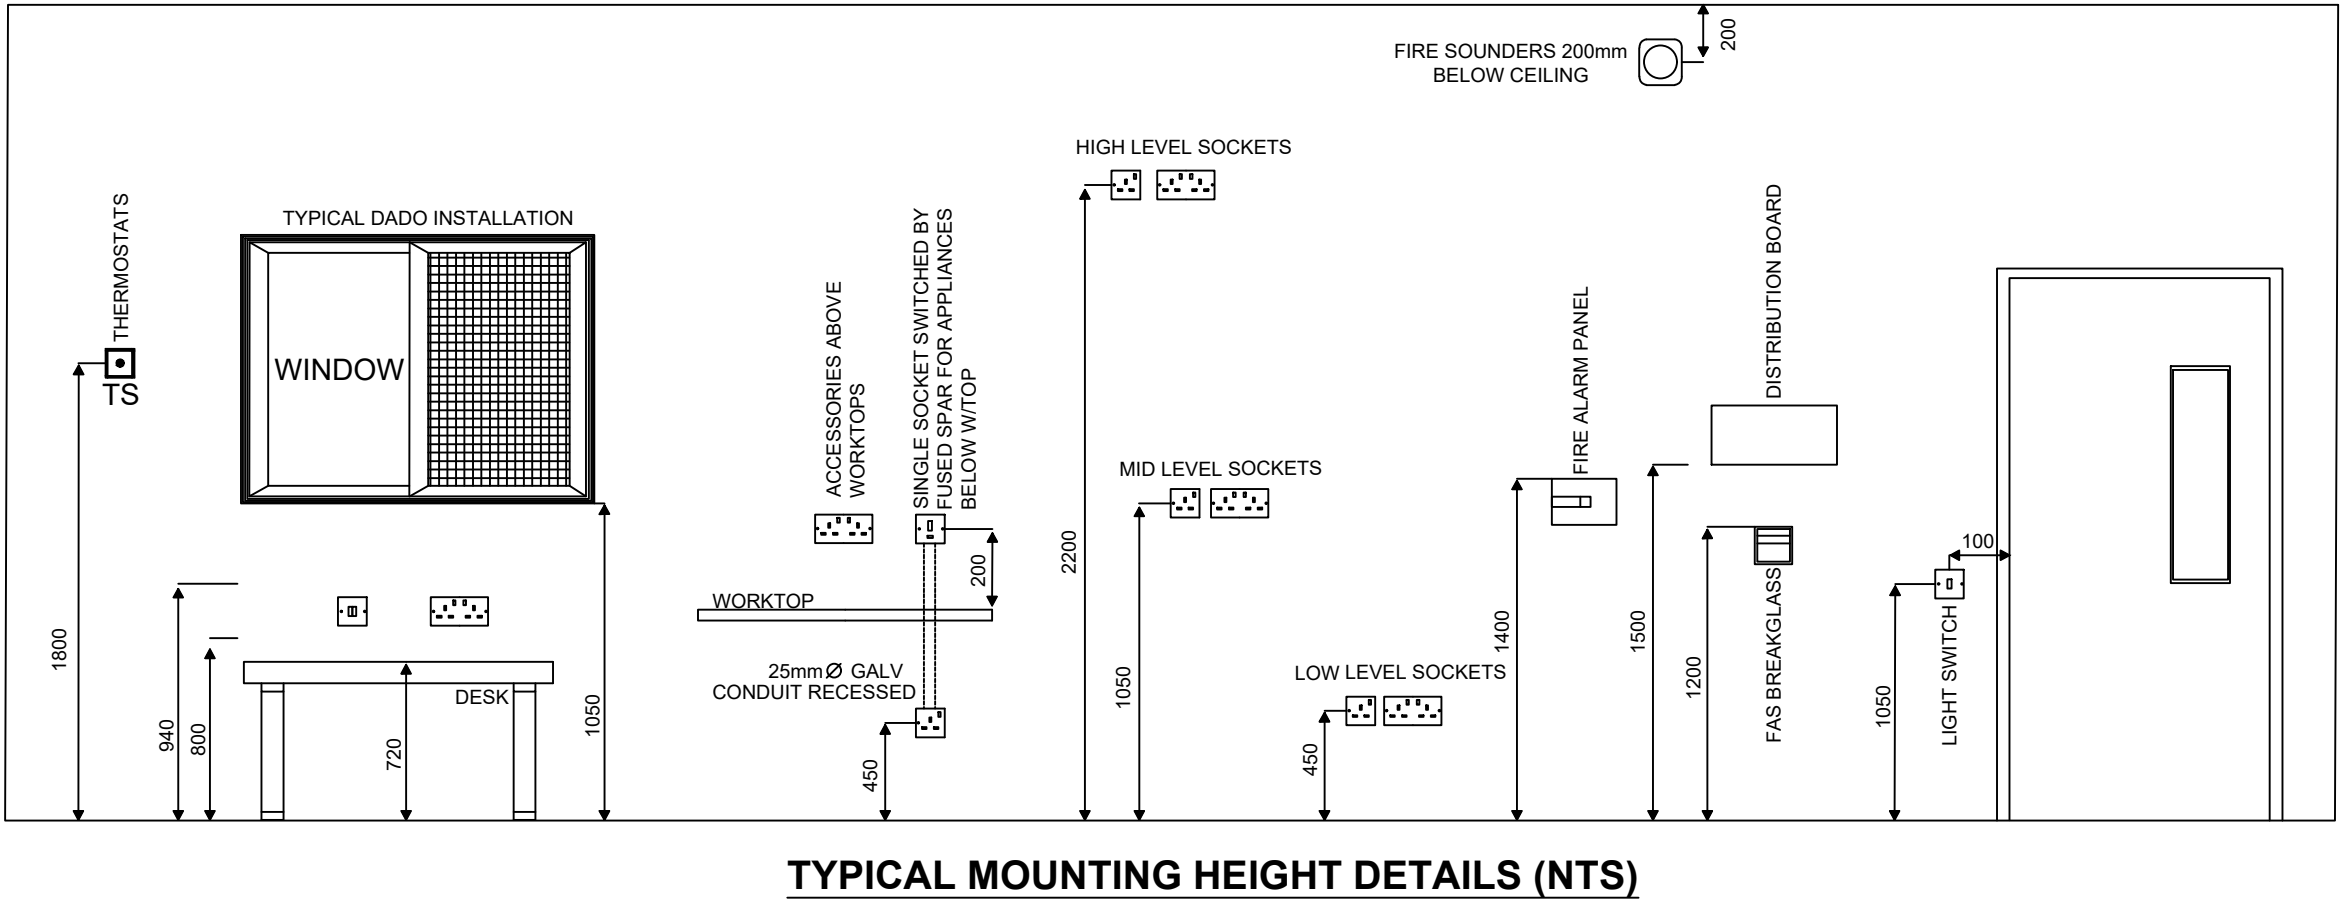
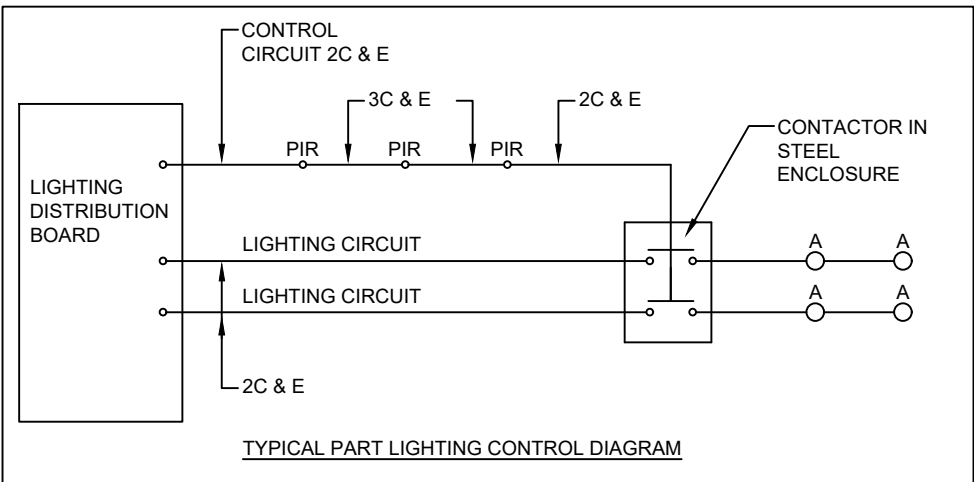
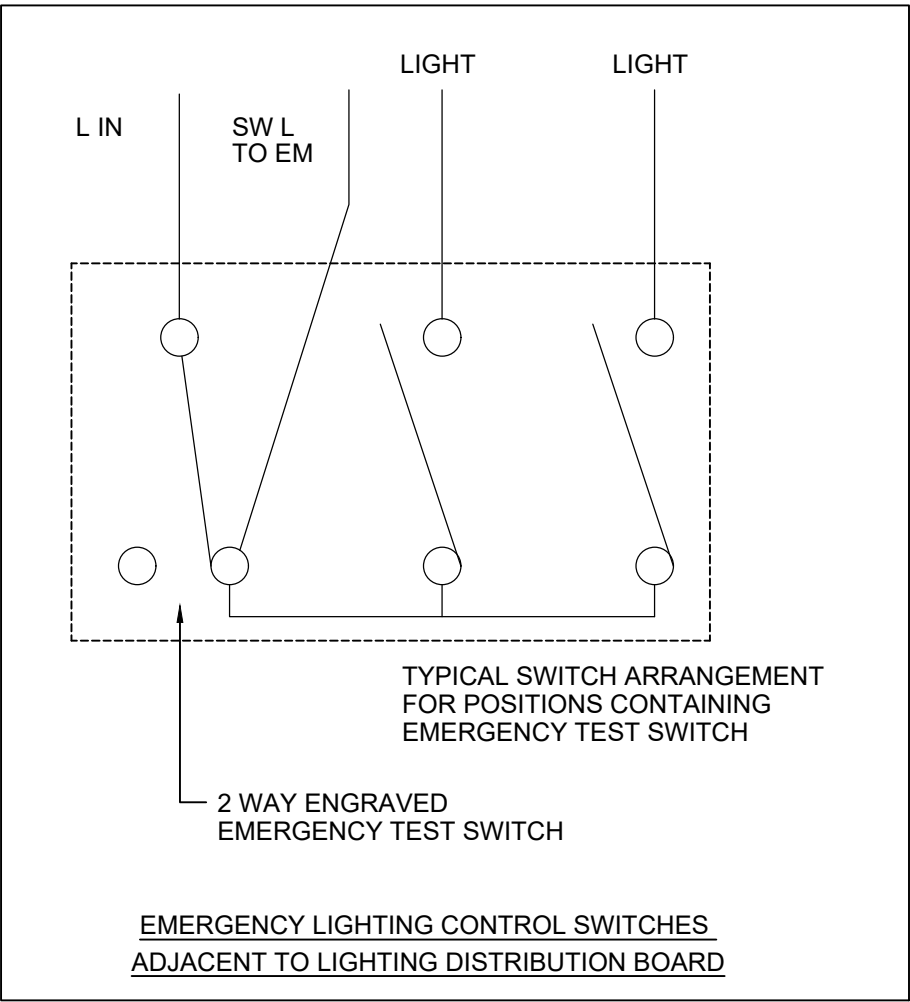


LEGEND	
	LIGHT FITTING - REFERENCE LINKED TO LUMINAIRE SCHEDULE
	LIGHT FITTING - C/W 3HR NON-MAINTAINED EMERGENCY BATTERY BACK UP
	WALL MOUNTED LIGHT FITTING - REFERENCE LINKED TO LUMINAIRE SCHEDULE
	LINEAR LIGHT FITTING - REFERENCE LINKED TO LUMINAIRE SCHEDULE
	LED EMERGENCY EXIT SIGN
	LIGHT CONTROLLER
	TRACK LIGHT FITTING - REFERENCE LINKED TO LUMINAIRE SCHEDULE
	ONE-WAY LIGHTING SWITCH
	TWO-WAY LIGHTING SWITCH
	INDICATED LIGHT SWITCH
	SMOKE DETECTOR
	SMOKE DETECTOR IN VOID - LINKED TO INDICATOR
	SMOKE DETECTOR SOUNDER - WIRED VIA MAINS SYSTEM
	HEAT DETECTOR SOUNDER - WIRED VIA MAINS SYSTEM
	SMOKE DETECTOR - WIRED VIA MAINS SYSTEM
	EMERGENCY EXIT GREEN BREAK GLASS C/W PROTECTIVE COVER
	SINGLE SWITCHED SOCKET
	FUSED SWITCHED SPUR
	DOUBLE SWITCHED SOCKET
	NEUTRAL ISOLATOR
	FUSED SWITCH
	METER
	TV POINT
	SINGLE TELEPHONE POINT
	SINGLE DATA POINT
	LIGHTNING PROTECTION ROD
	SATELLITE DISH
	TERRESTRIAL TELEVISION AERIAL
	BEMCO DISTRIBUTION UNIT
	1 PHASE DISTRIBUTION BOARD
	3 PHASE DISTRIBUTION BOARD
	MECHANICAL VENT
	TIME CLOCK
	BT DP POINT
	TV AMPLIFIER
	TV POINT
	SINGLE TELEPHONE POINT
	SHAVER SOCKET
	DOUBLE POLE COOKER ISOLATOR TO LOW LEVEL CONNECTOR PLATE
	ELECTRIC PANEL HEATER
	BOOSTER SWITCH
	HOT WATER CYLINDER
	BT POINT
	DOOR ENTRY CONTROLLER

LUMINAIRE SCHEDULE		
REF	DESCRIPTION	DETAILS
A	CORRIDOR LED DOWNLIGHTER	ANSELL GAMMA SENSOR LED LUMINAIRES
AE	CORRIDOR LED DOWNLIGHTER C/W 3HR EMERGENCY BATTERY PACK	ANSELL GAMMA SENSOR LED LUMINAIRES
FLAT C	BATTEN LAMP HOLDER	
EXTERNAL C	EXTERNAL WALL MOUNTED LED IP65 FITTING DIECAST EYELID	LUMINEUX BH 500 16 WATT
P	LED PENDANT IN EACH FLAT	
STAIRS B	WALL MOUNTED FLOODLIGHT LED	ASD
/E	COMPLETE WITH EMERGENCY FITTING	
FLAT B	BATHROOM FITTING	ANSELL DISCO
K	4 SPOT FITTING	PHILIPS LIMBALI 4 SPOT
Y	4.5 METER COLUMN C/W POLE TOP LED FLOODLIGHT	ASD
Z	LED FLOOD	ASD

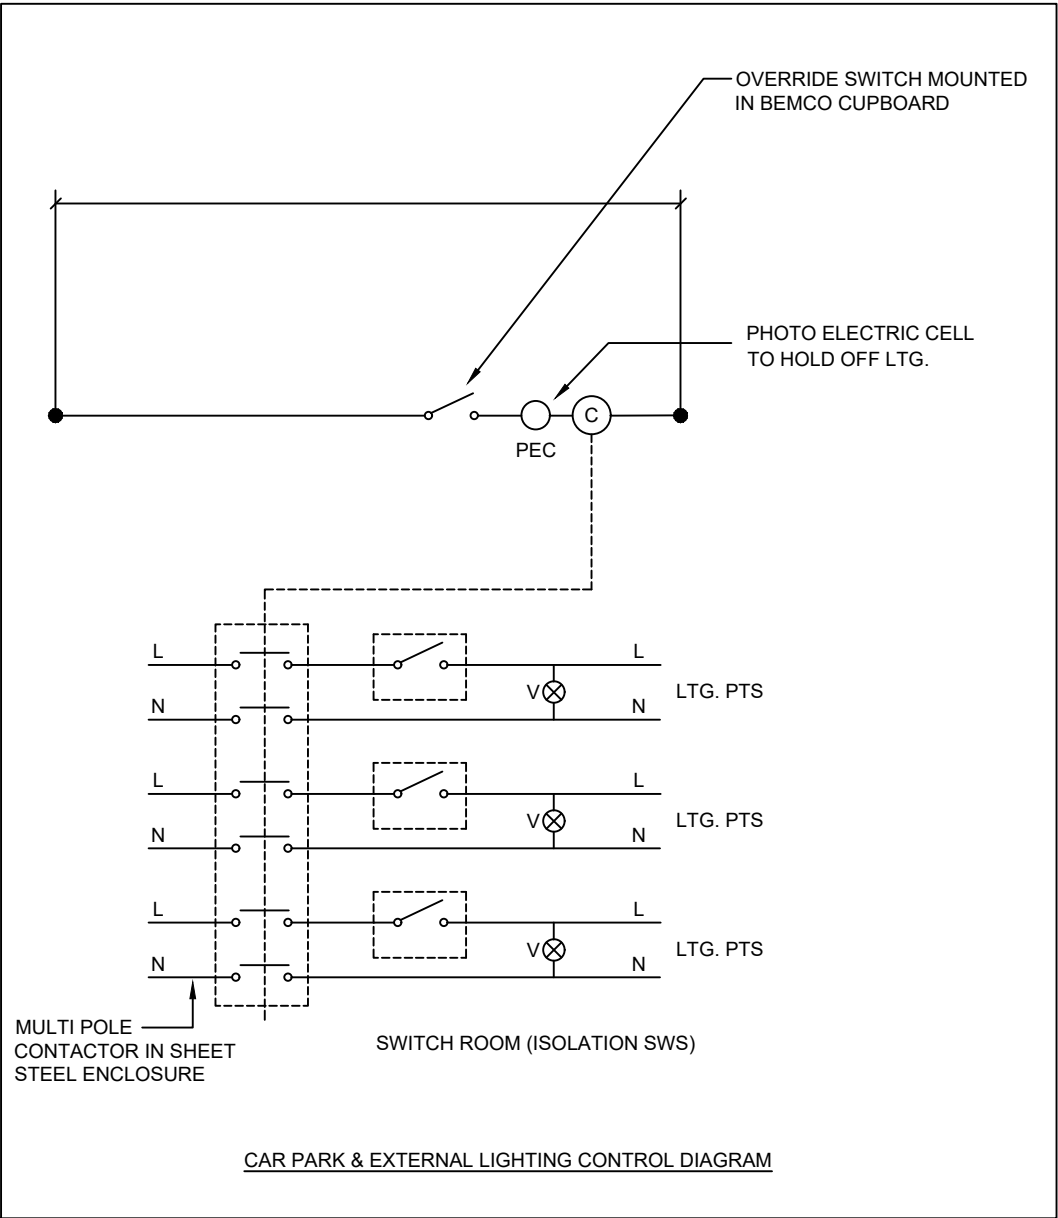

Rev	Date	Description
R1	07.09.22	Actuator note revised.
Project -		
Chatsworth Mill Williams Road, Gorton, Manchester, M18 7AY		
Title -		
Details & Diagrams		
Scale - nts @ A1		Design by - MD
Date - 26.06.22		Cad by - JGC
Drawing No. -		Revision -
5839-KGA-00-XX-DR-E-0201		R1

KGA (UK) Ltd
Chartered Building Services
Consulting Engineers
Trinity Chambers
10 Ivy Street
Birkenhead
Merseyside
CH41 5EF

T: 0151 647 5021
E: eng@kga.co.uk
W: www.kga.co.uk

