



01 DRAINAGE PLAN

1:100

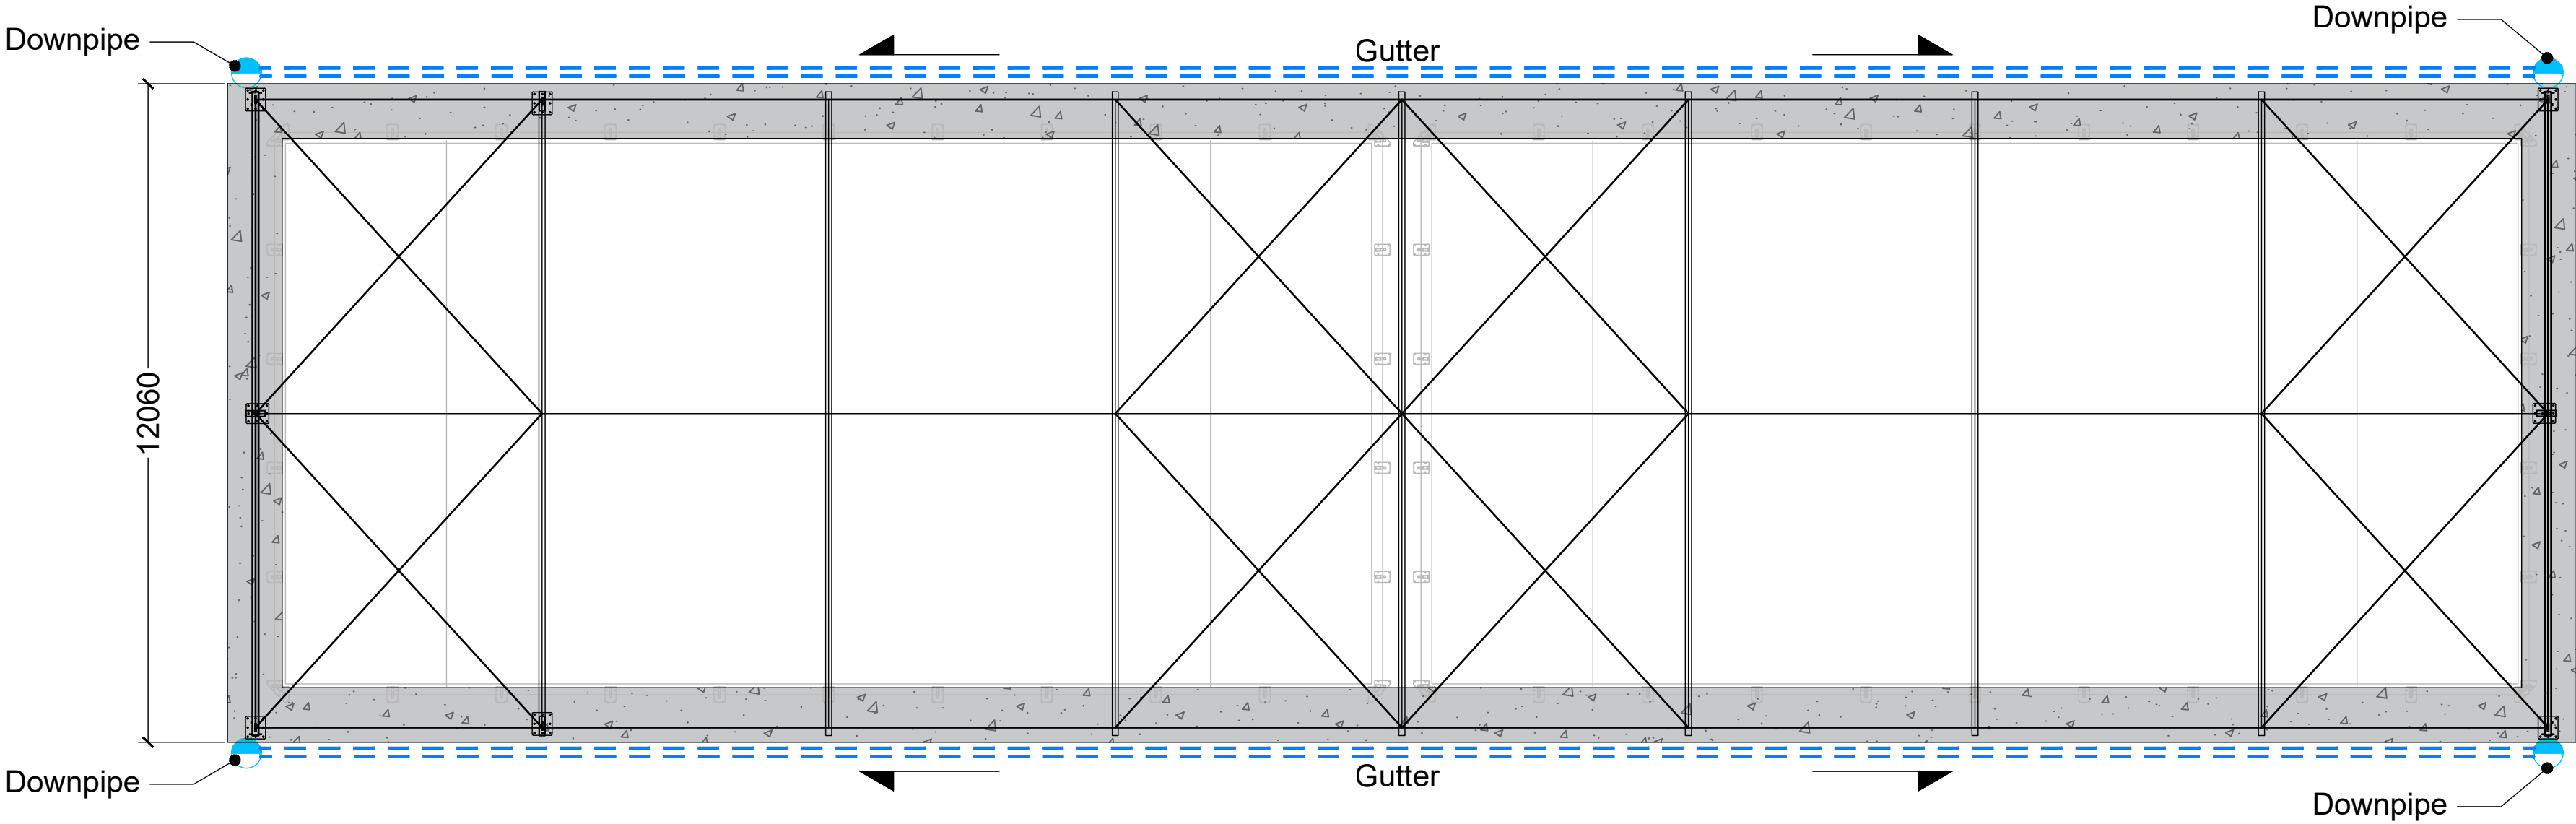

1:100
2m 0 2m 4m 6m

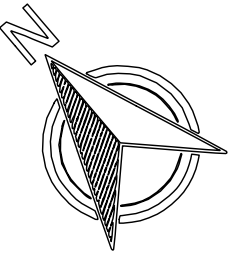


KEY

- Gutter
- Down pipes
- Stilt trap manhole
- Filter trench


02 END ELEVATION

1:100

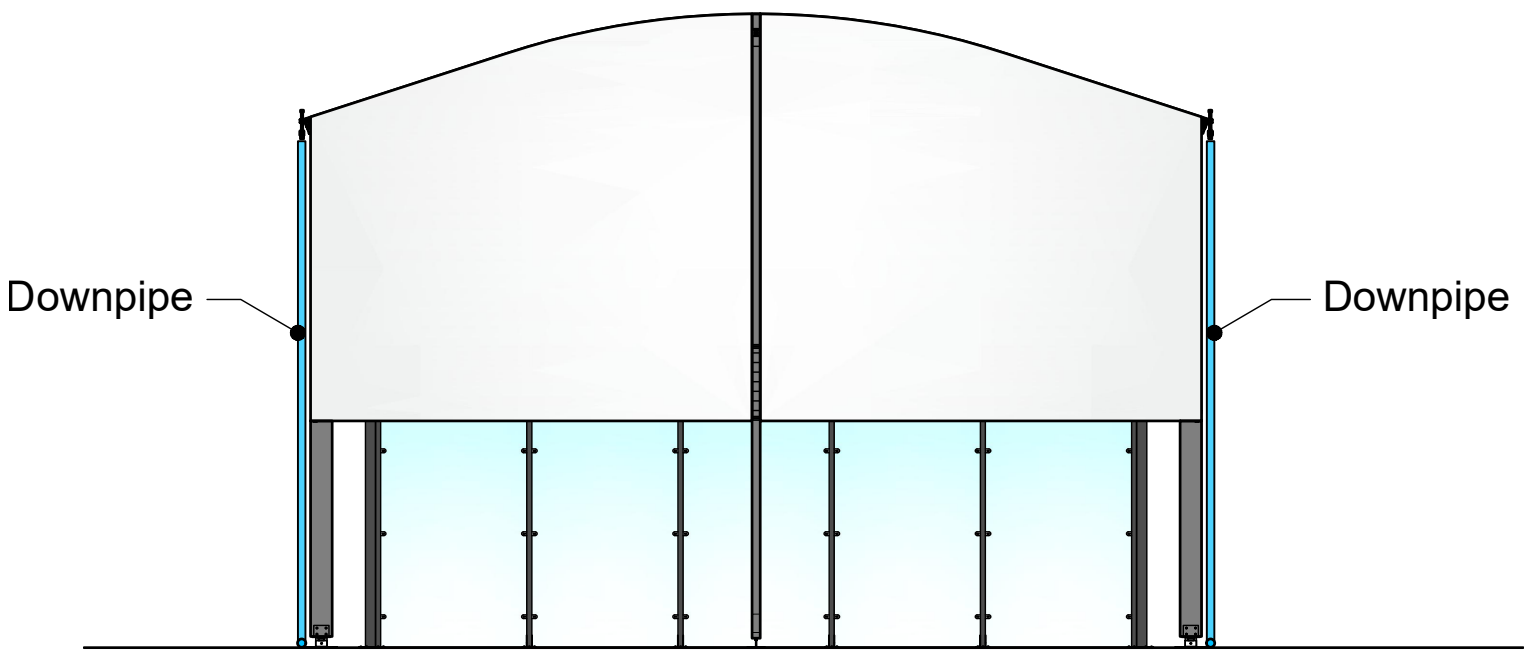

03 SIDE ELEVATION

1:100

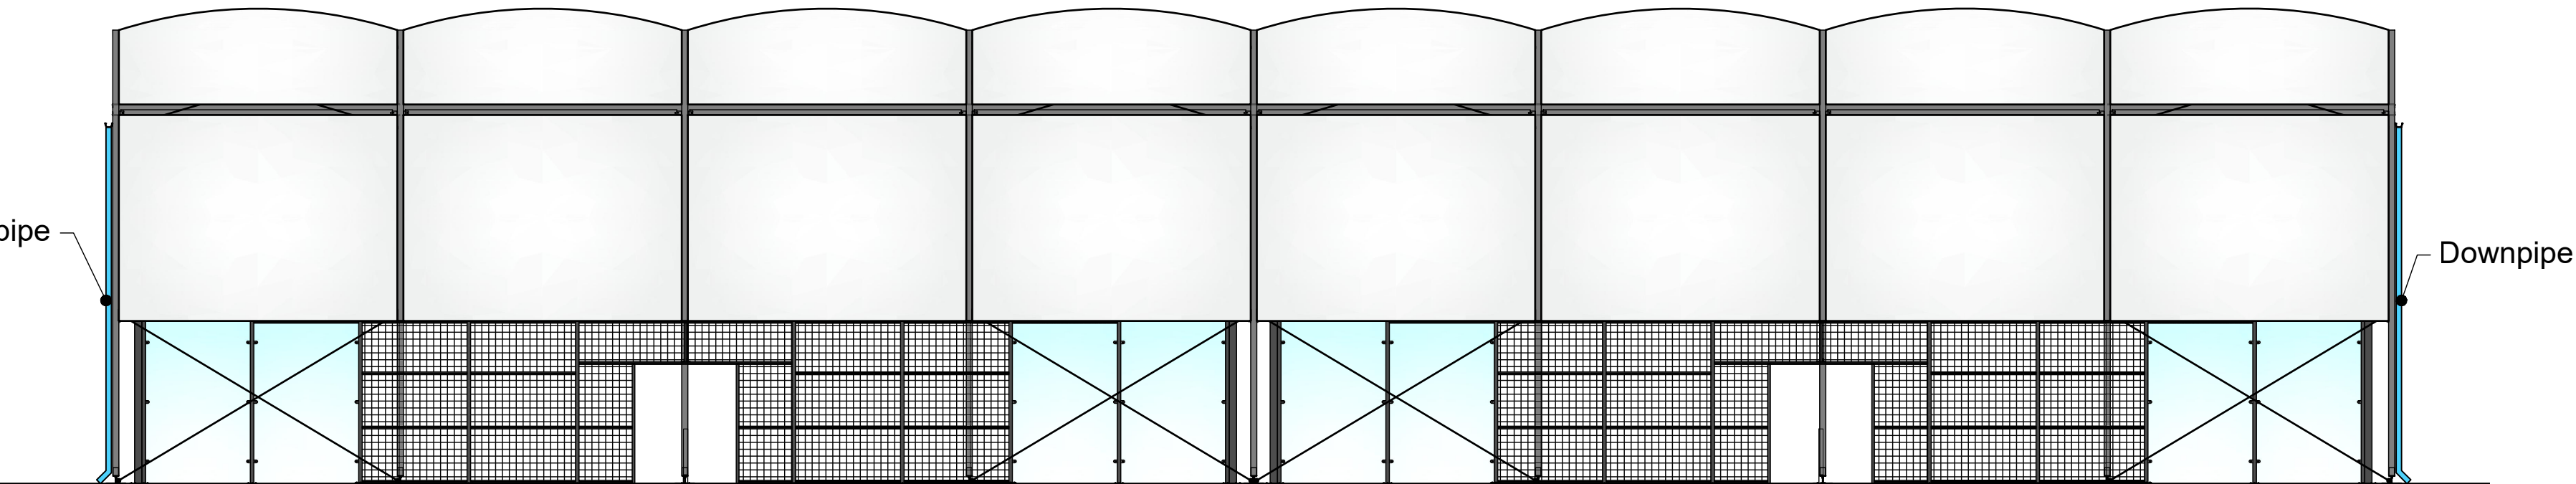

B	Updating lifting plan	LS	09.06.23
REV:	DESCRIPTION:	BY:	DATE:
STATUS:			
CLIENT:			
The Northern LTC			
SITE:			
The Northern LTC			
TITLE:			
DRAINAGE PLAN			
SCALE:	DATE:	DRAWN:	CHECKED:
1:100 @A1	12.06.23	AC	LS
PROJECT No:	DRAWING No:	REVISION:	
2011-04	010	A	

PADELTECH

Head office
Unit 12, 4-5 Lochside Way, Edinburgh, EH12 9DT
+44(0)131 581 8683
Southern office
Suite 3, Lake View House, Wilton Drive, Tournament Fields,
Warwick, CV34 6RG
+44(0)1926 679 586