 
 
 



FILENAME: E:\310000\310367 - GREATER MANCHESTER FRSS - BLACKLEY FIRE STATION\TECHNICAL\DRAWINGS\DWG [PLOTTED DATE: 13 April 2023 11:24:59

Luminaire Schedule						
Symbol	Qty	Label	Arrangement	Total Lamp Lumens	LLF	Description
	2	EX1S	SINGLE	14002	0.900	120w LED 4000k Viva City Flood 780mA with FW70 Optic and spill shield column mounted at 6m.
	4	EX1W	SINGLE	14002	0.900	120w LED 4000k Viva City Flood 780mA with FW70 Optic building mounted at 6m.
	2	EX2	SINGLE	8990	0.900	76w LED 4000k (4 module) 700mA Italo 1 with S05 Optic column mounted at 6m.
	4	EX3	SINGLE	3400	0.900	24w 4000k 1540mm (5ft) Climate Extra Single LED Array (Standard) mounted under canopy at 5.4m.
	2	EX4	SINGLE	819	0.900	6w LED 4000k Semita Urban Emergency bulkhead with cycle optic building mounted at 3m.
	3	EX4E	SINGLE	819	0.900	6w LED 4000k Semita Urban Emergency bulkhead with cycle optic building mounted at 3m.

THIS DRAWING IS INDICATIVE AND REPRESENTS ONLY THE DESIGN INTENT, THE CONTRACTOR MUST PRODUCE FULLY CO-ORDINATED WORKING / INSTALLATION DRAWINGS AS REFERRED TO IN THE CONTRACT DOCUMENTATION

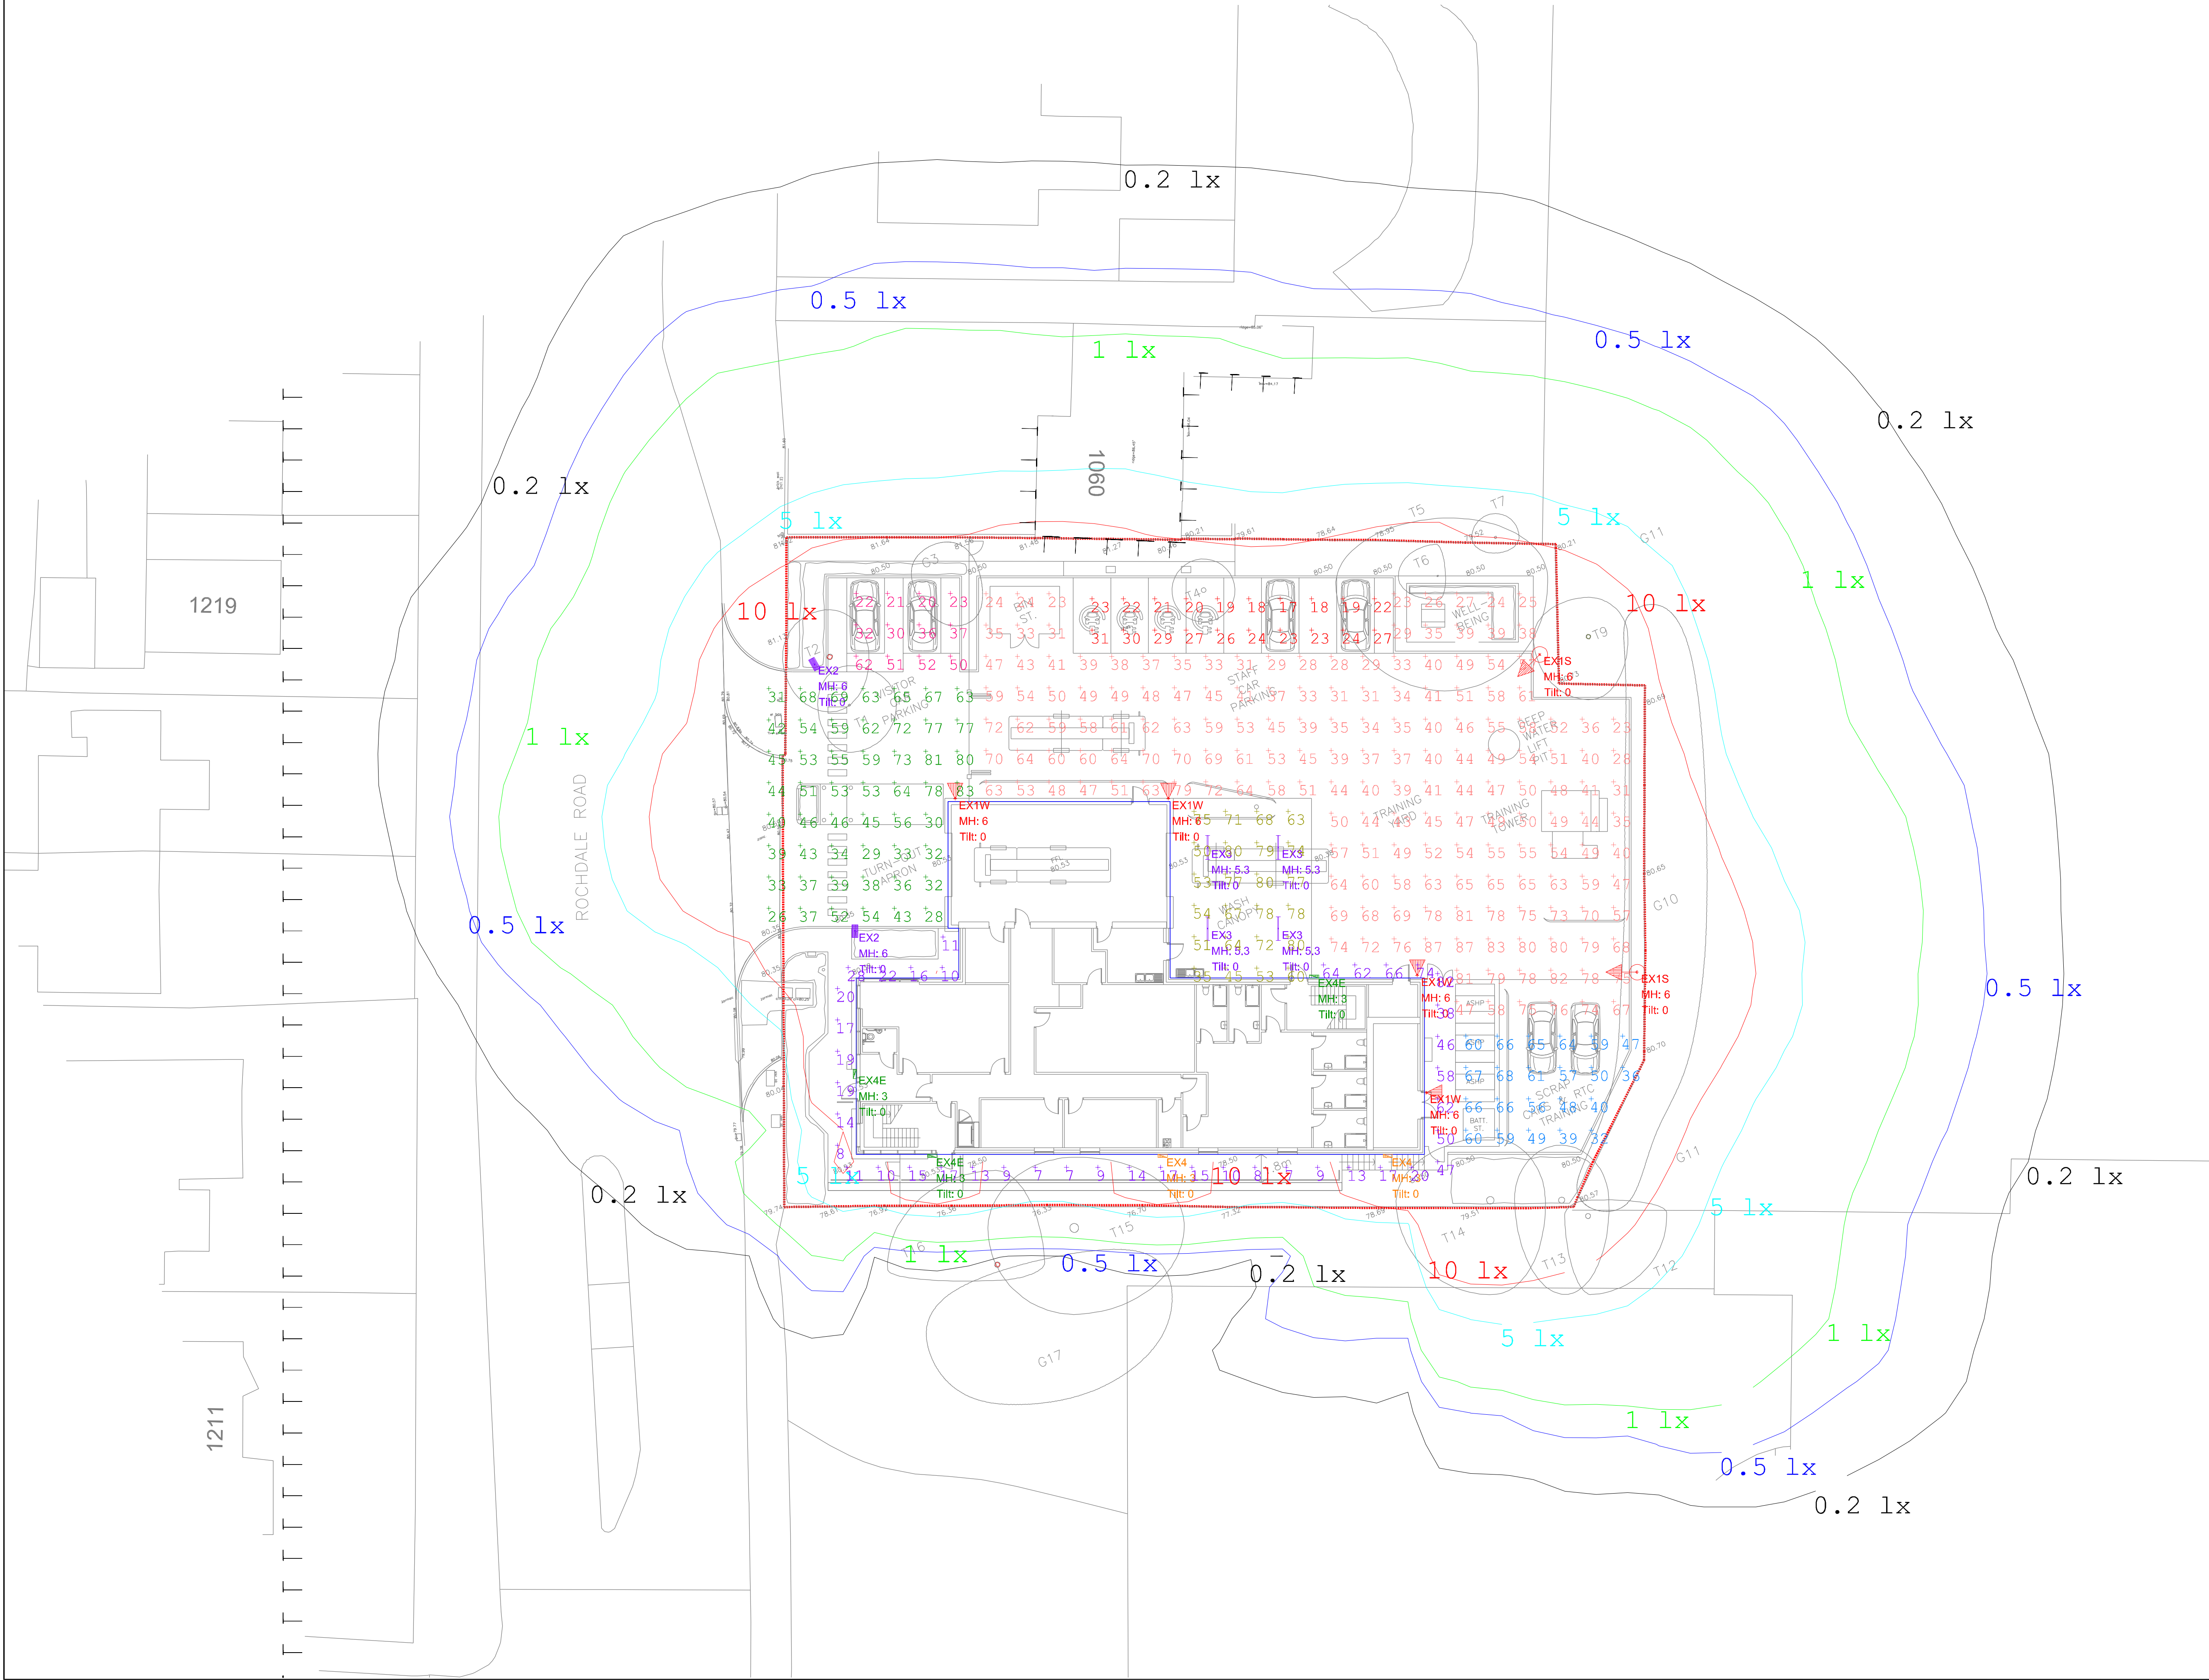

P02	ISSUED FOR STAGE 3	BT	KM	IC	04/23
P01	ISSUED FOR INFORMATION	CH	NS	KM	03/23
REV	DESCRIPTION	BY	CHK	APP	DATE

Project Status:		STAGE 3			
-----------------	--	---------	--	--	--



The Multi-disciplinary Engineering Consultancy

Core, Worldwide

Brown Street
Manchester, M2 1DH

E: mano@harleyhaddow.com
Edinburgh | Glasgow | London | Manchester
harleyhaddow.com

Association for Consulting and Engineering (ACE) Member

Project: 310367
BLACKLEY FIRE STATION

Drawing Title:
PROPOSED EXTERNAL
LIGHTING LAYOUT

Scale @ A1	Date	Engineer
1:200	MAR 2023	NS
Drawing No.	Revision	
310367-HAH-XX-00-D-E-09610	P02	