


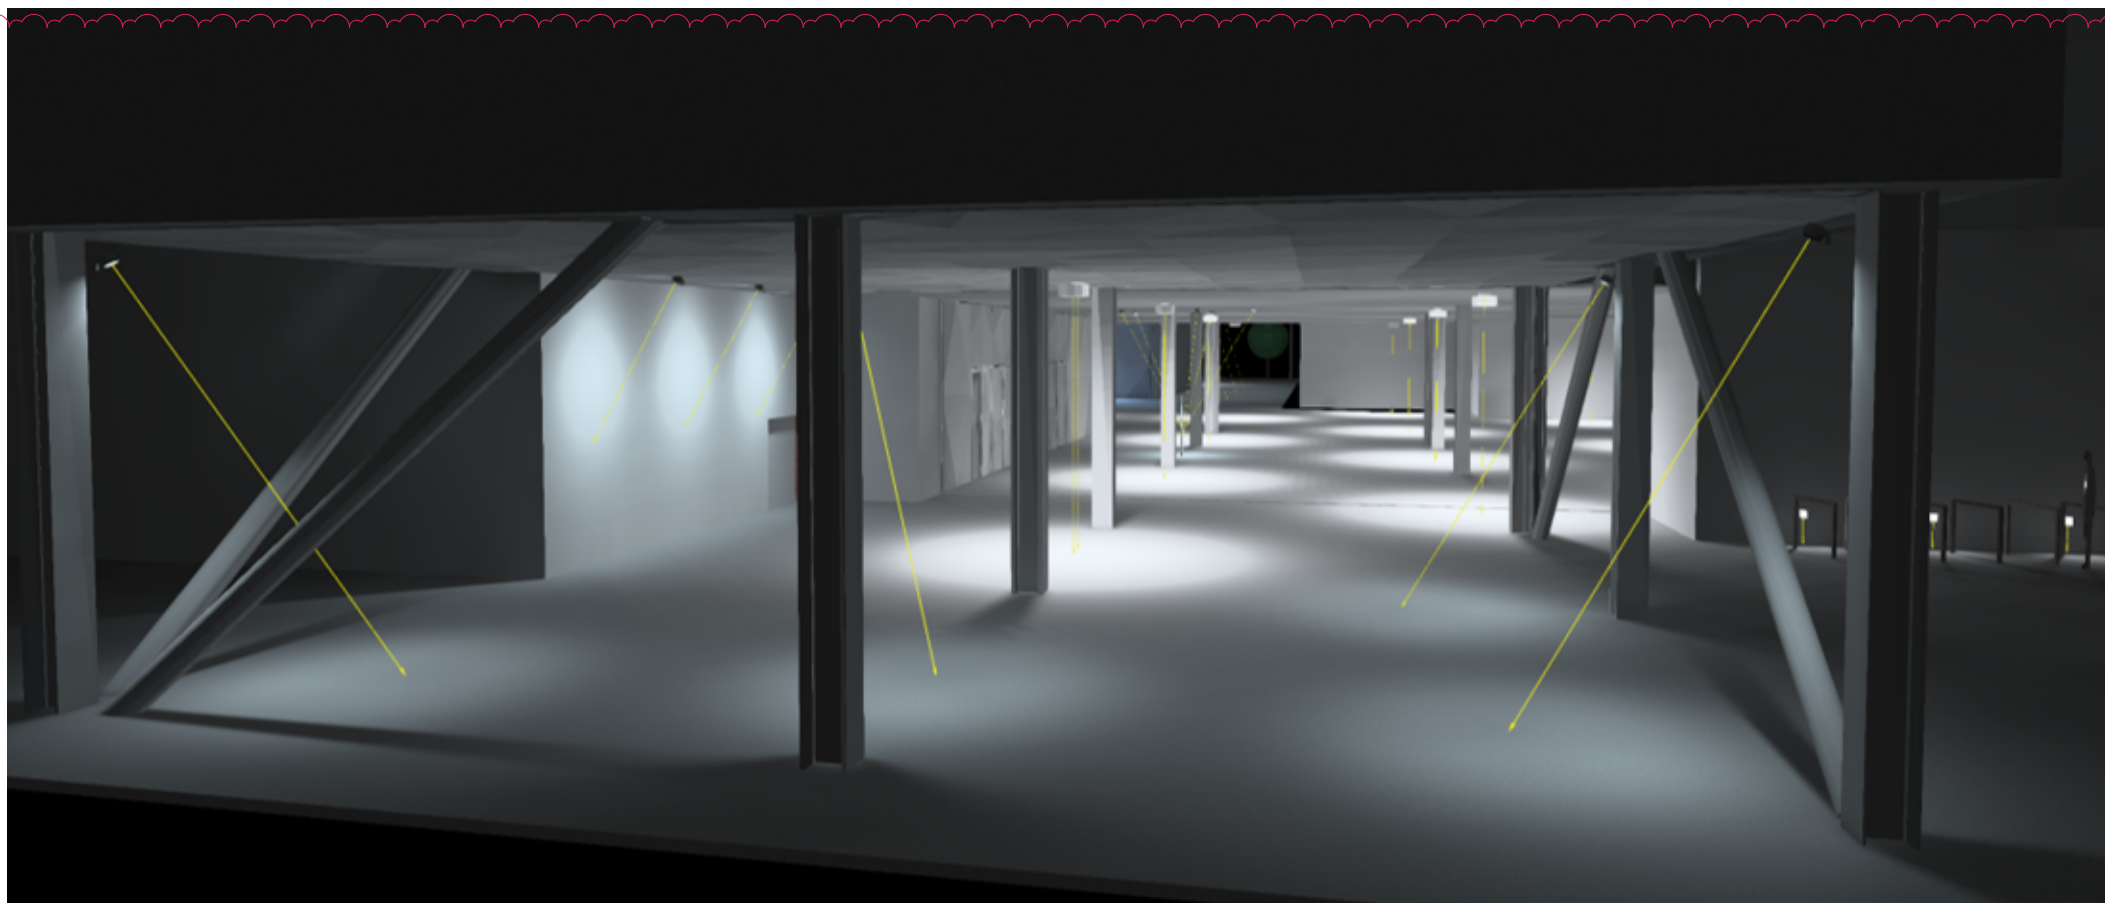


TOWERS SOFFIT

BUILDING DESIGN PARTNERSHIP SHALL HAVE NO RESPONSIBILITY FOR ANY USE MADE OF THIS DOCUMENT OTHER THAN FOR THAT WHICH IT WAS PREPARED AND ISSUED.
ALL DIMENSIONS SHOULD BE CHECKED ON SITE.
DO NOT SCALE FROM THIS DRAWING.
ANY DRAWING ERRORS OR DIVERGENCES SHOULD BE BROUGHT TO THE ATTENTION OF BUILDING DESIGN PARTNERSHIP AT THE ADDRESS SHOWN BELOW.
DRAWINGS SHALL BE READ IN CONJUNCTION WITH THE FOLLOWING BEFORE WORK COMMENCES:
• THE CDM DESIGN ISSUES REGISTER
• THE BDP RISK SERIES OF DRAWINGS
• THE PROJECT CDM RISK REGISTER

NOTES

1. THE INFORMATION SHOWN ON THIS DRAWING IS BASED UPON THE MODEL AND DRAWINGS ISSUED BY THE PROJECT ARCHITECT ON THE DATES AS INDICATED BELOW.
2. THIS DRAWING SHALL BE READ IN CONJUNCTION WITH THE LUMINAIRE SCHEDULE AND LIGHTING SPECIFICATION.
3. THIS IS NOT A COORDINATED WORKING OR INSTALLATION DRAWING.
4. THE PURPOSE OF THIS DRAWING AND THE ASSOCIATED BIM MODEL IT HAS BEEN DERIVED FROM IS TO PROVIDE A LEVEL OF DETAIL SUITABLE FOR BPPA PRO-FORMA 4A - TECHNICAL DESIGN.
5. DO NOT SCALE FROM THIS DRAWING. ALL DIMENSIONS ARE IN MILLIMETERS UNLESS OTHERWISE STATED.
6. LUMINAIRES WITH PREFIX OR SUFFIX 'E' ARE EMERGENCY LUMINAIRES WITH INTEGRAL 3HRS BATTERY. LUMINAIRES WITH SUFFIX 'CE' ARE EMERGENCY LUMINAIRES TO HAVE CENTRAL BATTERY. LUMINAIRES WITH SUFFIX 'SE' ARE EMERGENCY LUMINAIRES TO HAVE CENTRAL BATTERY SUPPLY WITH DUAL SUPPLY AND INTEGRAL CHARGE OVER-WITHIN.
7. ALL EXITS TO HAVE FINAL EXIT EMERGENCY LUMINAIRE LOCATED WITHIN 2M.
8. REVIEW AND COORDINATION OF EMERGENCY LIGHTING LOCATIONS REQUIRED TO COORDINATE WITH ONGOING ARCHITECTURAL UPDATES.
9. REVIEW AND COORDINATION OF LUMINAIRE LOCATIONS REQUIRED TO COORDINATE WITH ONGOING ARCHITECTURAL UPDATES.
10. REFER TO ELECTRICAL LAYOUT DRAWINGS FOR INFORMATION ON FEASIBLE DRIVER LOCATIONS AND CABLE ROUTING.
11. IN AREAS WITH NO DAL CONTROL, CERTAIN LUMINAIRE TYPES TO BE SUPPLIED WITH PRE-SET DIMMING LEVELS. REFER TO LUMINAIRE SCHEDULE FOR DETAILS.
12. BOTH THE LATEST OMA AND EXTER MODELS ARE SHOWN. THE OMA MODEL PROVIDES VISUAL DETAILS THAT ARE NOT CURRENTLY PRESENT IN THE EXTER MODEL. THIS IS REQUIRED TO DEMONSTRATE THE DESIGN INTENT OF THE LIGHTING PROPOSAL.

C03	CONTRACT ISSUE	NM	CL	16.07.22
C02	CONTRACT ISSUE	NM	CL	16.10.21
C01	CONTRACT ISSUE - VE ALTERATIONS	RD	NMCL	13.11.20
Rev	Description	By	Check	Date
The design illustrated upon this drawing has been coordinated with the following discipline models:				
Rev	Discipline	Model Name	Model Ref	Model Date
A	OMA	MF-OMA-XX-XX-80-A-00-0001	(P3)	
S	Buro Happold	MF-SHE-XX-XX-80-S-00-0002	(P3)	
Y	Chancel Blue	MF-CBL-XX-XX-80-Y-01-0001	(P3)	
A	Byder	MF-BYD-XX-XX-80-A-00-0001	(P3)	

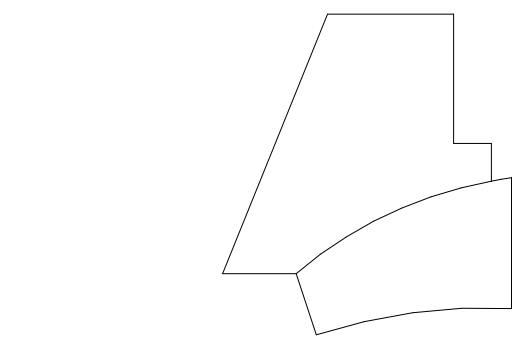

MANCHESTER CITY COUNCIL
Albert Square, Town Hall,
M2 5DB, Manchester
United Kingdom
T +44 (0) 161 234 5004

11 Ducie Street
PO Box 85
Piccadilly Basin
Manchester
M60 3JA
United Kingdom
T +44 (0)161 628 2200
www.bdp.com

BDP.

Contract

P2008093
Manchester Factory

Electrical Engineering Services

Warehouse
Ground Floor
Lighting Systems
Reflected Ceiling Plan

Project Code	Client	Issue Date	Scale	Drawn By
CC	NM	13/11/20	1:100	@AD
MF-BDP-WH-GF-DR-E-70-8002	C03			