


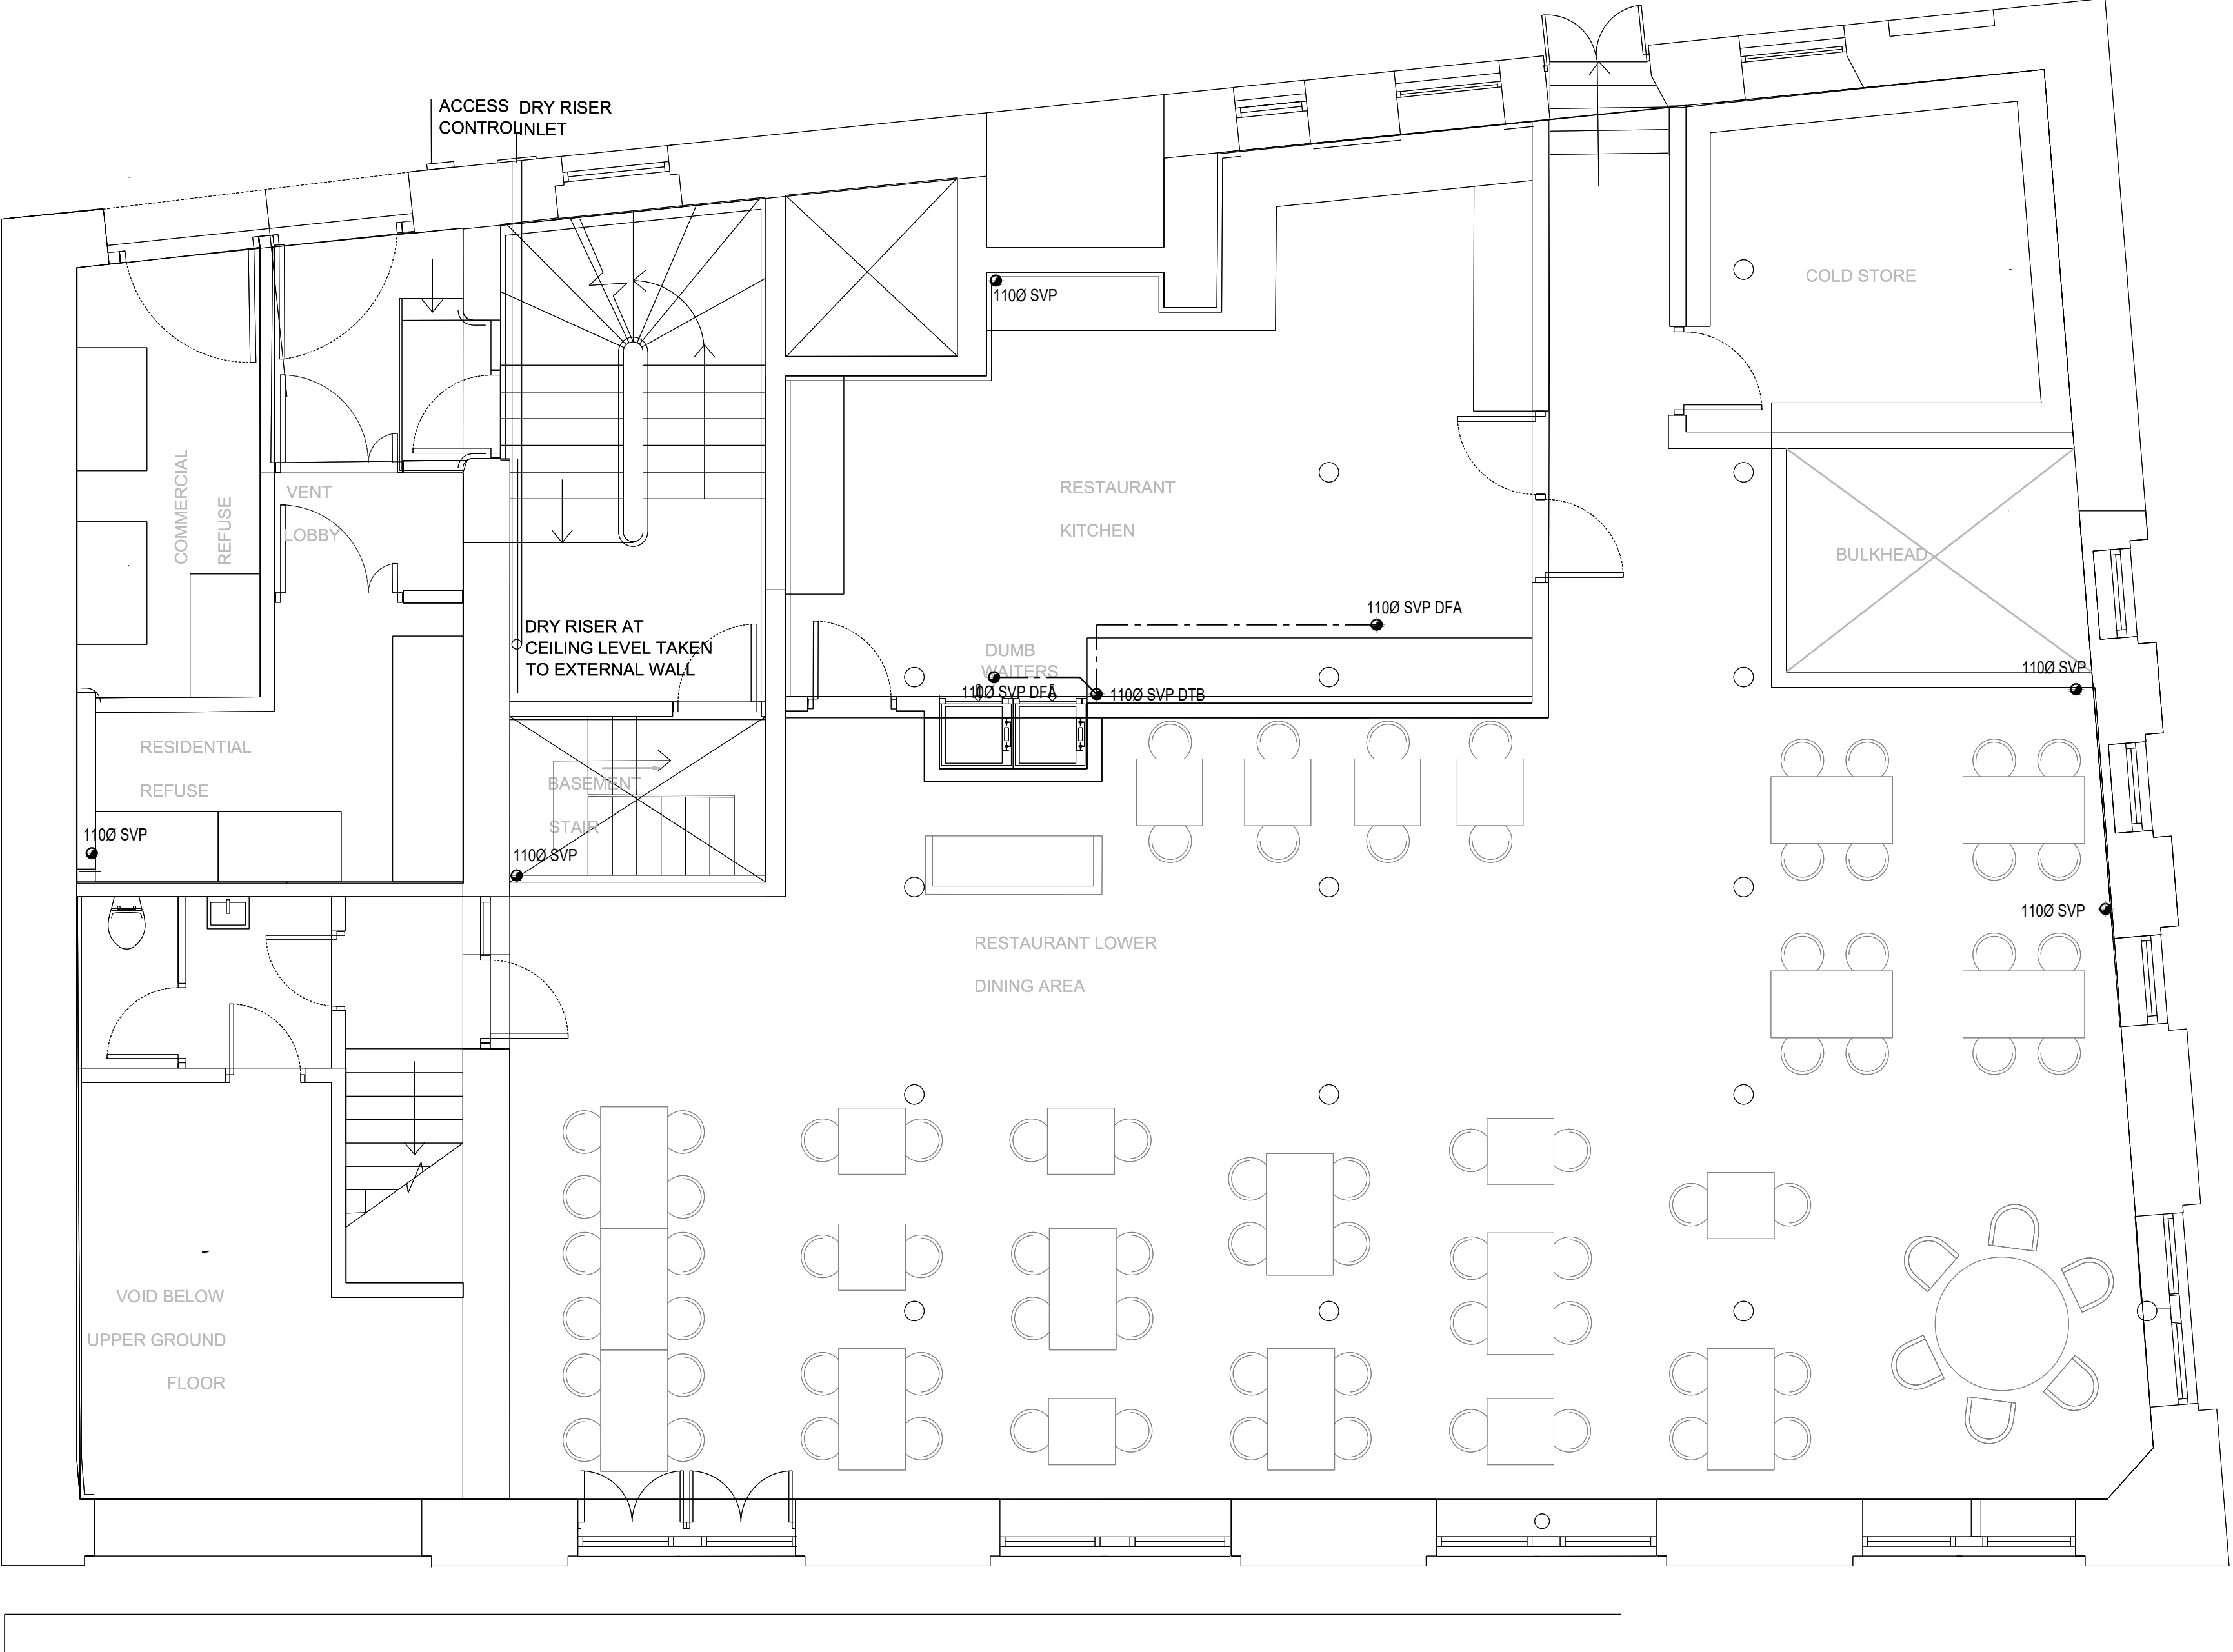

- NOTES
1. ALL SERVICE ROUTES DETAILED ARE APPROXIMATE. THE CONTRACTOR SHALL BE RESPONSIBLE FOR DETERMINING THE EXACT ROUTES AND POSITIONS OF ALL INSTALLED SERVICES AND EQUIPMENT.
 2. THE EXACT POSITION OF ALL SERVICES AND EQUIPMENT SHALL BE AGREED BY THE CONTRACT ADMINISTRATOR.
 3. THE CONTRACTOR SHALL BE RESPONSIBLE FOR FULLY CO-ORDINATING ANY SERVICES INSTALLED WITH THE BUILDING FABRIC AND SERVICES INSTALLED BY OTHERS.
 4. THIS DRAWING SHALL BE READ IN CONJUNCTION WITH ALL MECHANICAL, ELECTRICAL, ARCHITECTURAL AND STRUCTURAL DRAWINGS, CONTRACT DOCUMENTATION AND SPECIFICATION FOR THE WORKS.
 5. THIS DRAWING FORMS PART OF THE SPECIFICATION FOR THE WORKS.
 6. ALL DIMENSIONS SHOWN ARE IN MILLIMETRES.
 7. DO NOT SCALE FROM THIS DRAWING.
 8. EXISTING SERVICES SHOWN FAINT.

READ IN CONJUNCTION WITH
PWC REPORT: 4193-SSR-001

P3	12-05-23	ISSUED FOR INFORMATION
P2	21-12-22	ISSUED FOR INFORMATION
P1	02-12-22	ISSUED FOR INFORMATION
REV	DATE	REVISION DESCRIPTION
CLIENT THE SPACE STUDIO		
PROJECT FRASER HOUSE 36 CHARLOTTE STREET MANCHESTER		
TITLE MECHANICAL SERVICES - DRAINAGE LAYOUT LOWER GROUND LEVEL		
		
■ Burnham House, 373 Bury New Road, Manchester, M25 1AW T: 0161 773 1177 F: 0161 773 9977 manchester@parker-wilson.co.uk □ 2nd Floor, 72, Cannon Street, London EC4N 6AE T: 0207 251 4500 london@parker-wilson.co.uk www.parker-wilson.co.uk		
DRAWN BY J.F.	CHECKED B.P.	APPROVED BY P.G.
SCALE 1:50	SIZE A1	DATE November 2022
DRAWING No 4193-LG-SK112	REV P3	

PRELIMINARY