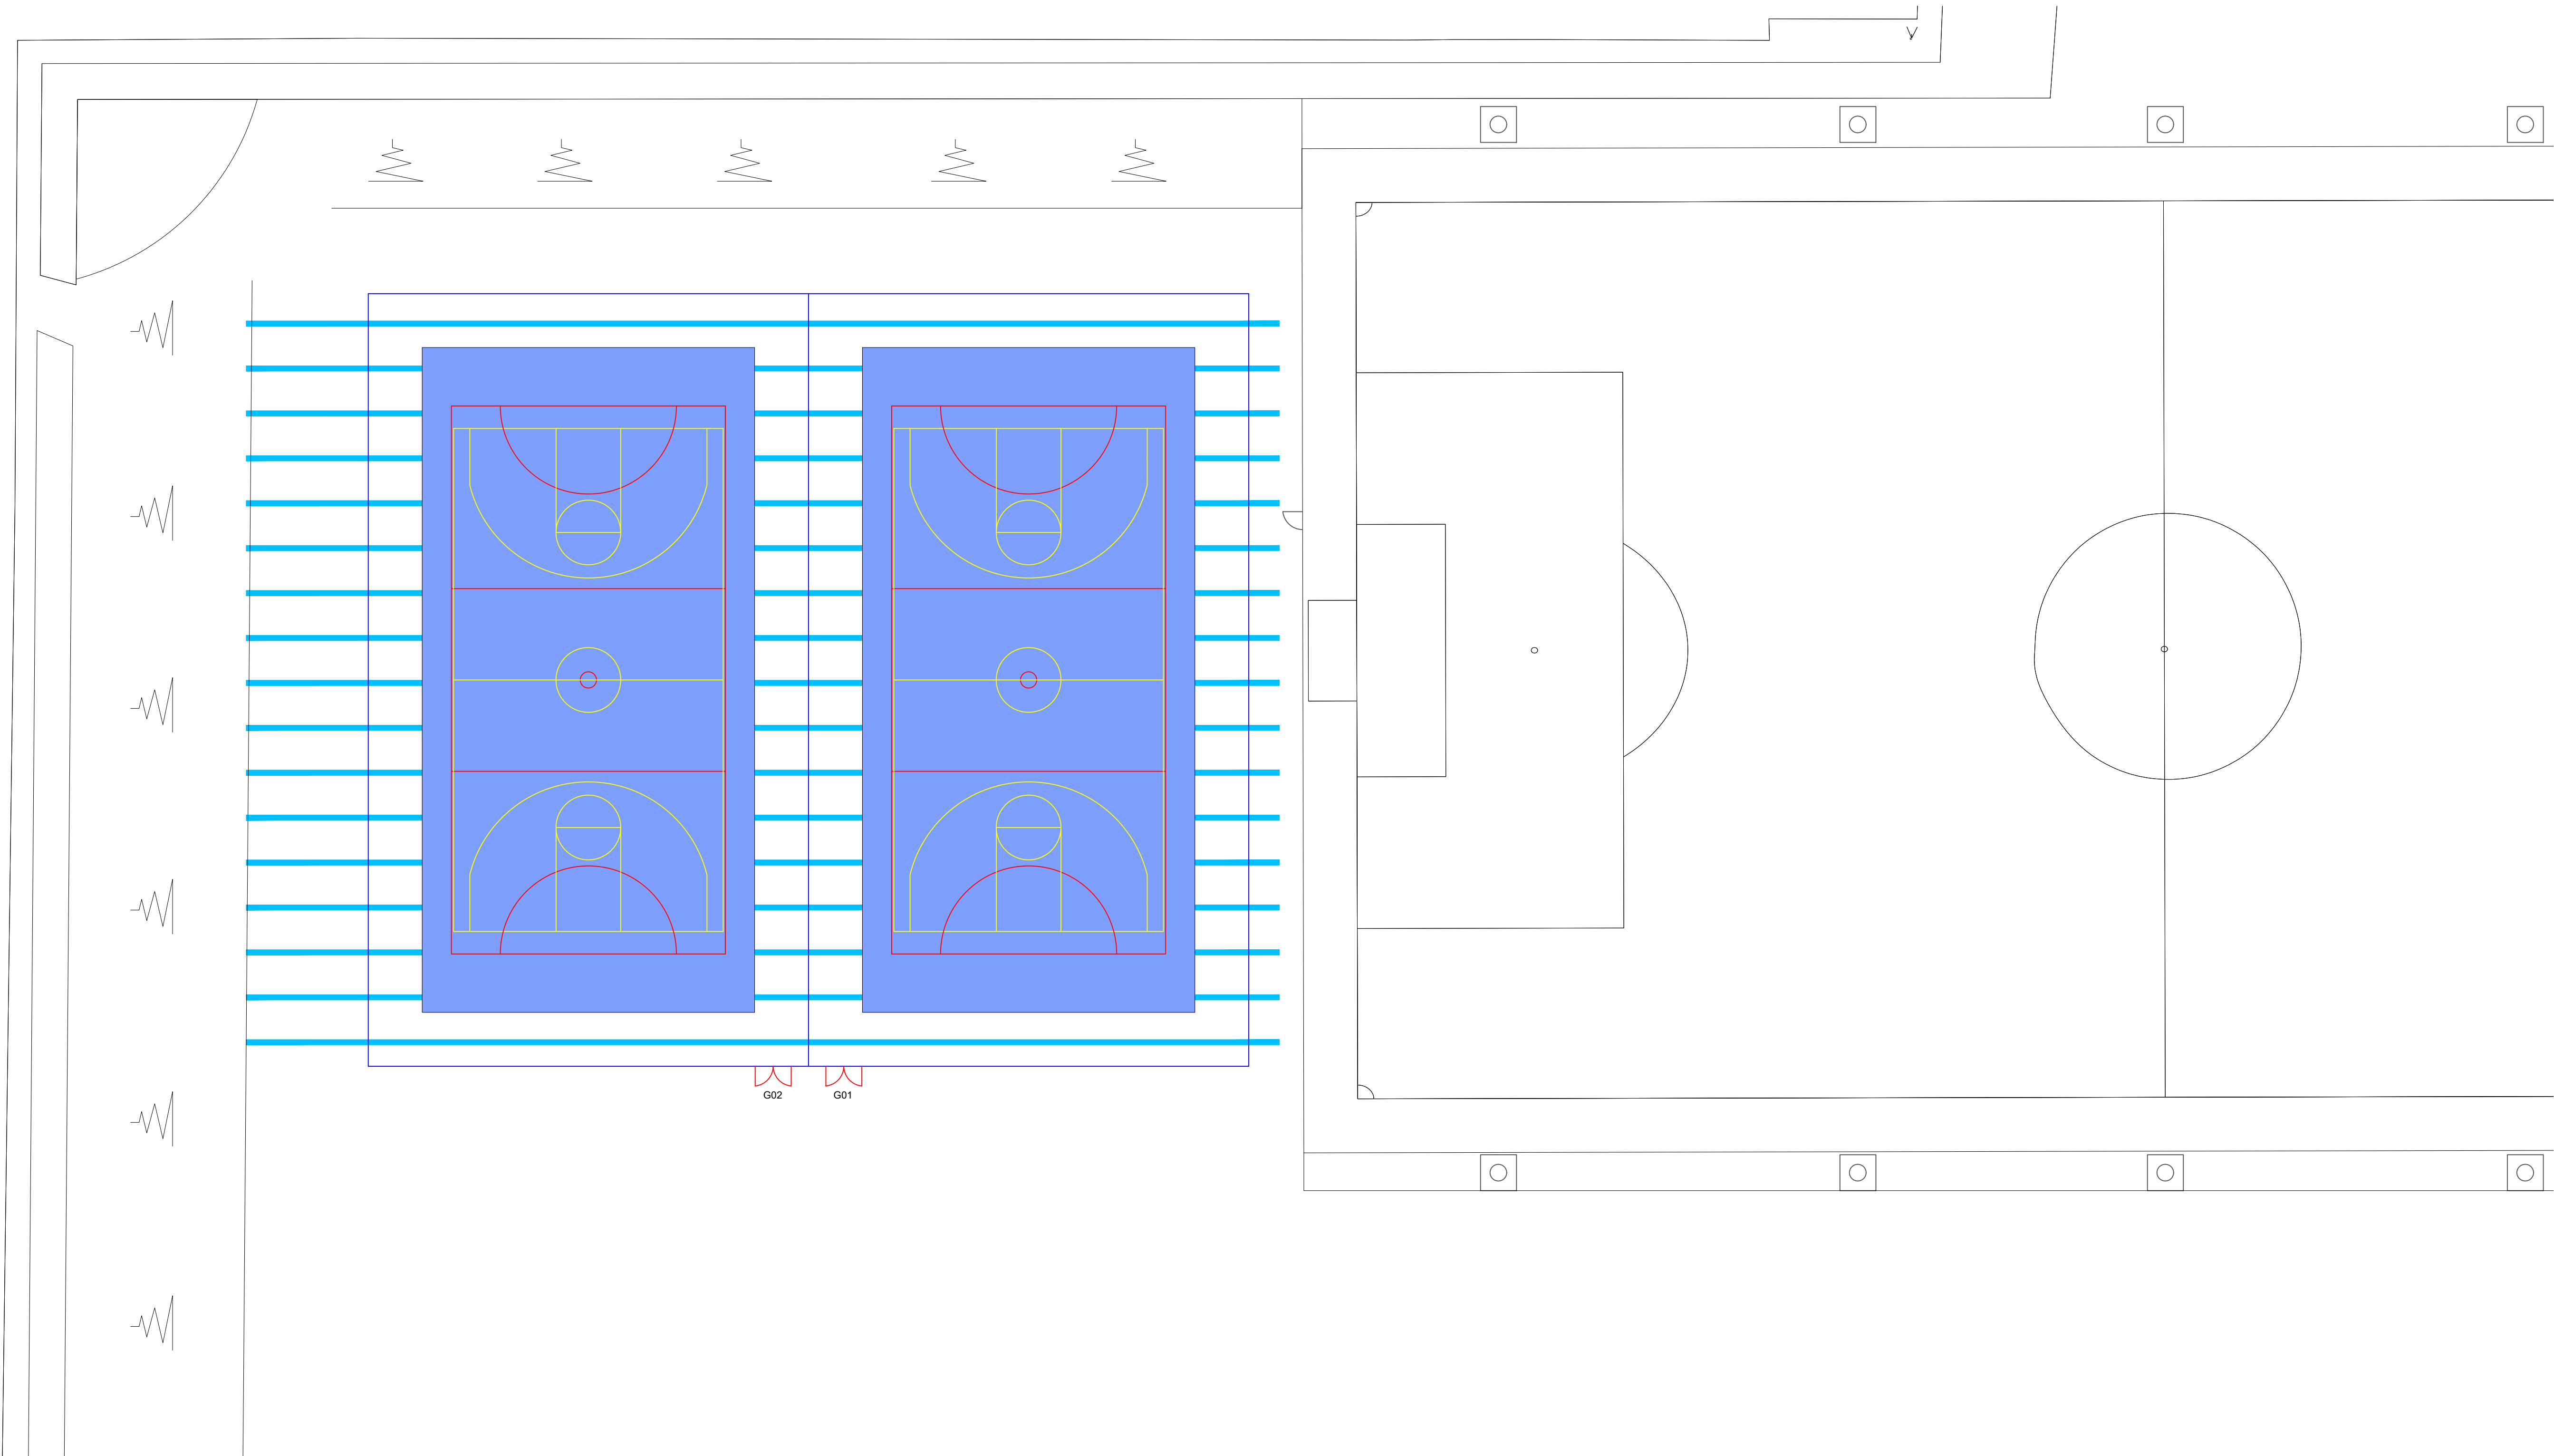


©
This drawing is Copyright and the property of Lancaster Maloney Limited and must not be reproduced in whole or in part without their written permission. Copyright is reserved. ©
This drawing must not be scaled. The Contractor is to report all dimensional discrepancies & errors to the Contract Administrator prior to commencing construction.
It is essential that this drawing is read in conjunction with the specification and all works identified included for.

NOTES

LEGEND

Surface
Water

Rev	Date	Comments	By
-----	------	----------	----

STATUS
PLANNING

Client
The East Manchester Academy, Beswick M11 3DS

Project Title
Increased Sport Provision

Drawing Title
Proposed Drainage Plan

Scale 1:200 @A1	Drawn by MMcD	Date Feb 2023
Job no. 2209-02	Drawing no. P06	Revision no. -

lancastermaloney
Lancaster Maloney Limited Registered Office:
Equitas House Unit 6 Station View Rhino Court Stockport SK7 5ER
Tel: 0161 477 3500 Fax: 0161 477 3600
E-mail: enquiries@lancastermaloney.co.uk www.lancastermaloney.co.uk
Registered in England No 4846621