


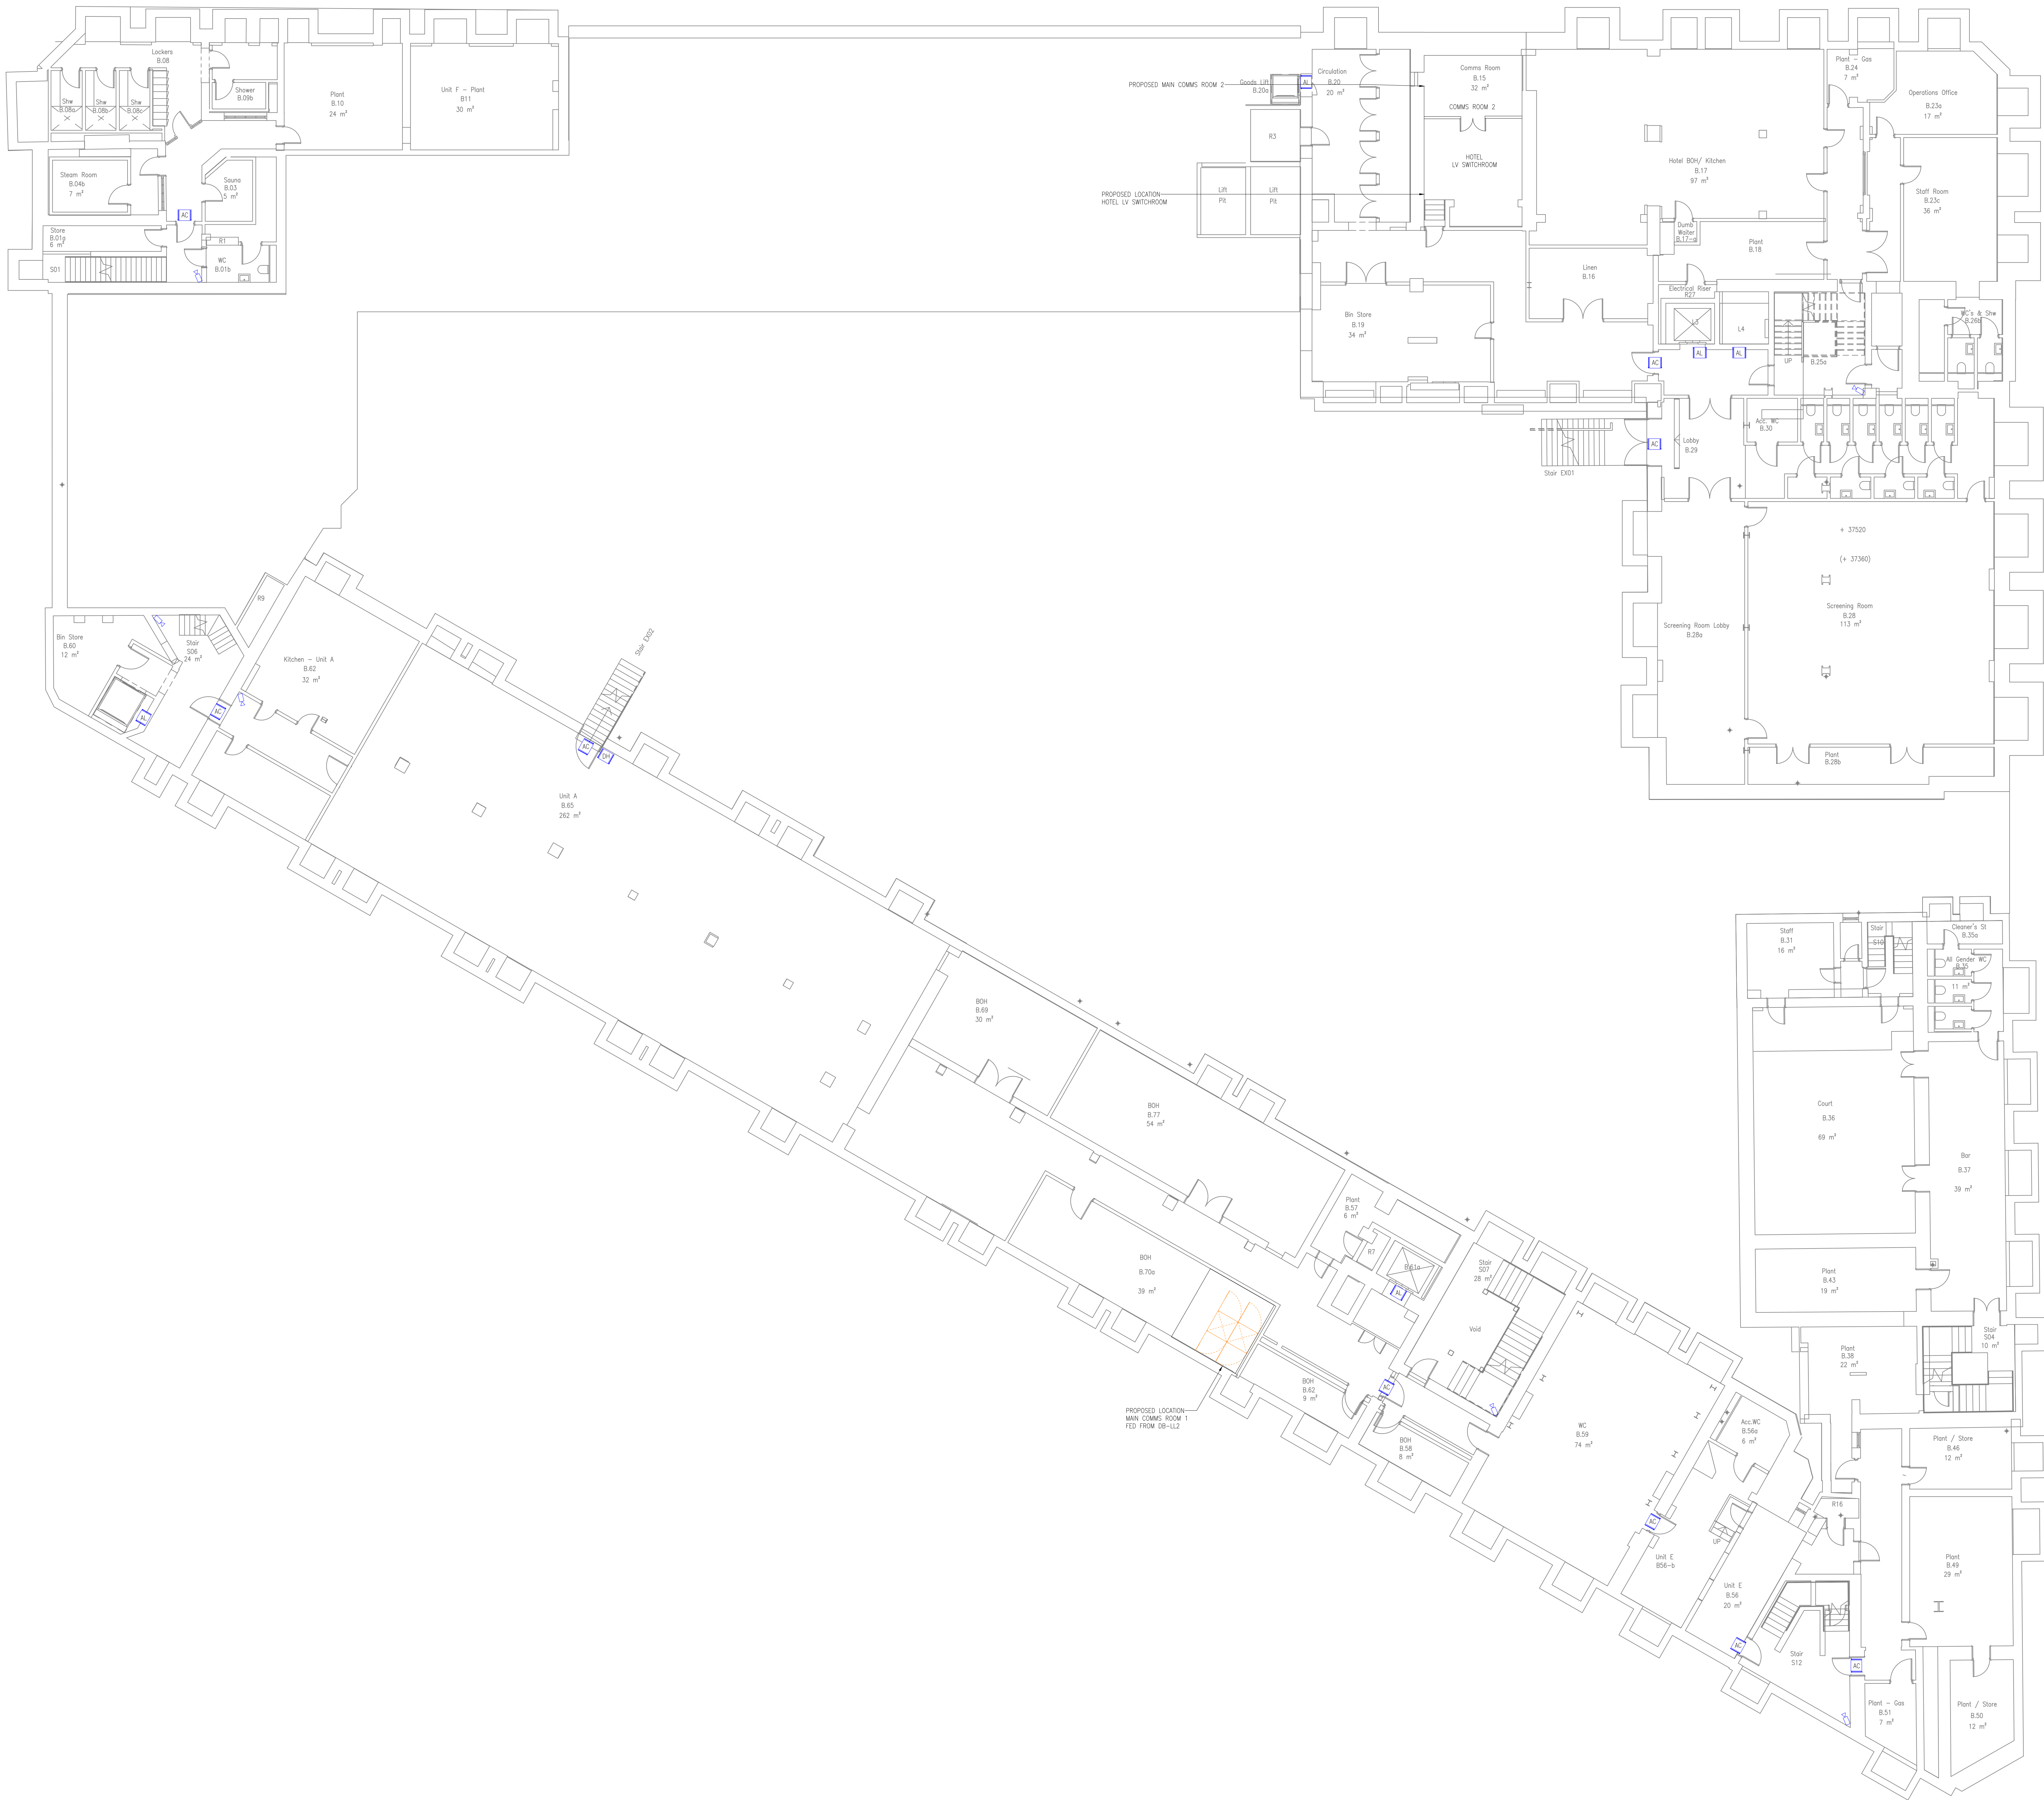

NOTES

1. DO NOT SCALE FROM THIS DRAWING
2. ALL DIMENSIONS TO BE CHECKED ON SITE BY THE CONTRACTOR PRIOR TO REINFORCEMENT OF SHOP DRAWINGS, FABRICATION OF PARTS, ORDERING MATERIALS OR COMMENCING WORKS
3. THIS DRAWING IS TO BE READ IN CONJUNCTION WITH ALL OTHER CONSULTANT'S DRAWINGS, SPECIFICATIONS AND SCHEDULES.
4. ANY VARIATION THROUGH FLOOR, SEX, STRUCTURAL ENGINEERS APPROVAL BEFORE COMMENCEMENT.
5. ALL PLANT AND EQUIPMENT SHALL BE INSTALLED FULLY IN ACCORDANCE WITH MANUFACTURER'S RECOMMENDATIONS

LEGEND

- CCTV CAMERA
- WEATHER PROOF CCTV CAMERA (P65)
- ACCESS CONTROLLED DOOR COMPRISED OF:
MAGLOCK (PSU)
GREEN BREAK GLASS
PUSH TO EXIT BUTTON
(MANUFACTURER - SALTO BLUENET-
WIRELESS & W+I BASED SYSTEM)
- ACCESS CONTROL FOR LIFT
(FINAL DETAILS TO BE CONFIRMED WITH LIFT
SPECIALIST/MANUFACTURER)
- DOOR INTERCOM PHONE SYSTEM
- CARD READER (HOTEL ROOM)
TYPICALLY OFF-LINE. FINAL DETAILS TBC
BY THE ACCESS CONTROL SPECIALIST
(MANUFACTURER - AFSO, SALTO - RFID,
WIRELESS & BLUETOOTH SMART)
- DOOR HOLD OPEN DEVICES

NOTE

ALL DOOR HOLD OPEN DEVICES,
ACCESS CONTROLLED DOORS & LIFTS
TO BE INTERFACED WITH THE FIRE
ALARM SYSTEM

FOR COMMENT
NOT FOR SITE USE

14.08.22	TENDER ISSUE	TS	AM/SL
13.04.22	TENDER ISSUE	TS	AM/SL
07.02.22	TENDER ISSUE	TS	AM/SL
02.06.21	INCORPORATES INTERIOR DESIGNER COMMENTS	TS	AM/SL
21.05.21	TENDER ISSUE	TS	AM/SL
26.03.21	INTERIM ISSUE FOR CLIENT COMMENTS	TS	AM/SL
26.02.21	PRELIMINARY ISSUE	TS	AM/SL
Date	Description	Rev	Drawn

CONSOLUX
CONSOLUX M&E CONSULTING LTD.
MECHANICAL & ELECTRICAL CONSULTING ENGINEERS

London Office
25 Pockley
London W1J 0DW
Tel: +44 (0)207 734 3030
Fax: +44 (0)207 617 7286
Email: mail@consolux.co.uk

Liverpool Office
The Cactus Exchange
Liverpool L3 5RB
Tel: +44 (0)151 708 9469
Fax: +44 (0)151 709 7184
www.consolux.co.uk

Project
LONDON ROAD FIRE STATION
FIRE STATION, LONDON ROAD
MANCHESTER, M1

Drawing Title
ELECTRICAL INSTALLATION SERVICES
BASEMENT FLOOR
SECURITY LAYOUT

Date	Design By	Drawn By	Scale
24.03.21	FR	BRW	1:100

Issue Status TENDER	Drawing Number 647-E-1641-S1-01	Rev TS
------------------------	------------------------------------	-----------