


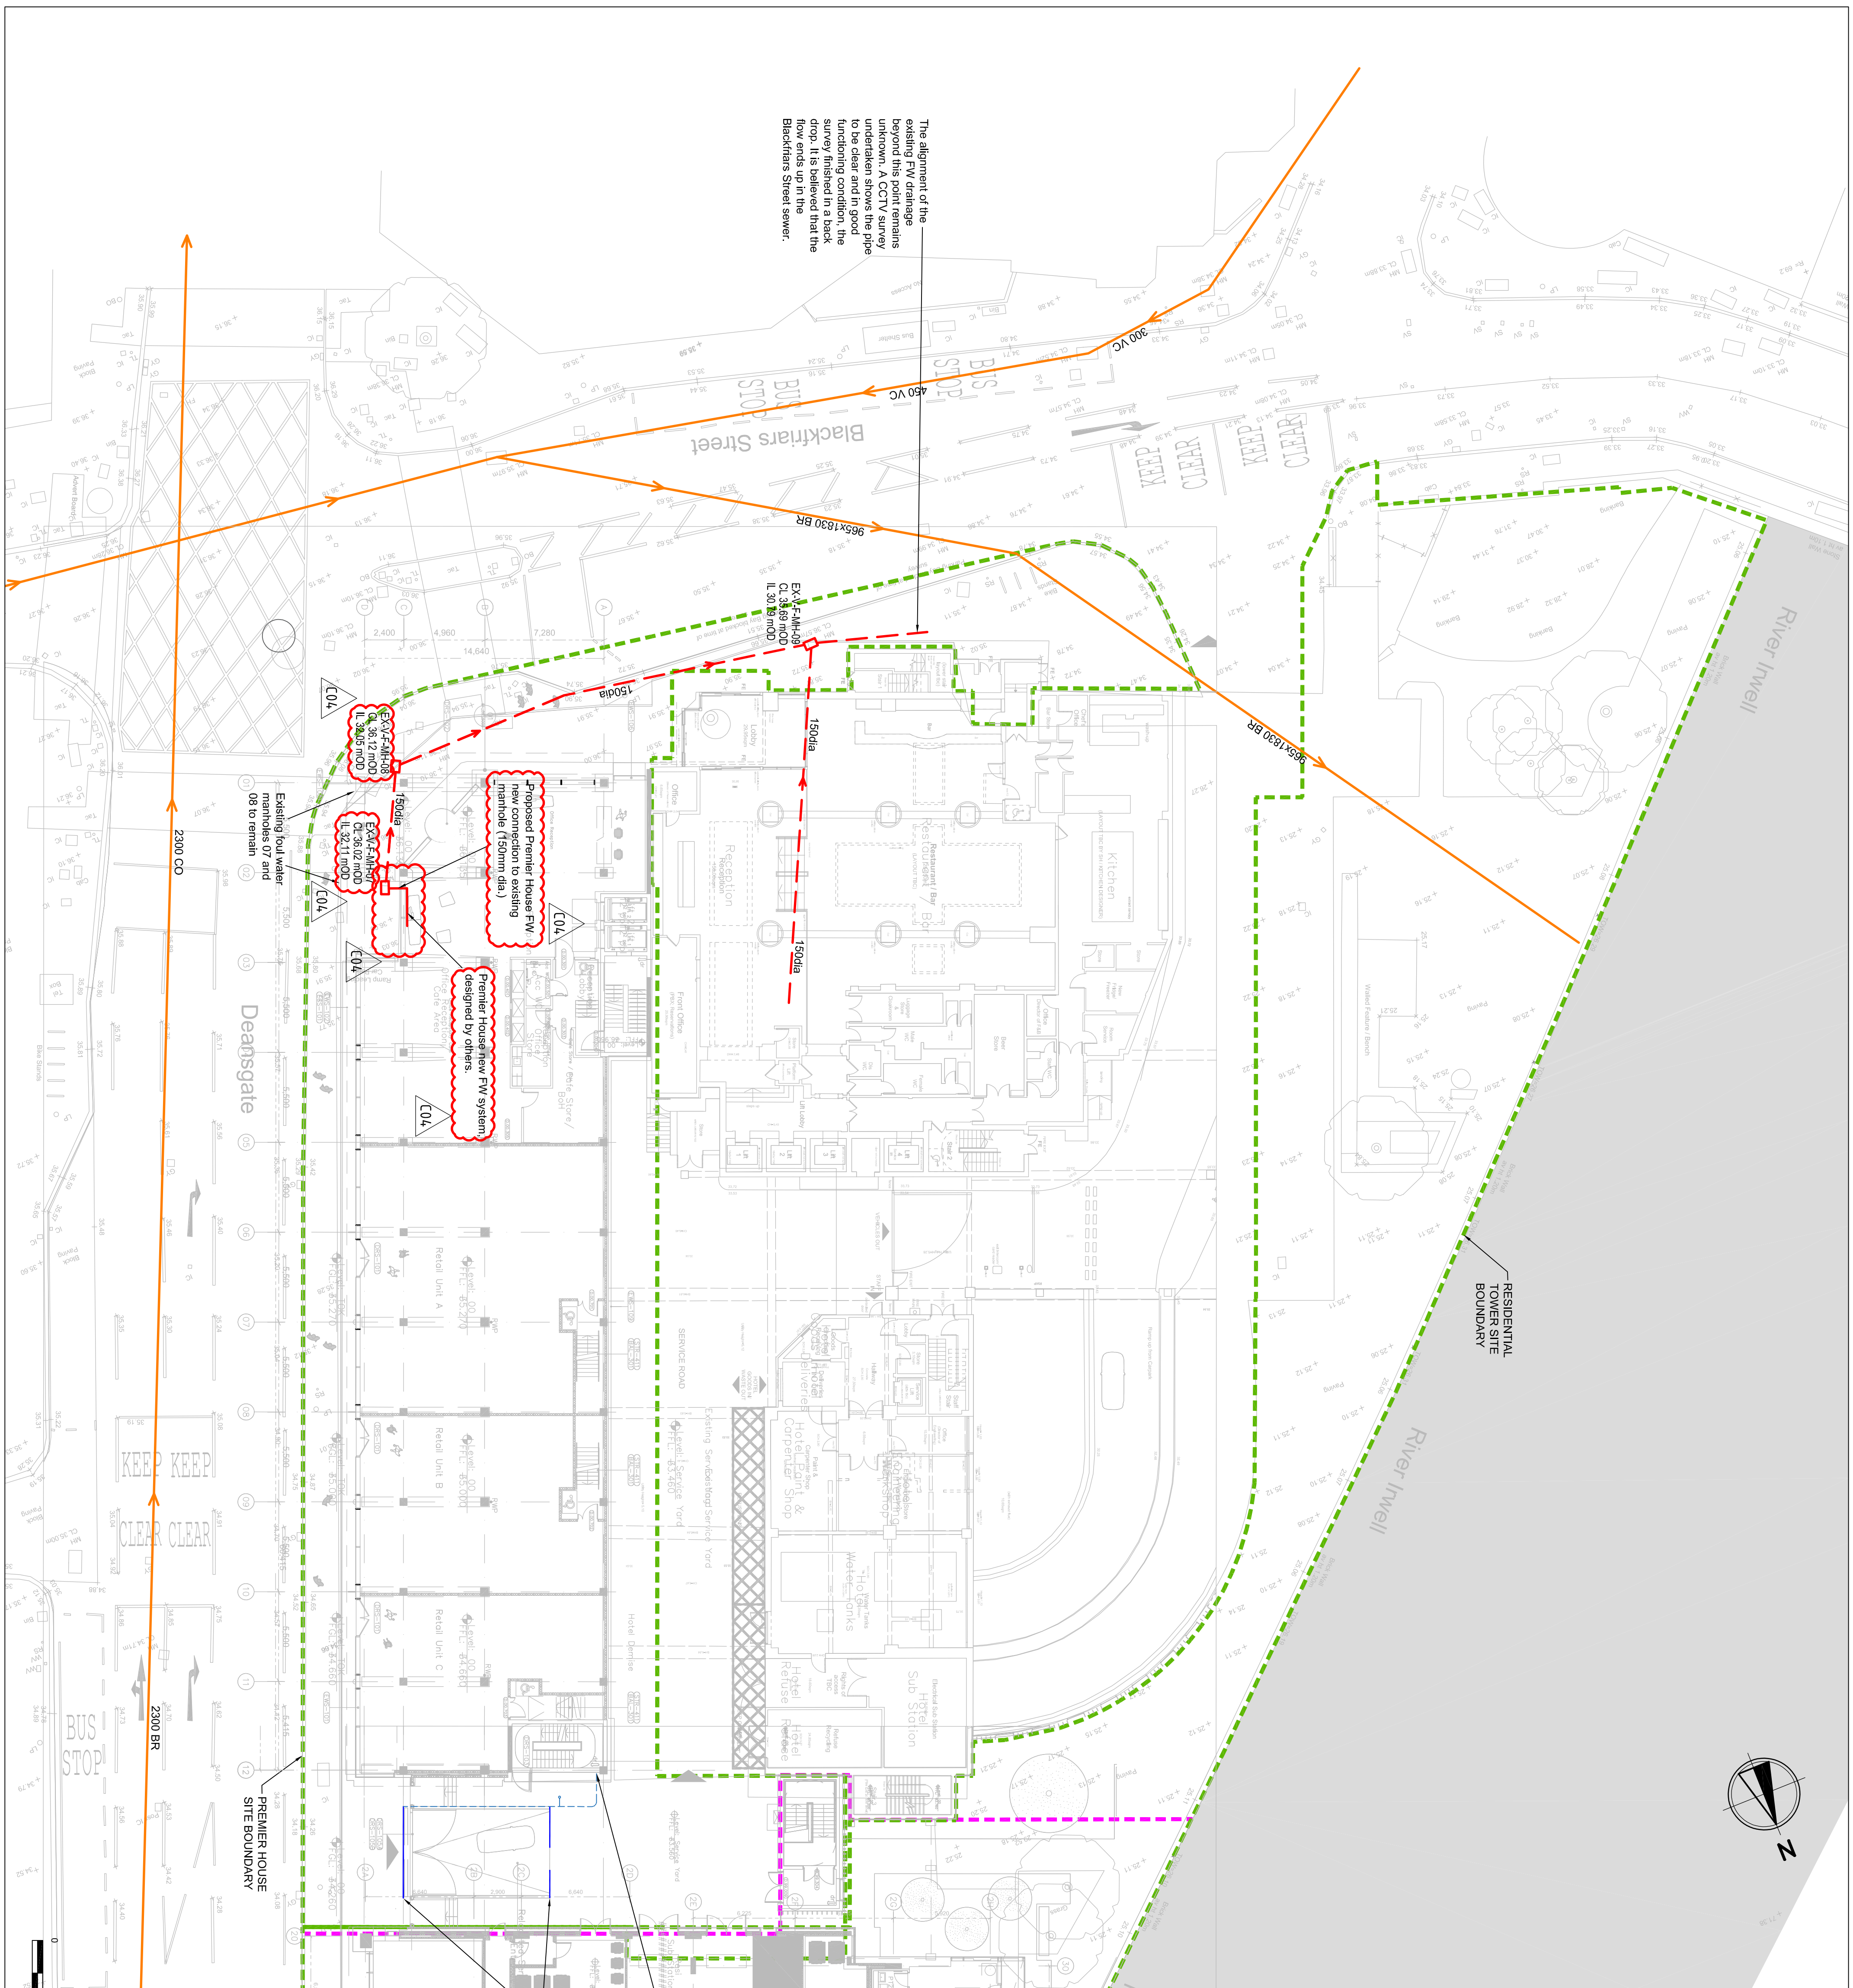

- [illegible]

LEGEND	
EXISTING	PROPOSED P/C DRAINAGE PIPES
	EXISTING P/C WATER DRAINAGE
	EXISTING U/I SEWER
	EXISTING P/C WATER DRAINAGE TO BE DEMOLISHED/DECOMMISSIONED
	EXISTING P/C WATER DRAINAGE TO BE DEMOLISHED/DECOMMISSIONED
	EXISTING U/I SEWER TO BE DEMOLISHED/DECOMMISSIONED
	PROPOSED SURFACE WATER CHANNEL DRAINS
	PROPOSED P/C WATER DRAINAGE
	PROPOSED U/I SEWER
	DEMOLITION LINE
	SITE PLANNING BOUNDARY

PROPERTY
ALLIANCE
GROUP LTD

ALLIANCE



London Office —
163 Tower Bridge Road,
London, SE1 3JW
P 44 (0) 7999 968 245
E / info@bgeeng.com
bgeeng.com —

**BG
&T**

RENAISSANCE

GENERAL

ISSUED FOR CONSTRUCTION

BOARD	DESIGNED	THICKENED	APPROVED
PB	JP (CE)	DF (CE)	LJK
DATE	GRD	SCALE	
OSGB36	BNG	1:200	

AT A1 SIZE

PROPOSED DRAINAGE - UPPER LEVEL
- SHEET 1

PROJECT No.	DRAWING No.	REV.
L20081	REN-BGE-C-GEN-060	C04