


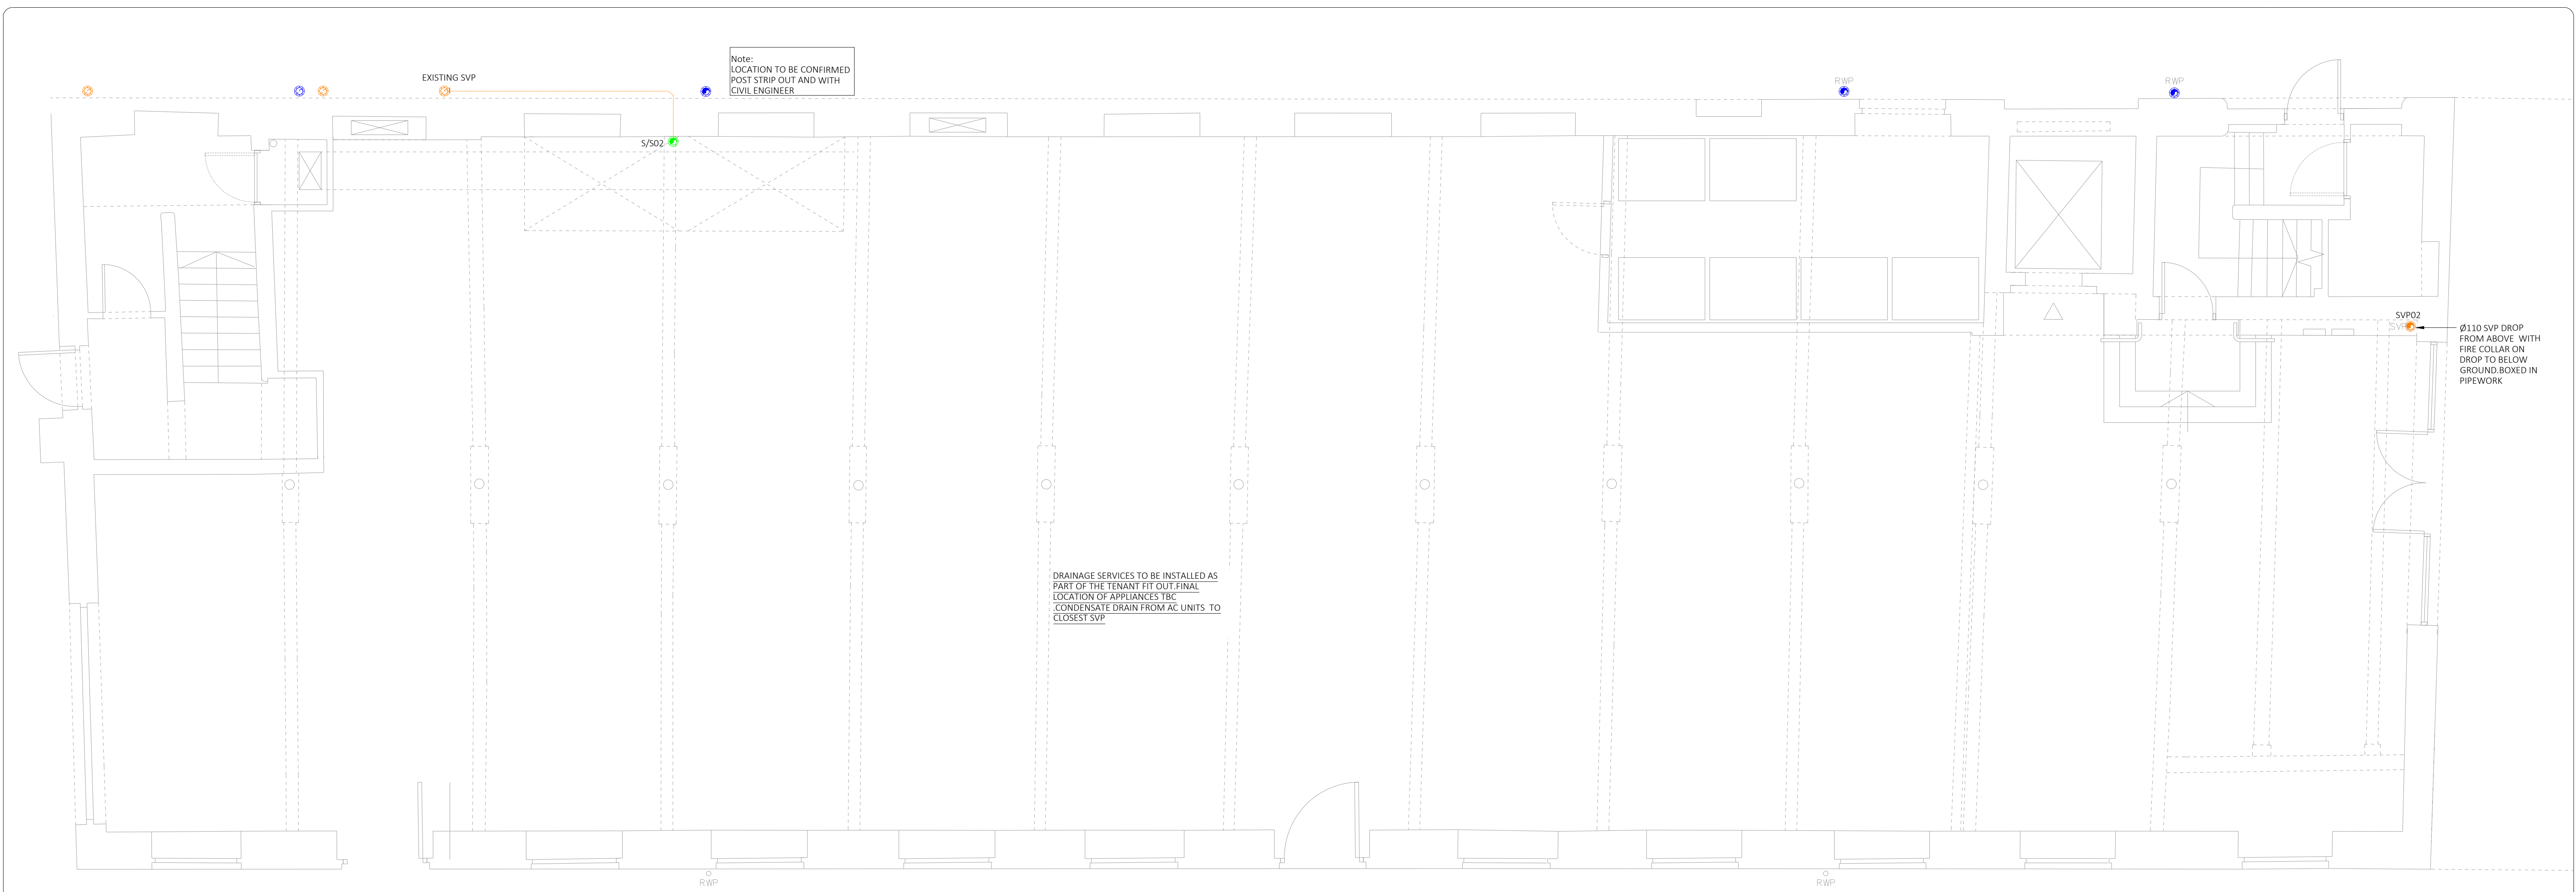

DRAINAGE LEGEND

SVP	110Ø SOIL AND VENT PIPE	VENT	VENT PIPE
S/S	110Ø STUB STACK C/W AIR	RWP	RAIN WATER PIPE
RE	RODDING EYE	PIPEWORK CONCEALED AT HIGH LEVEL	
FG	FLOOR GULLY	PIPEWORK CONCEALED AT LOW LEVEL	
AAV	AIR ADMITTANCE VALVE		

- Notes:**
- This drawing is subject to copyright and is not to be reproduced in part or whole without approval.
 - Do not scale this drawing - check all dimensions on site.
 - This drawing shall be read in conjunction with the project specification(s) and all other contract documentation.
 - All dimensions are in millimetres unless otherwise stated.
 - Location of all equipment shown shall be confirmed/approved with the Client/Architect/Engineer prior to any installation.
 - This drawing must be read in conjunction with Mechanical and Electrical performance specifications and all other drawings as issued by the Architect, Structural Engineer and Watt Energy and Consulting Engineers.
 - The location of equipment is typical only. The Contractor shall perform all calculations to determine the exact quantity and agree the final locations with the Architect.
 - This drawing shows the intended location of building services plant and service routes in such detail as to indicate the design. The drawing does not show all components that may be necessary to provide a full working installation.
 - The positions of connection points, accessories and building services items are approximate and shown for guidance to assist during the tender process.
 - Fully co-ordinated drawings, Construction drawings and Builderswork drawings shall be produced by the contractor. Under no circumstances shall the tender drawings be used as installation drawings.

WE&CE DRAWINGS ARE FOR DESIGN INTENT ONLY.
THE MEP CONTRACTOR IS RESPONSIBLE FOR THE
FINAL INSTALLATION DRAWINGS INCLUDING ALL
SETTING OUT, DIMENSIONS, ALIGNMENT AND
COORDINATION WITH THE ARCHITECTS
REQUIREMENTS.

T2	04/07/23	TENDER ISSUE	DG
T1	11/04/23	TENDER ISSUE	DK
P2	24/03/23	PRELIMINARY ISSUE	MG
P1	10/03/23	PRELIMINARY ISSUE	MG
Rev:	Date:	Status/Amendments:	By:




40 KING STREET, MANCHESTER, M2 6BA
TEL: 0161 434 3103 EMAIL: office@wece.co.uk

Client:
CAPITAL AND CENTRIC

Project:
CHAPELTOWN WAREHOUSE

Drawing Title:
MECHANICAL SERVICES
ABOVE GROUND DRAINAGE LAYOUT
GROUND FLOOR

Drawn By: MG	Checked By: DW	Cad By: DK
Scale: 1:50	Paper Size: A1	Date Created: 15/02/2023
Drawing Number: WECE / 353 / M / 100	Drawing Revision: T2	

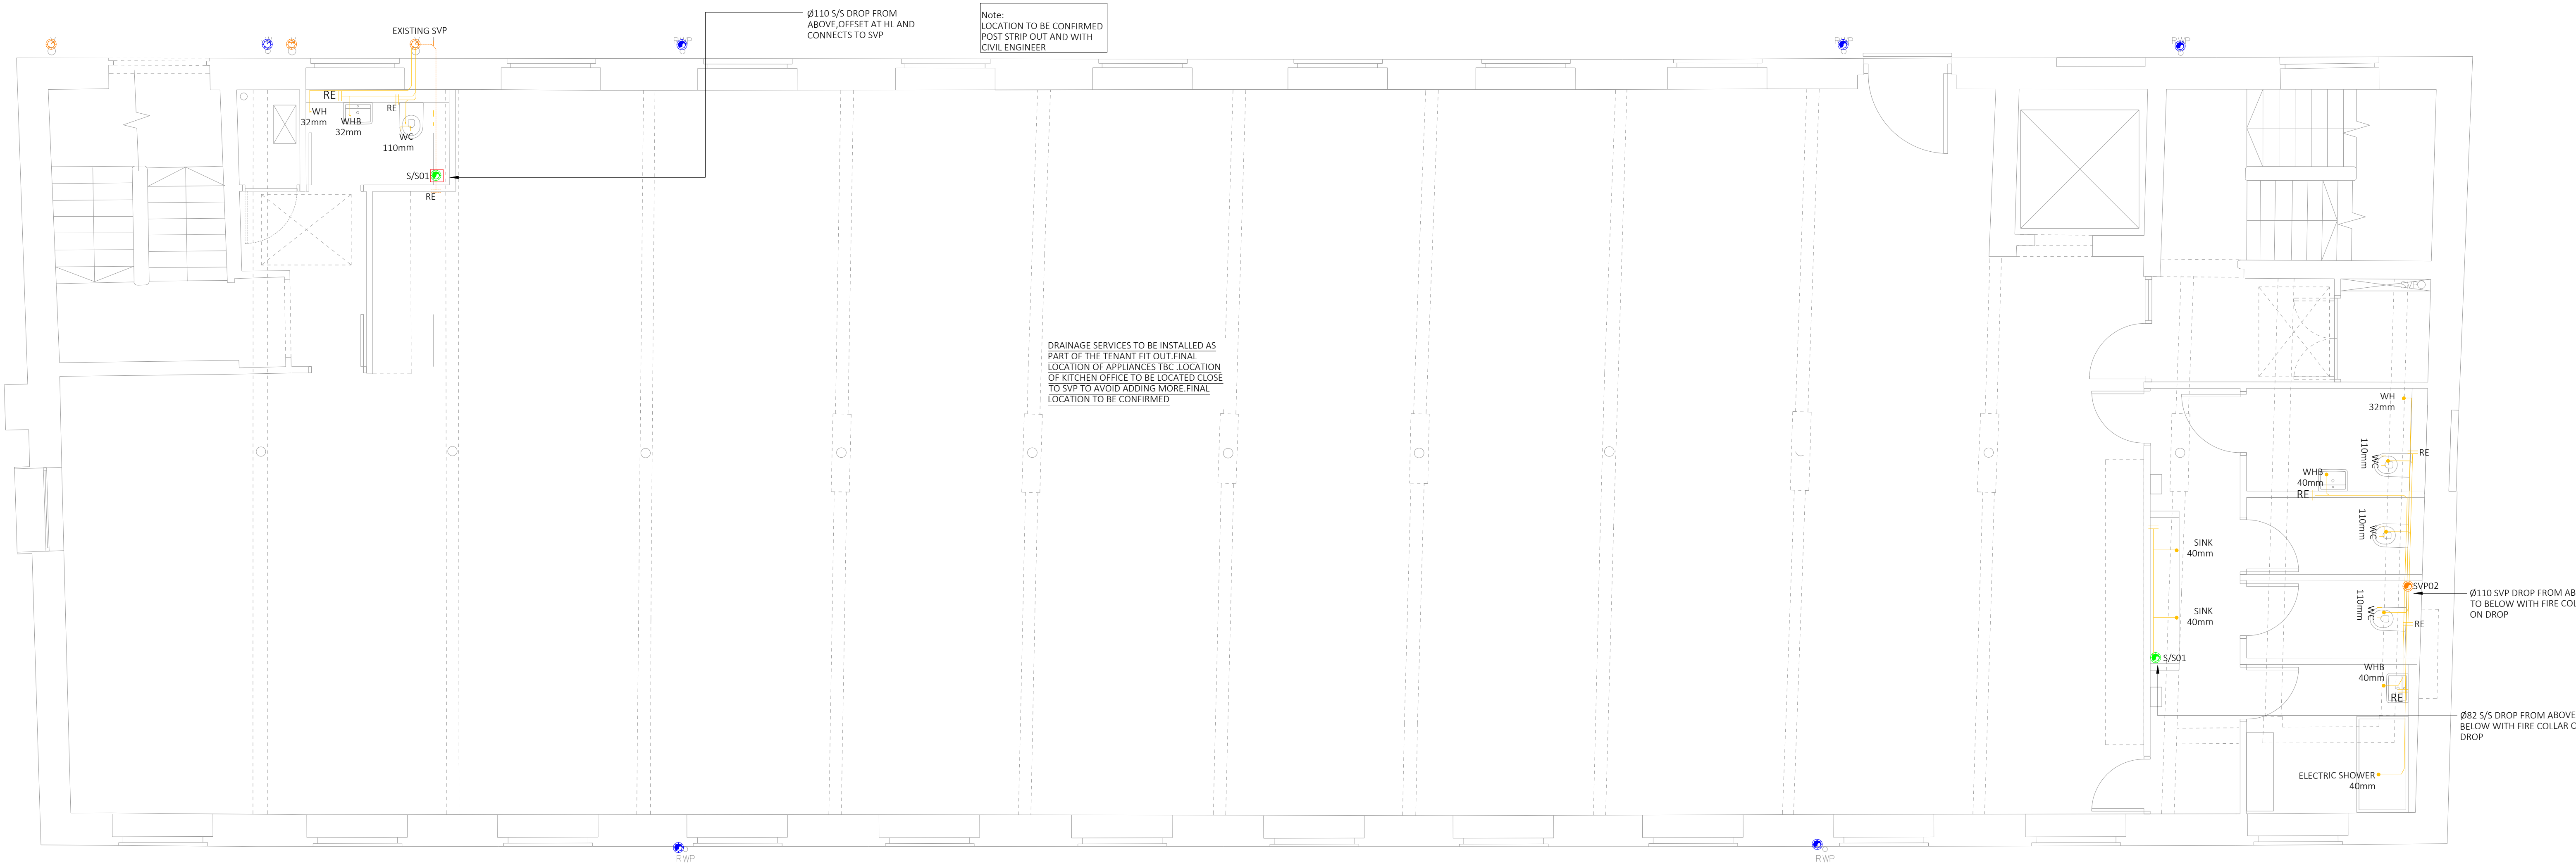

DRAINAGE LEGEND

- SVP

110Ø SOIL AND VENT PIPE
- VENT

VENT PIPE
- S/S

110Ø STUB STACK C/W AIR
- RWP

RAIN WATER PIPE
- RE

RODDING EYE
- FG

FLOOR GULLY
- AAV

AIR ADMITTANCE VALVE
- PIPEWORK CONCEALED AT HIGH LEVEL
- PIPEWORK CONCEALED AT LOW LEVEL

- Notes:
- This drawing is subject to copyright and is not to be reproduced in part or whole without approval.
 - Do not scale this drawing - check all dimensions on site.
 - This drawing shall be read in conjunction with the project specification(s) and all other contract documentation.
 - All dimensions are in millimetres unless otherwise stated.
 - Location of all equipment shown shall be confirmed/approved with the Client/Architect/Engineer prior to any installation.
 - This drawing must be read in conjunction with Mechanical and Electrical performance specifications and all other drawings as issued by the Architect, Structural Engineer and Watt Energy and Consulting Engineers.
 - The location of equipment is typical only. The Contractor shall perform all calculations to determine the exact quantity and agree the final locations with the Architect.
 - This drawing shows the intended location of building services plant and service routes in such detail as to indicate the design. The drawing does not show all components that may be necessary to provide a full working installation.
 - The positions of connection points, accessories and building services items are approximate and shown for guidance to assist during the tender process.
 - Fully co-ordinated drawings, Construction drawings and Builderswork drawings shall be produced by the contractor. Under no circumstances shall the tender drawings be used as installation drawings.

WE&CE DRAWINGS ARE FOR DESIGN INTENT ONLY.
THE MEP CONTRACTOR IS RESPONSIBLE FOR THE
FINAL INSTALLATION DRAWINGS INCLUDING ALL
SETTING OUT, DIMENSIONS, ALIGNMENT AND
COORDINATION WITH THE ARCHITECTS
REQUIREMENTS.

T2	04/07/23	TENDER ISSUE	DG
T1	11/04/23	TENDER ISSUE	DK
P2	24/03/23	PRELIMINARY ISSUE	MG
P1	10/03/23	PRELIMINARY ISSUE	MG
Rev:	Date:	Status/Amendments:	By:




40 KING STREET, MANCHESTER, M2 6BA
TEL: 0161 434 3103 EMAIL: office@wece.co.uk

Client:
CAPITAL AND CENTRIC

Project:
CHAPELTOWN WAREHOUSE

Drawing Title:
MECHANICAL SERVICES
ABOVE GROUND DRAINAGE LAYOUT
SECOND FLOOR

Drawn By: MG	Checked By: DW	Cad By: DK
Scale: 1:50	Paper Size: A1	Date Created: 15/02/2023
Drawing Number: WECE / 353 / M / 102	Drawing Revision: T2	

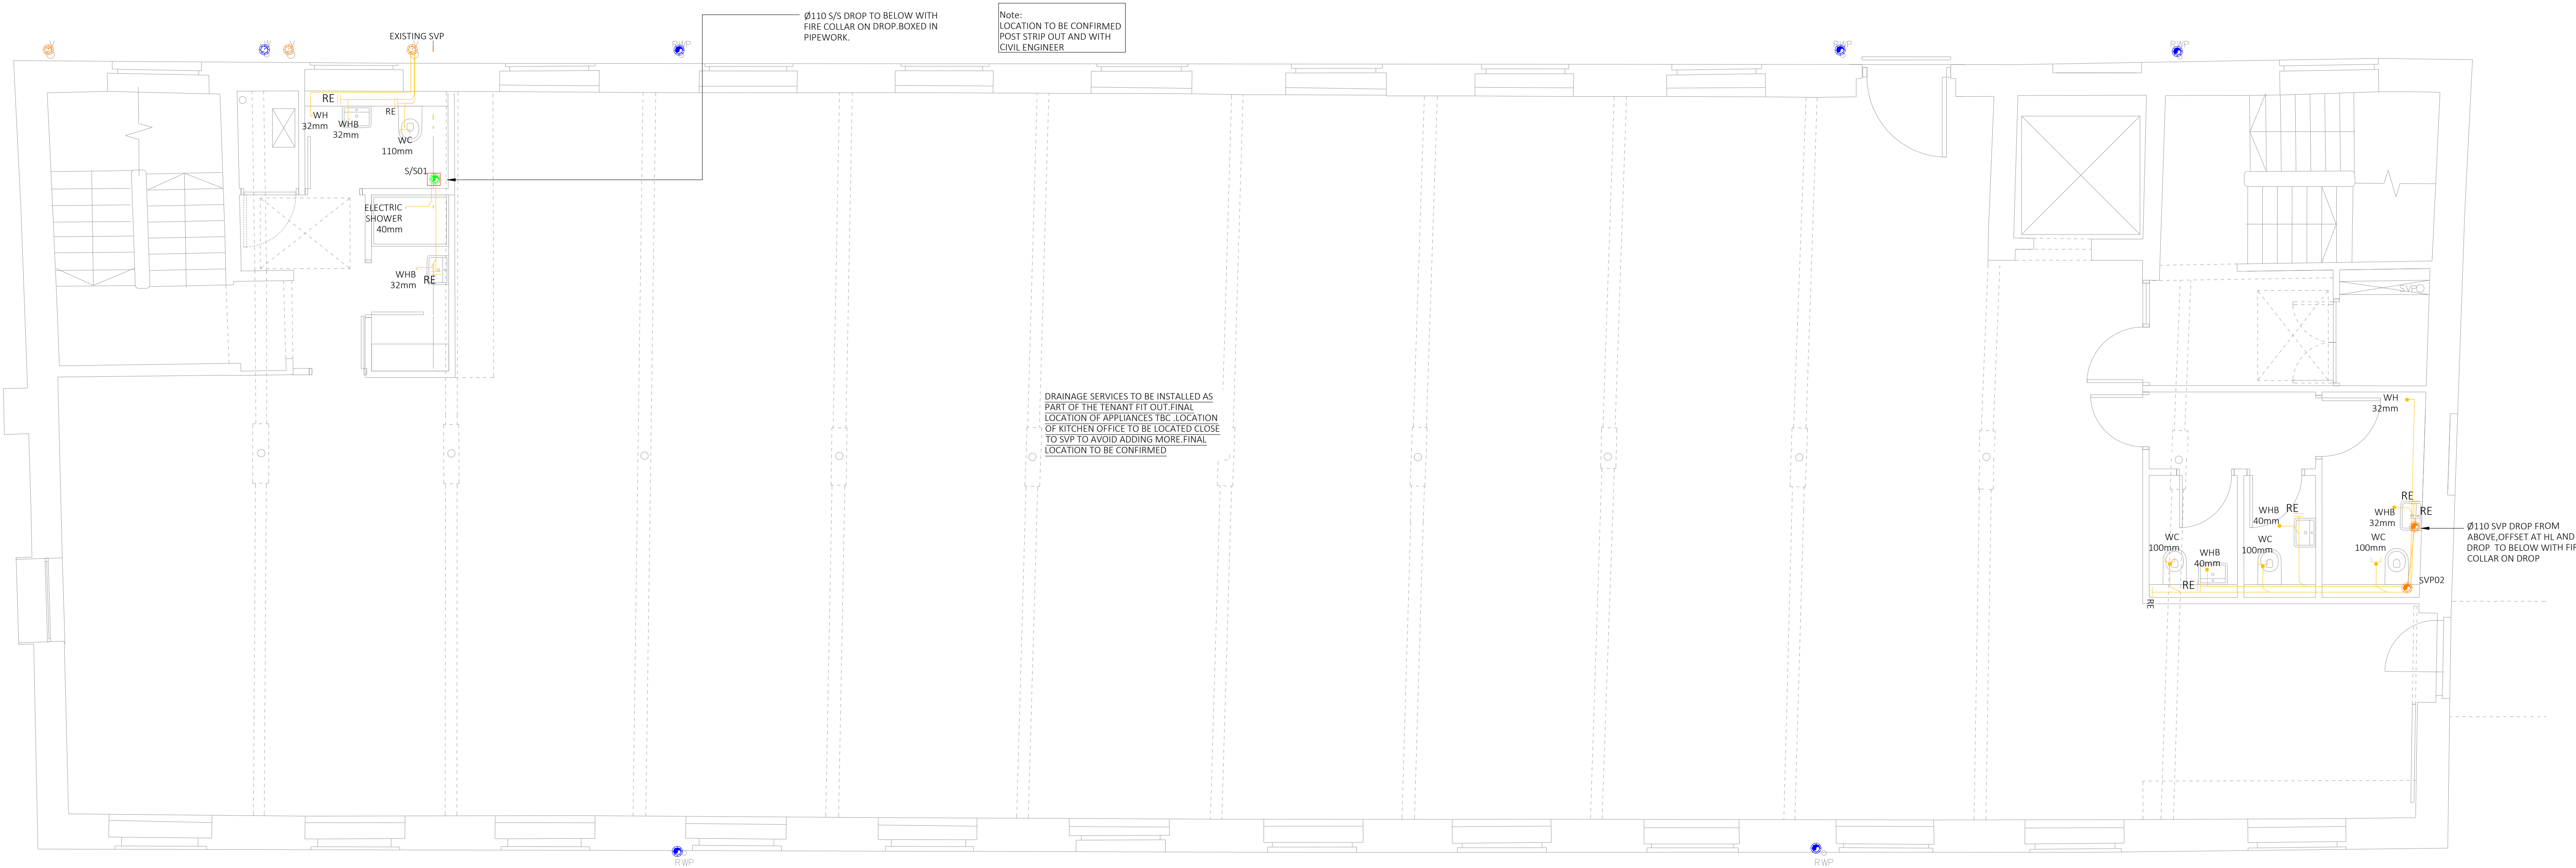

DRAINAGE LEGEND

- SVP

110Ø SOIL AND VENT PIPE
- S/S

110Ø STUB STACK C/W AIR
- RE

RODDING EYE
- FG

FLOOR GULLY
- AAV

AIR ADMITTANCE VALVE
- VENT

VENT PIPE
- RWP

RAIN WATER PIPE
- PIPEWORK CONCEALED AT HIGH LEVEL
- PIPEWORK CONCEALED AT LOW LEVEL

- Notes:
- This drawing is subject to copyright and is not to be reproduced in part or whole without approval.
 - Do not scale this drawing - check all dimensions on site.
 - This drawing shall be read in conjunction with the project specification(s) and all other contract documentation.
 - All dimensions are in millimetres unless otherwise stated.
 - Location of all equipment shown shall be confirmed/approved with the Client/Architect/Engineer prior to any installation.
 - This drawing must be read in conjunction with Mechanical and Electrical performance specifications and all other drawings as issued by the Architect, Structural Engineer and Watt Energy and Consulting Engineers.
 - The location of equipment is typical only. The Contractor shall perform all calculations to determine the exact quantity and agree the final locations with the Architect.
 - This drawing shows the intended location of building services plant and service routes in such detail as to indicate the design. The drawing does not show all components that may be necessary to provide a full working installation.
 - The positions of connection points, accessories and building services items are approximate and shown for guidance to assist during the tender process.
 - Fully co-ordinated drawings, Construction drawings and Builderswork drawings shall be produced by the contractor. Under no circumstances shall the tender drawings be used as installation drawings.

WE&CE DRAWINGS ARE FOR DESIGN INTENT ONLY.
THE MEP CONTRACTOR IS RESPONSIBLE FOR THE
FINAL INSTALLATION DRAWINGS INCLUDING ALL
SETTING OUT, DIMENSIONS, ALIGNMENT AND
COORDINATION WITH THE ARCHITECTS
REQUIREMENTS.

T2	04/07/23	TENDER ISSUE	DG
T1	11/04/23	TENDER ISSUE	DK
P2	24/03/23	PRELIMINARY ISSUE	MG
P1	10/03/23	PRELIMINARY ISSUE	MG
Rev:	Date:	Status/Amendments:	By:




40 KING STREET, MANCHESTER, M2 6BA
TEL: 0161 434 3103 EMAIL: office@wece.co.uk

Client:
CAPITAL AND CENTRIC

Project:
CHAPELTOWN WAREHOUSE

Drawing Title:
MECHANICAL SERVICES
ABOVE GROUND DRAINAGE LAYOUT
THIRD FLOOR

Drawn By: MG	Checked By: DW	Cad By: DK
Scale: 1:50	Paper Size: A1	Date Created: 15/02/23
Drawing Number: WECE / 353 / M / 103	Drawing Revision: T2	

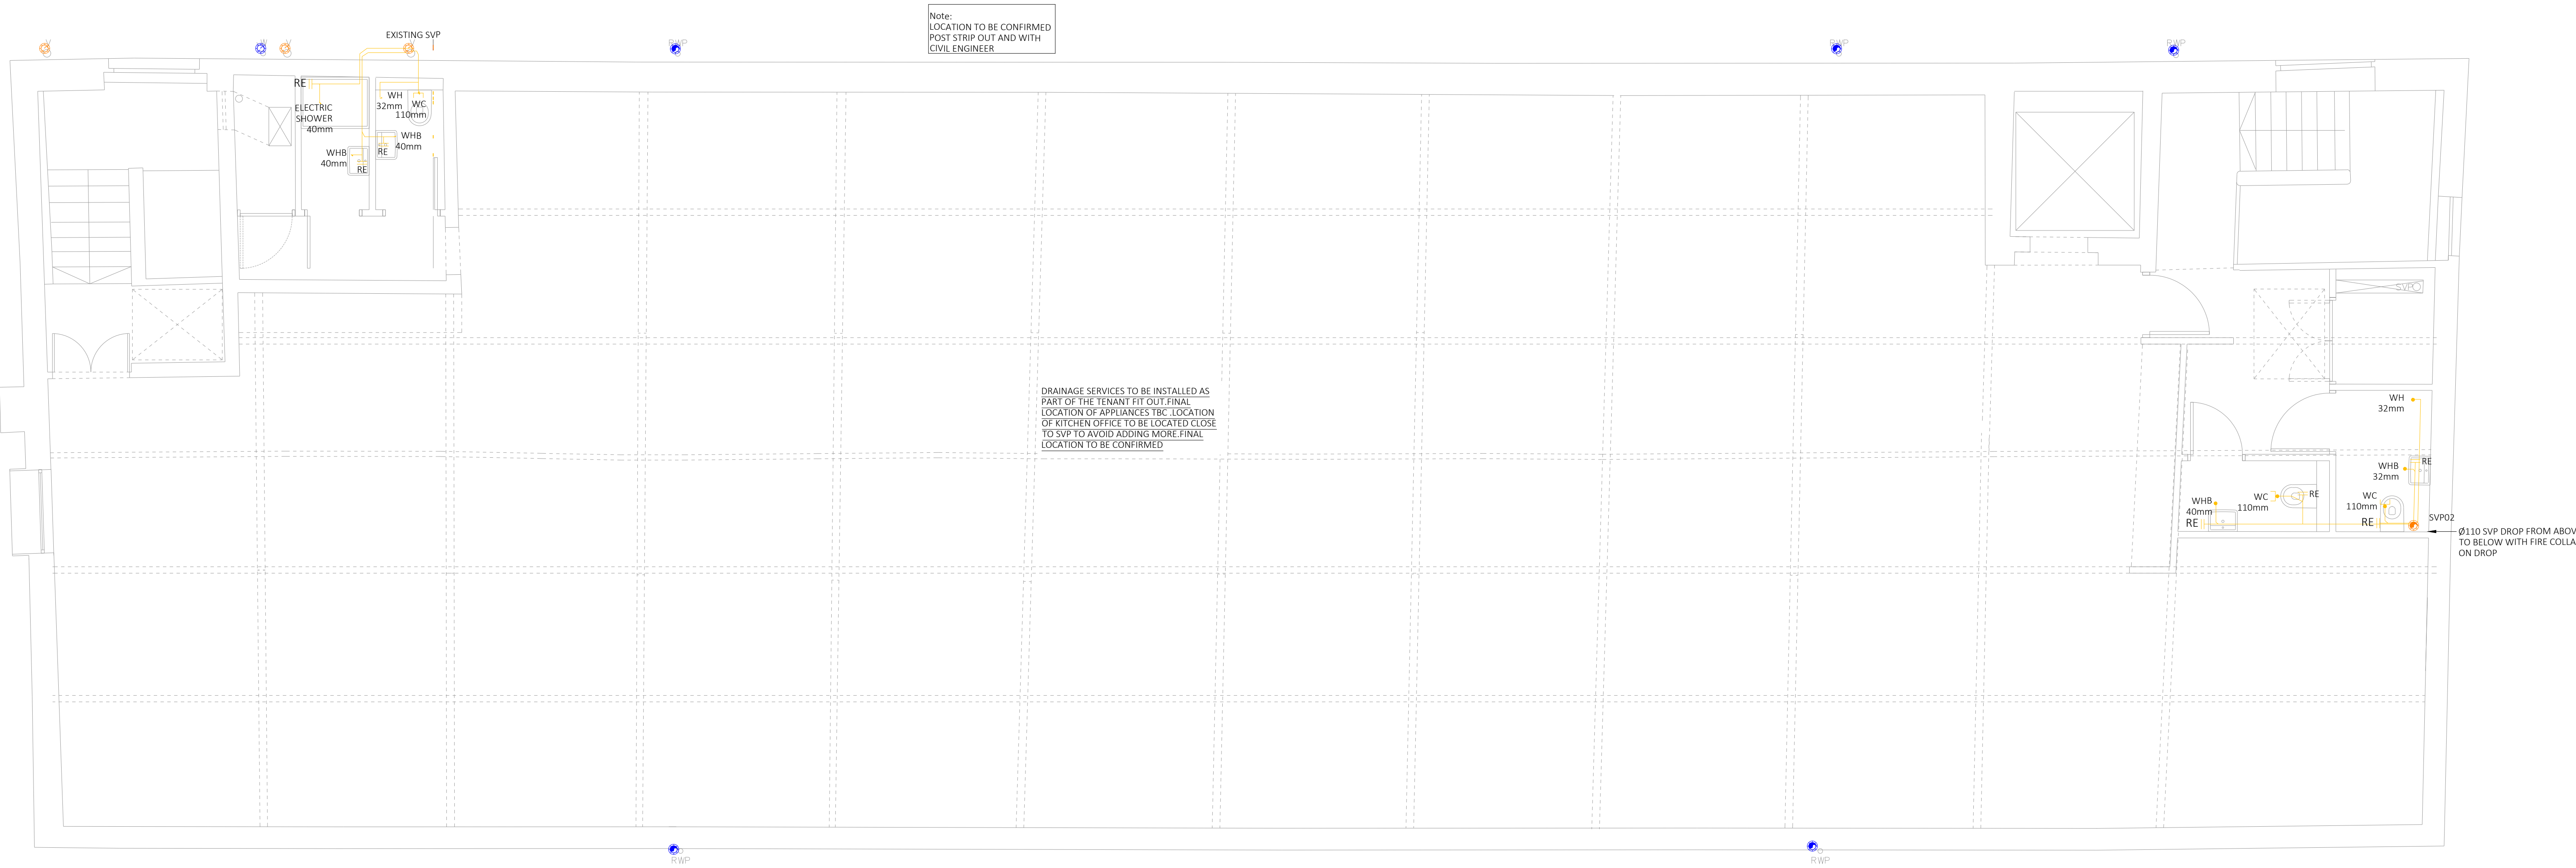

DRAINAGE LEGEND

- SVP

110Ø SOIL AND VENT PIPE
- VENT

VENT PIPE
- S/S

110Ø STUB STACK C/W AIR
- RWP

RAIN WATER PIPE
- RE

RODDING EYE
- FG

FLOOR GULLY
- AAV

AIR ADMITTANCE VALVE
- PIPEWORK CONCEALED AT HIGH LEVEL
- PIPEWORK CONCEALED AT LOW LEVEL

- Notes:**
- This drawing is subject to copyright and is not to be reproduced in part or whole without approval.
 - Do not scale this drawing - check all dimensions on site.
 - This drawing shall be read in conjunction with the project specification(s) and all other contract documentation.
 - All dimensions are in millimetres unless otherwise stated.
 - Location of all equipment shown shall be confirmed/approved with the Client/Architect/Engineer prior to any installation.
 - This drawing must be read in conjunction with Mechanical and Electrical performance specifications and all other drawings as issued by the Architect, Structural Engineer and Watt Energy and Consulting Engineers.
 - The location of equipment is typical only. The Contractor shall perform all calculations to determine the exact quantity and agree the final locations with the Architect.
 - This drawing shows the intended location of building services plant and service routes in such detail as to indicate the design. The drawing does not show all components that may be necessary to provide a full working installation.
 - The positions of connection points, accessories and building services items are approximate and shown for guidance to assist during the tender process.
 - Fully co-ordinated drawings, Construction drawings and Builderswork drawings shall be produced by the contractor. Under no circumstances shall the tender drawings be used as installation drawings.

WE&CE DRAWINGS ARE FOR DESIGN INTENT ONLY.
THE MEP CONTRACTOR IS RESPONSIBLE FOR THE
FINAL INSTALLATION DRAWINGS INCLUDING ALL
SETTING OUT, DIMENSIONS, ALIGNMENT AND
COORDINATION WITH THE ARCHITECTS
REQUIREMENTS.

T2	04/07/23	TENDER ISSUE	DG
T1	11/04/23	TENDER ISSUE	DK
P2	24/03/23	PRELIMINARY ISSUE	MG
P1	10/03/23	PRELIMINARY ISSUE	MG
Rev:	Date:	Status/Amendments:	By:




40 KING STREET, MANCHESTER, M2 6BA
TEL: 0161 434 3103 EMAIL: office@wece.co.uk

Client:
CAPITAL AND CENTRIC

Project:
CHAPELTOWN WAREHOUSE

Drawing Title:
MECHANICAL SERVICES
ABOVE GROUND DRAINAGE LAYOUT
FOURTH FLOOR

Drawn By: MG	Checked By: DW	Cad By: DK
Scale: 1:50	Paper Size: A1	Date Created: 15/02/2023
Drawing Number: WECE / 353 / M / 104	Drawing Revision: T2	

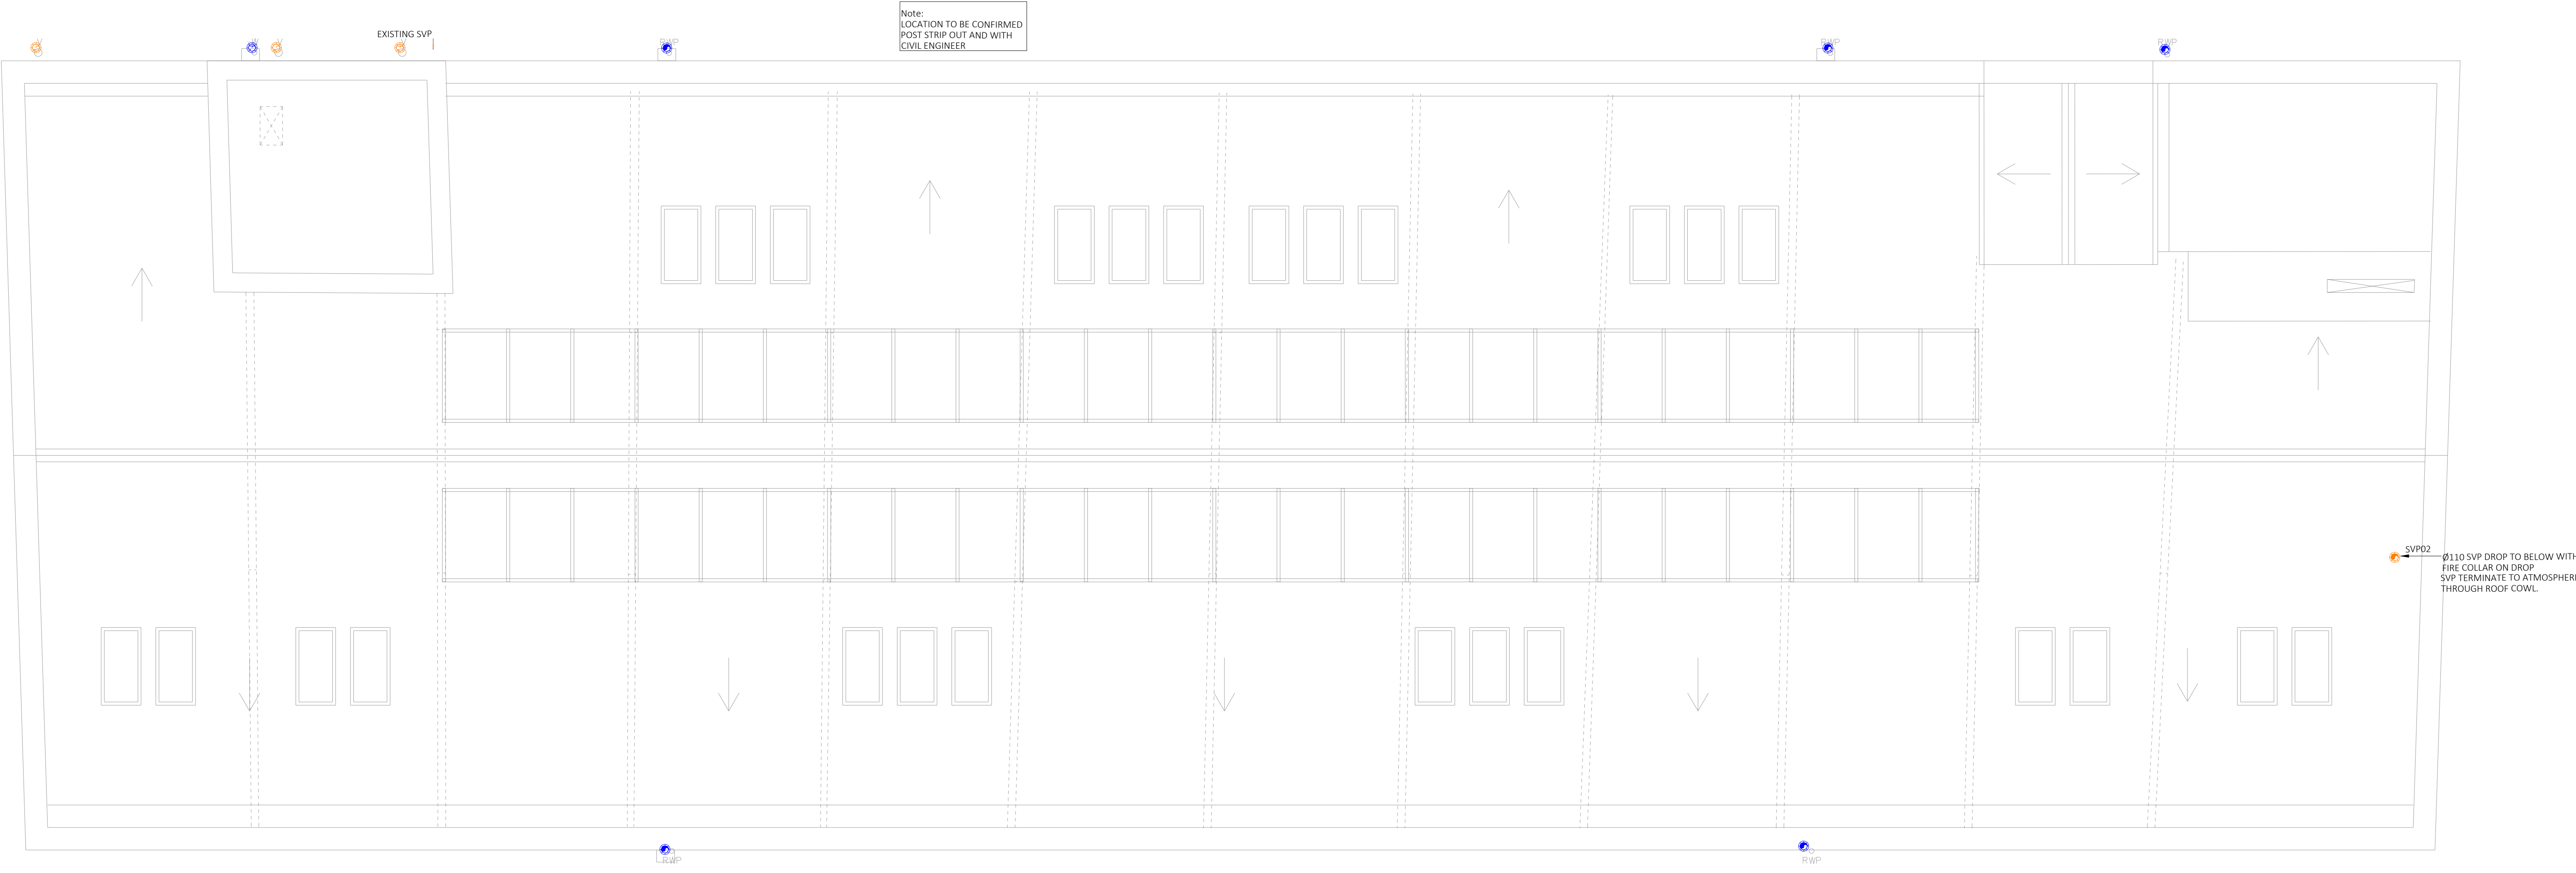

DRAINAGE LEGEND

SVP	110Ø SOIL AND VENT PIPE	VENT	VENT PIPE
S/S	110Ø STUB STACK C/W AIR	RWP	RAIN WATER PIPE
RE	RODDING EYE	— — —	PIPEWORK CONCEALED AT HIGH LEVEL
FG	FLOOR GULLY	+ — —	PIPEWORK CONCEALED AT LOW LEVEL
AAV	AIR ADMITTANCE VALVE		

Notes:

- This drawing is subject to copyright and is not to be reproduced in part or whole without approval.
- Do not scale this drawing - check all dimensions on site.
- This drawing shall be read in conjunction with the project specification(s) and all other contract documentation.
- All dimensions are in millimetres unless otherwise stated.
- Location of all equipment shown shall be confirmed/approved with the Client/Architect/Engineer prior to any installation.
- This drawing must be read in conjunction with Mechanical and Electrical performance specifications and all other drawings as issued by the Architect, Structural Engineer and Watt Energy and Consulting Engineers.
- The location of equipment is typical only. The Contractor shall perform all calculations to determine the exact quantity and agree the final locations with the Architect.
- This drawing shows the intended location of building services plant and service routes in such detail as to indicate the design. The drawing does not show all components that may be necessary to provide a full working installation.
- The positions of connection points, accessories and building services items are approximate and shown for guidance to assist during the tender process.
- Fully co-ordinated drawings, Construction drawings and Builderswork drawings shall be produced by the contractor. Under no circumstances shall the tender drawings be used as installation drawings.

WE&CE DRAWINGS ARE FOR DESIGN INTENT ONLY.
THE MEP CONTRACTOR IS RESPONSIBLE FOR THE
FINAL INSTALLATION DRAWINGS INCLUDING ALL
SETTING OUT, DIMENSIONS, ALIGNMENT AND
COORDINATION WITH THE ARCHITECTS
REQUIREMENTS.

T2	04/07/23	TENDER ISSUE	DG
T1	11/04/23	TENDER ISSUE	DK
P2	24/03/23	PRELIMINARY ISSUE	MG
P1	10/03/23	PRELIMINARY ISSUE	MG
Rev:	Date:	Status/Amendments:	By:




40 KING STREET, MANCHESTER, M2 6BA
TEL: 0161 434 3103 EMAIL: office@wece.co.uk

Client:
CAPITAL AND CENTRIC

Project:
CHAPELTOWN WAREHOUSE



Drawing Title:
MECHANICAL SERVICES
ABOVE GROUND DRAINAGE LAYOUT
ROOF

Drawn By: MG	Checked By: DW	Cad By: DK
Scale: 1:50	Paper Size: A1	Date Created: 15/02/2023
Drawing Number: WECE / 353 / M / 105	Drawing Revision: T2	

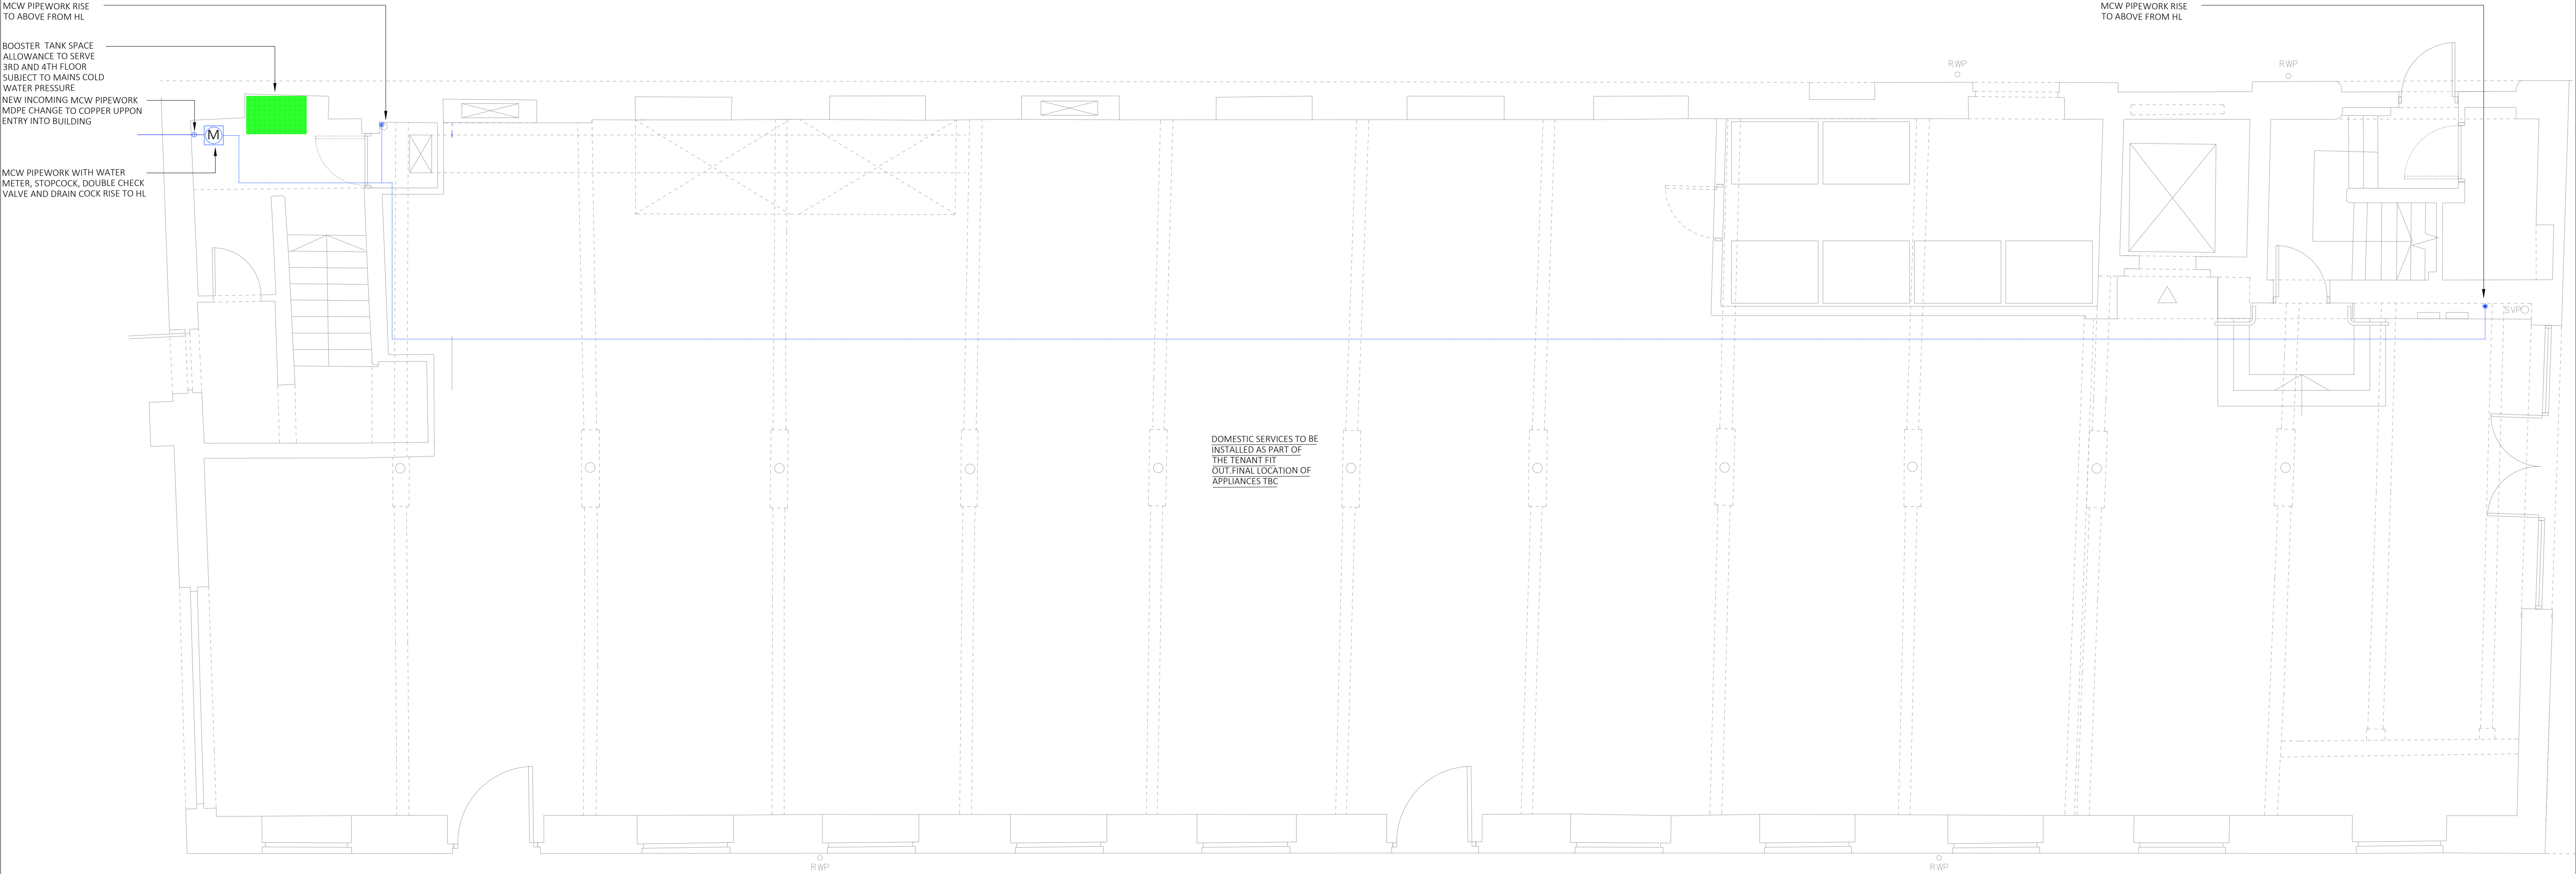

NOTE : ALL PIPEWORK TO BE CONCEALED WHERE POSSIBLE AND INSULTED IN A BLACK MATERIAL TO BE AS DISCREET AS POSSIBLE

 DOMESTIC SERVICES LEGEND

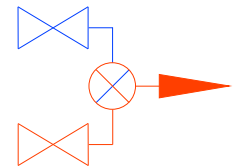	THERMOSTATIC MIXING VALVE		BOOSTER COLD WATER SERVICES (BCWS) HIGH LEVEL IN CEILING VOID
	OUTLET		DOMESTIC HOT WATER (DHW) HIGH LEVEL IN CEILING VOID
	ISOLATION VALVE		BOOSTER COLD WATER SERVICES (BCWS) LOW LEVEL
	PIPEWORK RISE / DROP		DOMESTIC HOT WATER (DHW) LOW LEVEL
	AMR WATER METER		INCOMING COLD WATER MAINS BELOW FLOOR

Notes:

- This drawing is subject to copyright and is not to be reproduced in part or whole without approval.
- Do not scale this drawing - check all dimensions on site.
- This drawing shall be read in conjunction with the project specification(s) and all other contract documentation.
- All dimensions are in millimetres unless otherwise stated.
- Location of all equipment shown shall be confirmed/approved with the Client/Architect/Engineer prior to any installation.
- This drawing must be read in conjunction with Mechanical and Electrical performance specifications and all other drawings as issued by the Architect, Structural Engineer and Watt Energy and Consulting Engineers.
- The location of equipment is typical only. The Contractor shall perform all calculations to determine the exact quantity and agree the final locations with the Architect.
- This drawing shows the intended location of building services plant and service routes in such detail as to indicate the design. The drawing does not show all components that may be necessary to provide a full working installation.
- The positions of connection points, accessories and building services items are approximate and shown for guidance to assist during the tender process.
- Fully co-ordinated drawings, Construction drawings and Builderswork drawings shall be produced by the contractor. Under no circumstances shall the tender drawings be used as installation drawings.

WE&CE DRAWINGS ARE FOR DESIGN INTENT ONLY.
THE MEP CONTRACTOR IS RESPONSIBLE FOR THE
FINAL INSTALLATION DRAWINGS INCLUDING ALL
SETTING OUT, DIMENSIONS, ALIGNMENT AND
COORDINATION WITH THE ARCHITECTS
REQUIREMENTS.

T1	11/04/23	TENDER ISSUE	DK
P2	24/03/23	PRELIMINARY ISSUE	MG
P1	10/03/23	PRELIMINARY ISSUE	MG
Rev:	Date:	Status/Amendments:	By:



40 KING STREET, MANCHESTER, M2 6BA
TEL: 0161 434 3103 EMAIL: office@wece.co.uk


Client:
CAPITAL AND CENTRIC

Project:
CHAPELTOWN WAREHOUSE

Drawing Title:
MECHANICAL SERVICES
DOMESTIC SERVICES LAYOUT
GROUND FLOOR

Drawn By: MG	Checked By: DW	Cad By: DK
Scale: 1:50	Paper Size: A1	Date Created: 15/02/2023
Drawing Number: WECE / 353 / M / 200	Drawing Revision: T1	

DOMESTIC SERVICES LEGEND

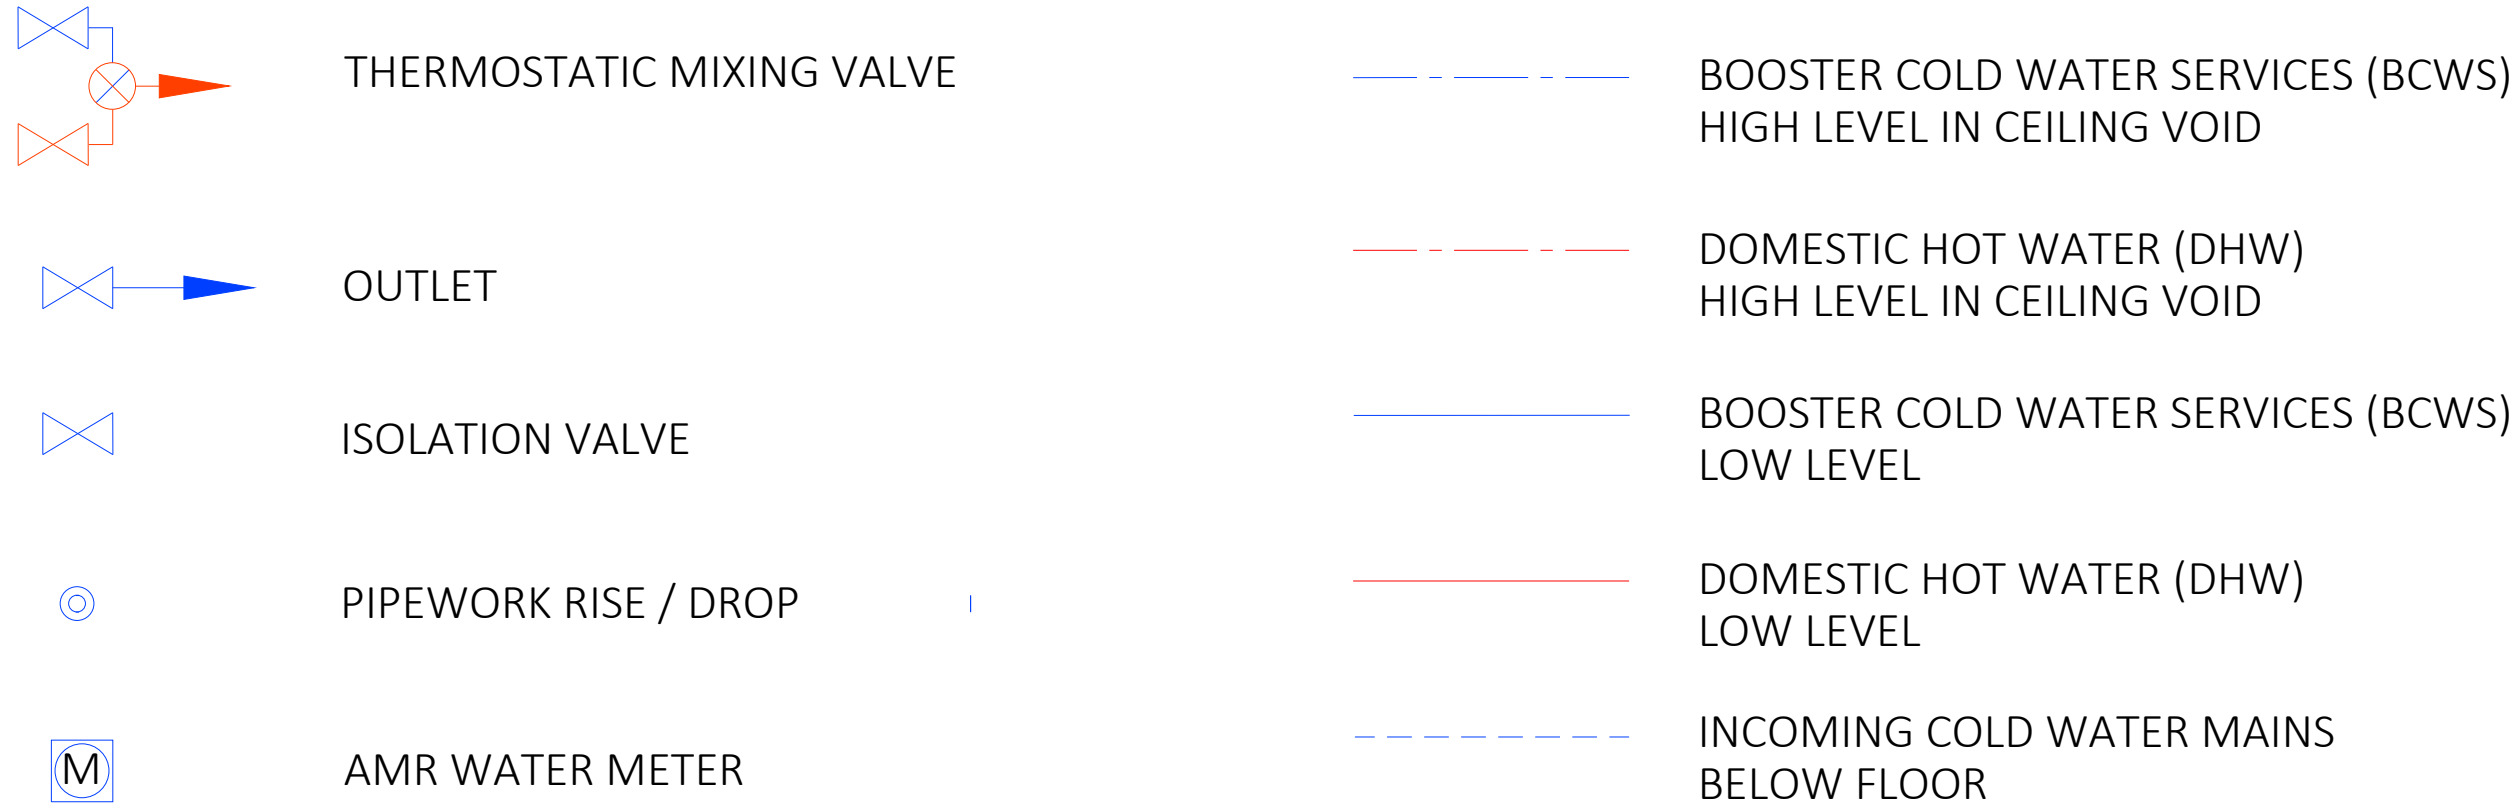

Notes:

- This drawing is subject to copyright and is not to be reproduced in part or whole without approval.
- Do not scale this drawing - check all dimensions on site.
- This drawing shall be read in conjunction with the project specification(s) and all other contract documentation.
- All dimensions are in millimetres unless otherwise stated.
- Location of all equipment shown shall be confirmed/approved with the Client/Architect/Engineer prior to any installation.
- This drawing must be read in conjunction with Mechanical and Electrical performance specifications and all other drawings as issued by the Architect, Structural Engineer and Watt Energy and Consulting Engineers.
- The location of equipment is typical only. The Contractor shall perform all calculations to determine the exact quantity and agree the final locations with the Architect.
- This drawing shows the intended location of building services plant and service routes in such detail as to indicate the design. The drawing does not show all components that may be necessary to provide a full working installation.
- The positions of connection points, accessories and building services items are approximate and shown for guidance to assist during the tender process.
- Fully co-ordinated drawings, Construction drawings and Builderswork drawings shall be produced by the contractor. Under no circumstances shall the tender drawings be used as installation drawings.

WE&CE DRAWINGS ARE FOR DESIGN INTENT ONLY.
THE MEP CONTRACTOR IS RESPONSIBLE FOR THE
FINAL INSTALLATION DRAWINGS INCLUDING ALL
SETTING OUT, DIMENSIONS, ALIGNMENT AND
COORDINATION WITH THE ARCHITECTS
REQUIREMENTS.

T1	11/04/23	TENDER ISSUE	DK
P2	24/03/23	PRELIMINARY ISSUE	MG
P1	10/03/23	PRELIMINARY ISSUE	MG
Rev:	Date:	Status/Amendments:	By:



40 KING STREET, MANCHESTER, M2 6BA
TEL: 0161 434 3103 EMAIL: office@wece.co.uk

Client:
CAPITAL AND CENTRIC


Project:
CHAPELTOWN WAREHOUSE

Drawing Title:
MECHANICAL SERVICES
DOMESTIC SERVICES LAYOUT
FIRST FLOOR


Drawn By: MG	Checked By: DW	Cad By: DK
Scale: 1:50	Paper Size: A1	Date Created: 15/02/2023
Drawing Number: WECE / 353 / M / 201	Drawing Revision: T1	



DOMESTIC SERVICES LEGEND

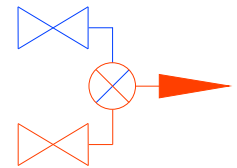

THERMOSTATIC MIXING VALVE

 

OUTLET



ISOLATION VALVE



PIPEWORK RISE / DROP



AMR WATER METER



BOOSTER COLD WATER SERVICES (BCWS)
HIGH LEVEL IN CEILING VOID



DOMESTIC HOT WATER (DHW)
HIGH LEVEL IN CEILING VOID



BOOSTER COLD WATER SERVICES (BCWS)
LOW LEVEL



DOMESTIC HOT WATER (DHW)
LOW LEVEL



INCOMING COLD WATER MAINS
BELOW FLOOR

Notes:

- This drawing is subject to copyright and is not to be reproduced in part or whole without approval.
- Do not scale this drawing - check all dimensions on site.
- This drawing shall be read in conjunction with the project specification(s) and all other contract documentation.
- All dimensions are in millimetres unless otherwise stated.
- Location of all equipment shown shall be confirmed/approved with the Client/Architect/Engineer prior to any installation.
- This drawing must be read in conjunction with Mechanical and Electrical performance specifications and all other drawings as issued by the Architect, Structural Engineer and Watt Energy and Consulting Engineers.
- The location of equipment is typical only. The Contractor shall perform all calculations to determine the exact quantity and agree the final locations with the Architect.
- This drawing shows the intended location of building services plant and service routes in such detail as to indicate the design. The drawing does not show all components that may be necessary to provide a full working installation.
- The positions of connection points, accessories and building services items are approximate and shown for guidance to assist during the tender process.
- Fully co-ordinated drawings, Construction drawings and Builderswork drawings shall be produced by the contractor. Under no circumstances shall the tender drawings be used as installation drawings.

WE&CE DRAWINGS ARE FOR DESIGN INTENT ONLY.
THE MEP CONTRACTOR IS RESPONSIBLE FOR THE
FINAL INSTALLATION DRAWINGS INCLUDING ALL
SETTING OUT, DIMENSIONS, ALIGNMENT AND
COORDINATION WITH THE ARCHITECTS
REQUIREMENTS.

T1	11/04/23	TENDER ISSUE	DK
P2	24/03/23	PRELIMINARY ISSUE	MG
P1	10/03/23	PRELIMINARY ISSUE	MG
Rev:	Date:	Status/Amendments:	By:




40 KING STREET, MANCHESTER, M2 6BA
TEL: 0161 434 3103 EMAIL: office@wece.co.uk

Client:
CAPITAL AND CENTRIC


Project:
CHAPELTOWN WAREHOUSE

Drawing Title:
MECHANICAL SERVICES
DOMESTIC SERVICES LAYOUT
SECOND FLOOR


Drawn By: MG	Checked By: DW	Cad By: DK
Scale: 1:50	Paper Size: A1	Date Created: 15/02/2023
Drawing Number: WECE / 353 / M / 202	Drawing Revision: T1	

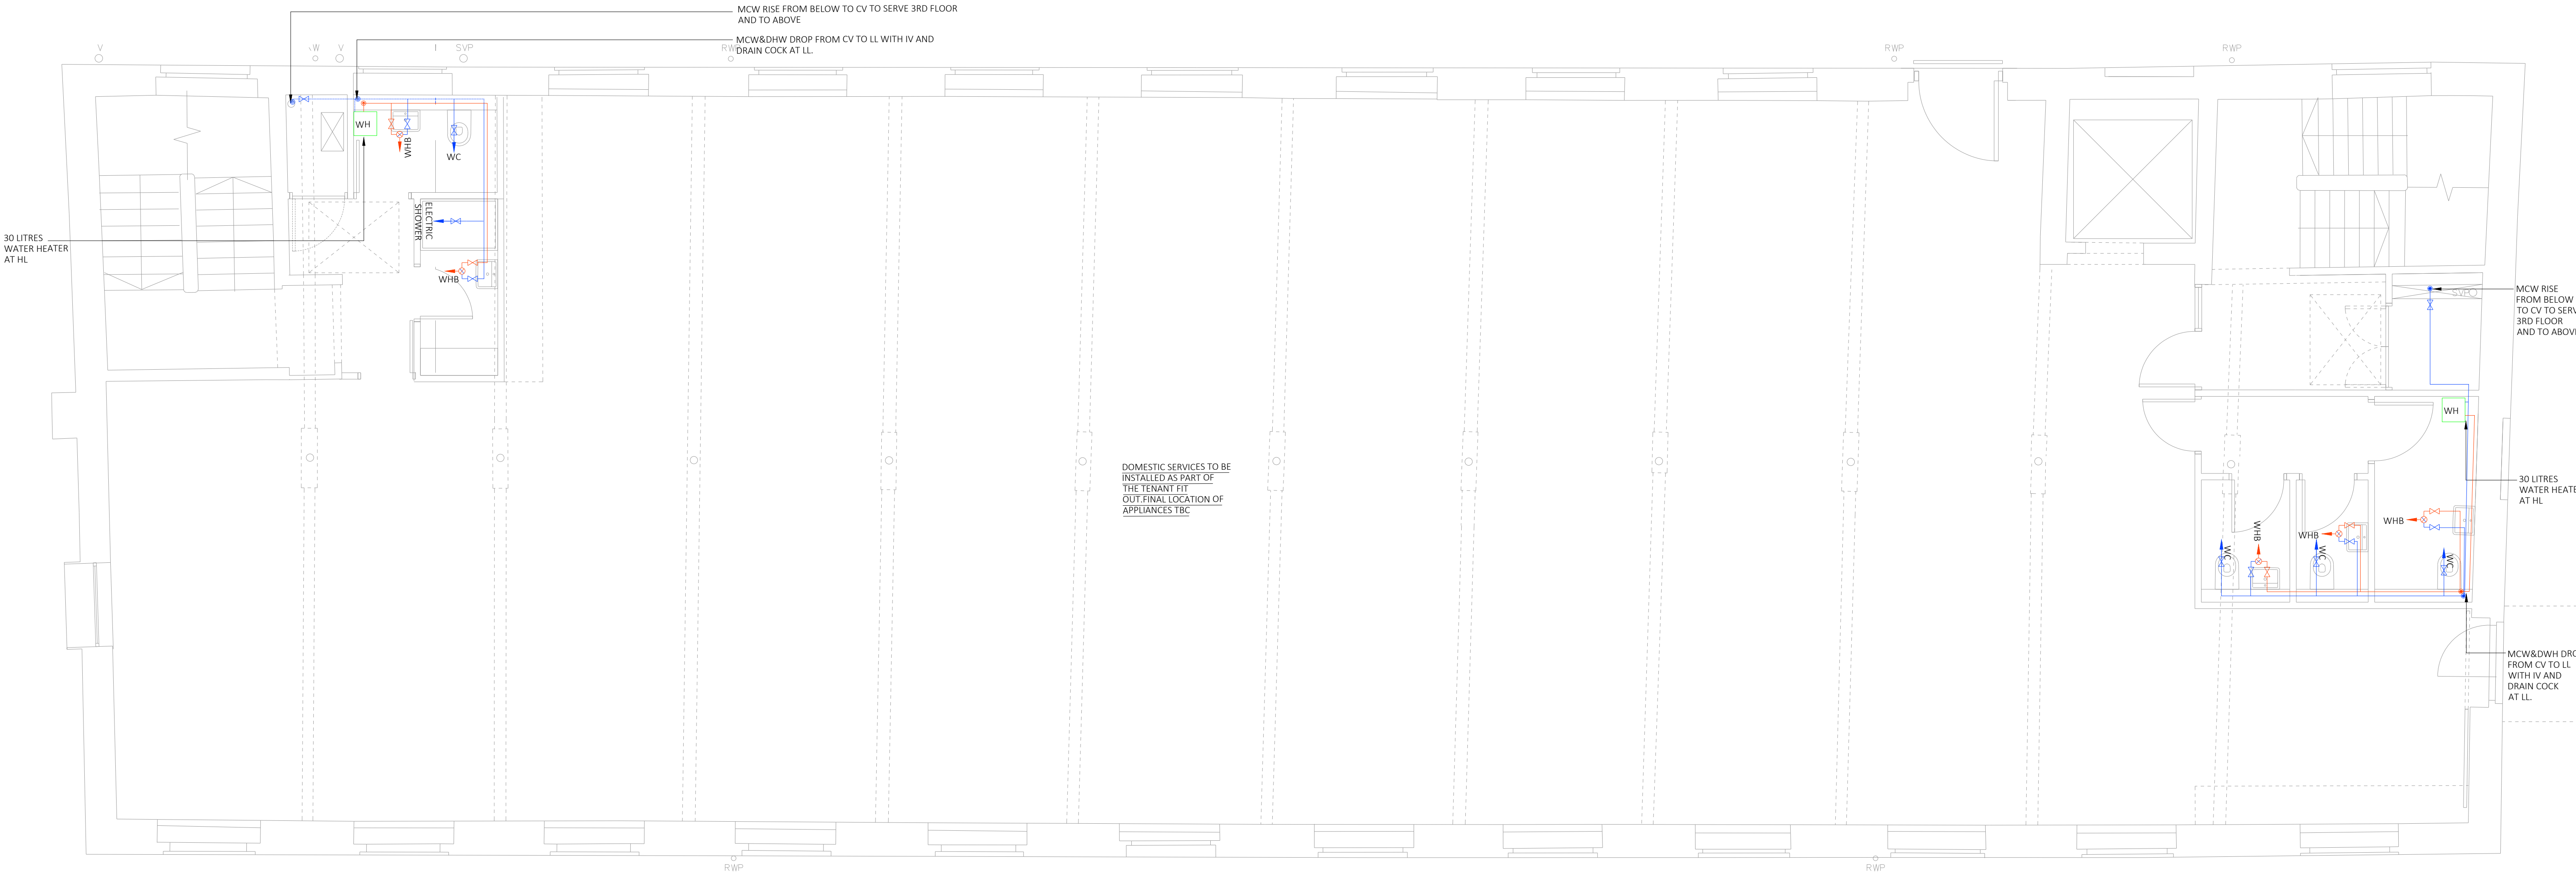

DOMESTIC SERVICES LEGEND

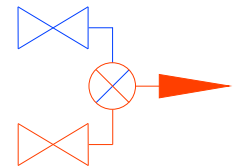

THERMOSTATIC MIXING VALVE

 

OUTLET



ISOLATION VALVE



PIPEWORK RISE / DROP



AMR WATER METER



BOOSTER COLD WATER SERVICES (BCWS)
HIGH LEVEL IN CEILING VOID



DOMESTIC HOT WATER (DHW)
HIGH LEVEL IN CEILING VOID



BOOSTER COLD WATER SERVICES (BCWS)
LOW LEVEL



DOMESTIC HOT WATER (DHW)
LOW LEVEL



INCOMING COLD WATER MAINS
BELOW FLOOR

- Notes:
- This drawing is subject to copyright and is not to be reproduced in part or whole without approval.
 - Do not scale this drawing - check all dimensions on site.
 - This drawing shall be read in conjunction with the project specification(s) and all other contract documentation.
 - All dimensions are in millimetres unless otherwise stated.
 - Location of all equipment shown shall be confirmed/approved with the Client/Architect/Engineer prior to any installation.
 - This drawing must be read in conjunction with Mechanical and Electrical performance specifications and all other drawings as issued by the Architect, Structural Engineer and Watt Energy and Consulting Engineers.
 - The location of equipment is typical only. The Contractor shall perform all calculations to determine the exact quantity and agree the final locations with the Architect.
 - This drawing shows the intended location of building services plant and service routes in such detail as to indicate the design. The drawing does not show all components that may be necessary to provide a full working installation.
 - The positions of connection points, accessories and building services items are approximate and shown for guidance to assist during the tender process.
 - Fully co-ordinated drawings, Construction drawings and Builderswork drawings shall be produced by the contractor. Under no circumstances shall the tender drawings be used as installation drawings.

WE&CE DRAWINGS ARE FOR DESIGN INTENT ONLY.
THE MEP CONTRACTOR IS RESPONSIBLE FOR THE
FINAL INSTALLATION DRAWINGS INCLUDING ALL
SETTING OUT, DIMENSIONS, ALIGNMENT AND
COORDINATION WITH THE ARCHITECTS
REQUIREMENTS.

T1	11/04/23	TENDER ISSUE	DK
P2	24/03/23	PRELIMINARY ISSUE	MG
P1	10/03/23	PRELIMINARY ISSUE	MG
Rev:	Date:	Status/Amendments:	By:




40 KING STREET, MANCHESTER, M2 6BA
TEL: 0161 434 3103 EMAIL: office@wece.co.uk

Client:
CAPITAL AND CENTRIC


Project:
CHAPELTOWN WAREHOUSE

Drawing Title:
MECHANICAL SERVICES
DOMESTIC SERVICES LAYOUT
THIRD FLOOR

Drawn By: MG	Checked By: DW	Cad By: DK
Scale: 1:50	Paper Size: A1	Date Created: 15/02/2023
Drawing Number: WECE / 353 / M / 203	Drawing Revision: T1	

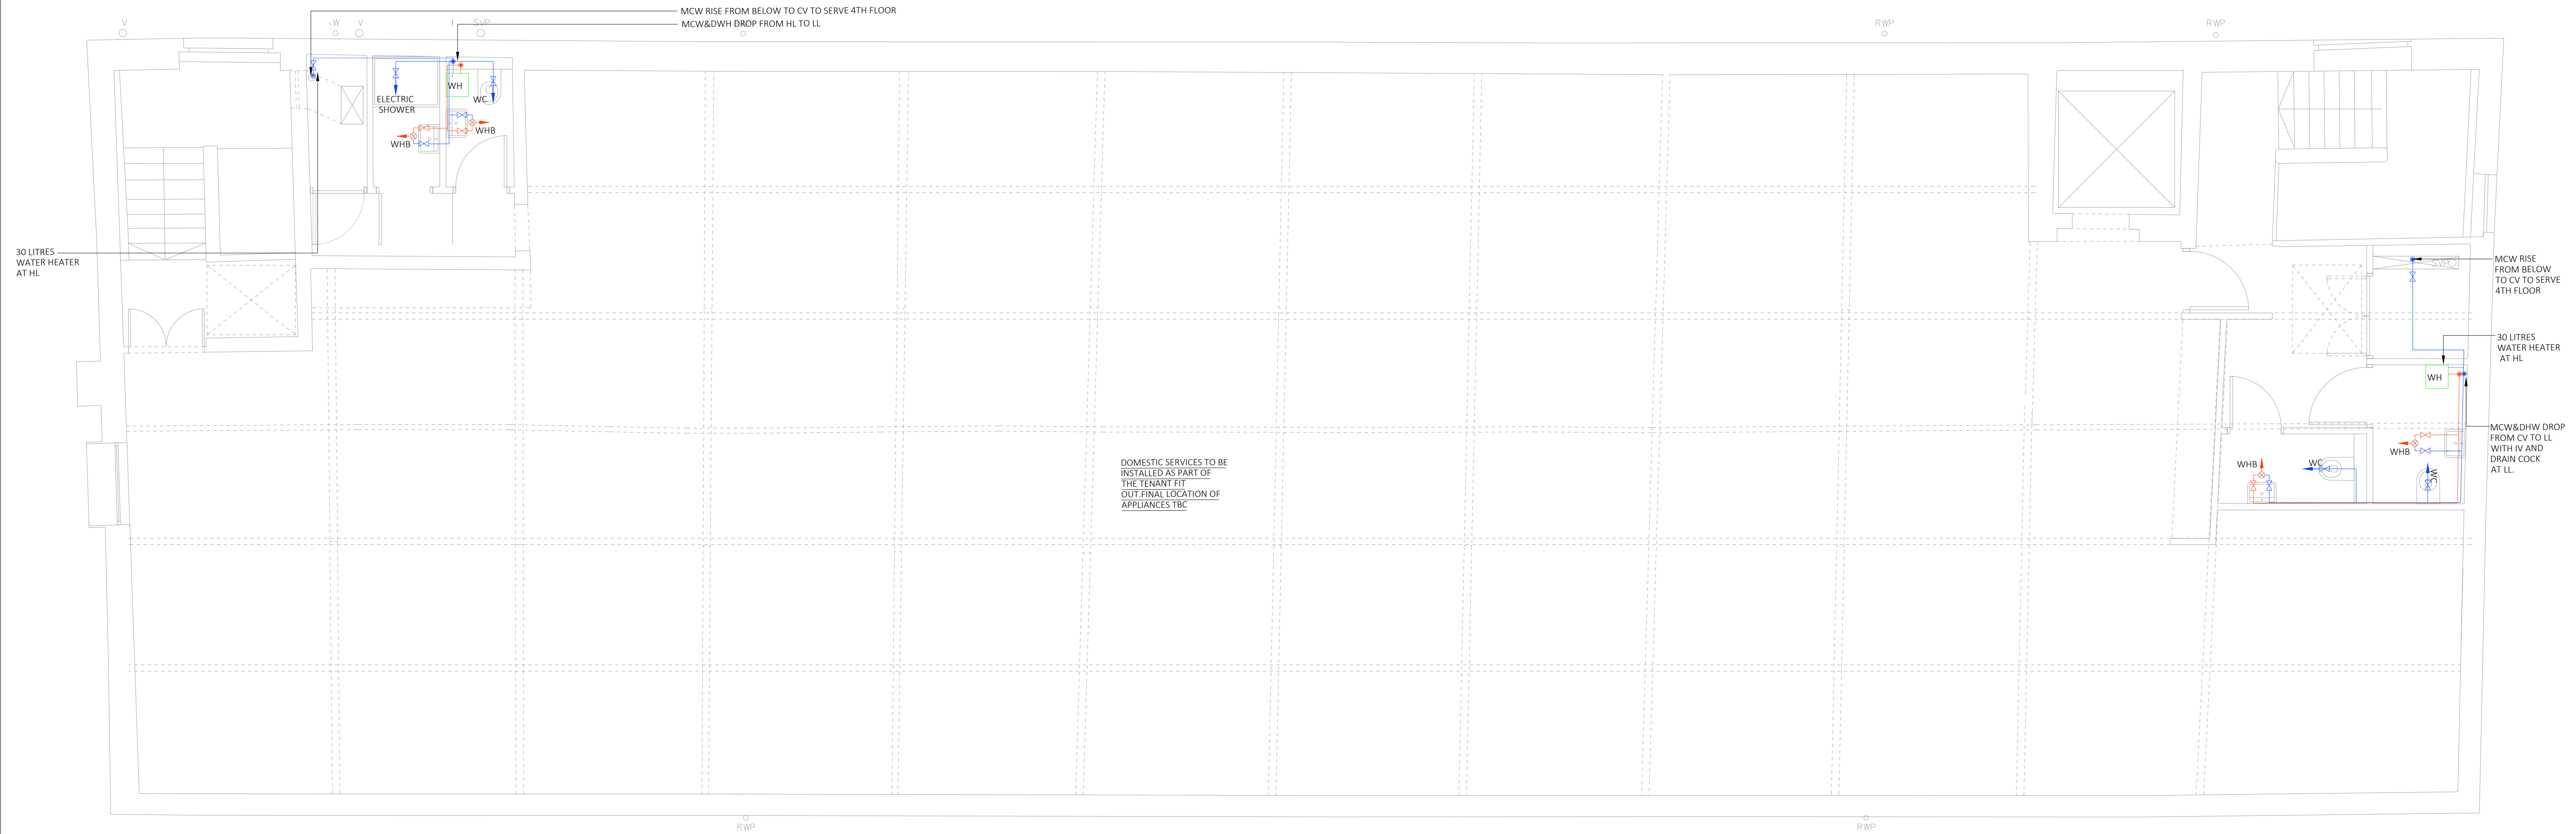

DOMESTIC SERVICES LEGEND

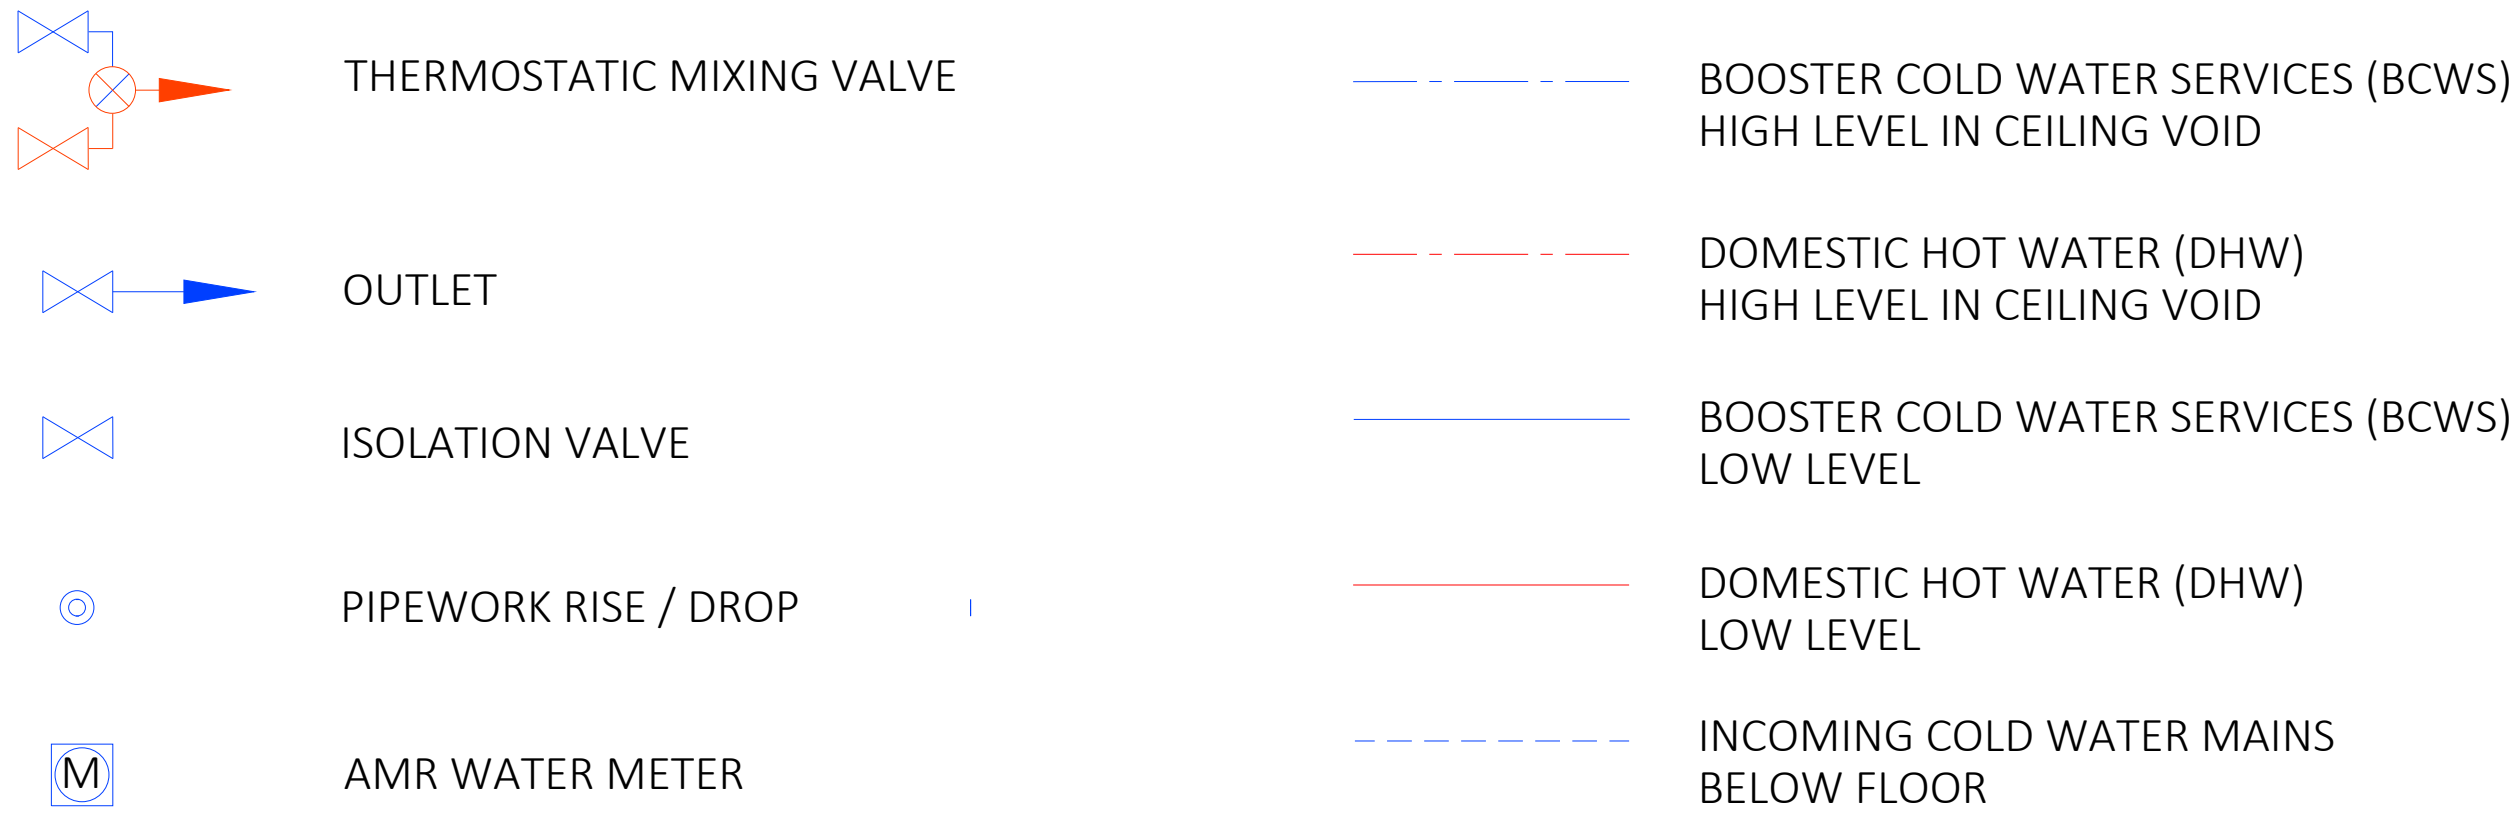

Notes:

- This drawing is subject to copyright and is not to be reproduced in part or whole without approval.
- Do not scale this drawing - check all dimensions on site.
- This drawing shall be read in conjunction with the project specification(s) and all other contract documentation.
- All dimensions are in millimetres unless otherwise stated.
- Location of all equipment shown shall be confirmed/approved with the Client/Architect/Engineer prior to any installation.
- This drawing must be read in conjunction with Mechanical and Electrical performance specifications and all other drawings as issued by the Architect, Structural Engineer and Watt Energy and Consulting Engineers.
- The location of equipment is typical only. The Contractor shall perform all calculations to determine the exact quantity and agree the final locations with the Architect.
- This drawing shows the intended location of building services plant and service routes in such detail as to indicate the design. The drawing does not show all components that may be necessary to provide a full working installation.
- The positions of connection points, accessories and building services items are approximate and shown for guidance to assist during the tender process.
- Fully co-ordinated drawings, Construction drawings and Builderswork drawings shall be produced by the contractor. Under no circumstances shall the tender drawings be used as installation drawings.

WE&CE DRAWINGS ARE FOR DESIGN INTENT ONLY. THE MEP CONTRACTOR IS RESPONSIBLE FOR THE FINAL INSTALLATION DRAWINGS INCLUDING ALL SETTING OUT, DIMENSIONS, ALIGNMENT AND COORDINATION WITH THE ARCHITECTS REQUIREMENTS.

T1	11/04/23	TENDER ISSUE	DK
P2	24/03/23	PRELIMINARY ISSUE	MG
P1	10/03/23	PRELIMINARY ISSUE	MG
Rev:	Date:	Status/Amendments:	By:




40 KING STREET, MANCHESTER, M2 6BA
TEL: 0161 434 3103 EMAIL: office@wece.co.uk

Client:
CAPITAL AND CENTRIC


Project:
CHAPELTOWN WAREHOUSE

Drawing Title:
MECHANICAL SERVICES
DOMESTIC SERVICES LAYOUT
FOURTH FLOOR

Drawn By: MG	Checked By: DW	Cad By: DK
Scale: 1:50	Paper Size: A1	Date Created: 15/02/2023
Drawing Number: WECE / 353 / M / 204	Drawing Revision: T1	

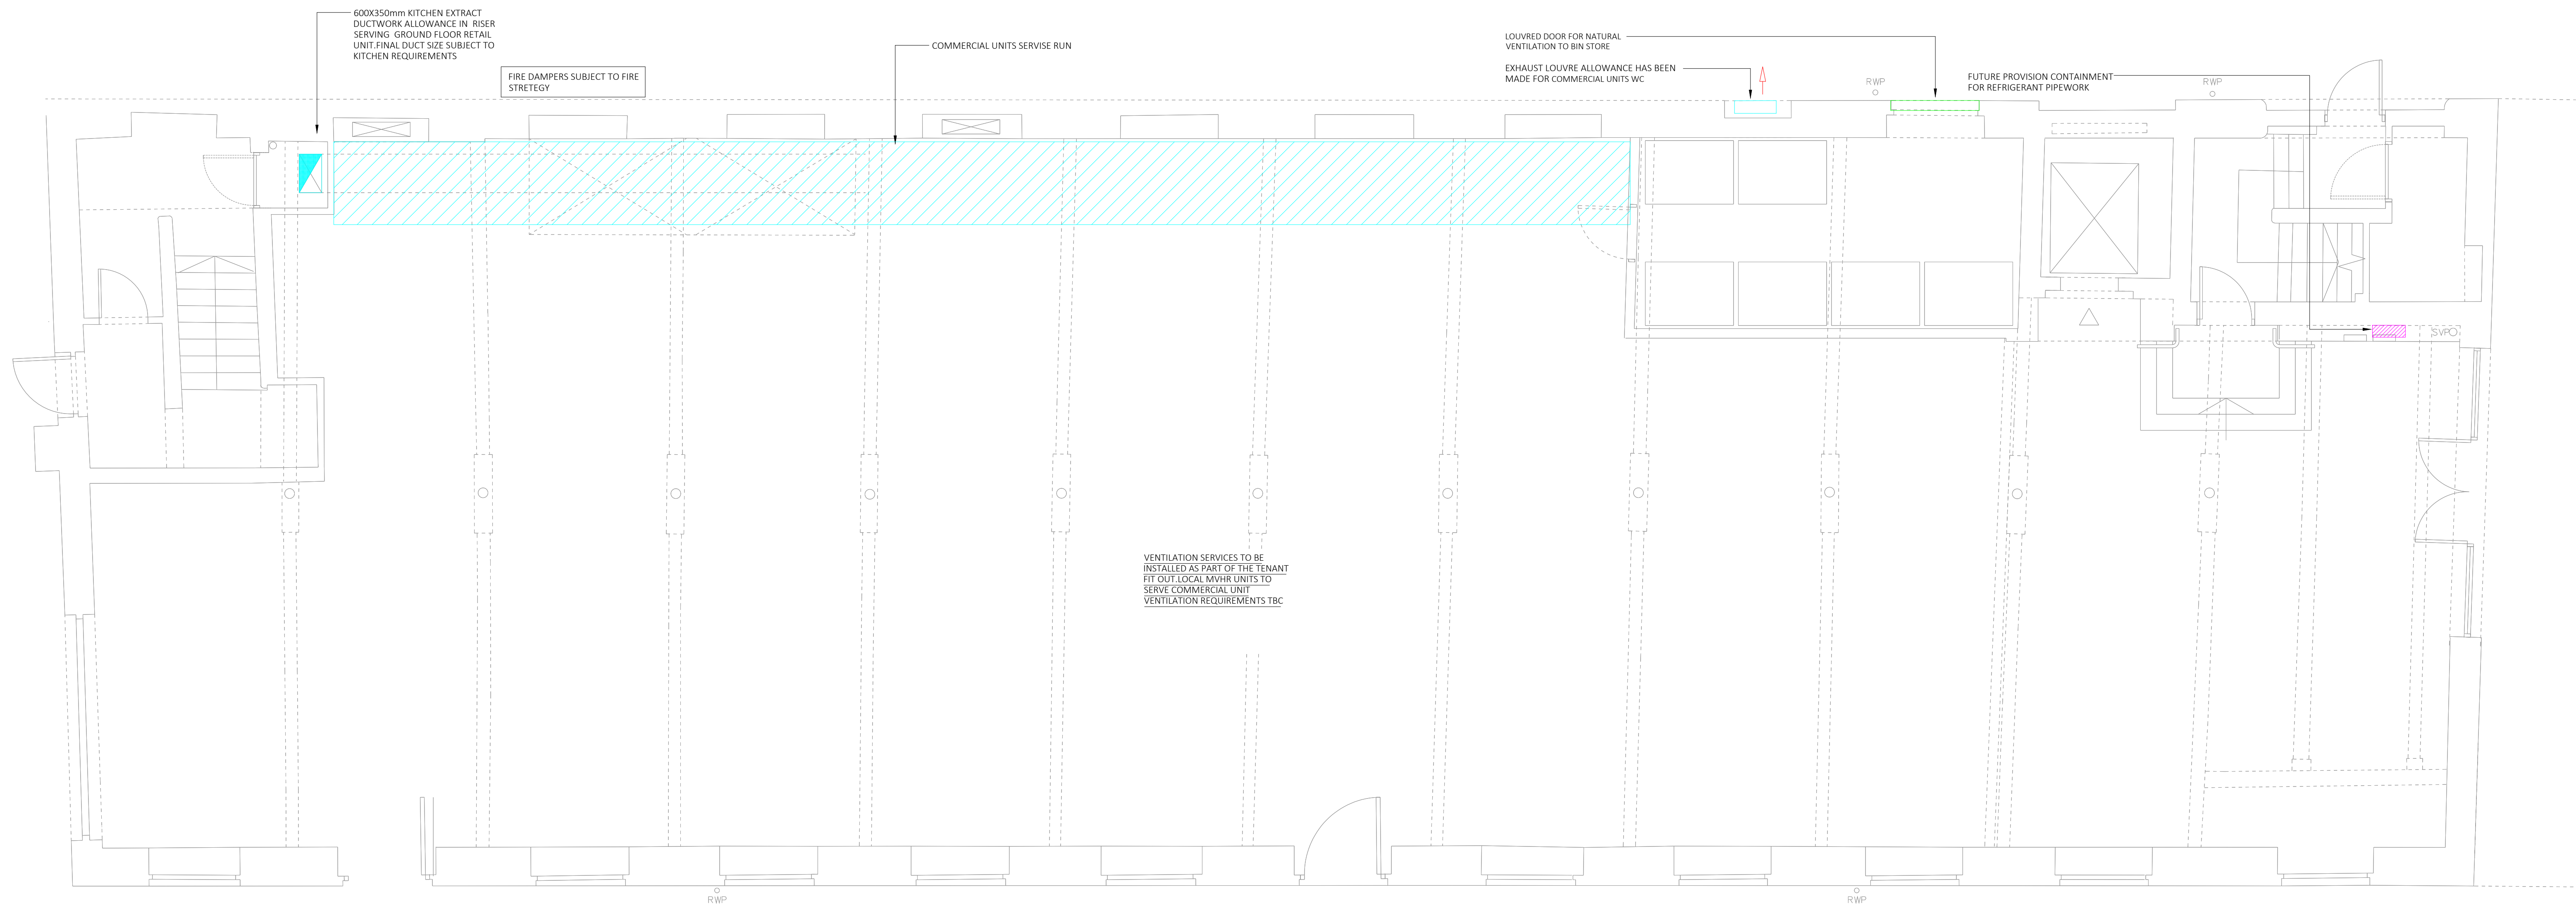

VENTILATION LEGEND

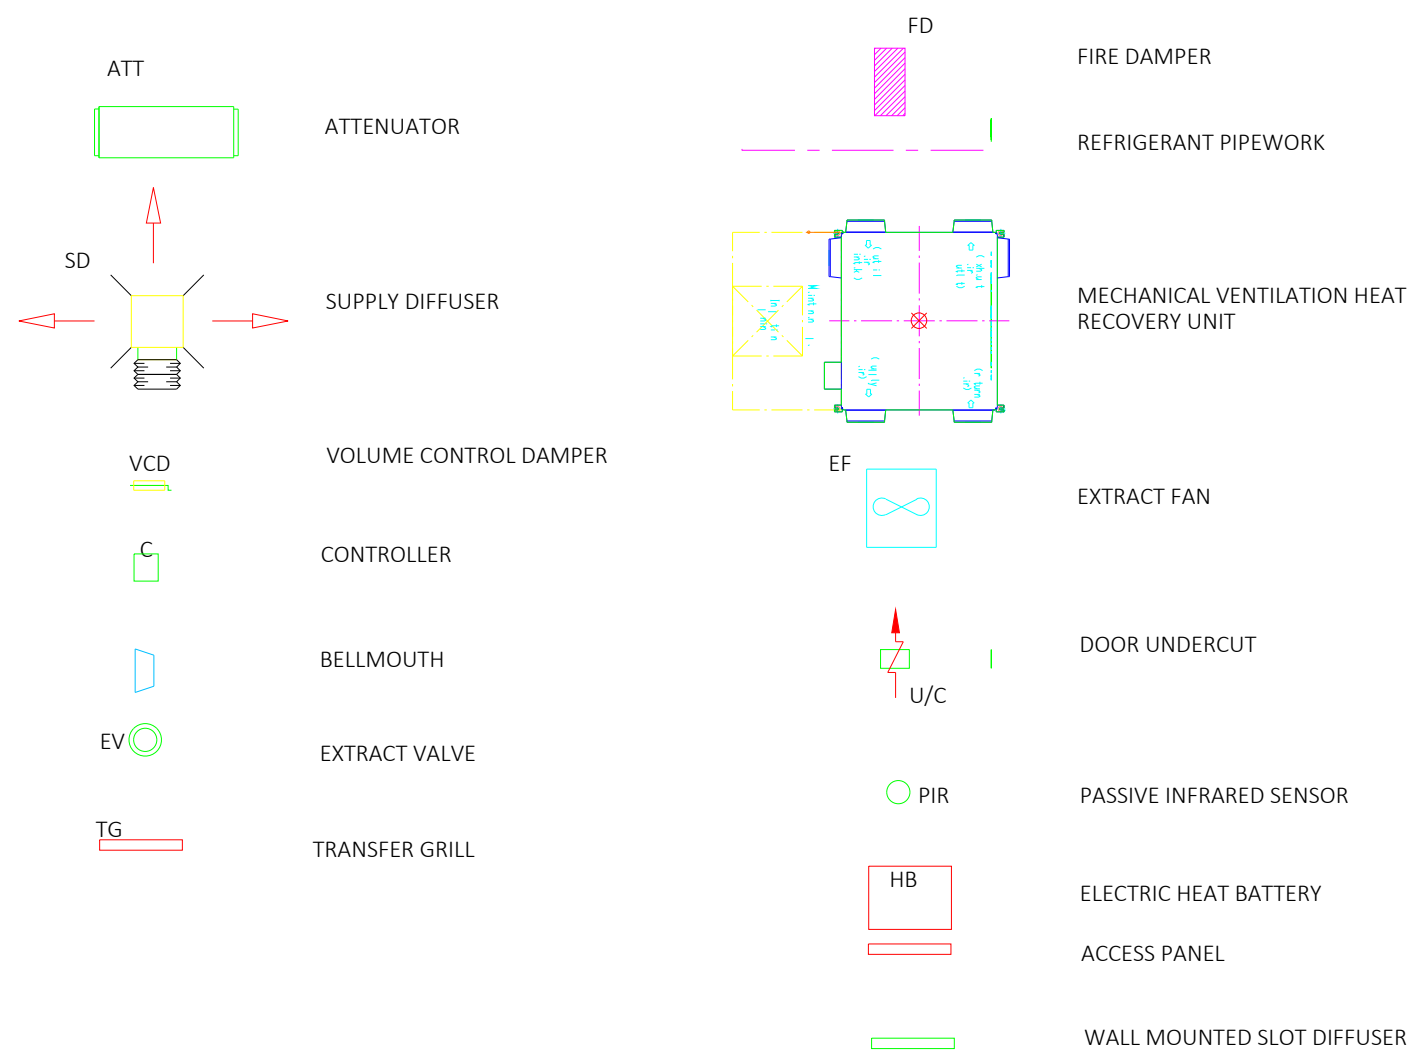

Notes:

- This drawing is subject to copyright and is not to be reproduced in part or whole without approval.
- Do not scale this drawing - check all dimensions on site.
- This drawing shall be read in conjunction with the project specification(s) and all other contract documentation.
- All dimensions are in millimetres unless otherwise stated.
- Location of all equipment shown shall be confirmed/approved with the Client/Architect/Engineer prior to any installation.
- This drawing must be read in conjunction with Mechanical and Electrical performance specifications and all other drawings as issued by the Architect, Structural Engineer and Watt Energy and Consulting Engineers.
- The location of equipment is typical only. The Contractor shall perform all calculations to determine the exact quantity and agree the final locations with the Architect.
- This drawing shows the intended location of building services plant and service routes in such detail as to indicate the design. The drawing does not show all components that may be necessary to provide a full working installation.
- The positions of connection points, accessories and building services items are approximate and shown for guidance to assist during the tender process.
- Fully co-ordinated drawings, Construction drawings and Builderswork drawings shall be produced by the contractor. Under no circumstances shall the tender drawings be used as installation drawings.

WE&CE DRAWINGS ARE FOR DESIGN INTENT ONLY.
THE MEP CONTRACTOR IS RESPONSIBLE FOR THE
FINAL INSTALLATION DRAWINGS INCLUDING ALL
SETTING OUT, DIMENSIONS, ALIGNMENT AND
COORDINATION WITH THE ARCHITECTS
REQUIREMENTS.

T2	04/07/23	TENDER ISSUE	DG
T1	11/04/23	TENDER ISSUE	DK
P2	24/03/23	PRELIMINARY ISSUE	MG
P1	10/03/23	PRELIMINARY ISSUE	MG
Rev:	Date:	Status/Amendments:	By:




40 KING STREET, MANCHESTER, M2 6BA
TEL: 0161 434 3103 EMAIL: office@wece.co.uk

Client:
CAPITAL AND CENTRIC


Project:
CHAPELTOWN WAREHOUSE

Drawing Title:
MECHANICAL SERVICES
VENTILATION AND AIR CONDITION LAYOUT
GROUND FLOOR

Drawn By: MG	Checked By: DW	Cad By: DK
Scale: 1:50	Paper Size: A1	Date Created: 15/02/2023
Drawing Number: WECE / 353 / M / 100	Drawing Revision: T2	

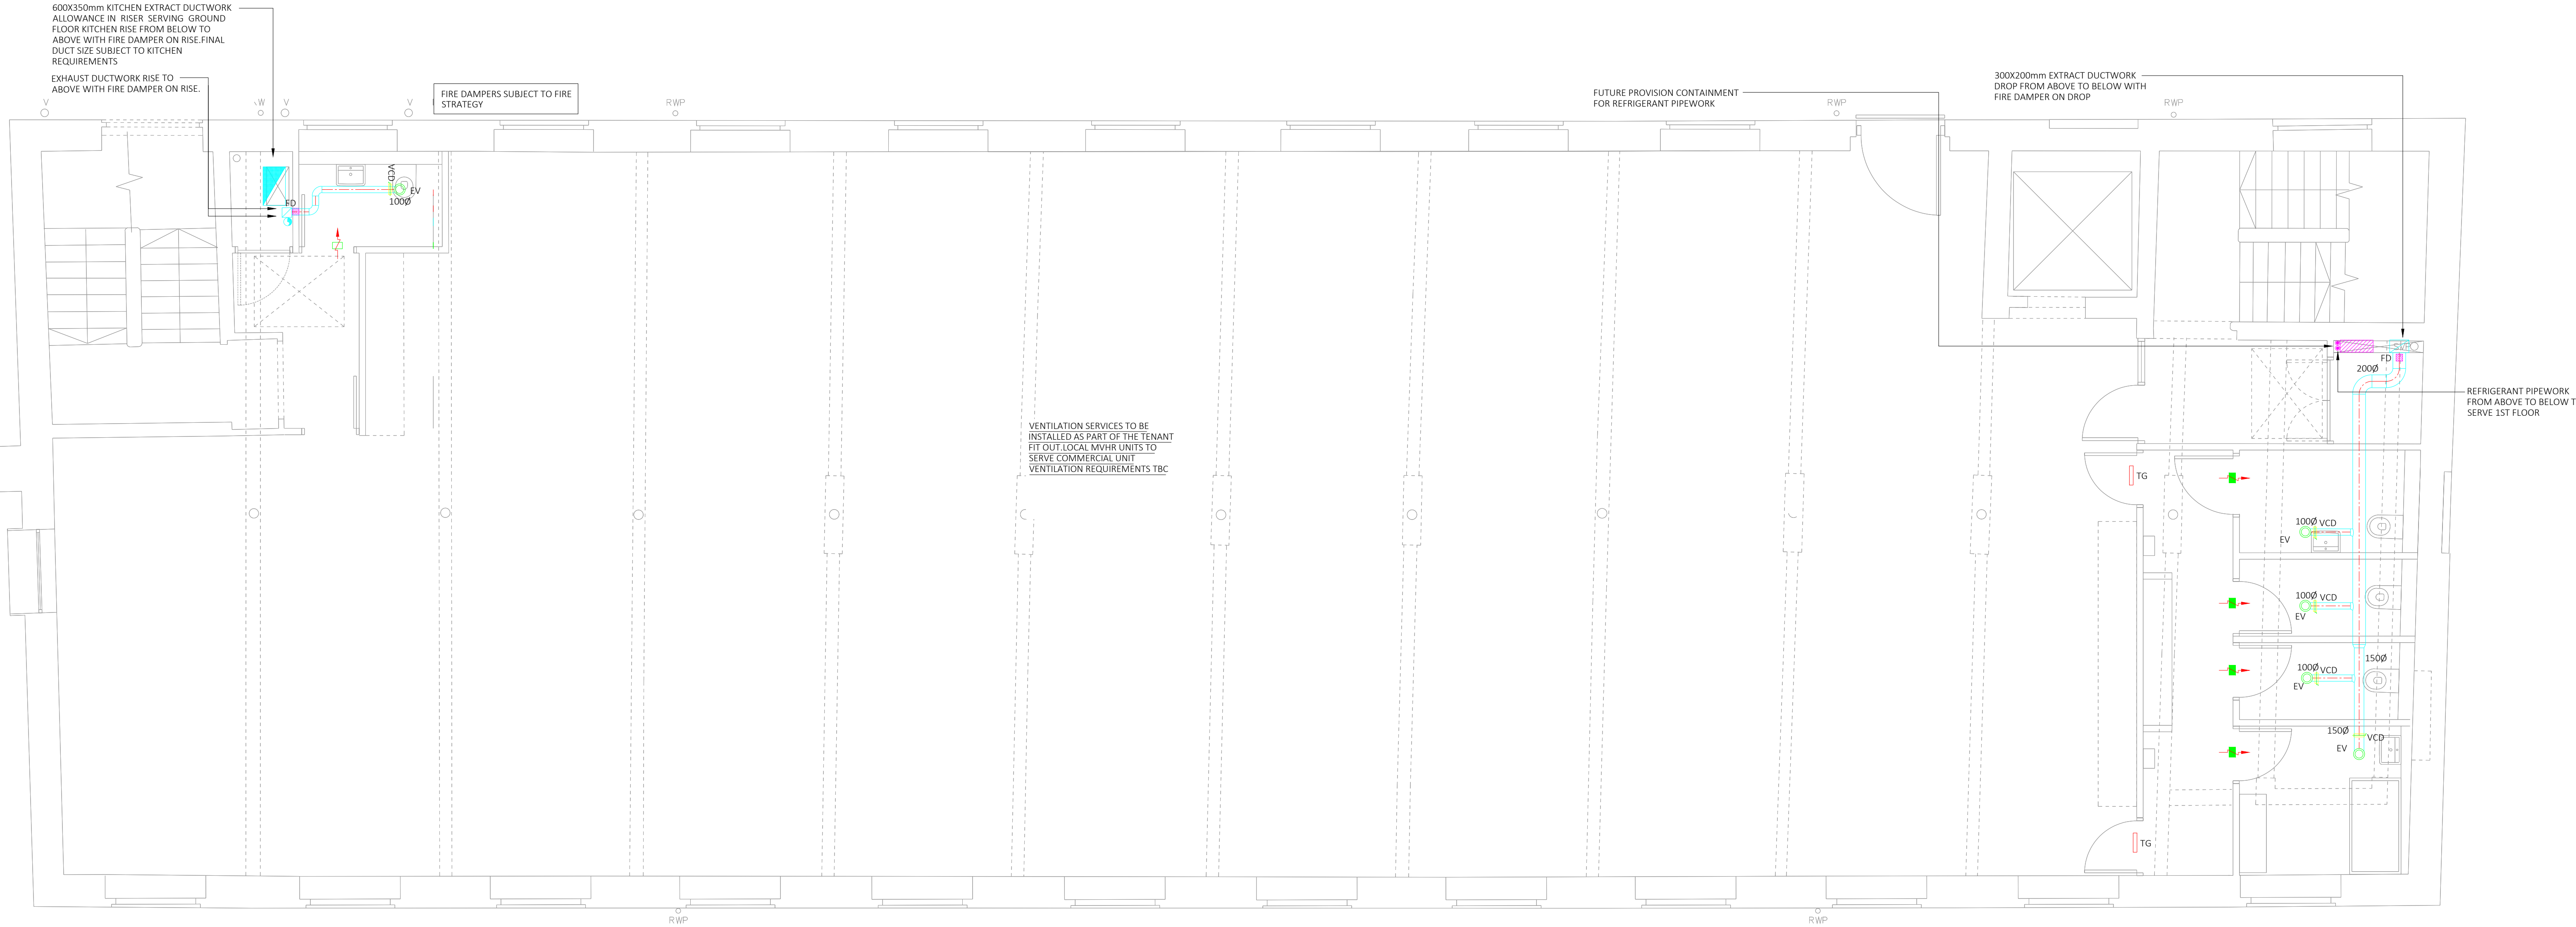

VENTILATION LEGEND

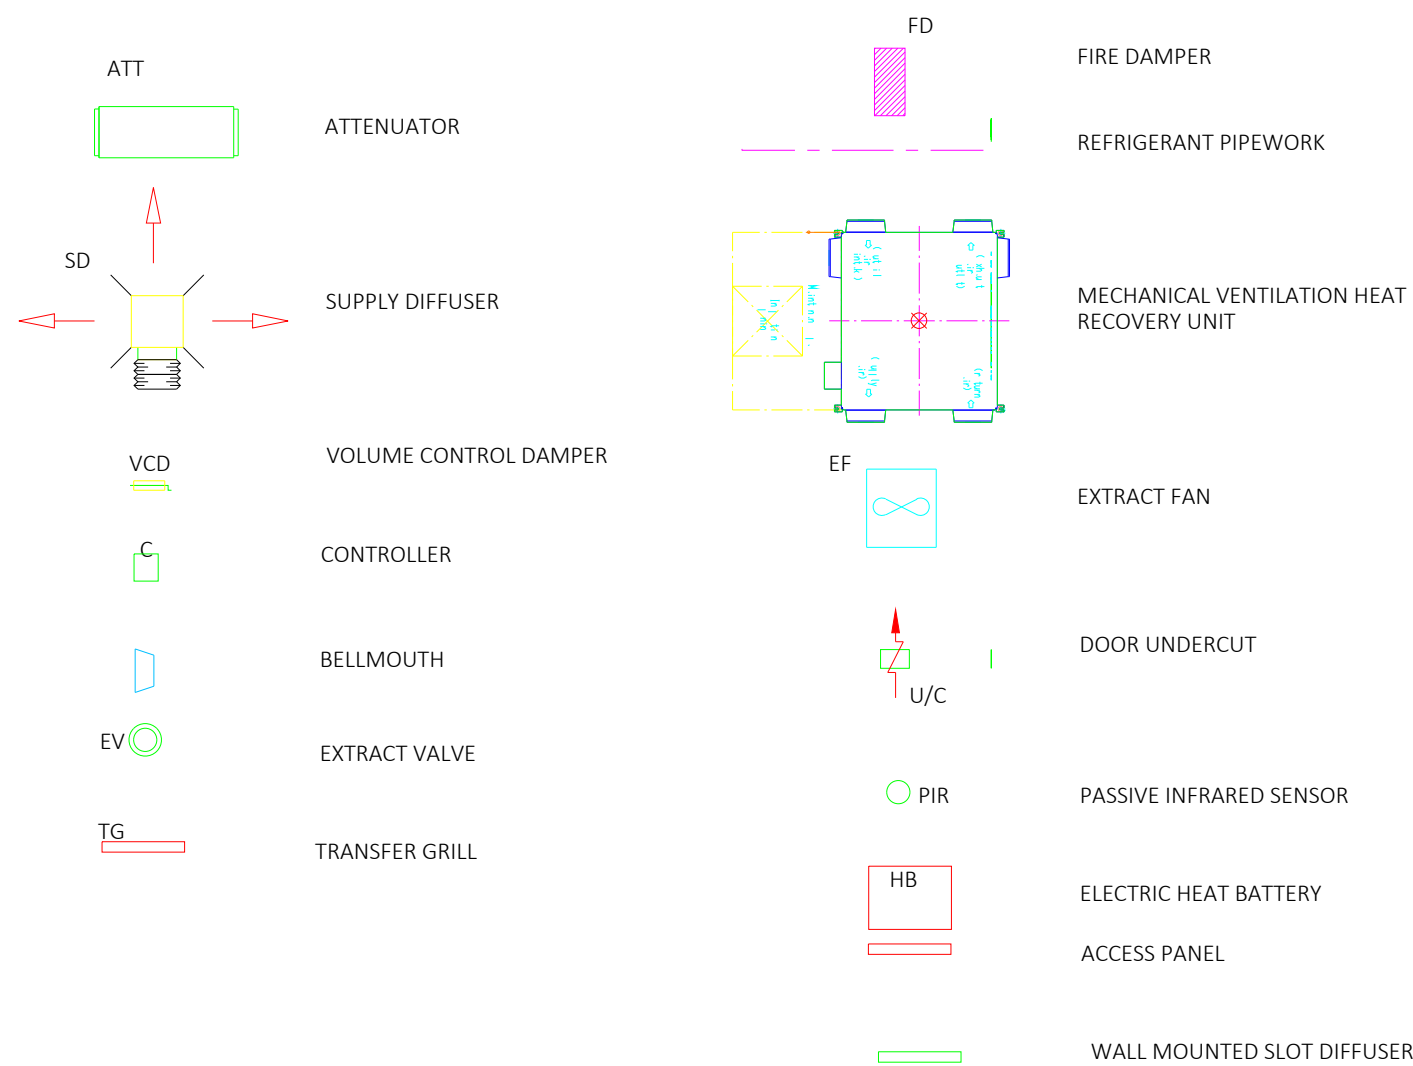

Notes:

- This drawing is subject to copyright and is not to be reproduced in part or whole without approval.
- Do not scale this drawing - check all dimensions on site.
- This drawing shall be read in conjunction with the project specification(s) and all other contract documentation.
- All dimensions are in millimetres unless otherwise stated.
- Location of all equipment shown shall be confirmed/approved with the Client/Architect/Engineer prior to any installation.
- This drawing must be read in conjunction with Mechanical and Electrical performance specifications and all other drawings as issued by the Architect, Structural Engineer and Watt Energy and Consulting Engineers.
- The location of equipment is typical only. The Contractor shall perform all calculations to determine the exact quantity and agree the final locations with the Architect.
- This drawing shows the intended location of building services plant and service routes in such detail as to indicate the design. The drawing does not show all components that may be necessary to provide a full working installation.
- The positions of connection points, accessories and building services items are approximate and shown for guidance to assist during the tender process.
- Fully co-ordinated drawings, Construction drawings and Builderswork drawings shall be produced by the contractor. Under no circumstances shall the tender drawings be used as installation drawings.

WE&CE DRAWINGS ARE FOR DESIGN INTENT ONLY.
THE MEP CONTRACTOR IS RESPONSIBLE FOR THE
FINAL INSTALLATION DRAWINGS INCLUDING ALL
SETTING OUT, DIMENSIONS, ALIGNMENT AND
COORDINATION WITH THE ARCHITECTS
REQUIREMENTS.

T3	04/07/23	TENDER ISSUE	DG
T2	22/06/23	TENDER ISSUE	MG
T1	11/04/23	TENDER ISSUE	DK
P2	24/03/23	PRELIMINARY ISSUE	MG
P1	10/03/23	PRELIMINARY ISSUE	MG
Rev:	Date:	Status/Amendments:	By:




40 KING STREET, MANCHESTER, M2 6BA
TEL: 0161 434 3103 EMAIL: office@wece.co.uk

Client:
CAPITAL AND CENTRIC


Project:
CHAPELTOWN WAREHOUSE

Drawing Title:
MECHANICAL SERVICES
VENTILATION AND AIR CONDITION LAYOUT
SECOND FLOOR

Drawn By: MG	Checked By: DW	Cad By: DK
Scale: 1:50	Paper Size: A1	Date Created: 15/02/2023
Drawing Number: WECE / 353 / M / 302	Drawing Revision: T3	

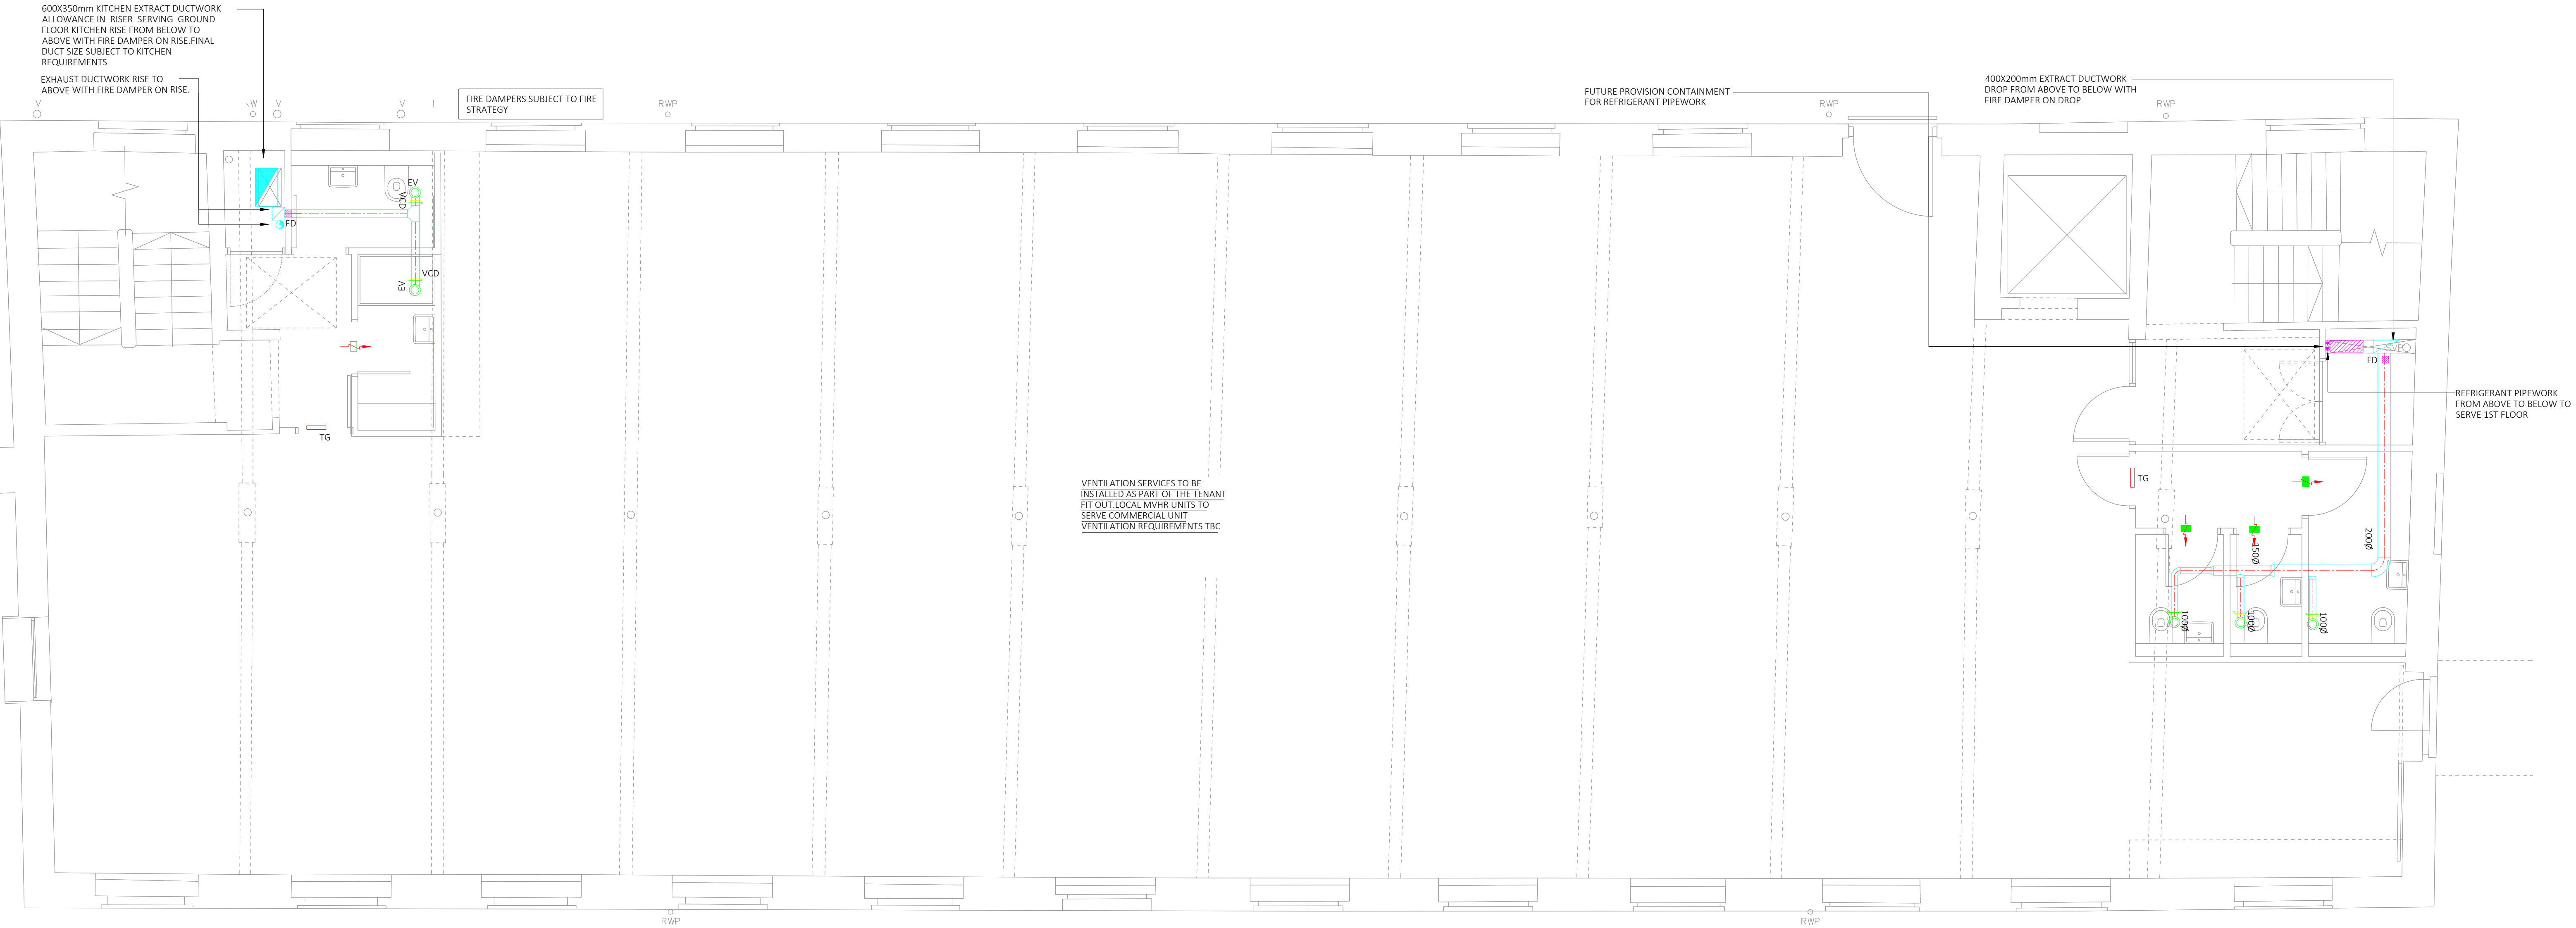

VENTILATION LEGEND

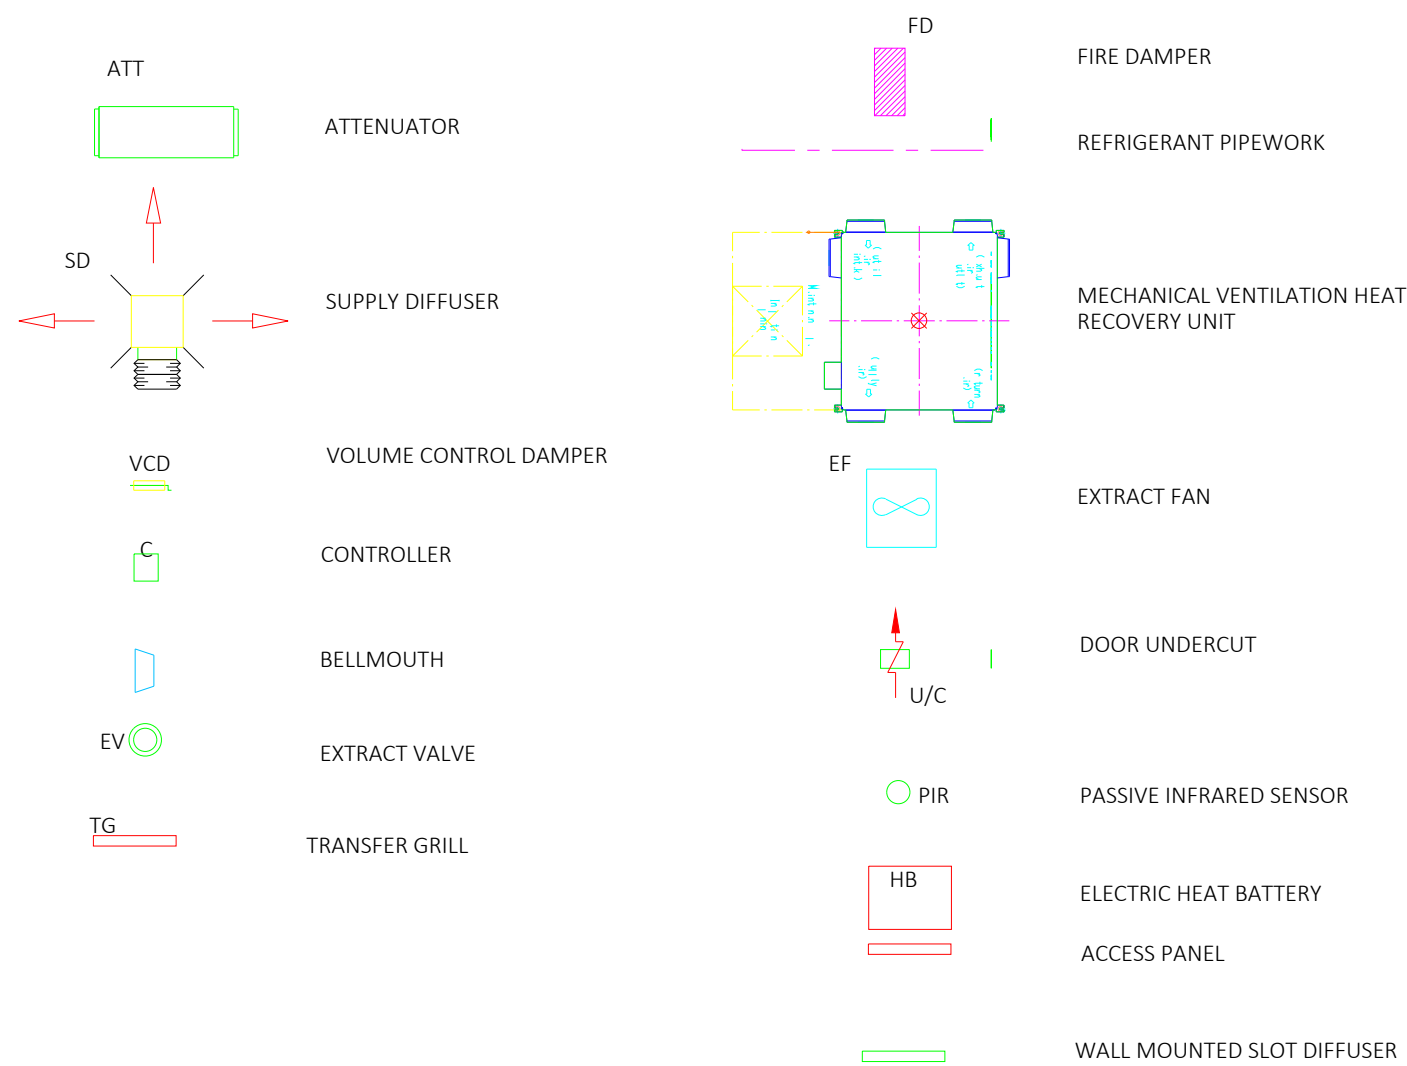

Notes:

- This drawing is subject to copyright and is not to be reproduced in part or whole without approval.
- Do not scale this drawing - check all dimensions on site.
- This drawing shall be read in conjunction with the project specification(s) and all other contract documentation.
- All dimensions are in millimetres unless otherwise stated.
- Location of all equipment shown shall be confirmed/approved with the Client/Architect/Engineer prior to any installation.
- This drawing must be read in conjunction with Mechanical and Electrical performance specifications and all other drawings as issued by the Architect, Structural Engineer and Watt Energy and Consulting Engineers.
- The location of equipment is typical only. The Contractor shall perform all calculations to determine the exact quantity and agree the final locations with the Architect.
- This drawing shows the intended location of building services plant and service routes in such detail as to indicate the design. The drawing does not show all components that may be necessary to provide a full working installation.
- The positions of connection points, accessories and building services items are approximate and shown for guidance to assist during the tender process.
- Fully co-ordinated drawings, Construction drawings and Builderswork drawings shall be produced by the contractor. Under no circumstances shall the tender drawings be used as installation drawings.

WE&CE DRAWINGS ARE FOR DESIGN INTENT ONLY.
THE MEP CONTRACTOR IS RESPONSIBLE FOR THE
FINAL INSTALLATION DRAWINGS INCLUDING ALL
SETTING OUT, DIMENSIONS, ALIGNMENT AND
COORDINATION WITH THE ARCHITECTS
REQUIREMENTS.

T3	04/07/23	TENDER ISSUE	DG
T2	22/06/23	TENDER ISSUE	MG
T1	11/04/23	TENDER ISSUE	DK
P2	24/03/23	PRELIMINARY ISSUE	MG
P1	10/03/23	PRELIMINARY ISSUE	MG
Rev:	Date:	Status/Amendments:	By:




40 KING STREET, MANCHESTER, M2 6BA
TEL: 0161 434 3103 EMAIL: office@wece.co.uk

Client:
CAPITAL AND CENTRIC


Project:
CHAPELTOWN WAREHOUSE

Drawing Title:
MECHANICAL SERVICES
VENTILATION AND AIR CONDITION LAYOUT
THIRD FLOOR

Drawn By: MG	Checked By: DW	Cad By: DK
Scale: 1:50	Paper Size: A1	Date Created: 15/02/2023
Drawing Number: WECE / 353 / M / 303	Drawing Revision: T3	

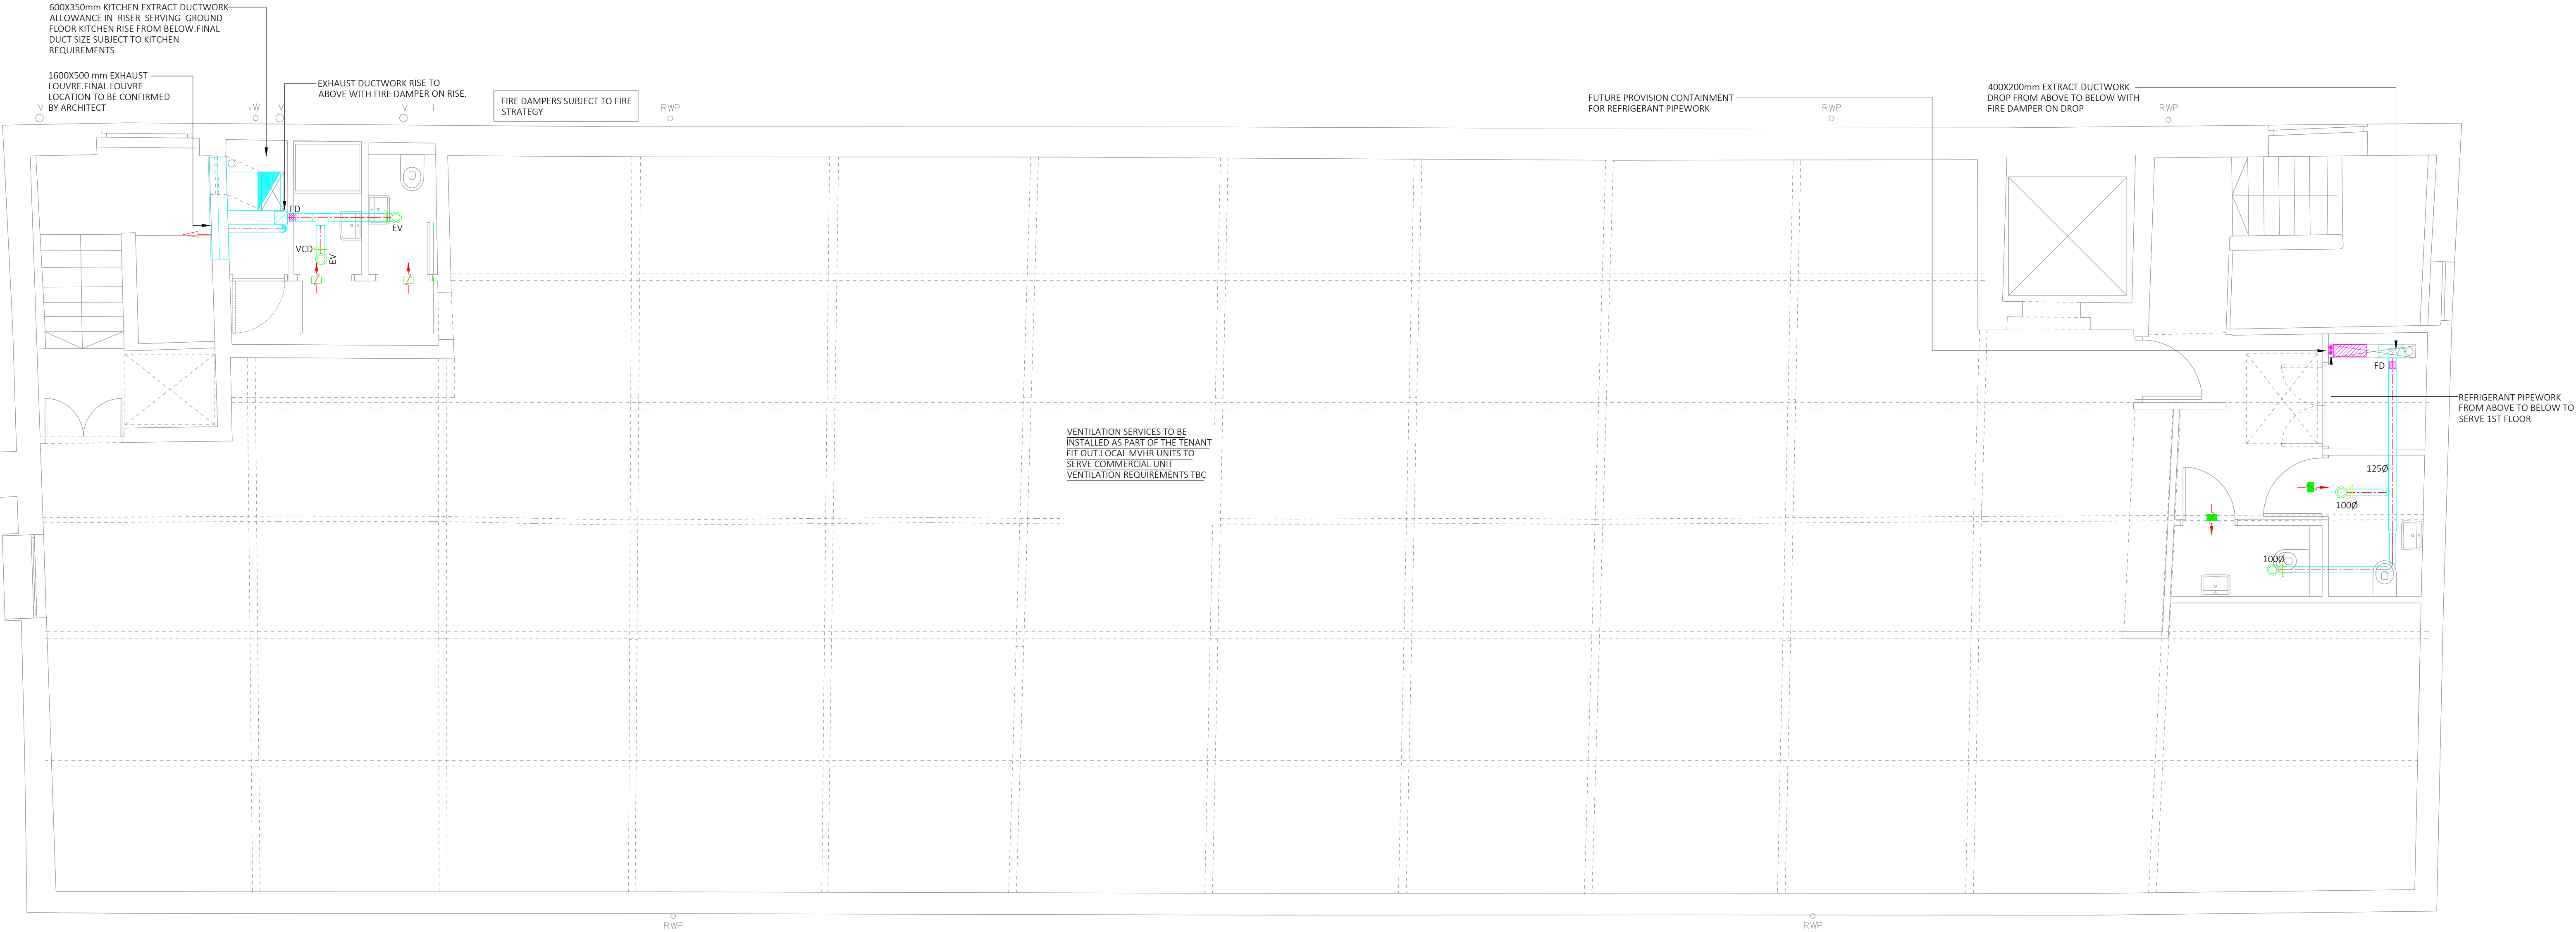

VENTILATION LEGEND

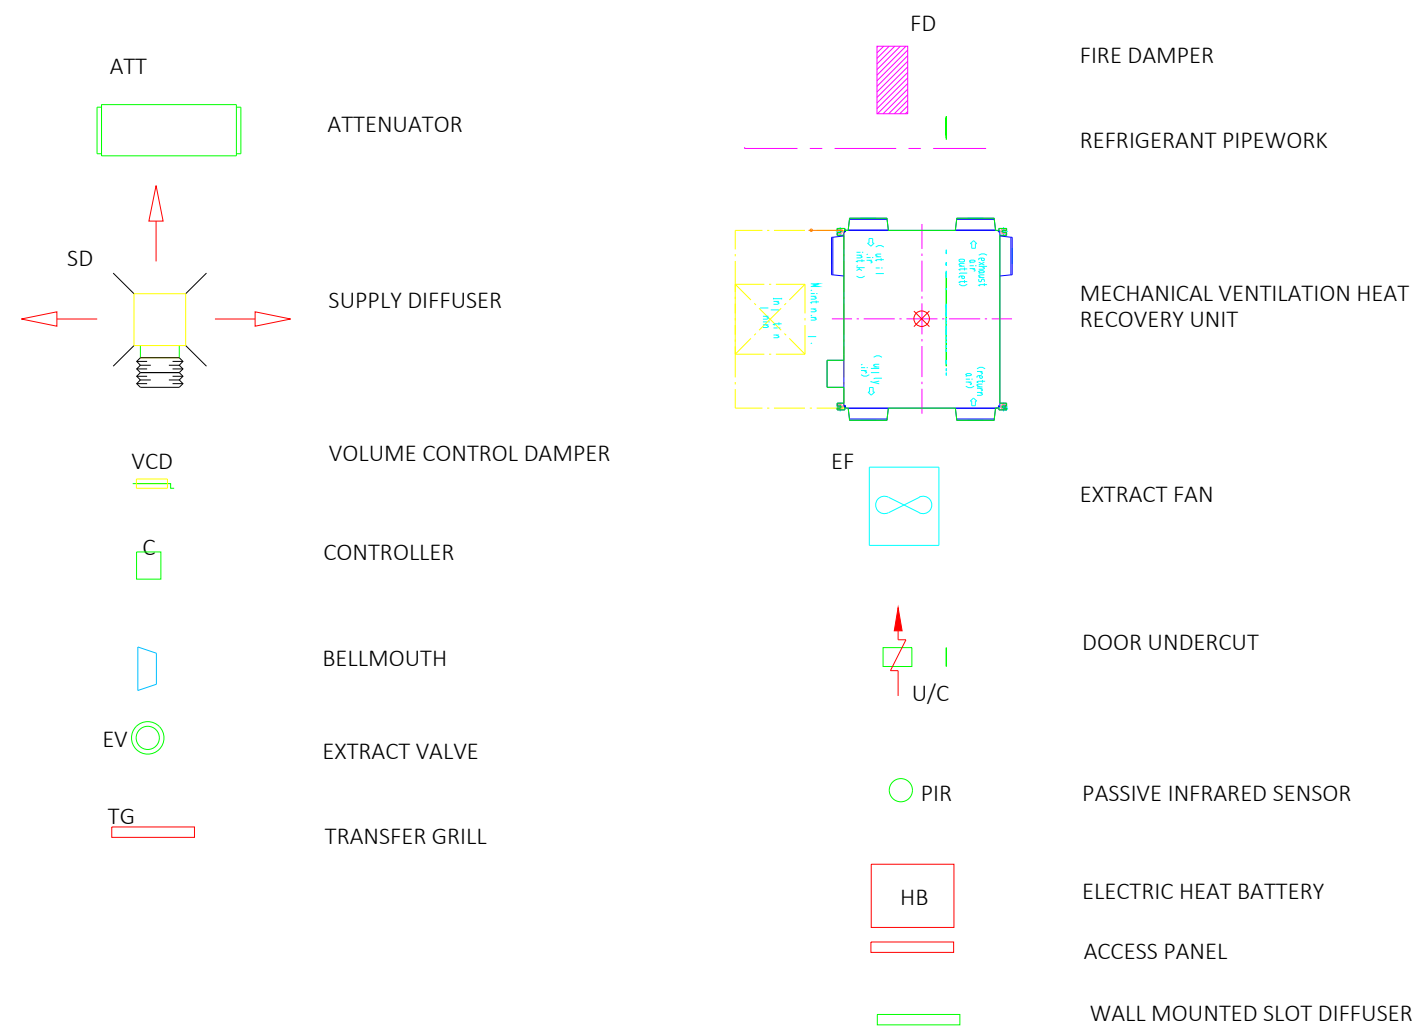

Notes:

- This drawing is subject to copyright and is not to be reproduced in part or whole without approval.
- Do not scale this drawing - check all dimensions on site.
- This drawing shall be read in conjunction with the project specification(s) and all other contract documentation.
- All dimensions are in millimetres unless otherwise stated.
- Location of all equipment shown shall be confirmed/approved with the Client/Architect/Engineer prior to any installation.
- This drawing must be read in conjunction with Mechanical and Electrical performance specifications and all other drawings as issued by the Architect, Structural Engineer and Watt Energy and Consulting Engineers.
- The location of equipment is typical only. The Contractor shall perform all calculations to determine the exact quantity and agree the final locations with the Architect.
- This drawing shows the intended location of building services plant and service routes in such detail as to indicate the design. The drawing does not show all components that may be necessary to provide a full working installation.
- The positions of connection points, accessories and building services items are approximate and shown for guidance to assist during the tender process.
- Fully co-ordinated drawings, Construction drawings and Builderswork drawings shall be produced by the contractor. Under no circumstances shall the tender drawings be used as installation drawings.

WE&CE DRAWINGS ARE FOR DESIGN INTENT ONLY.
THE MEP CONTRACTOR IS RESPONSIBLE FOR THE
FINAL INSTALLATION DRAWINGS INCLUDING ALL
SETTING OUT, DIMENSIONS, ALIGNMENT AND
COORDINATION WITH THE ARCHITECTS
REQUIREMENTS.

T3	04/07/23	TENDER ISSUE	DG
T2	22/06/23	TENDER ISSUE	MG
T1	11/04/23	TENDER ISSUE	DK
P2	24/03/23	PRELIMINARY ISSUE	MG
P1	10/03/23	PRELIMINARY ISSUE	MG
Rev:	Date:	Status/Amendments:	By:




40 KING STREET, MANCHESTER, M2 6BA
TEL: 0161 434 3103 EMAIL: office@wece.co.uk

Client:
CAPITAL AND CENTRIC


Project:
CHAPELTOWN WAREHOUSE

Drawing Title:
MECHANICAL SERVICES
VENTILATION AND AIR CONDITION LAYOUT
FOURTH FLOOR

Drawn By: MG	Checked By: DW	Cad By: DK
Scale: 1:50	Paper Size: A1	Date Created: 15/02/2023
Drawing Number: WECE / 353 / M / 304	Drawing Revision: T3	

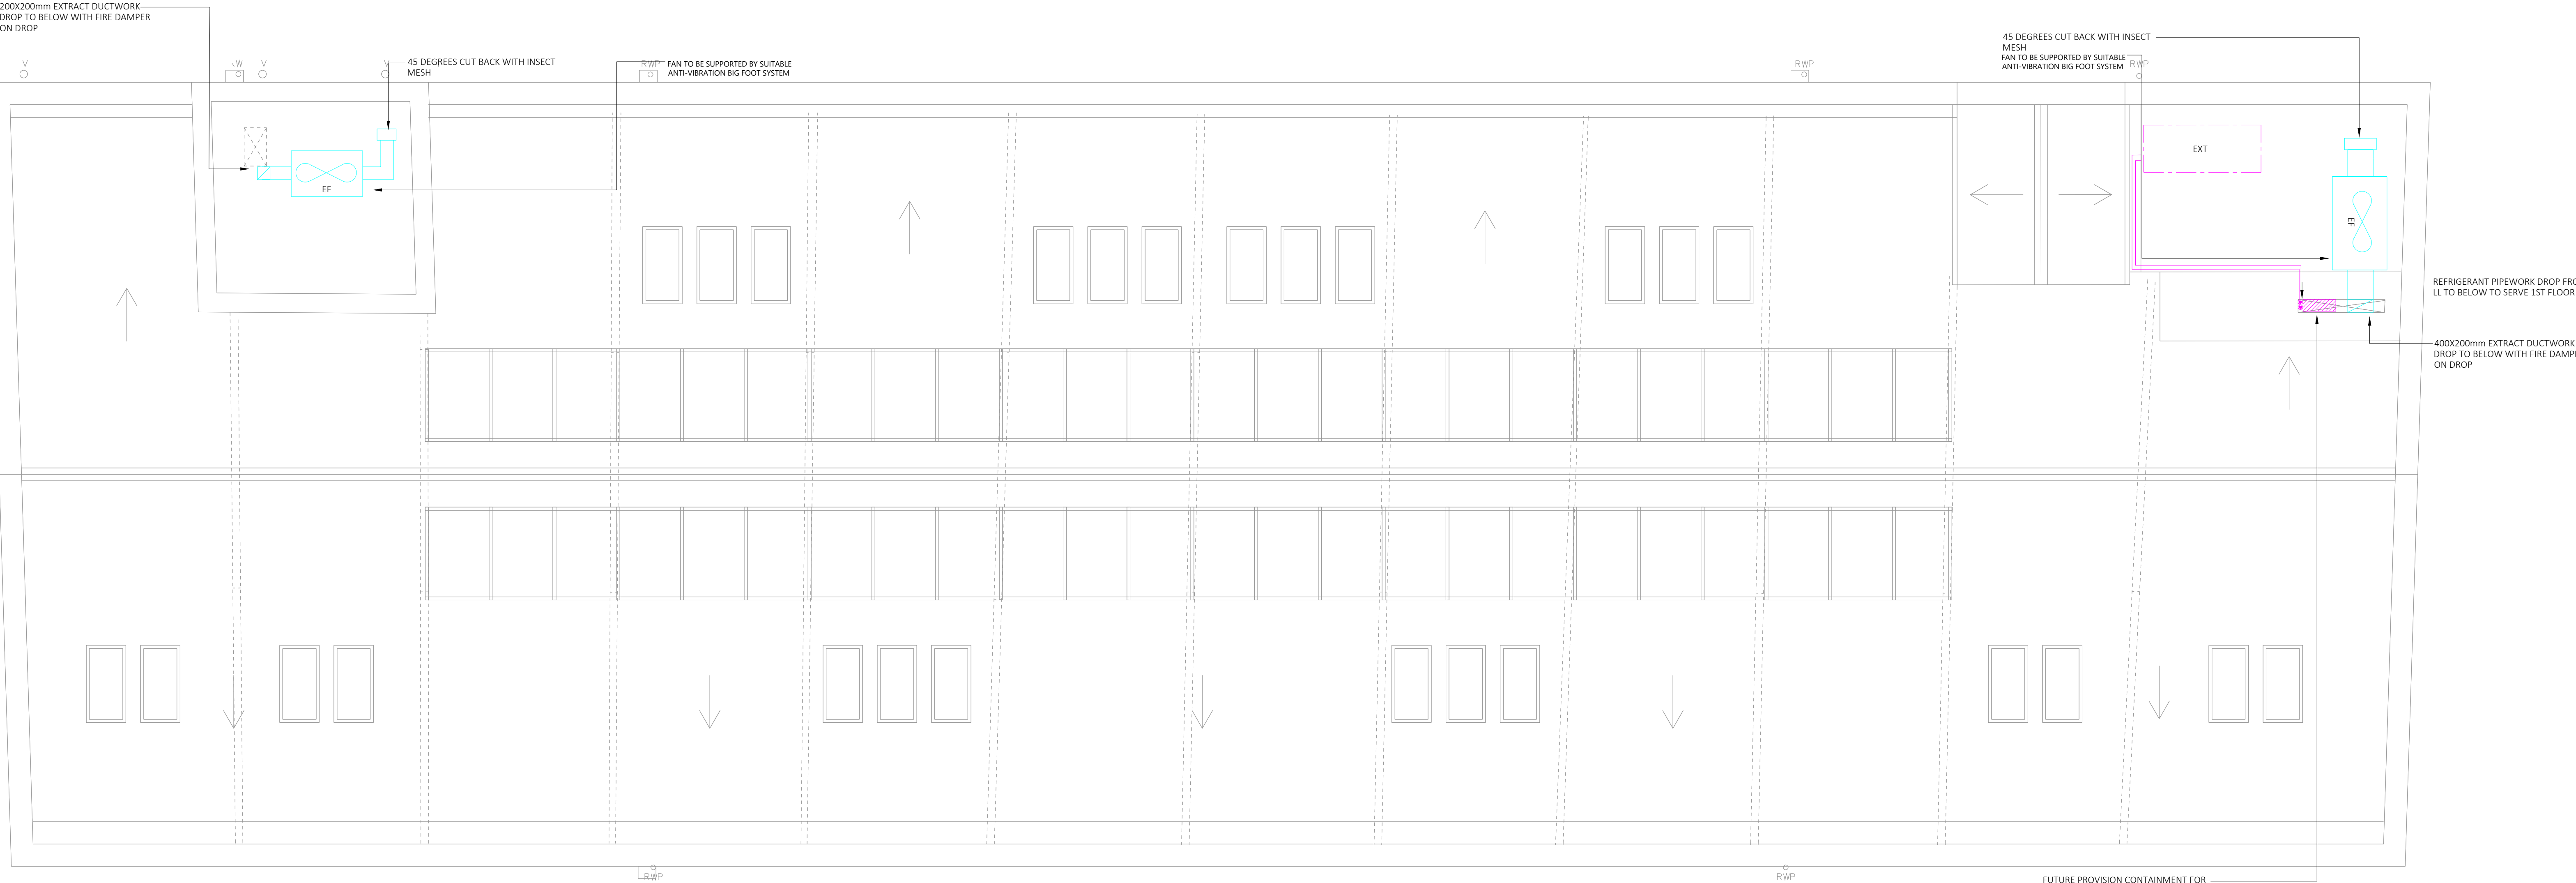

VENTILATION LEGEND

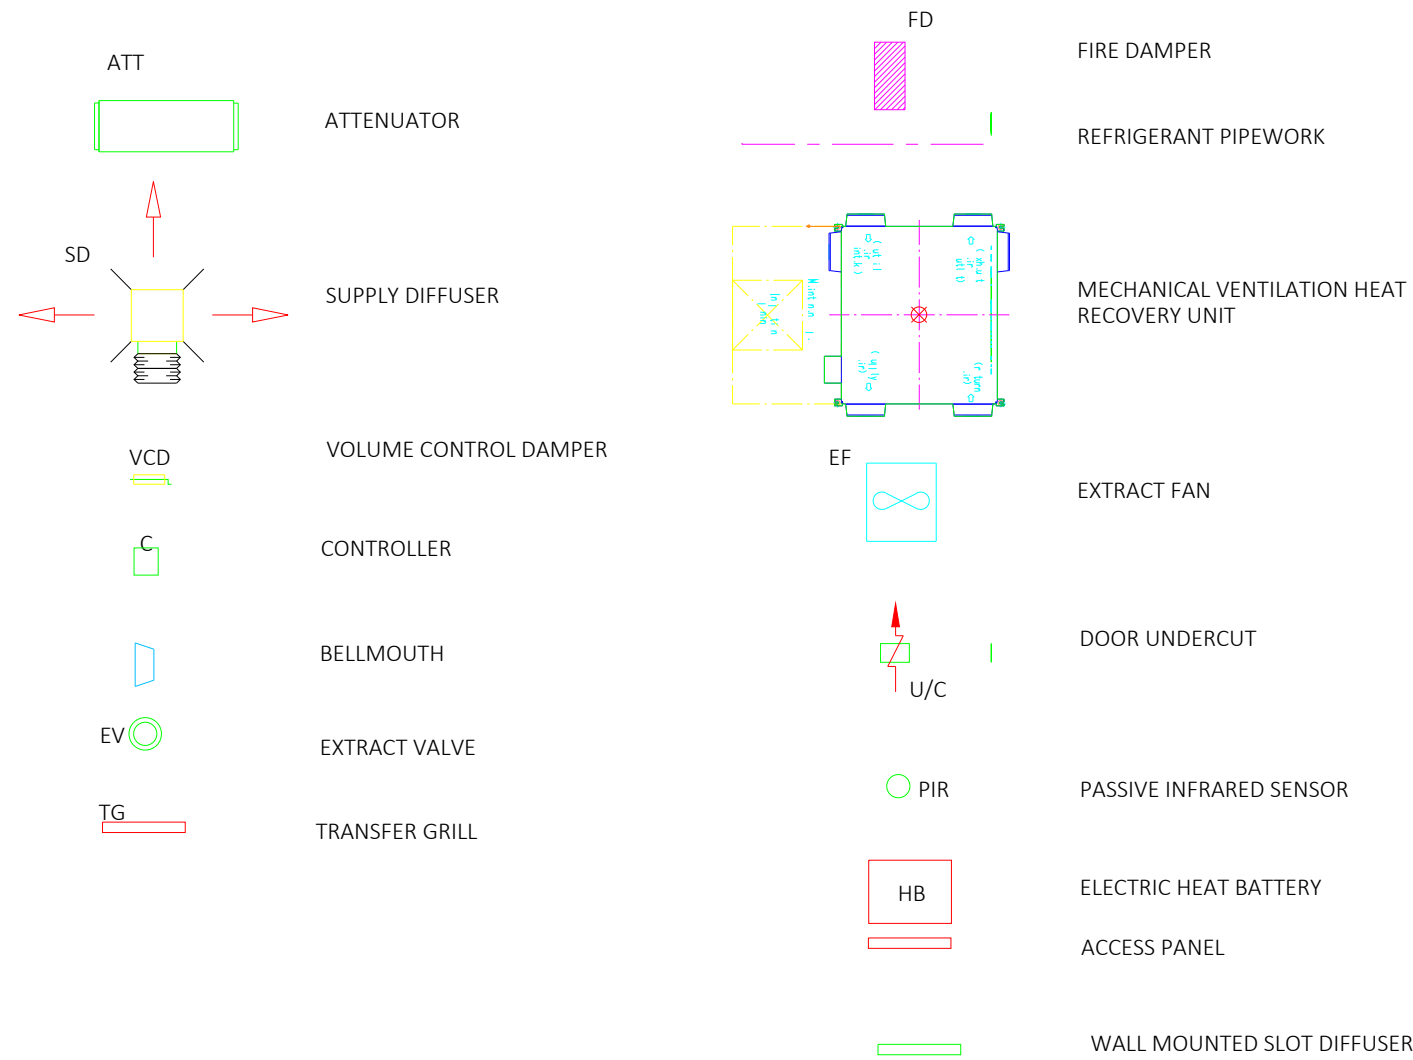

Notes:

- This drawing is subject to copyright and is not to be reproduced in part or whole without approval.
- Do not scale this drawing - check all dimensions on site.
- This drawing shall be read in conjunction with the project specification(s) and all other contract documentation.
- All dimensions are in millimetres unless otherwise stated.
- Location of all equipment shown shall be confirmed/approved with the Client/Architect/Engineer prior to any installation.
- This drawing must be read in conjunction with Mechanical and Electrical performance specifications and all other drawings as issued by the Architect, Structural Engineer and Watt Energy and Consulting Engineers.
- The location of equipment is typical only. The Contractor shall perform all calculations to determine the exact quantity and agree the final locations with the Architect.
- This drawing shows the intended location of building services plant and service routes in such detail as to indicate the design. The drawing does not show all components that may be necessary to provide a full working installation.
- The positions of connection points, accessories and building services items are approximate and shown for guidance to assist during the tender process.
- Fully co-ordinated drawings, Construction drawings and Builderswork drawings shall be produced by the contractor. Under no circumstances shall the tender drawings be used as installation drawings.

WE&CE DRAWINGS ARE FOR DESIGN INTENT ONLY.
THE MEP CONTRACTOR IS RESPONSIBLE FOR THE
FINAL INSTALLATION DRAWINGS INCLUDING ALL
SETTING OUT, DIMENSIONS, ALIGNMENT AND
COORDINATION WITH THE ARCHITECTS
REQUIREMENTS.

T3	04/07/23	TENDER ISSUE	DG
T2	22/06/23	TENDER ISSUE	MG
T1	11/04/23	TENDER ISSUE	DK
P2	24/03/23	PRELIMINARY ISSUE	MG
P1	10/03/23	PRELIMINARY ISSUE	MG
Rev:	Date:	Status/Amendments:	By:

40 KING STREET, MANCHESTER, M2 6BA
TEL: 0161 434 3103 EMAIL: office@wece.co.uk

Client:
CAPITAL AND CENTRIC

Project:
CHAPELTOWN WAREHOUSE

Drawing Title:
MECHANICAL SERVICES
VENTILATION AND AIR CONDITION LAYOUT
ROOF

Drawn By: MG	Checked By: DW	Cad By: DK
Scale: 1:50	Paper Size: A1	Date Created: 15/02/2023
Drawing Number: WECE / 353 / M / 305	Drawing Revision: T3	