



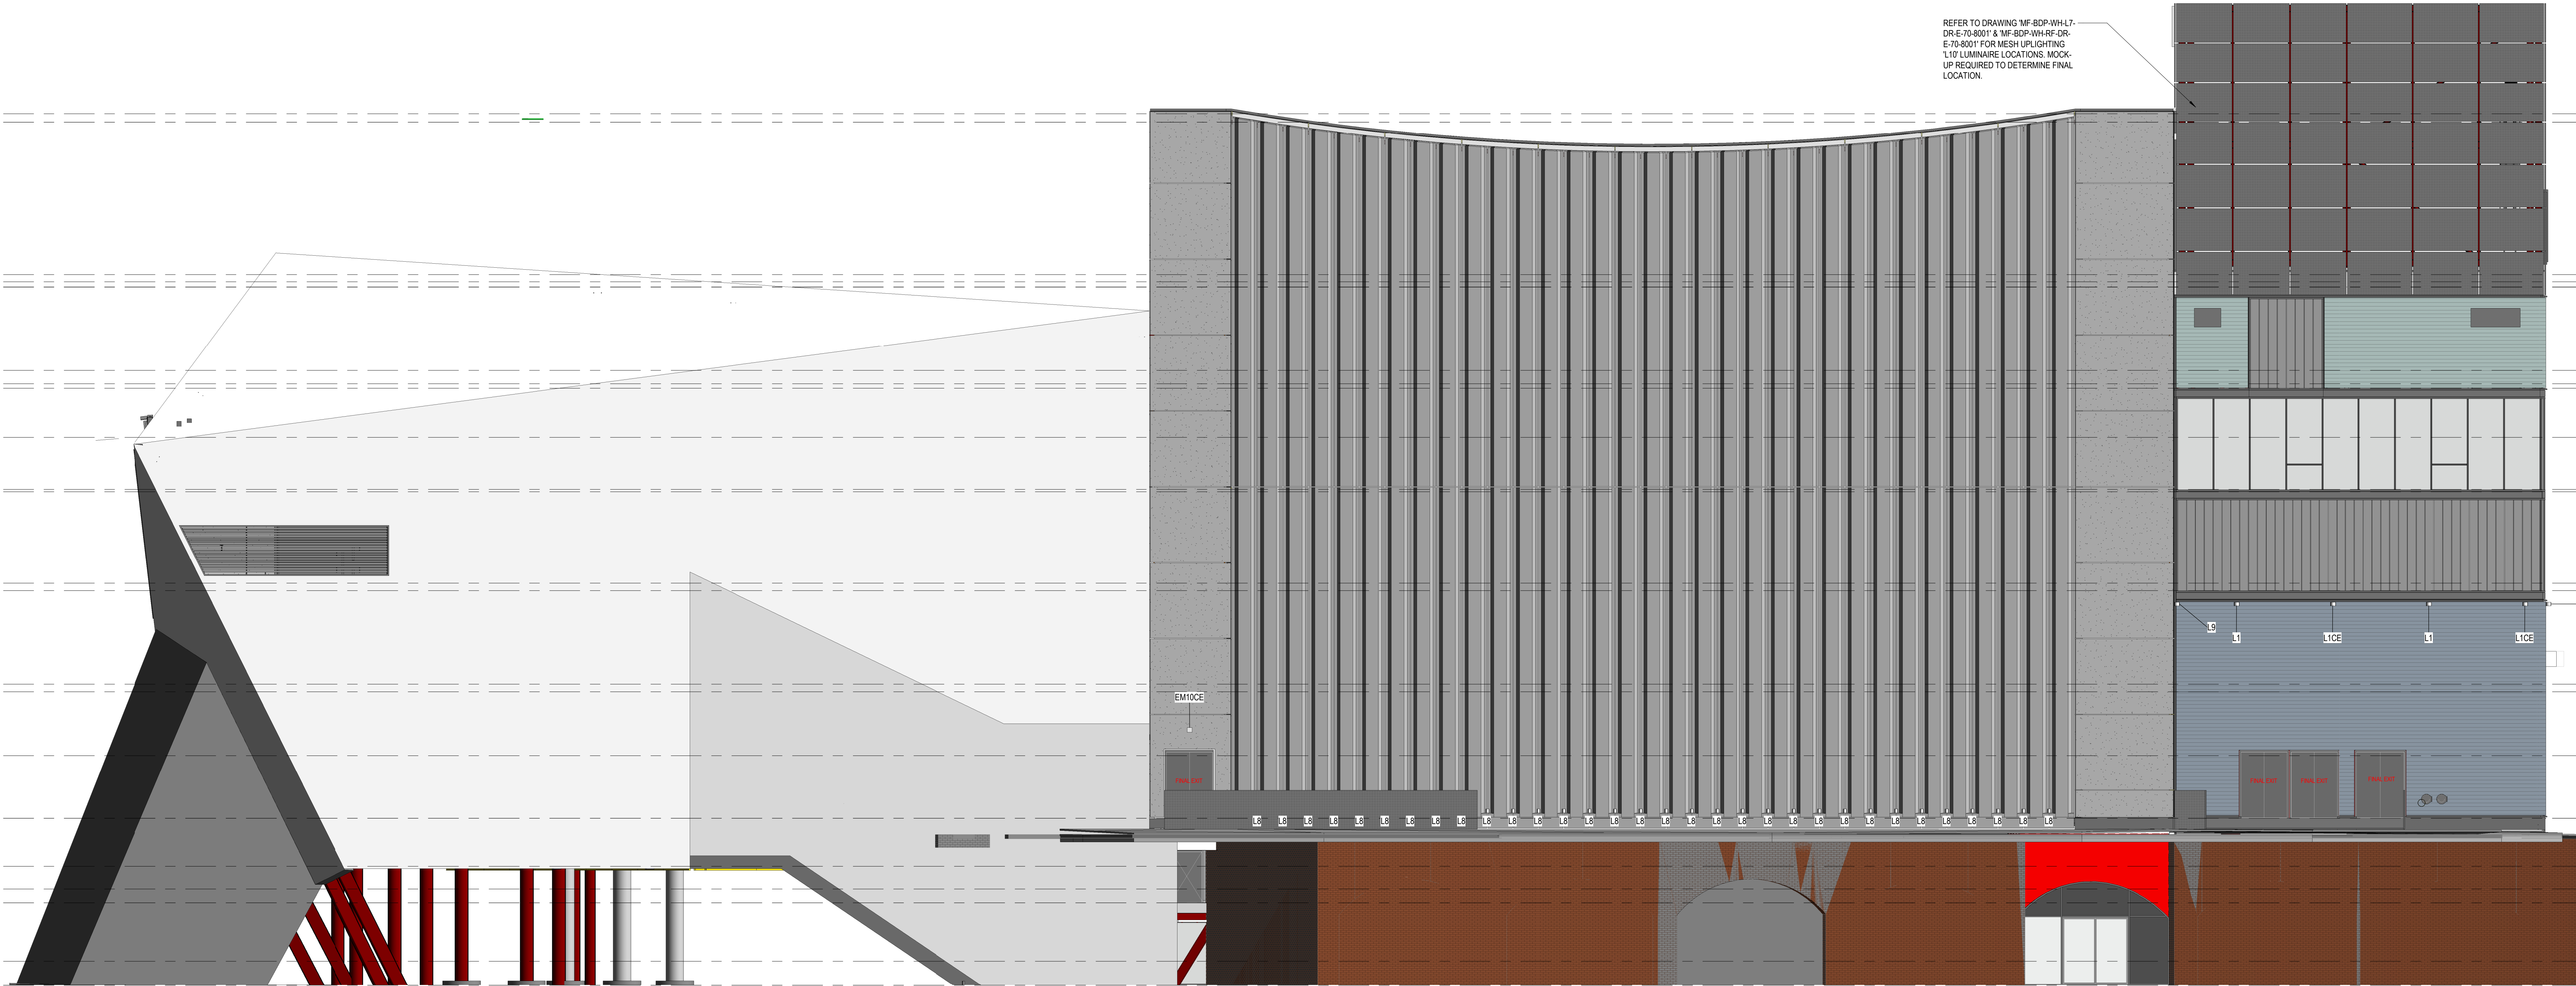

1 Elevation South
SCALE: 1 : 100

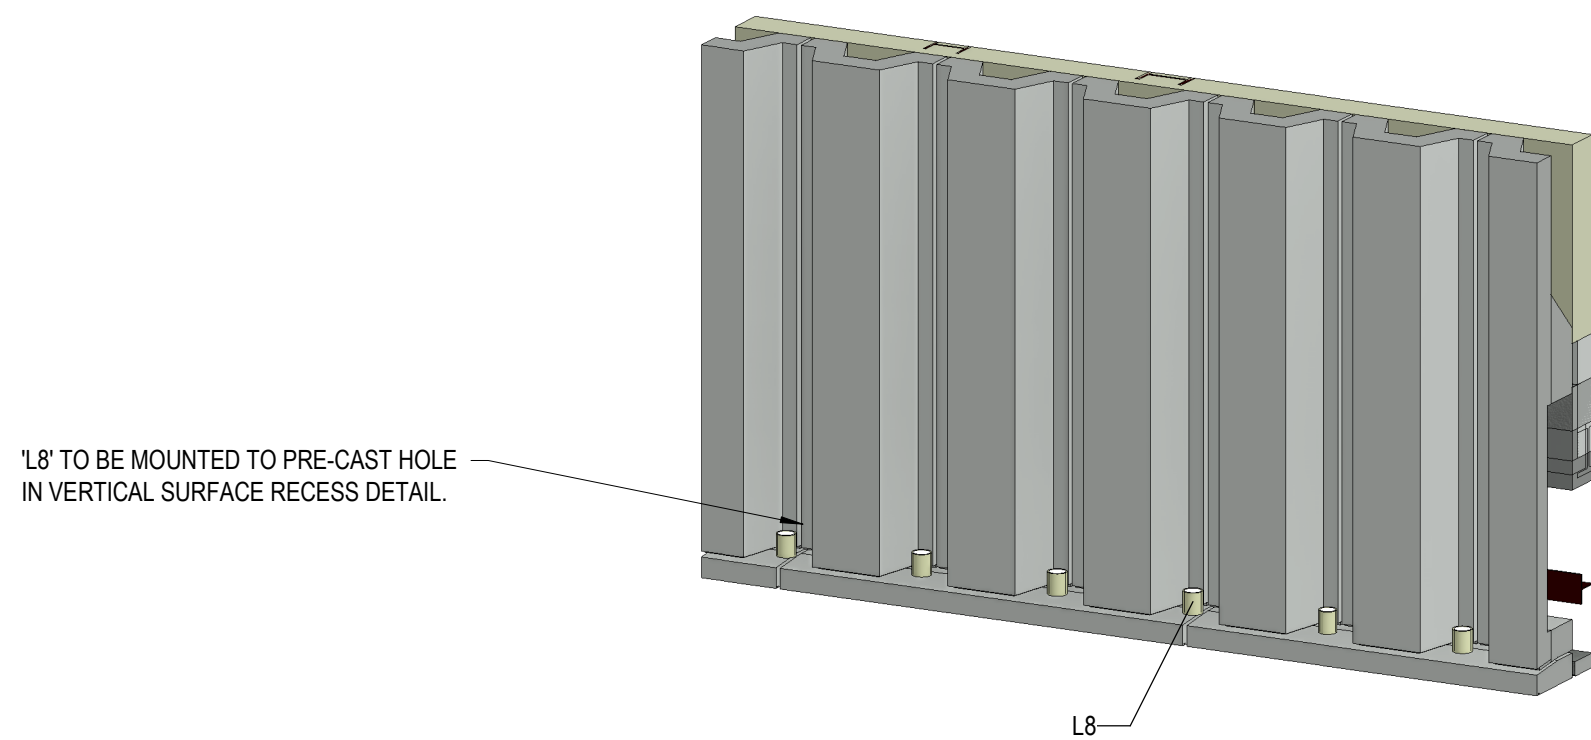


2 Warehouse Gable End Up-lighting Detail
SCALE:

BUILDING DESIGN PARTNERSHIP SHALL HAVE NO RESPONSIBILITY FOR ANY USE MADE OF THIS DOCUMENT OTHER THAN THAT FOR WHICH IT WAS PREPARED AND ISSUED.
ALL DIMENSIONS SHOULD BE CHECKED ON SITE.
DO NOT SCALE FROM THIS DRAWING.
ANY DRAWING ERRORS OR DISCREPANCIES SHOULD BE BROUGHT TO THE ATTENTION OF BUILDING DESIGN PARTNERSHIP AT THE ADDRESS SHOWN BELOW.
DRAWINGS SHALL BE READ IN CONJUNCTION WITH THE FOLLOWING BEFORE WORK COMMENCES:
• THE CDM DESIGN ISSUES REGISTER
• THE BDP RISK SERIES OF DRAWINGS
• THE PROJECT CDM RISK REGISTER

NOTES

1. THE INFORMATION SHOWN ON THIS DRAWING IS BASED UPON THE MODEL AND DRAWINGS ISSUED BY THE PROJECT ARCHITECT ON THE DATES AS INDICATED BELOW.
2. THIS DRAWING SHALL BE READ IN CONJUNCTION WITH THE LUMINAIRE SCHEDULE AND LIGHTING SPECIFICATION.
3. THIS IS NOT A COORDINATED WORKING OR INSTALLATION DRAWING.
4. THE PURPOSE OF THIS DRAWING AND THE ASSOCIATED BIM MODEL IT HAS BEEN FORMED FROM IS TO PROVIDE A LEVEL OF DETAIL SUITABLE FOR BUREAU PRO FORMA A1 - TECHNICAL DESIGN.
5. DO NOT SCALE FROM THIS DRAWING. ALL DIMENSIONS ARE IN MILLIMETRES UNLESS OTHERWISE STATED.
6. LUMINAIRES WITH SUFFIX 'CE' ARE EMERGENCY LUMINAIRES TO HAVE CONTINGENT BATTERY SUPPLY WITH 3HR EMERGENCY LIGHTING FUNCTION.
7. ALL EXITS TO HAVE FINAL EXIT EMERGENCY LUMINAIRE LOCATED WITHIN 2M.
8. REVIEW AND COORDINATION OF EMERGENCY LIGHTING LOCATIONS REQUIRED TO COORDINATE WITH ONGOING ARCHITECTURAL UPDATES.
9. REVIEW AND COORDINATION OF LUMINAIRE LOCATIONS REQUIRED TO COORDINATE WITH ONGOING ARCHITECTURAL UPDATES.

001 CONTRACT ISSUE - VE ALTERATIONS				001	IMMEDIATE	13.11.20
Rev	Description	By	Checked	Drawn	Issue	
01	01 - DM	01	01	01	01	01
A	28090903	00A	00A	00A	00A	00A
S	15100003	00S	00S	00S	00S	00S
Y	01100003	00Y	00Y	00Y	00Y	00Y

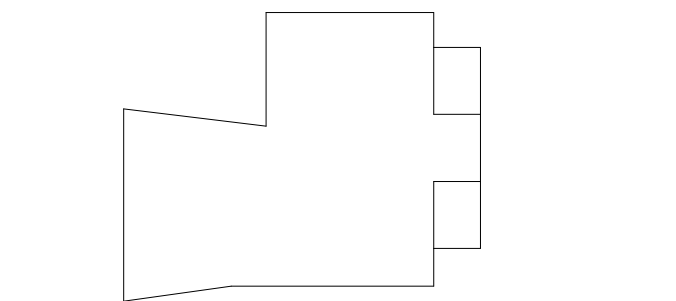

MANCHESTER CITY COUNCIL
Albert Square, Town Hall,
M2 5DB, Manchester
United Kingdom
T +44 (0) 161 234 5004

11 Ducie Street
PO Box 85
Piccadilly Basin
Manchester
M60 3JA
United Kingdom
T +44 (0) 161 628 2200
www.bdp.com

For Information
P2008093
Manchester Factory
Electrical Engineering Services
Facades
Elevation South
Lighting Systems

Revised	Issue	Revised	Issue	Revised	Issue	Revised	Issue
CC	NM	13/11/20	1: 100	CC	NM	13/11/20	1: 100

MF-BDP-XX-XX-DR-E-70-8095

C01