



SHIP CANAL HOUSE, MANCHESTER

TYPICAL LIFT LOBBY - CEILING + FEATURE LIGHTING LAYOUT


This drawing is the property of **bluesky** Design and must not be copied or otherwise reproduced. All dimensions must be checked on site before commencing work. This drawing was produced using AutoCAD 2019.

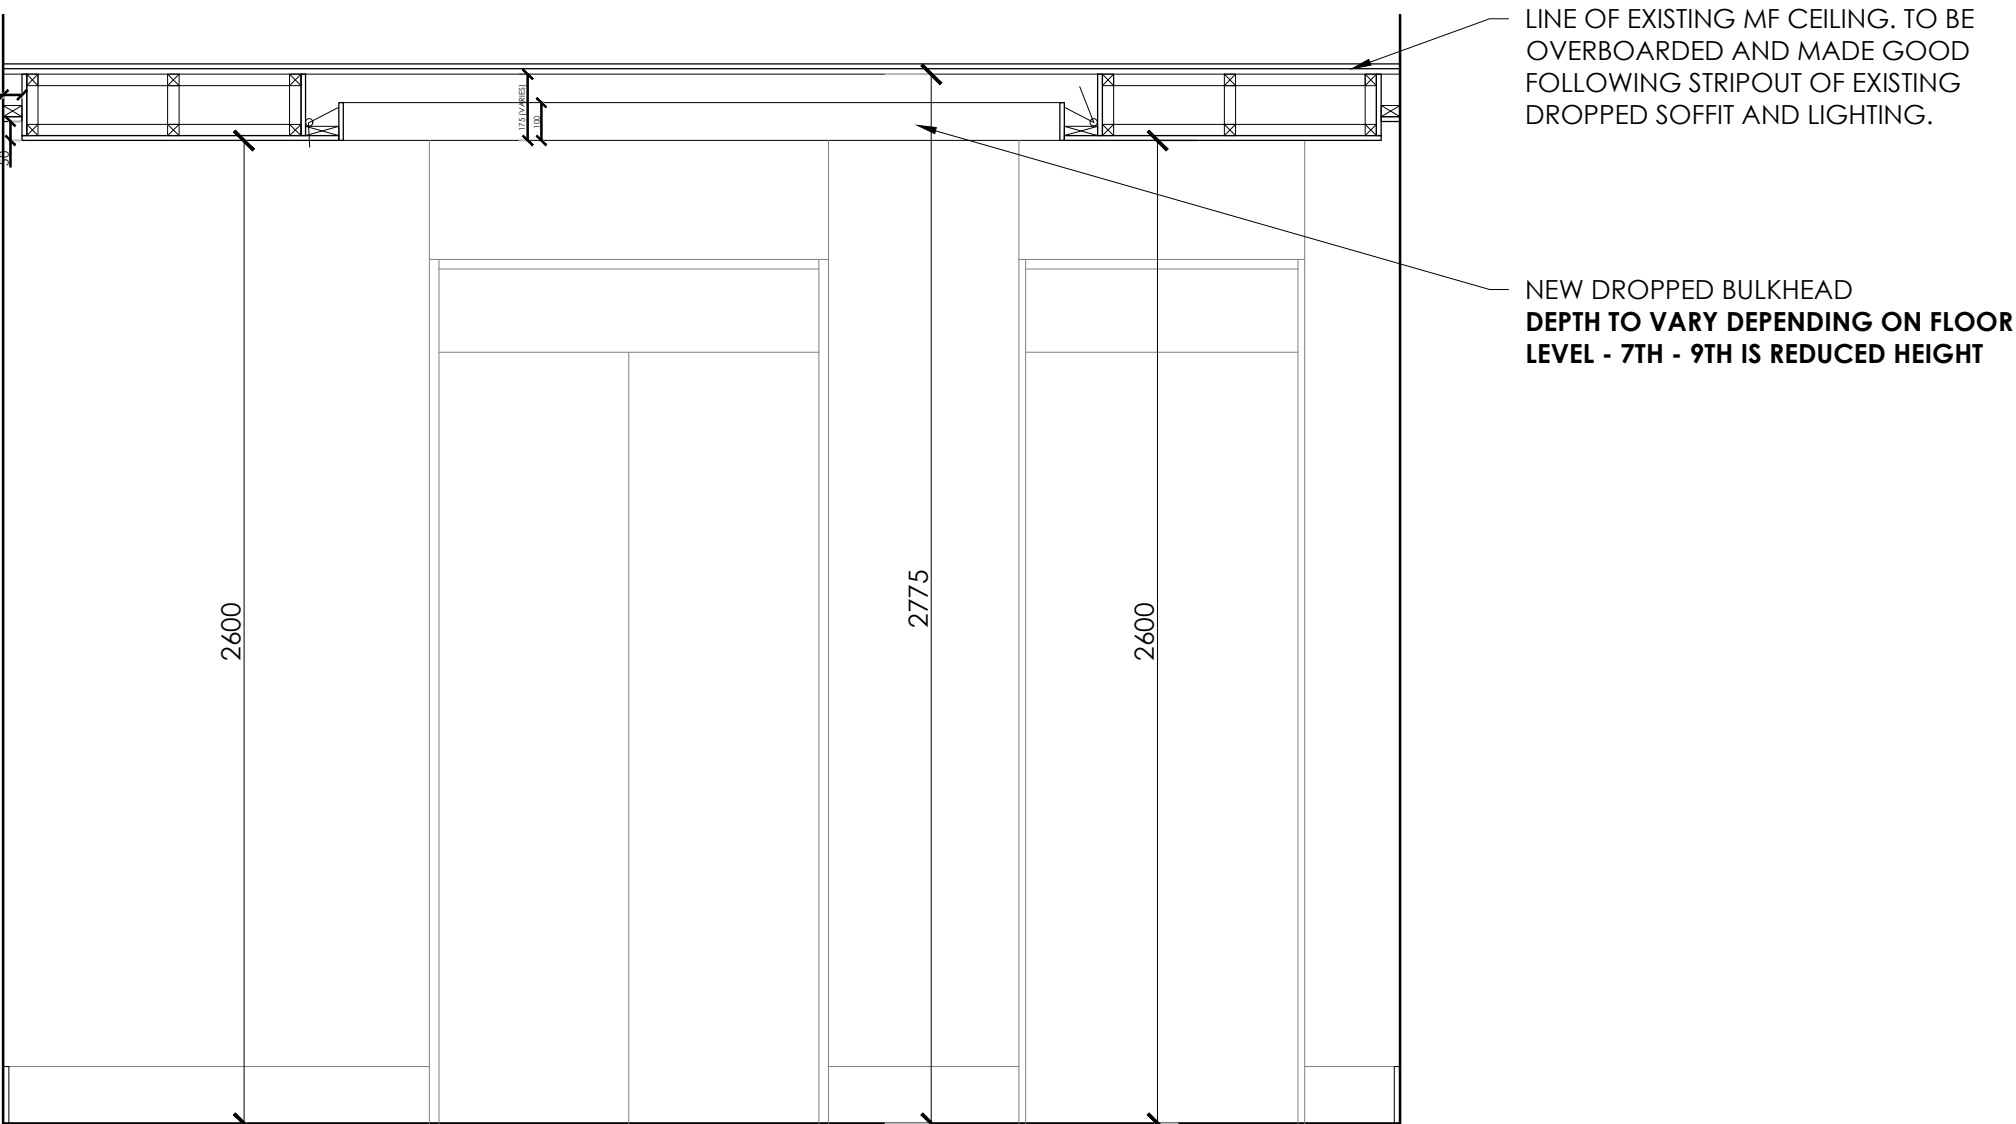


SECTION A-A - SCALE 1:20

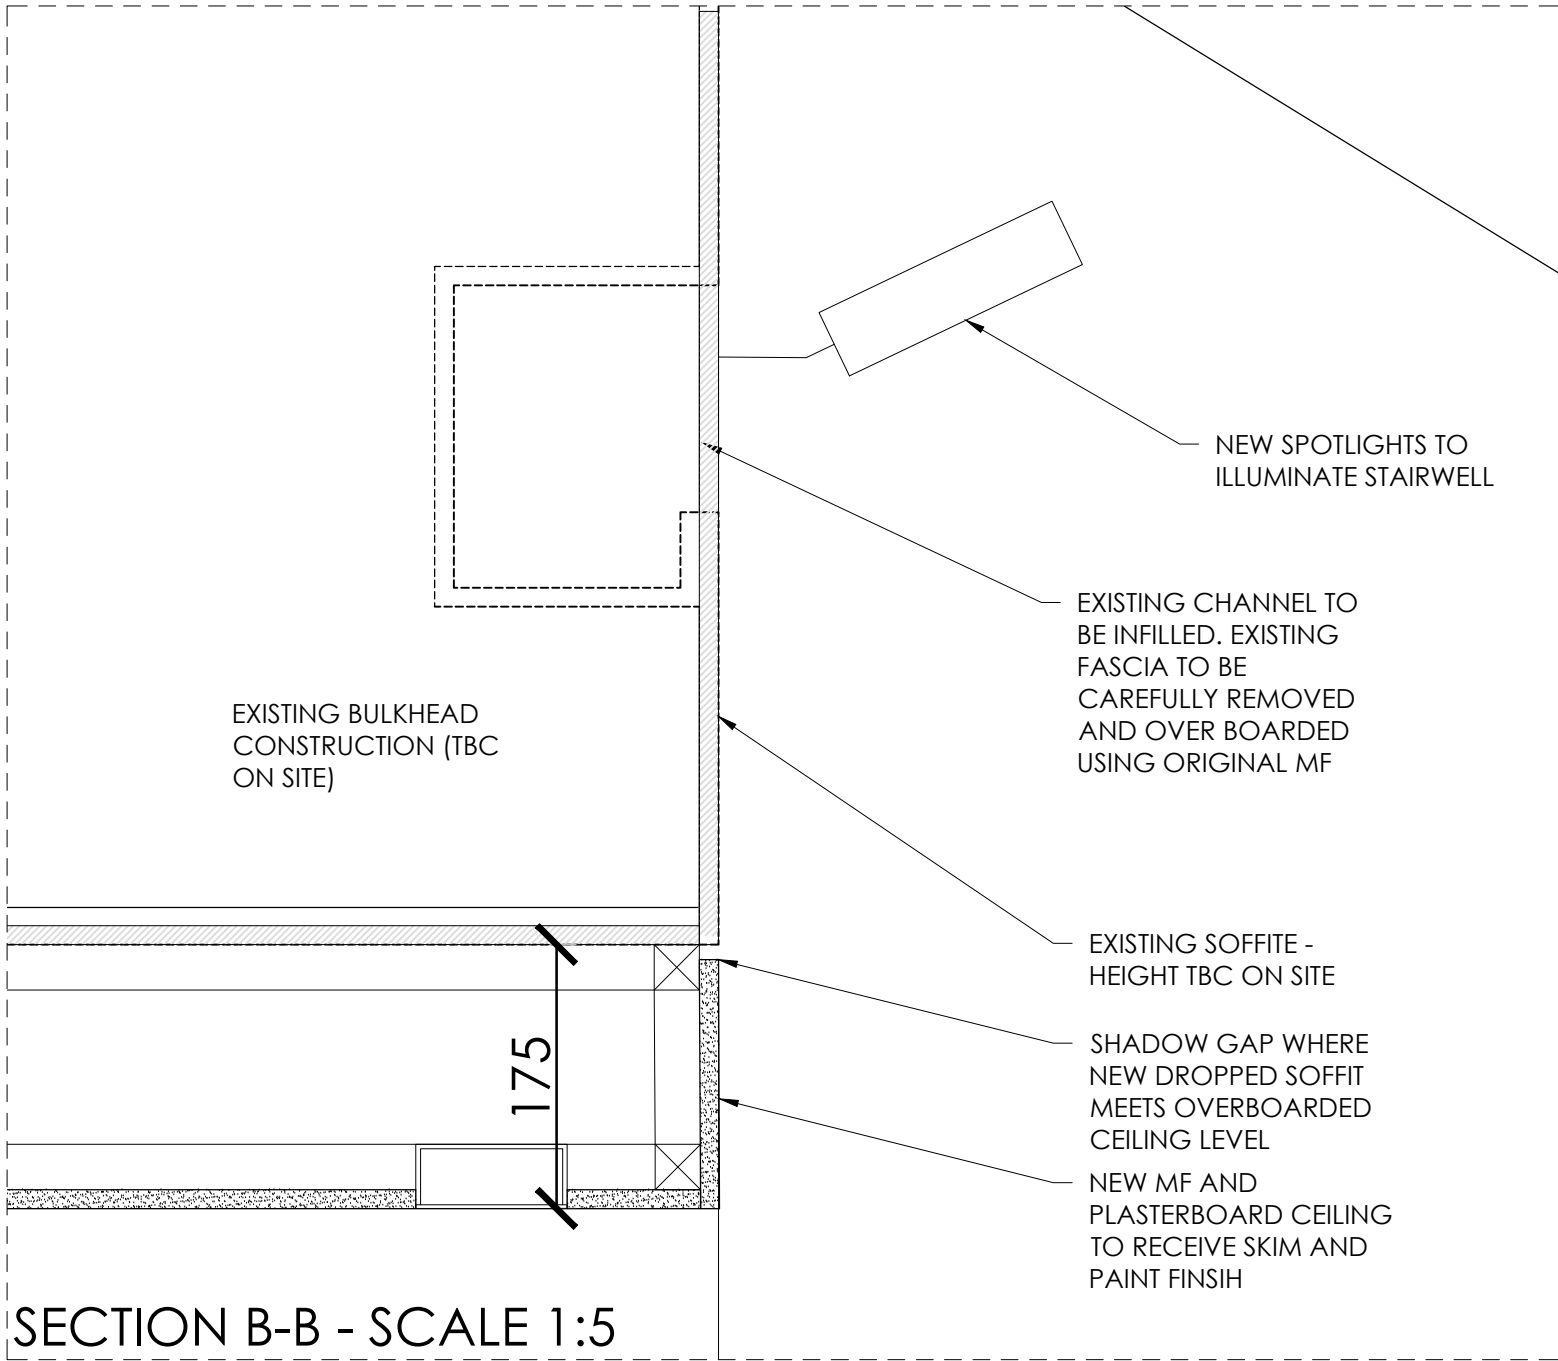


SECTION B-B - SCALE 1:5

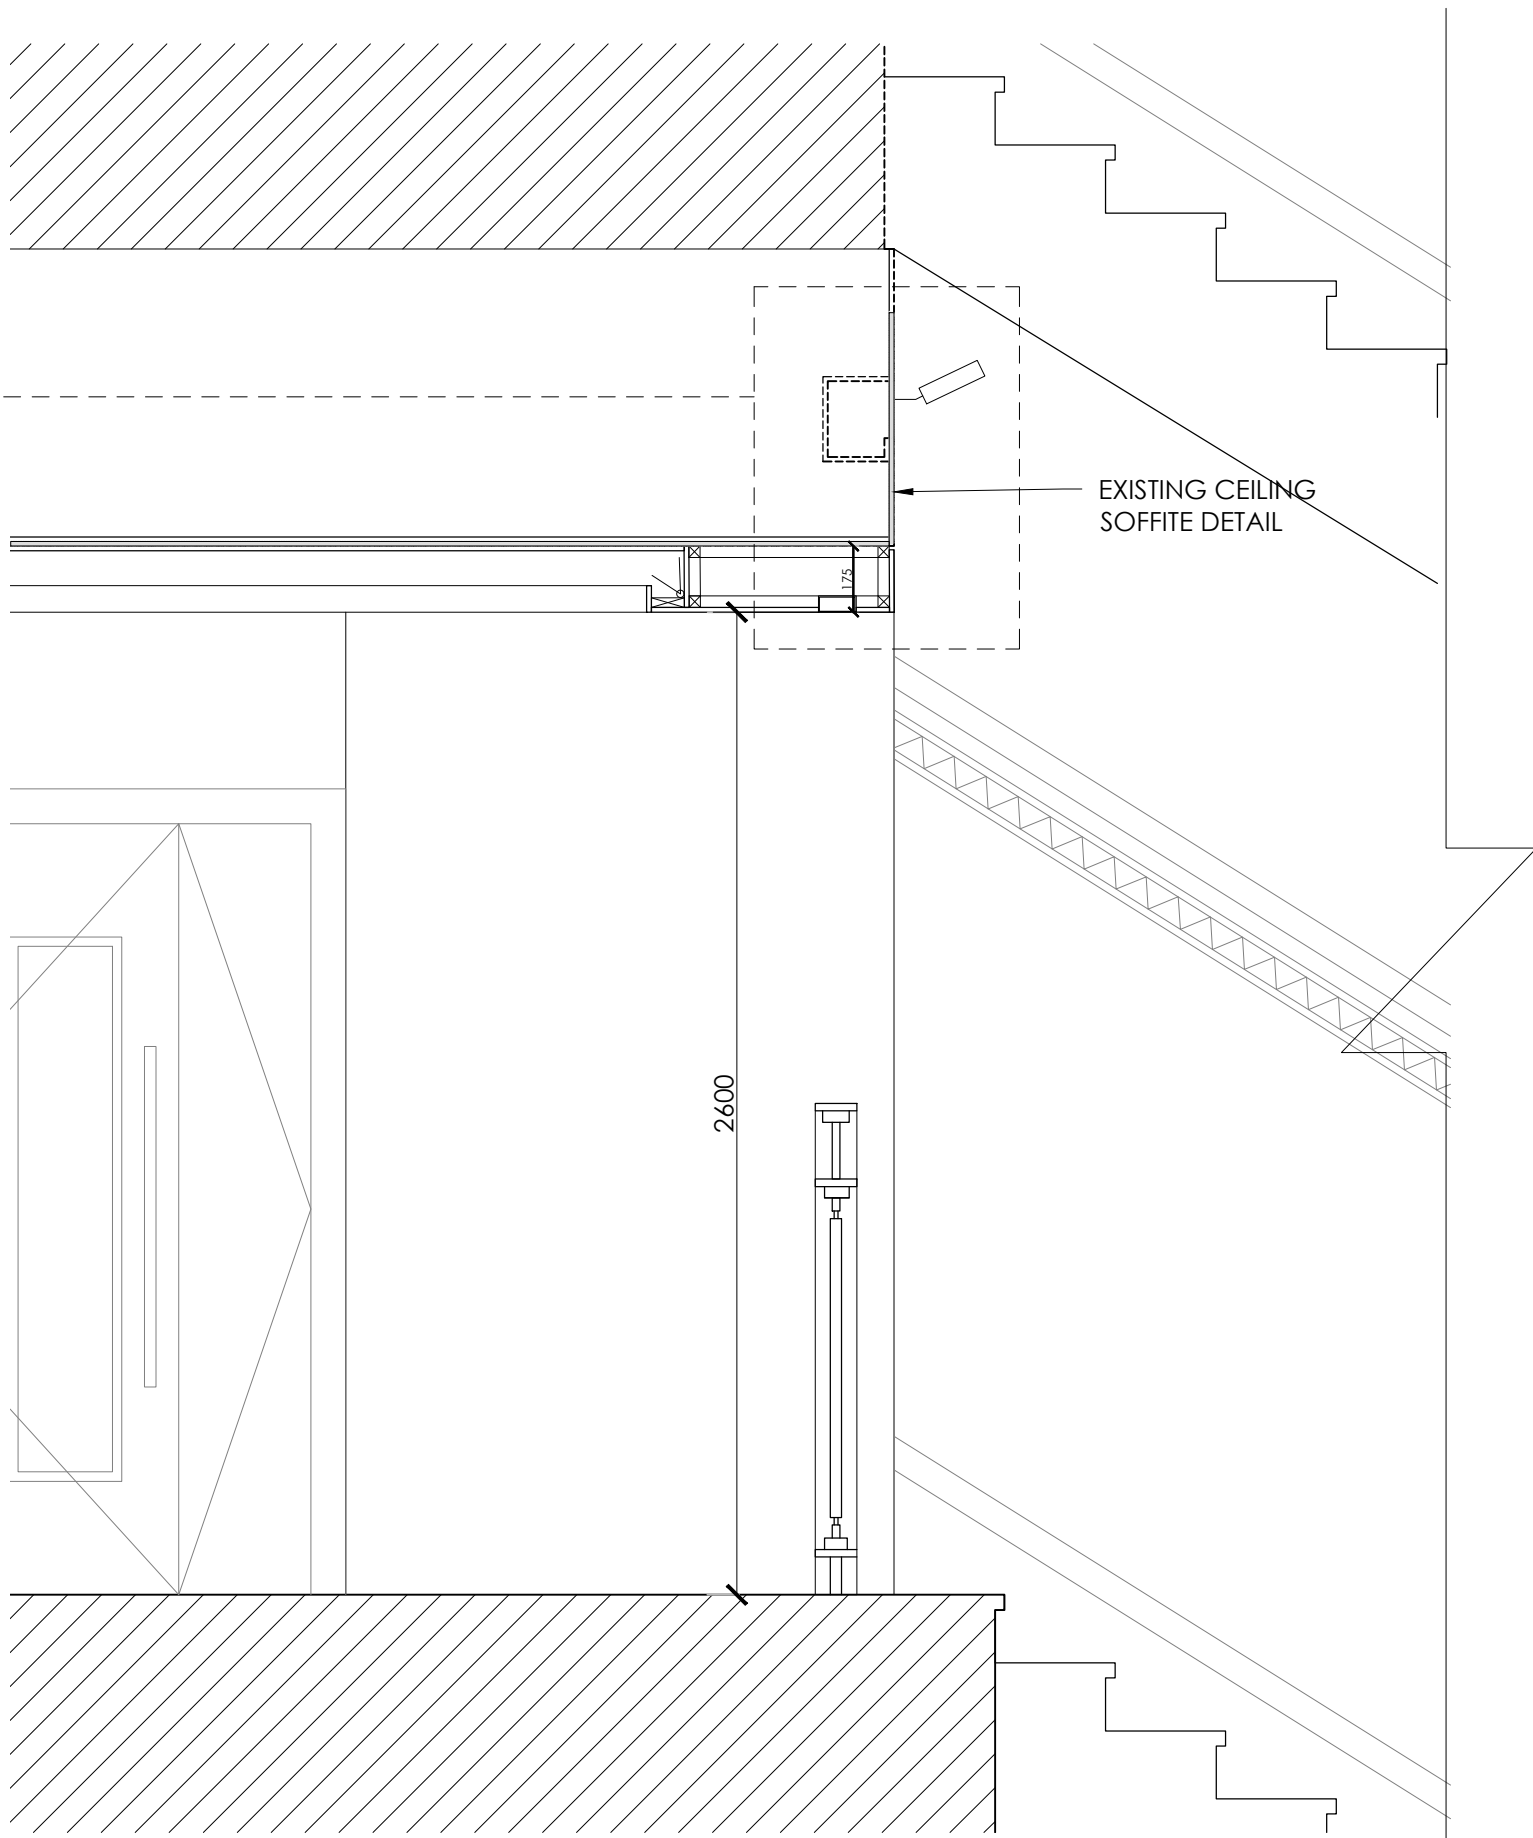

SECTION B-B - SCALE 1:20

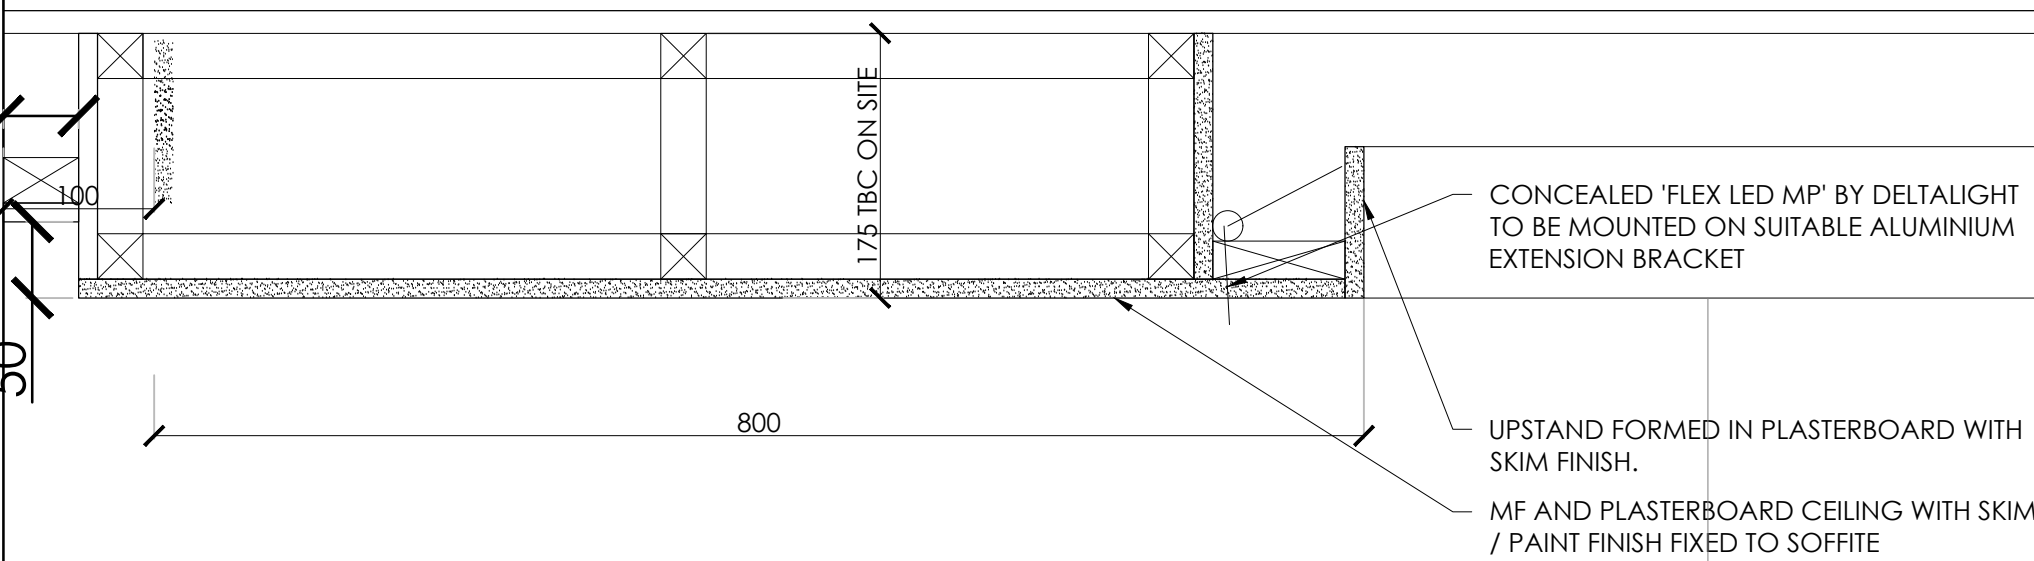


SECTION A-A - SCALE 1:5

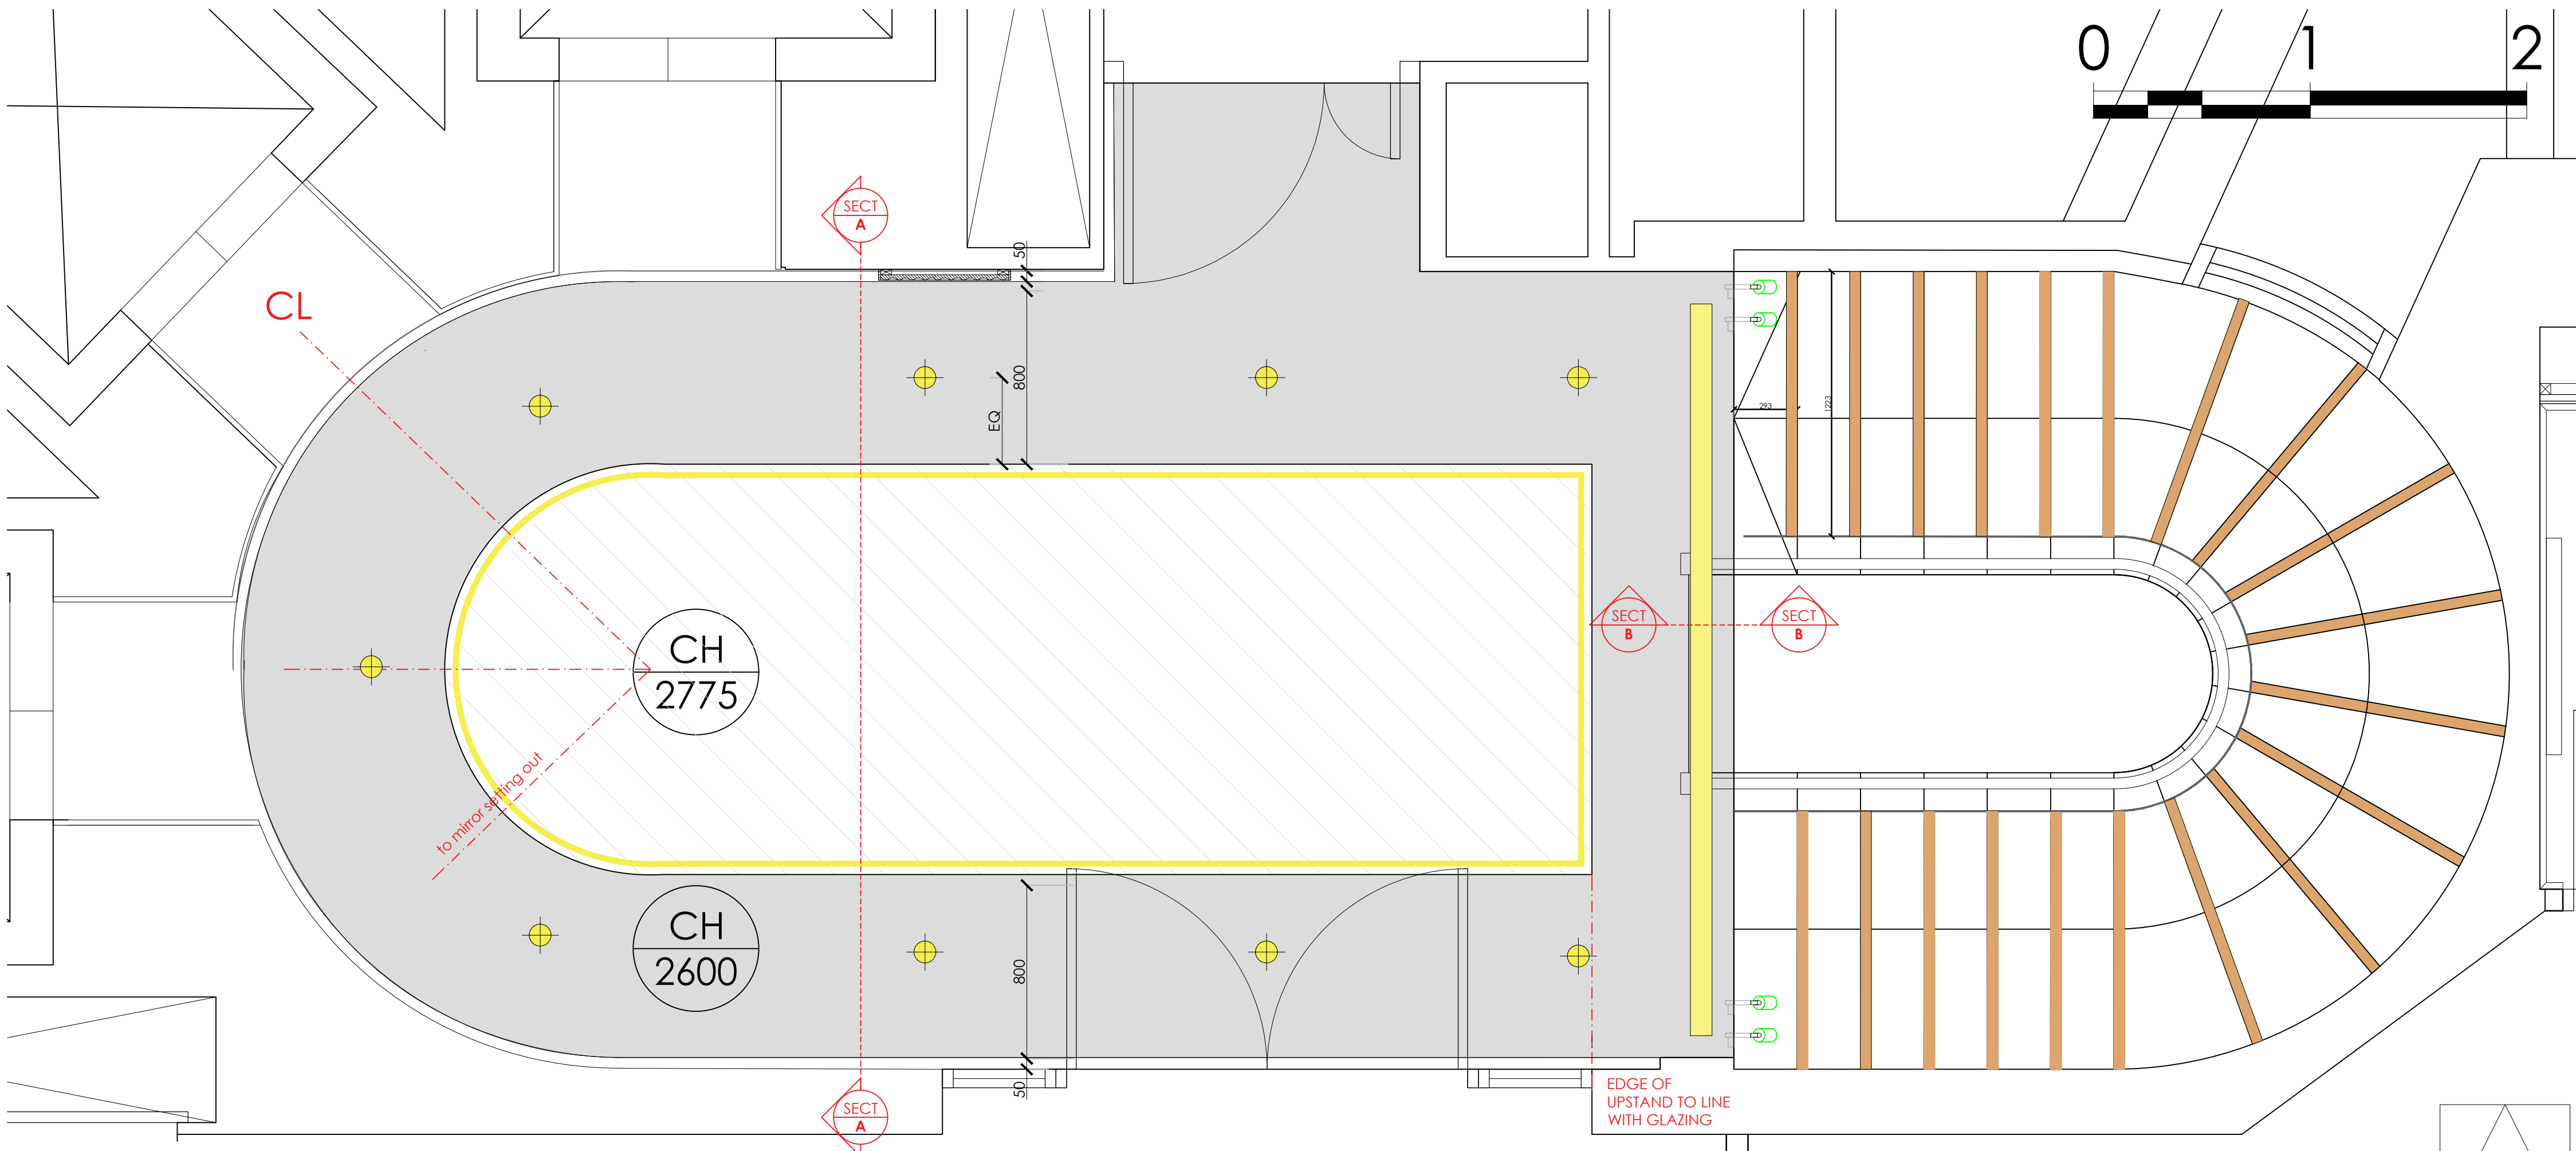

FEATURE CEILINGS KEY



FEATURE LIGHTING KEY

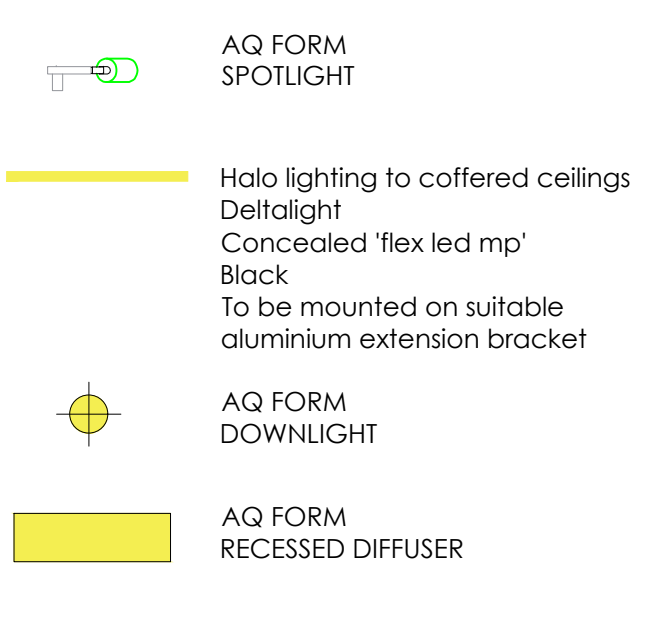

NOTES:
M&E LIGHTING CONSULTANT TO APPROVE ALL LIGHTING LEVELS AND POWER OUTPUTS.
FOR FULL M&E PROPOSALS, REFER TO M&E CONSULTANTS SPECIFICATION FOR ALL SERVICES RUNS, LIGHTING & ELECTRICAL LAYOUTS
THIS DRAWING SHOWS LIGHTING DESIGN INTENT ONLY FOR FEATURE LIGHTING
SETTING OUT TO BE COORDINATED WITH M&E CONSULTANT'S LAYOUT

NOTE: ALL DRAWING INFORMATION SUBJECT TO SITE SURVEY AND DRAWING UPDATES POST STRIP-OUT

Rev	Date	Description	Initials
D	06.04.23	UPDATES FROM CLIENT MEETING	PB
C	30.03.23	BULKHEAD / LIGHTING TO STAIRWELL UPDATED, FC	
B	16.12.22	BULKHEAD / LIGHTING TO STAIRWELL UPDATED, FC	
A	13.12.22	HERITAGE ISSUE	ST

Client:	GROSVENOR
Project:	SHIP CANAL HOUSE
Address:	SHIP CANAL HOUSE, KING STREET
Drawing Title:	TYPICAL LIFT LOBBY - CEILING + FEATURE LIGHTING LAYOUT
Date:	25.11.2022
Project Number:	1308
Scale:	1:20 / 1:5 @A1
Drawn by:	CEB
Drawing Number:	1308-0X-CL-01D