



✱ DOOR UNDERCUT

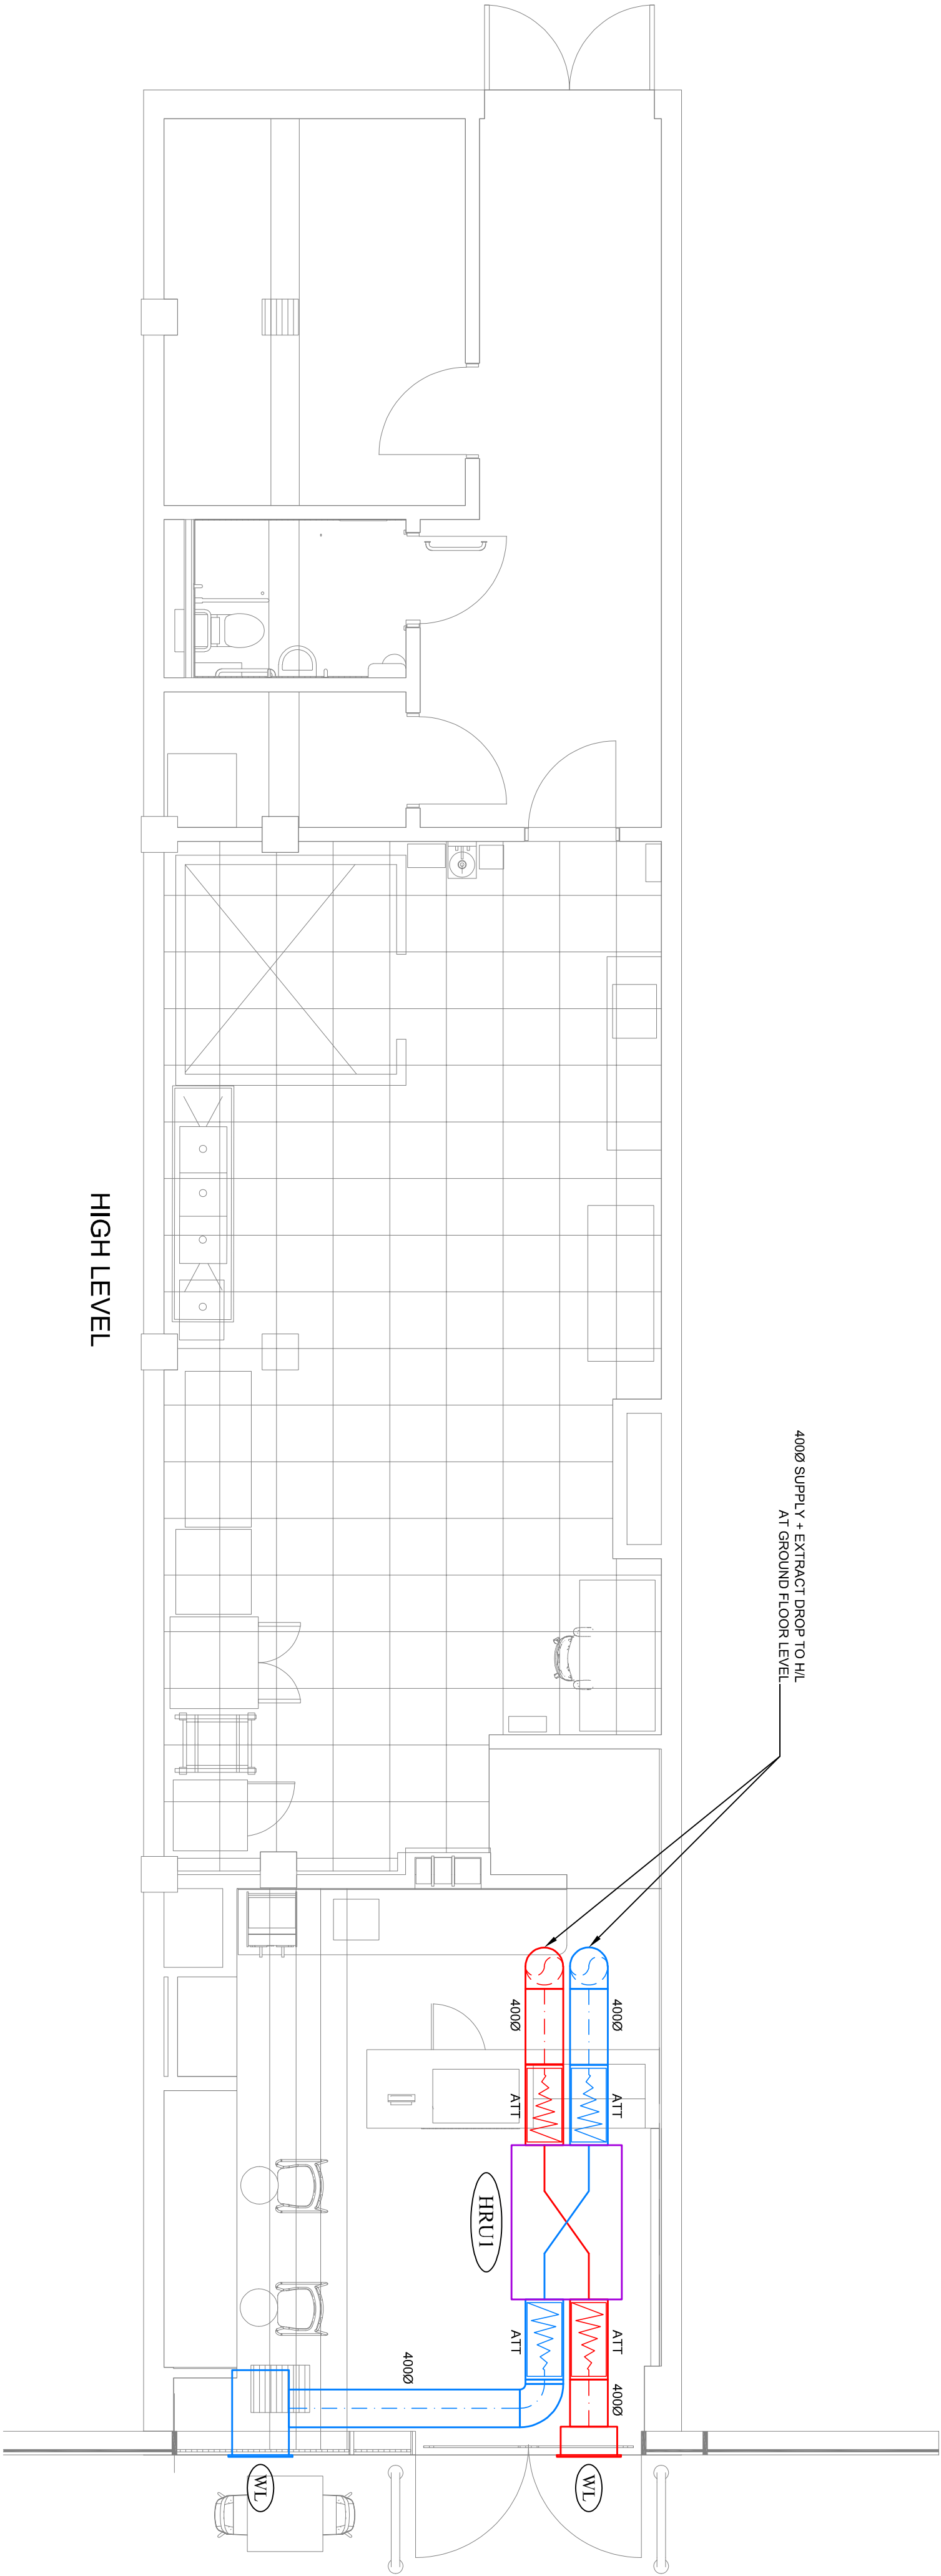


HIGH LEVEL

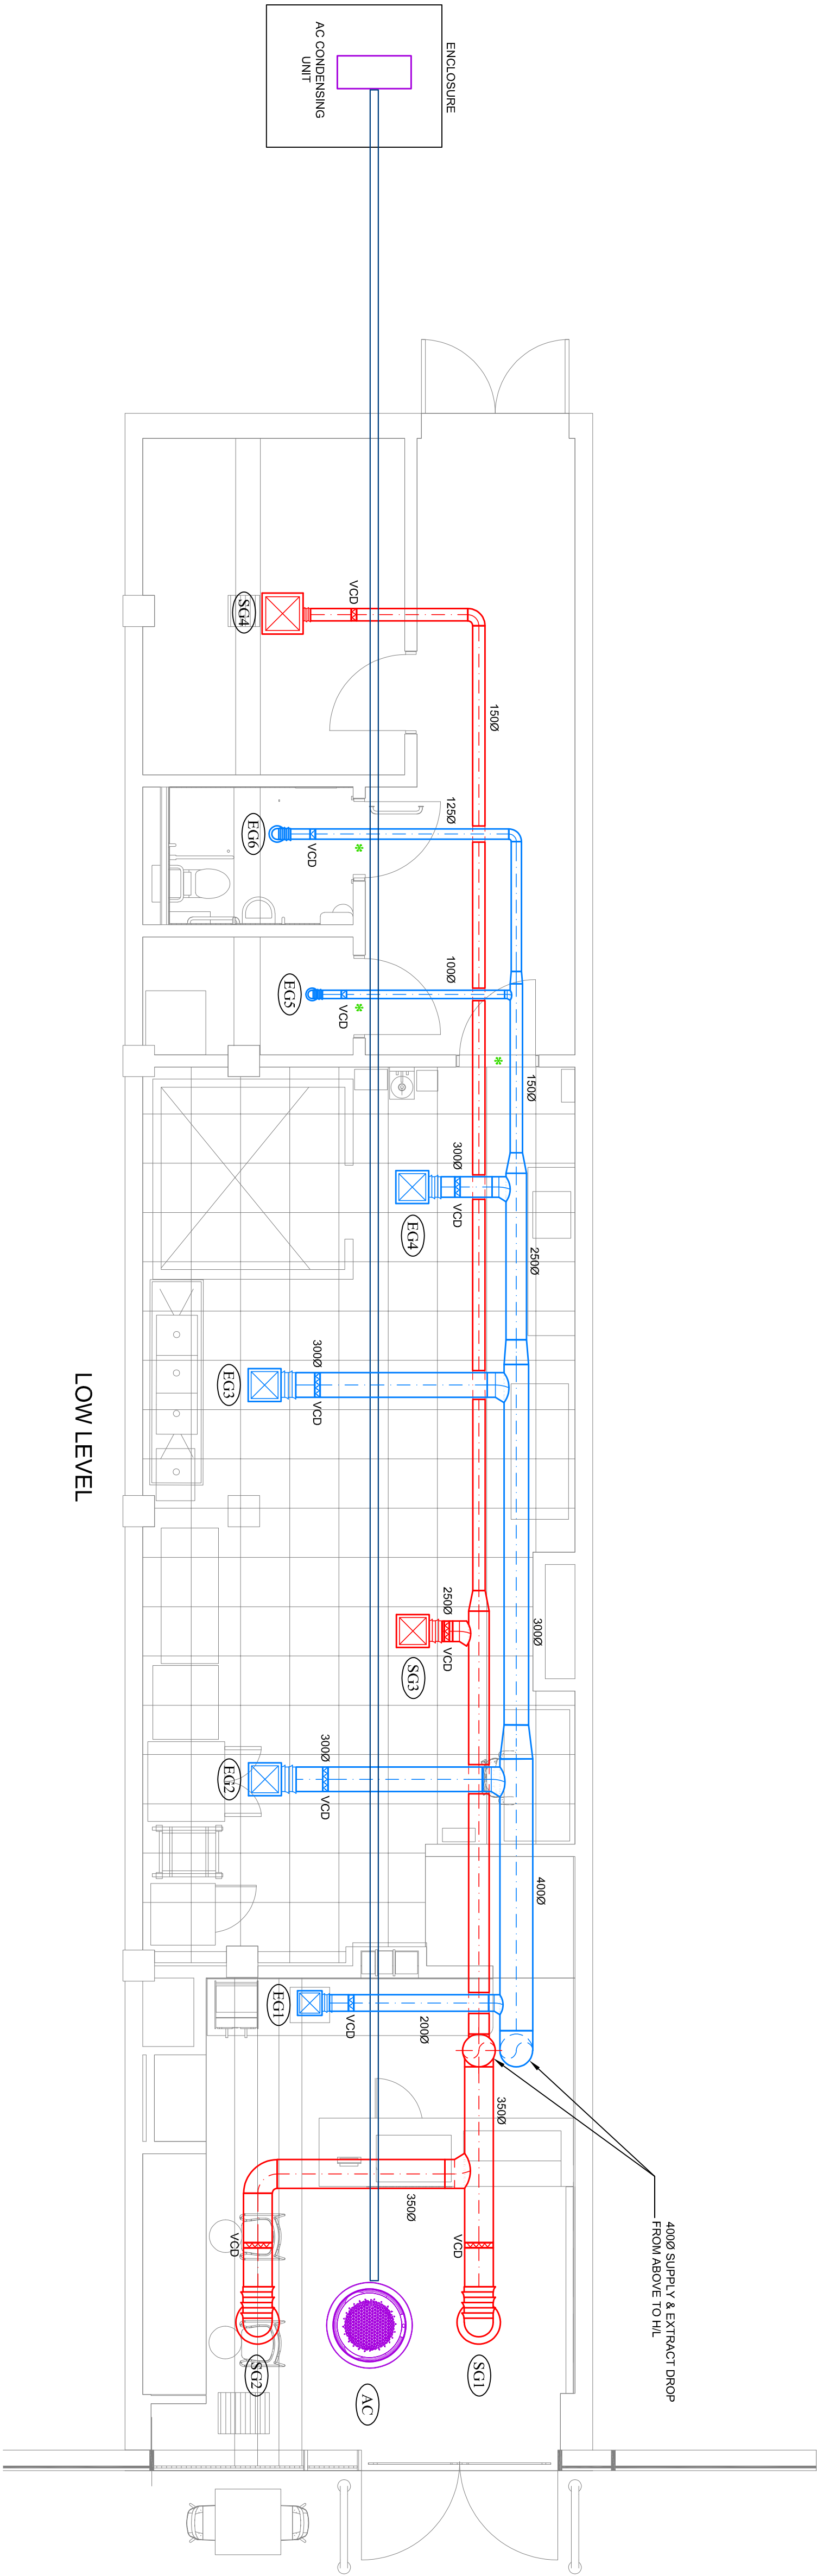

LOW LEVEL

For Approval

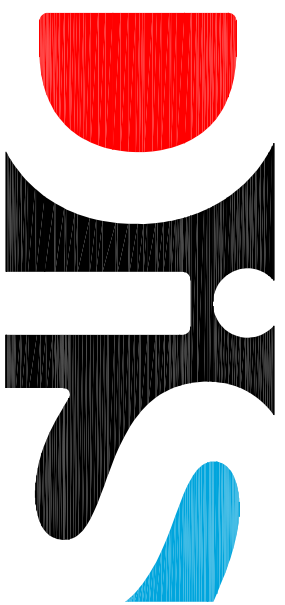

DESIGN INSTALLATION
SERVICE LIMITED

Unit 4, Manchester Park, Tewkesbury Road, Cheltenham, GL51 9EU
Tel: 01242 531120 Email: info@design.co.uk
Specialist in Design and Installation of Building Services

Project
Insomnia Cookies
University Green

Title
Ground Floor
Ventilation Layout

Scale	Drawn By	Engineer
1:50	Al Bell	T Coombs
Date	CAD File Ref	Checked
28-09-22		
Drawing Number	Revision	
M/22/05/01	B	