


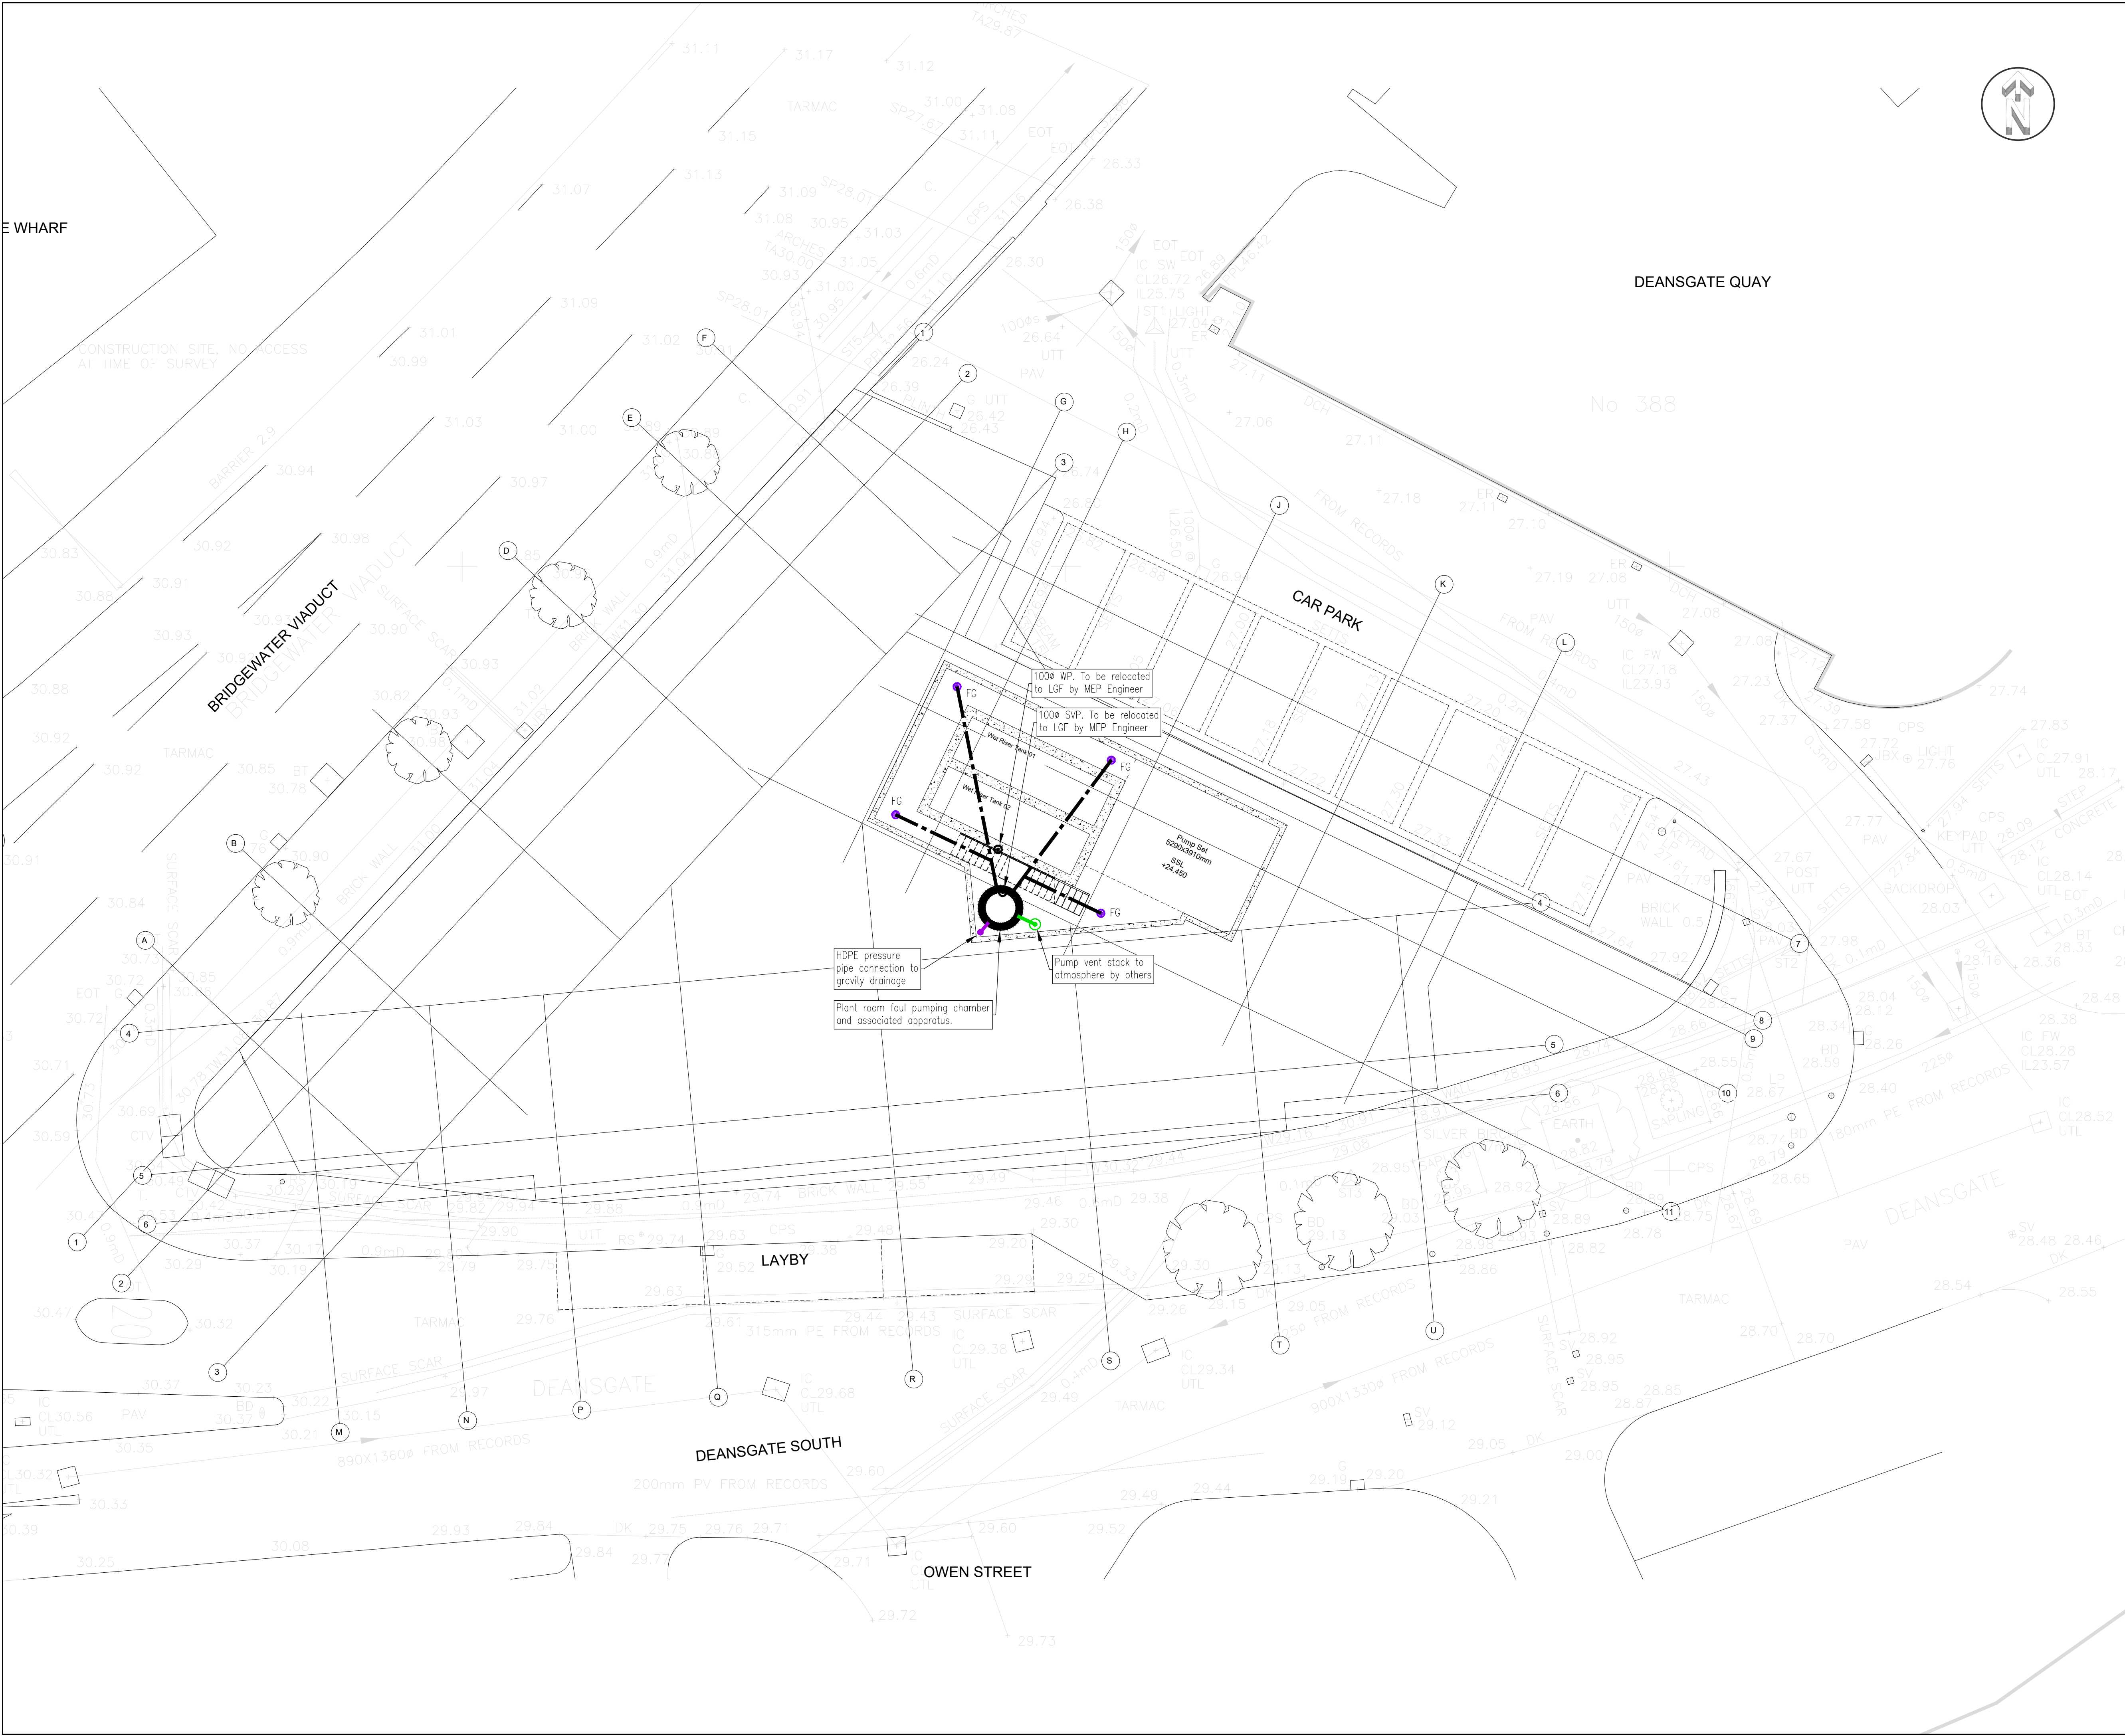

NOTES

- GENERAL**
1. ALL DIMENSIONS ARE IN MILLIMETRES UNLESS NOTED OTHERWISE.
 2. ALL LEVELS ARE IN METRES UNLESS NOTED OTHERWISE.
 3. DO NOT SCALE FROM THIS DRAWING. USE FIGURED DIMENSIONS ONLY.
 4. ANY DISCREPANCIES TO BE REPORTED IMMEDIATELY TO THE ENGINEER.
 5. THIS DRAWING IS TO BE READ IN CONJUNCTION WITH ALL RELEVANT ARCHITECTS, SUBCONTRACTORS AND SPECIALISTS DRAWINGS AND SPECIFICATIONS.
 6. THIS DRAWING IS COPYRIGHT © PROPERTY OF SHEAR DESIGN LIMITED.

For drawing key and notes
refer to drawing
20047-121 Lower ground
floor drainage layout

Note
Locations of all manhole
covers in ground floor to
be coordinated with interior
designer.

RIBA STAGE 4

REV	DATE	DESCRIPTION	BY	CHK
AMENDMENTS				
CLIENT: FUSION MANCHESTER DEVCO LTD				
PROJECT: STUDENT ACCOMMODATION DEANSGATE SOUTH, MANCHESTER				
TITLE: DRAINAGE LAYOUT BASEMENT				
 Consulting Civil and Structural Engineers 7 Ashtree Court - Woody Close - Cardiff Gate Business Park - Cardiff - CF23 8RW Tel: 029 2054 7000 - Fax: 029 2054 7001 - www.shear-design.com - enquiries@shear-design.com				
DRAWN: TU	CHECKED: DK	DATE: JUNE 2023	SCALE: 1:100 @ A1	
SHEAR DESIGN REF: 20047	DRAWING NUMBER: 20047-123	REVISION: - STATUS: T		