


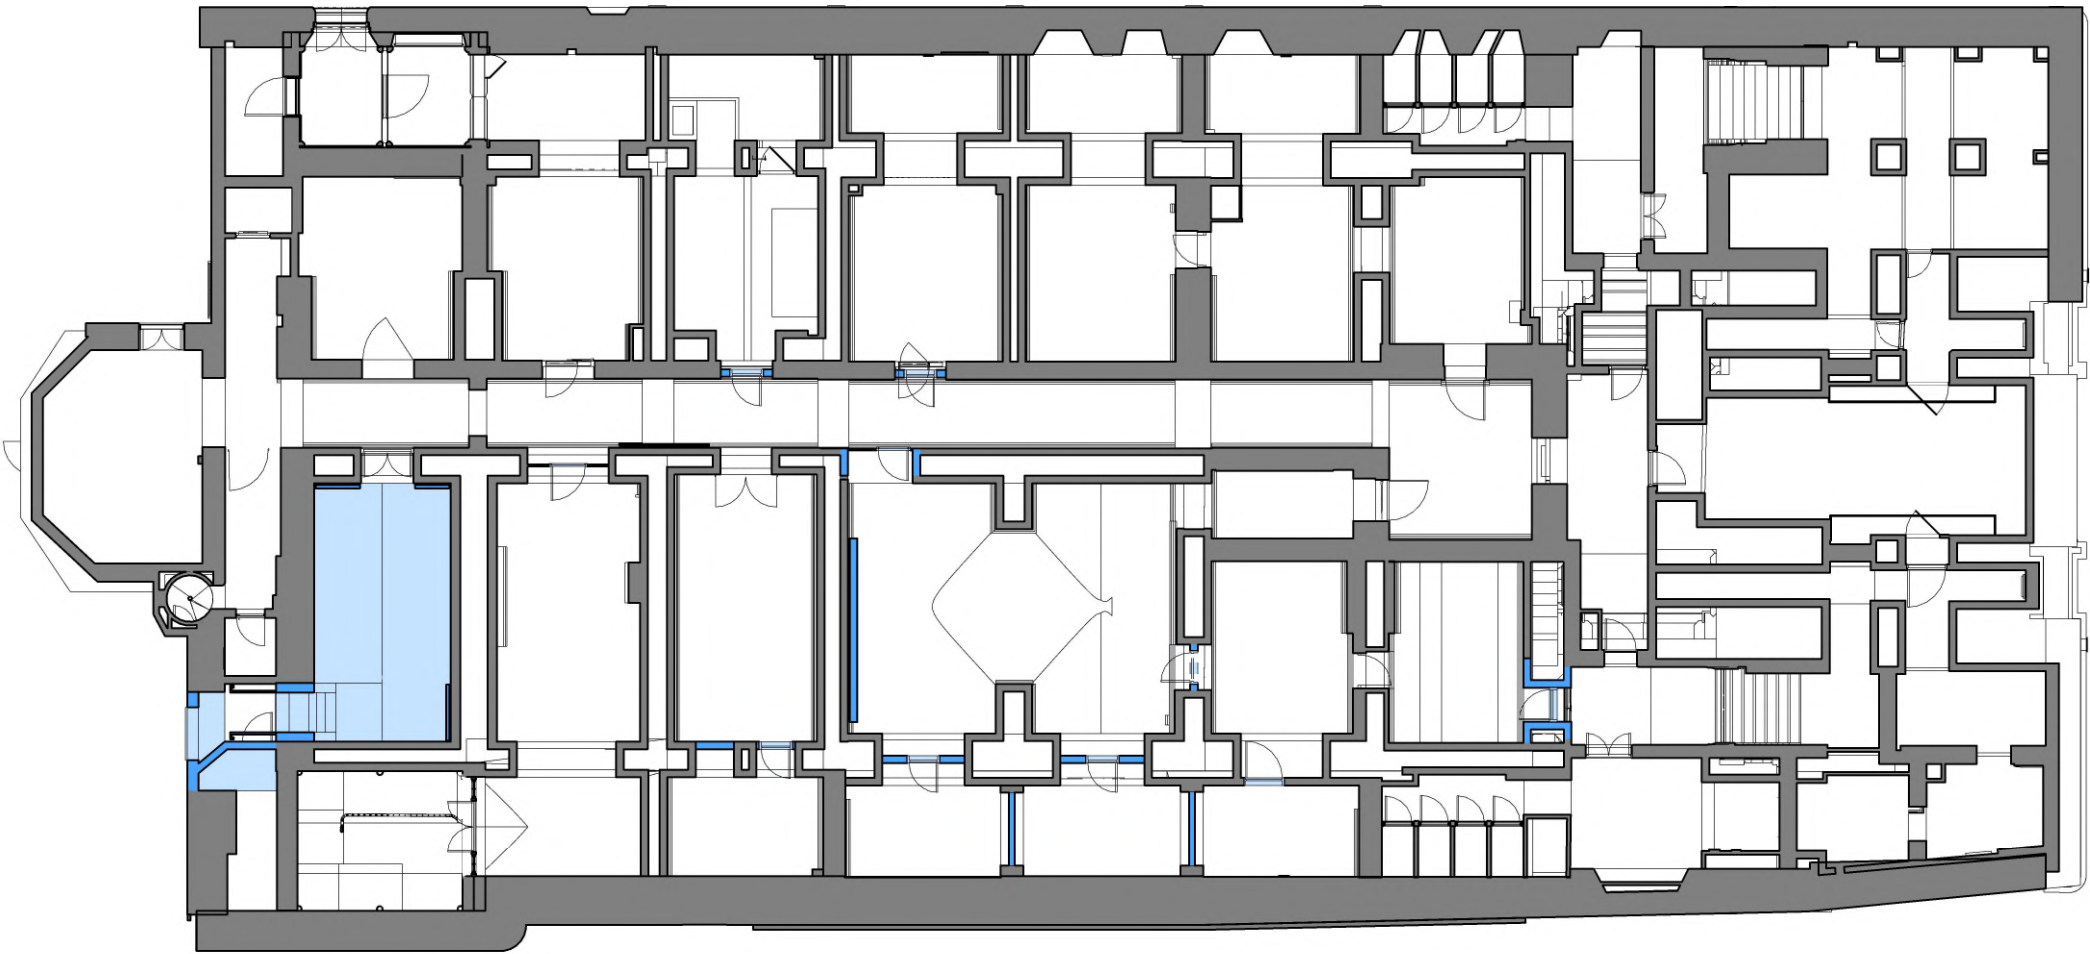

Cellar Reflected Ceiling Plan as Proposed
Scale 1 : 100

Information Note

Any drawing format is to be read in conjunction with and at the scale of accompanying documents.

Where colours other than black or grey are used the drawing must be plotted in colour.

All dimensions are to be checked on site by the Contractor, scaling is for Local Authority purposes only.

Unless otherwise indicated, all dimensions are in millimeters.

All information on this drawing is to be read in conjunction with the relevant Donald Insall Associates (Insall) specification and trade contractors' drawings and information by specialists.

In the event of any discrepancy, please contact Insall immediately.

This drawing may contain survey information by others and is to be used solely for the purposes for which it was issued.

These are uncontrolled documents issued for information purposes only. If you have any queries regarding the drawings, contact Insall immediately.

Insall cannot be held responsible for any errors arising from changes made to an uncontrolled file.

Drawings by Donald Insall Associates to be read in conjunction with full 'Next Chapter' drawing sets, including those by Structural Engineer, MEP Engineer, Exhibition Designer, Fire Consultant and Acoustic Consultant.

P3	27.06.23	JXW	RXC	Planning Permission and LBC Application		
P2	09.05.23	JXW	RXC	For Costing		
P1	13.04.23	JXW	RXC	Initial Issue		
Rev.	Date	Dim.	Auth.	Description		
Purpose of Issue						
Planning Permission and LBC Application						
Project Information						
The John Rylands Research Institute and Library Manchester, 'Next Chapter' Project						
Drawing Title						
Cellar Reflected Ceiling Plan as Proposed						
Drawing Number						
Project ID	Originator	Functional Breakdown	Spatial Breakdown	Form	Discipline	Number
JRL - DIA - ZZ - 01B - D60- ACL - 4200						
Project Number		Scale at A1		Status	Revision	
MAN.JRL.03		As indicated		S3	P3	

Donald Insall Associates

Chartered Architects and Historic Building Consultants

Ducie House, 37 Ducie Street, Manchester M1 2JW
(+44) 0161 359 4326
Manchester@insall-architects.co.uk

© 2023 DONALD INSALL ASSOCIATES LTD



Information Note

Any drawing format is to be read in conjunction with and at the scale of accompanying documents.

Where colours other than black or grey are used the drawing must be plotted in colour.

All dimensions are to be checked on site by the Contractor, scaling is for Local Authority purposes only.

Unless otherwise indicated, all dimensions are in millimeters.

All information on this drawing is to be read in conjunction with the relevant Donald Insall Associates (Insall) specification and trade contractors' drawings and information by specialists.


In the event of any discrepancy, please contact Insall immediately.

This drawing may contain survey information by others and is to be used solely for the purposes for which it was issued.

These are uncontrolled documents issued for information purposes only. If you have any queries regarding the drawings, contact Insall immediately.

Insall cannot be held responsible for any errors arising from changes made to an uncontrolled file.

Drawings by Donald Insall Associates to be read in conjunction with full 'Next Chapter' drawing sets, including those by Structural Engineer, MEP Engineer, Exhibition Designer, Fire Consultant and Acoustic Consultant.

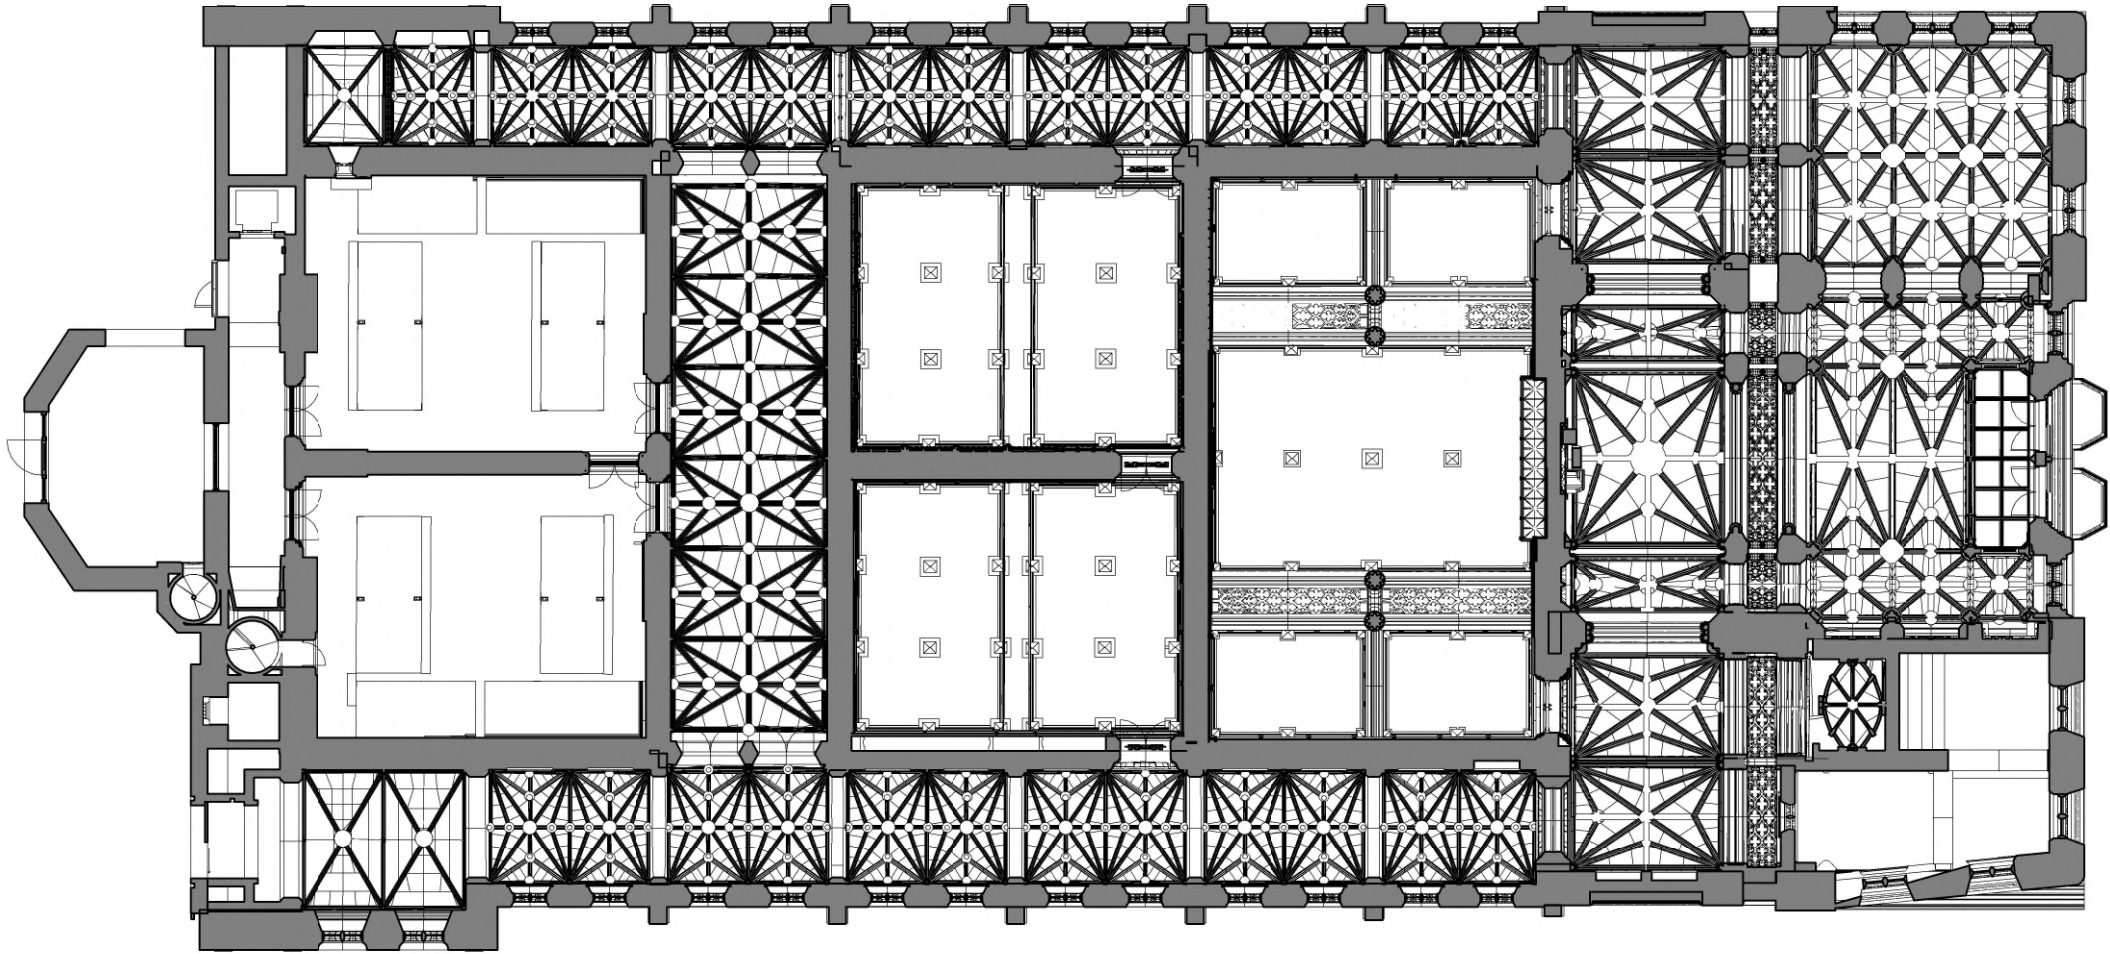

Historic Entrance and First Floor Reflected Ceiling Plan as Proposed
Scale 1 : 100

P3	27.06.23	JXW	RXC	Planning Permission and LBC Application		
P2	09.05.23	JXW	RXC	For Costing		
P1	13.04.23	JXW	RXC	Initial Issue		
Rev.	Date	Dim.	Auth.	Description		
Purpose of Issue						
Planning Permission and LBC Application						
Project Information						
The John Rylands						
Research Institute and Library						
Manchester, 'Next Chapter' Project						
Drawing Title						
Historic Entrance and First Floor Reflected Ceiling Plan as Proposed						
Drawing Number						
Project ID	Originator	Functional Breakdown	Spatial Breakdown	Form	Discipline	Number
JRL - DIA - ZZ - 20B -D60- ACL - 4201						
Project Number		Scale at A1		Status	Revision	
MAN.JRL.03		As indicated		S3	P3	
Donald Insall Associates						
Chartered Architects and Historic Building Consultants						
Ducie House, 37 Ducie Street, Manchester M1 2JW						
(+44) 0161 359 4326						
Manchester@insall-architects.co.uk						
© 2023 DONALD INSALL ASSOCIATES LTD						



Information Note

Any drawing format is to be read in conjunction with and at the scale of accompanying documents.

Where colours other than black or grey are used the drawing must be plotted in colour.

All dimensions are to be checked on site by the Contractor, scaling is for Local Authority purposes only.

Unless otherwise indicated, all dimensions are in millimeters.


All information on this drawing is to be read in conjunction with the relevant Donald Insall Associates (Insall) specification and trade contractors' drawings and information by specialists.

In the event of any discrepancy, please contact Insall immediately.

This drawing may contain survey information by others and is to be used solely for the purposes for which it was issued.

These are uncontrolled documents issued for information purposes only. If you have any queries regarding the drawings, contact Insall immediately.


Insall cannot be held responsible for any errors arising from changes made to an uncontrolled file.

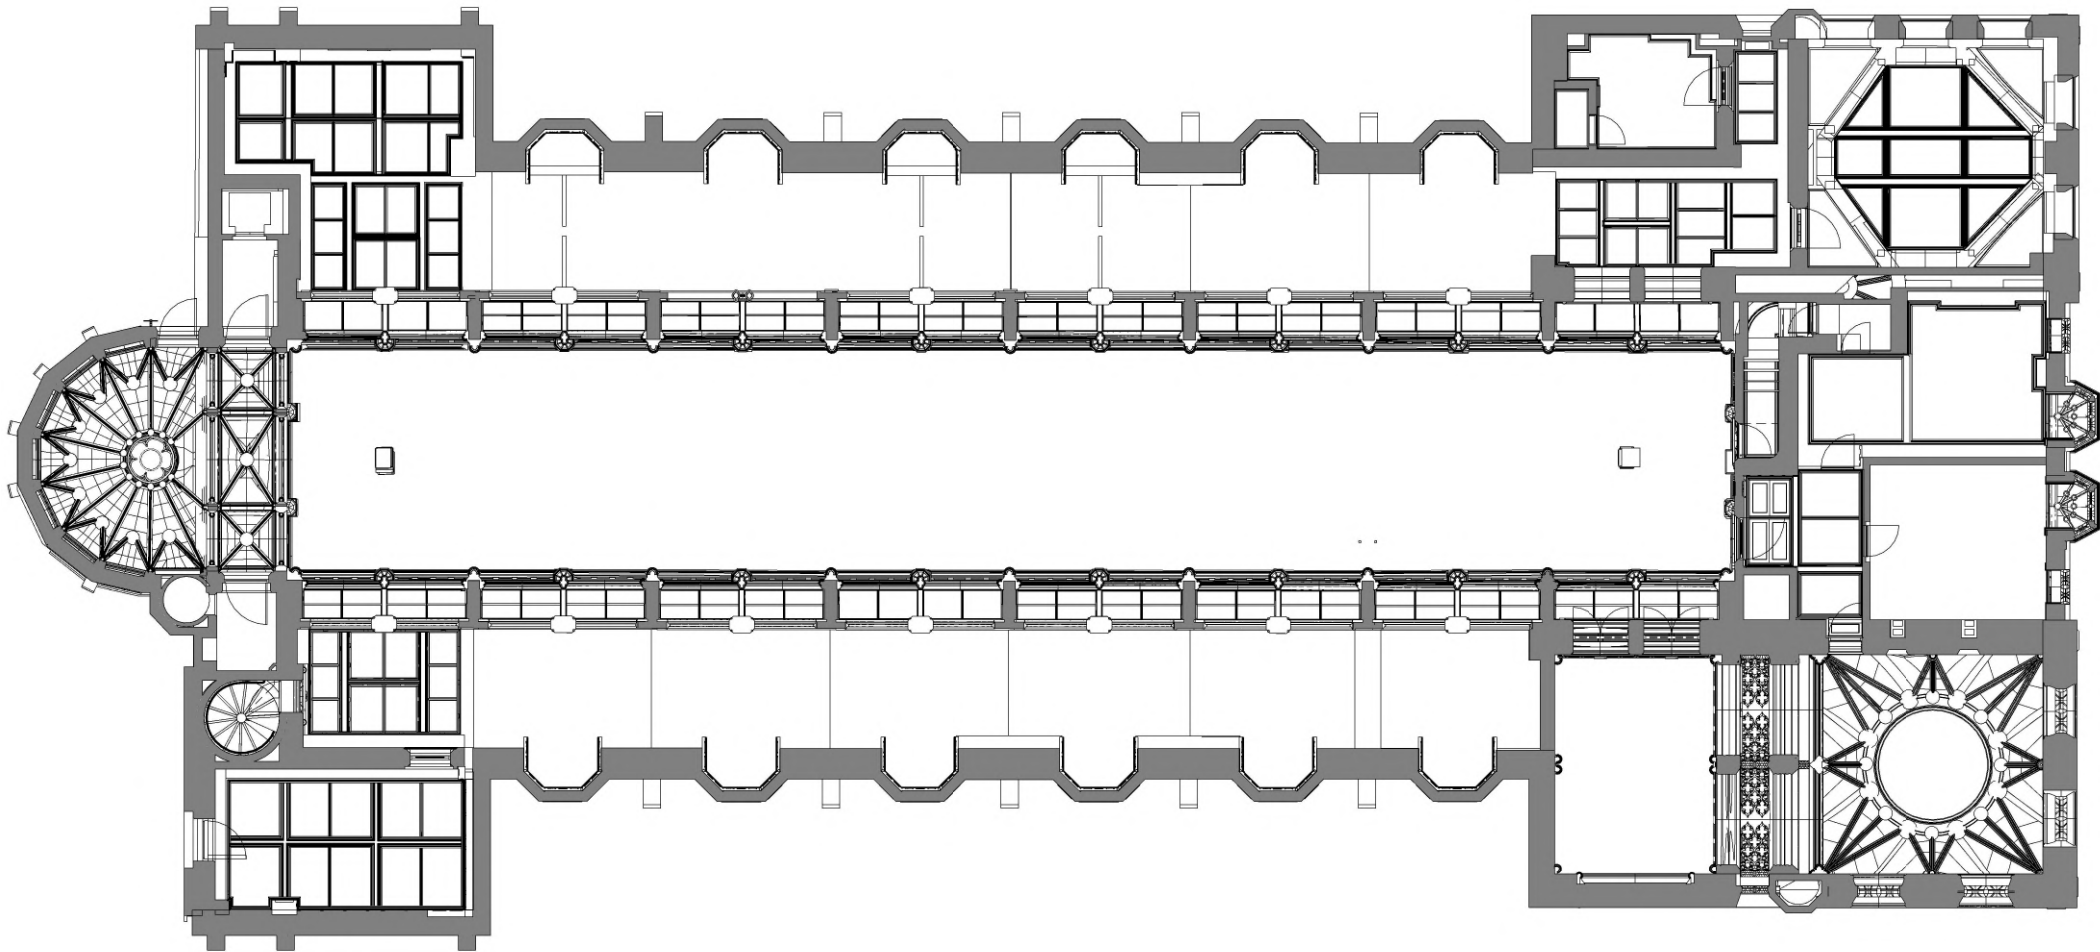

Reading Room Reflective Ceiling Plan as Proposed
SCALE : 100

P1	16.03.23	JXW	ELE	Initial Issue
Rev.	Date	Dim.	Auth.	Description
Purpose of Issue				
Review and Comment				
Project Information				
The John Rylands Research Institute and Library Manchester, 'Next Chapter' Project				
Drawing Title				
Reading Room - Reflected Ceiling as Proposed				
Drawing Number				
Project ID	Originator	Functional Breakdown	Spatial Breakdown	Form Discipline Number
JRL	- DIA -	ZZ	- 40B -D60-	ACL - 4203
Project Number		Scale at A1	Status	Revision
MAN.JRL.03		As indicated	S3	P1
Donald Insall Associates				
Chartered Architects and Historic Building Consultants				
Ducie House, 37 Ducie Street, Manchester M1 2JW (+44) 0161 359 4326 Manchester@insall-architects.co.uk				
© 2023 DONALD INSALL ASSOCIATES LTD				



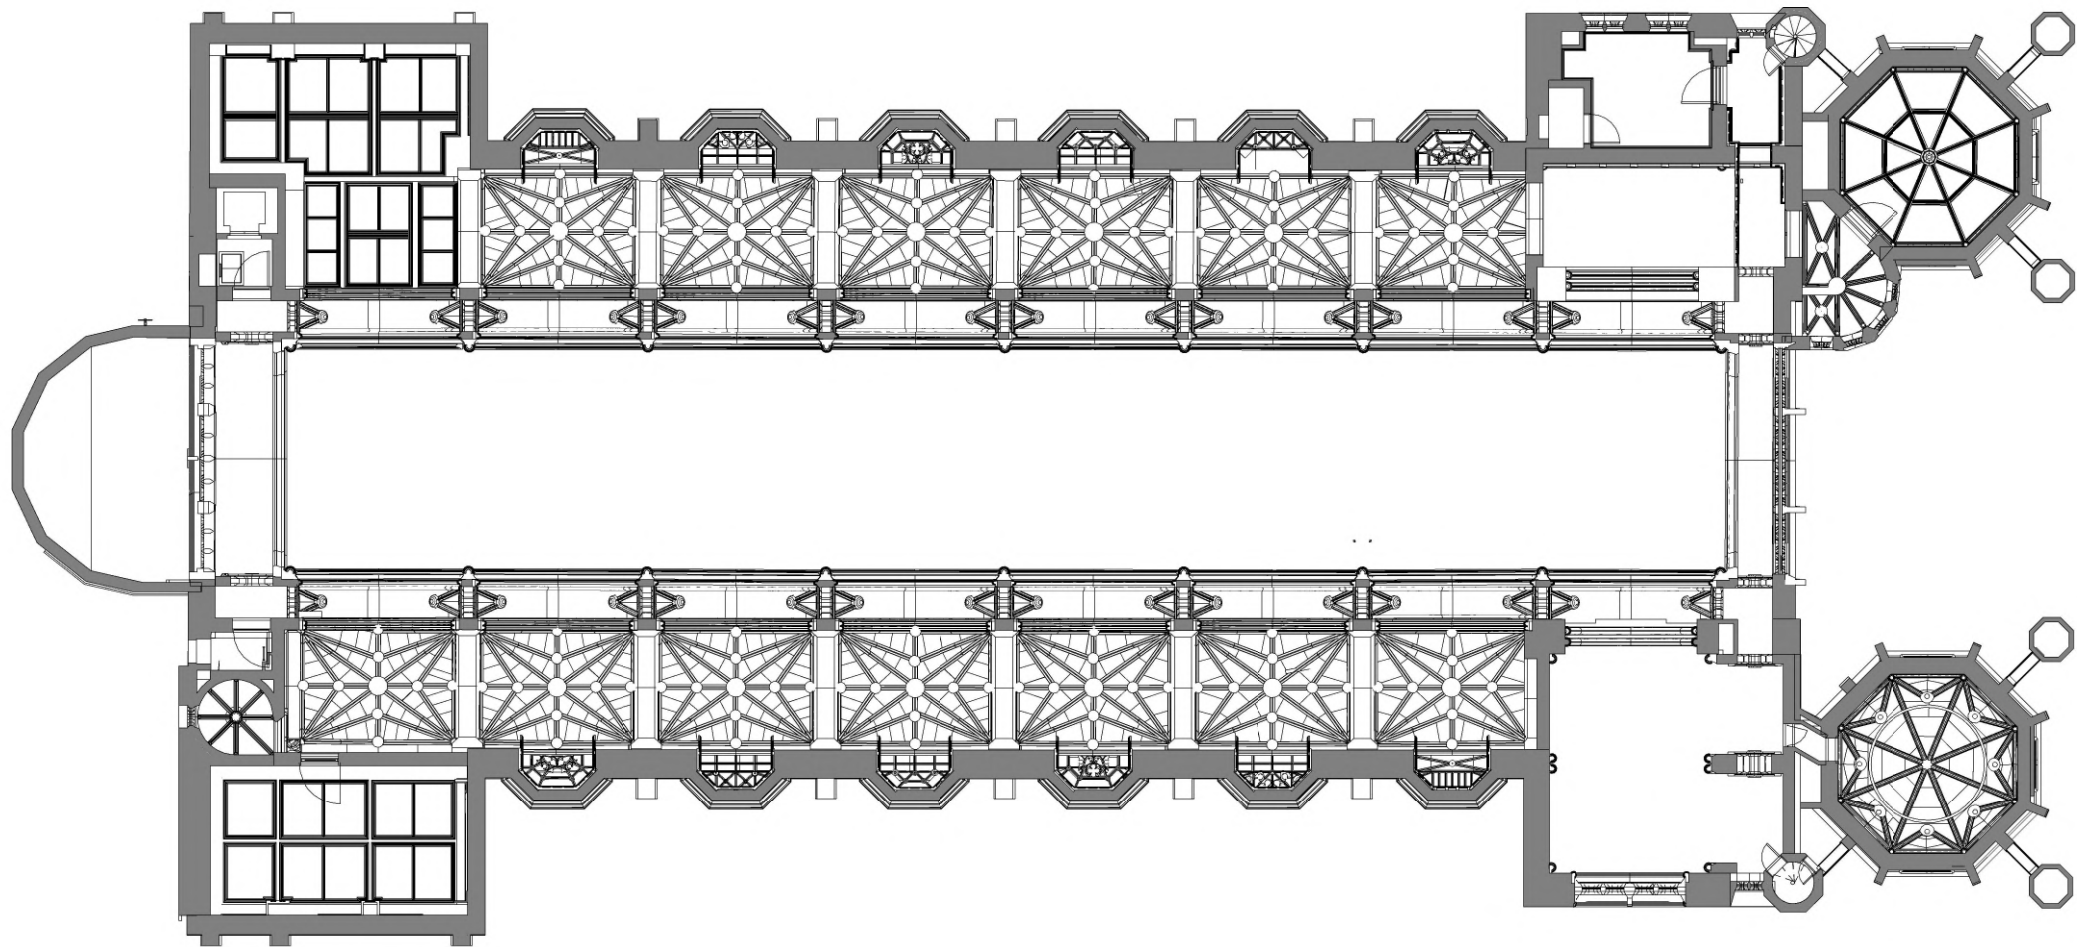

Reading Room Mezzanine Reflective Ceiling Plan as Proposed
SCALE : 100

Information Note

Any drawing format is to be read in conjunction with and at the scale of accompanying documents.

Where colours other than black or grey are used the drawing must be plotted in colour.

All dimensions are to be checked on site by the Contractor, scaling is for Local Authority purposes only.

Unless otherwise indicated, all dimensions are in millimeters.

All information on this drawing is to be read in conjunction with the relevant Donald Insall Associates (Insall) specification and trade contractors' drawings and information by specialists.

In the event of any discrepancy, please contact Insall immediately.

This drawing may contain survey information by others and is to be used solely for the purposes for which it was issued.

These are uncontrolled documents issued for information purposes only. If you have any queries regarding the drawings, contact Insall immediately.

Insall cannot be held responsible for any errors arising from changes made to an uncontrolled file.

P1	16.03.23	JXW	ELE	Initial Issue	
Rev.	Date	Dim.	Auth.	Description	
Purpose of Issue					
Review and Comment					
Project Information					
The John Rylands					
Research Institute and Library					
Manchester, 'Next Chapter' Project					
Drawing Title					
Reading Room Mezzanine - Reflected Ceiling as Proposed					
Drawing Number					
Project ID	Originator	Functional Breakdown	Spatial Breakdown	Form	Discipline Number
JRL	- DIA	- ZZ	- 50B	- D60-	ACL - 4204
Project Number		Scale at A1		Status	Revision
MAN.JRL.03		As indicated		S3	P1

Donald Insall Associates

Chartered Architects and Historic Building Consultants

Ducie House, 37 Ducie Street, Manchester M1 2JW
(+44) 0161 359 4326
Manchester@insall-architects.co.uk

© 2023 DONALD INSALL ASSOCIATES LTD





Basement Reflected Ceiling Plan as Proposed
Scale 1 : 100

Information Note

Any drawing format is to be read in conjunction with and at the scale of accompanying documents.

Where colours other than black or grey are used the drawing must be plotted in colour.

All dimensions are to be checked on site by the Contractor, scaling is for Local Authority purposes only.

Unless otherwise indicated, all dimensions are in millimeters.

All information on this drawing is to be read in conjunction with the relevant Donald Insall Associates (Insall) specification and trade contractors' drawings and information by specialists.

In the event of any discrepancy, please contact Insall immediately.

This drawing may contain survey information by others and is to be used solely for the purposes for which it was issued.

These are uncontrolled documents issued for information purposes only. If you have any queries regarding the drawings, contact Insall immediately.

Insall cannot be held responsible for any errors arising from changes made to an uncontrolled file.

Drawings by Donald Insall Associates to be read in conjunction with full 'Next Chapter' drawing sets. Including those by Structural Engineer, MEP Engineer, Exhibition Designer, Fire Consultant and Acoustic Consultant.

P3	27.06.23	JXW	RXC	Planning Permission and LBC Application		
P2	09.05.23	JXW	RXC	For Costing		
P1	16.03.23	JXW	ELE	Initial Issue		
Rev.	Date	Dim.	Auth.	Description		
Purpose of Issue						
Planning Permission and LBC Application						
Project Information						
The John Rylands						
Research Institute and Library						
Manchester, 'Next Chapter' Project						
Drawing Title						
Basement - Reflected Ceiling Plan as Proposed						
Drawing Number						
Project ID	Originator	Functional Breakdown	Spatial Breakdown	Form	Discipline	Number
JRL	- DIA	- ZZ	- 00A	- D60-	ACL	- 4250
Project Number		Scale at A1		Status	Revision	
MAN_JRL_03		As indicated		S3	P3	

Donald Insall Associates

Chartered Architects and Historic Building Consultants

Ducie House, 37 Ducie Street, Manchester M1 2JW
(+44) 0161 359 4326
Manchester@insall-architects.co.uk

© 2023 DONALD INSALL ASSOCIATES LTD



Information Note

Any drawing format is to be read in conjunction with and at the scale of accompanying documents.

Where colours other than black or grey are used the drawing must be plotted in colour.

All dimensions are to be checked on site by the Contractor, scaling is for Local Authority purposes only.

Unless otherwise indicated, all dimensions are in millimeters.

All information on this drawing is to be read in conjunction with the relevant Donald Insall Associates (Insall) specification and trade contractors' drawings and information by specialists.


In the event of any discrepancy, please contact Insall immediately.

This drawing may contain survey information by others and is to be used solely for the purposes for which it was issued.

These are uncontrolled documents issued for information purposes only. If you have any queries regarding the drawings, contact Insall immediately.

Insall cannot be held responsible for any errors arising from changes made to an uncontrolled file.

Drawings by Donald Insall Associates to be read in conjunction with full 'Next Chapter' drawing sets. Including those by Structural Engineer, MEP Engineer, Exhibition Designer, Fire Consultant and Acoustic Consultant.

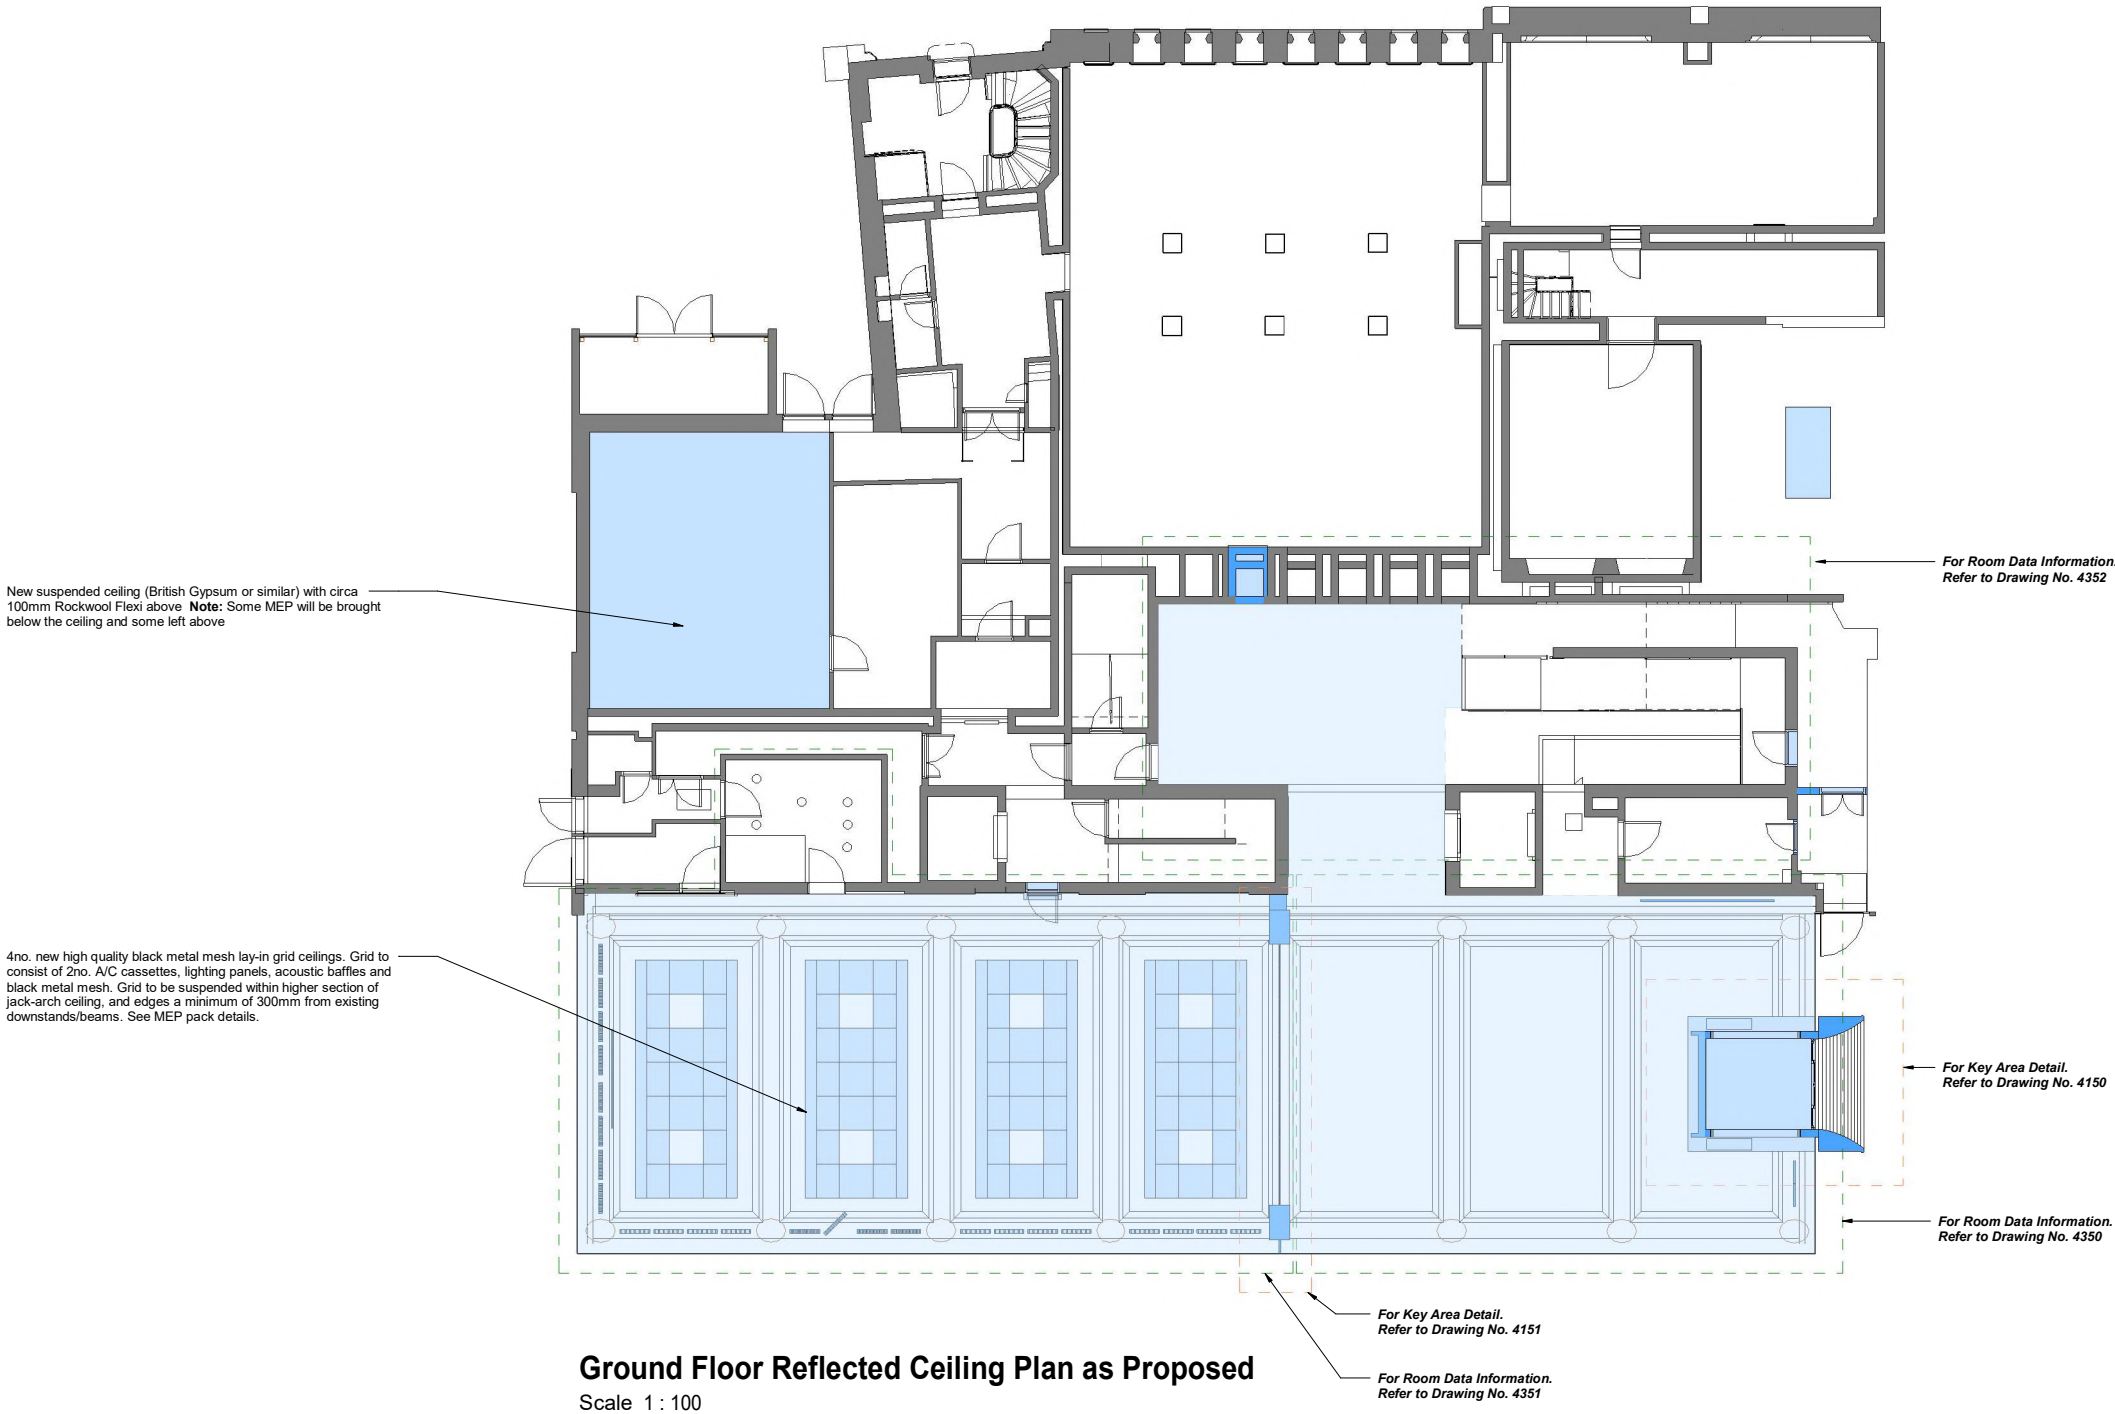

P3	27.06.23	JXW	RXC	Planning Permission and LBC Application
P2	09.05.23	JXW	RXC	For Costing
P1	13.04.23	JXW	RXC	Initial Issue
Rev.	Date	On	Auth.	Description
Purpose of Issue				
Planning Permission and LBC Application				
Project Information				
The John Rylands Research Institute and Library Manchester, 'Next Chapter' Project				
Drawing Title				
Ground Floor - Reflected Ceiling Plan as Proposed				
Drawing Number				
Project ID	Originator	Functional Breakdown	Spatial Breakdown	Form Discipline Number
JRL	- DIA -	ZZ	- 10A - D60-	ACL - 4251
Project Number				
MAN_JRL_03		Scale at A1	Status	Revision
As indicated		S3	P3	
Donald Insall Associates				
Chartered Architects and Historic Building Consultants				
Ducie House, 37 Ducie Street, Manchester M1 2JW (+44) 0161 359 4326 Manchester@insall-architects.co.uk				
© 2023 DONALD INSALL ASSOCIATES LTD				



Information Note

Any drawing format is to be read in conjunction with and at the scale of accompanying documents.

Where colours other than black or grey are used the drawing must be plotted in colour.

All dimensions are to be checked on site by the Contractor, scaling is for Local Authority purposes only.

Unless otherwise indicated, all dimensions are in millimeters.

All information on this drawing is to be read in conjunction with the relevant Donald Insall Associates (Insall) specification and trade contractors' drawings and information by specialists.


In the event of any discrepancy, please contact Insall immediately.

This drawing may contain survey information by others and is to be used solely for the purposes for which it was issued.

These are uncontrolled documents issued for information purposes only. If you have any queries regarding the drawings, contact Insall immediately.

Insall cannot be held responsible for any errors arising from changes made to an uncontrolled file.

Drawings by Donald Insall Associates to be read in conjunction with full 'Next Chapter' drawing sets. Including those by Structural Engineer, MEP Engineer, Exhibition Designer, Fire Consultant and Acoustic Consultant.

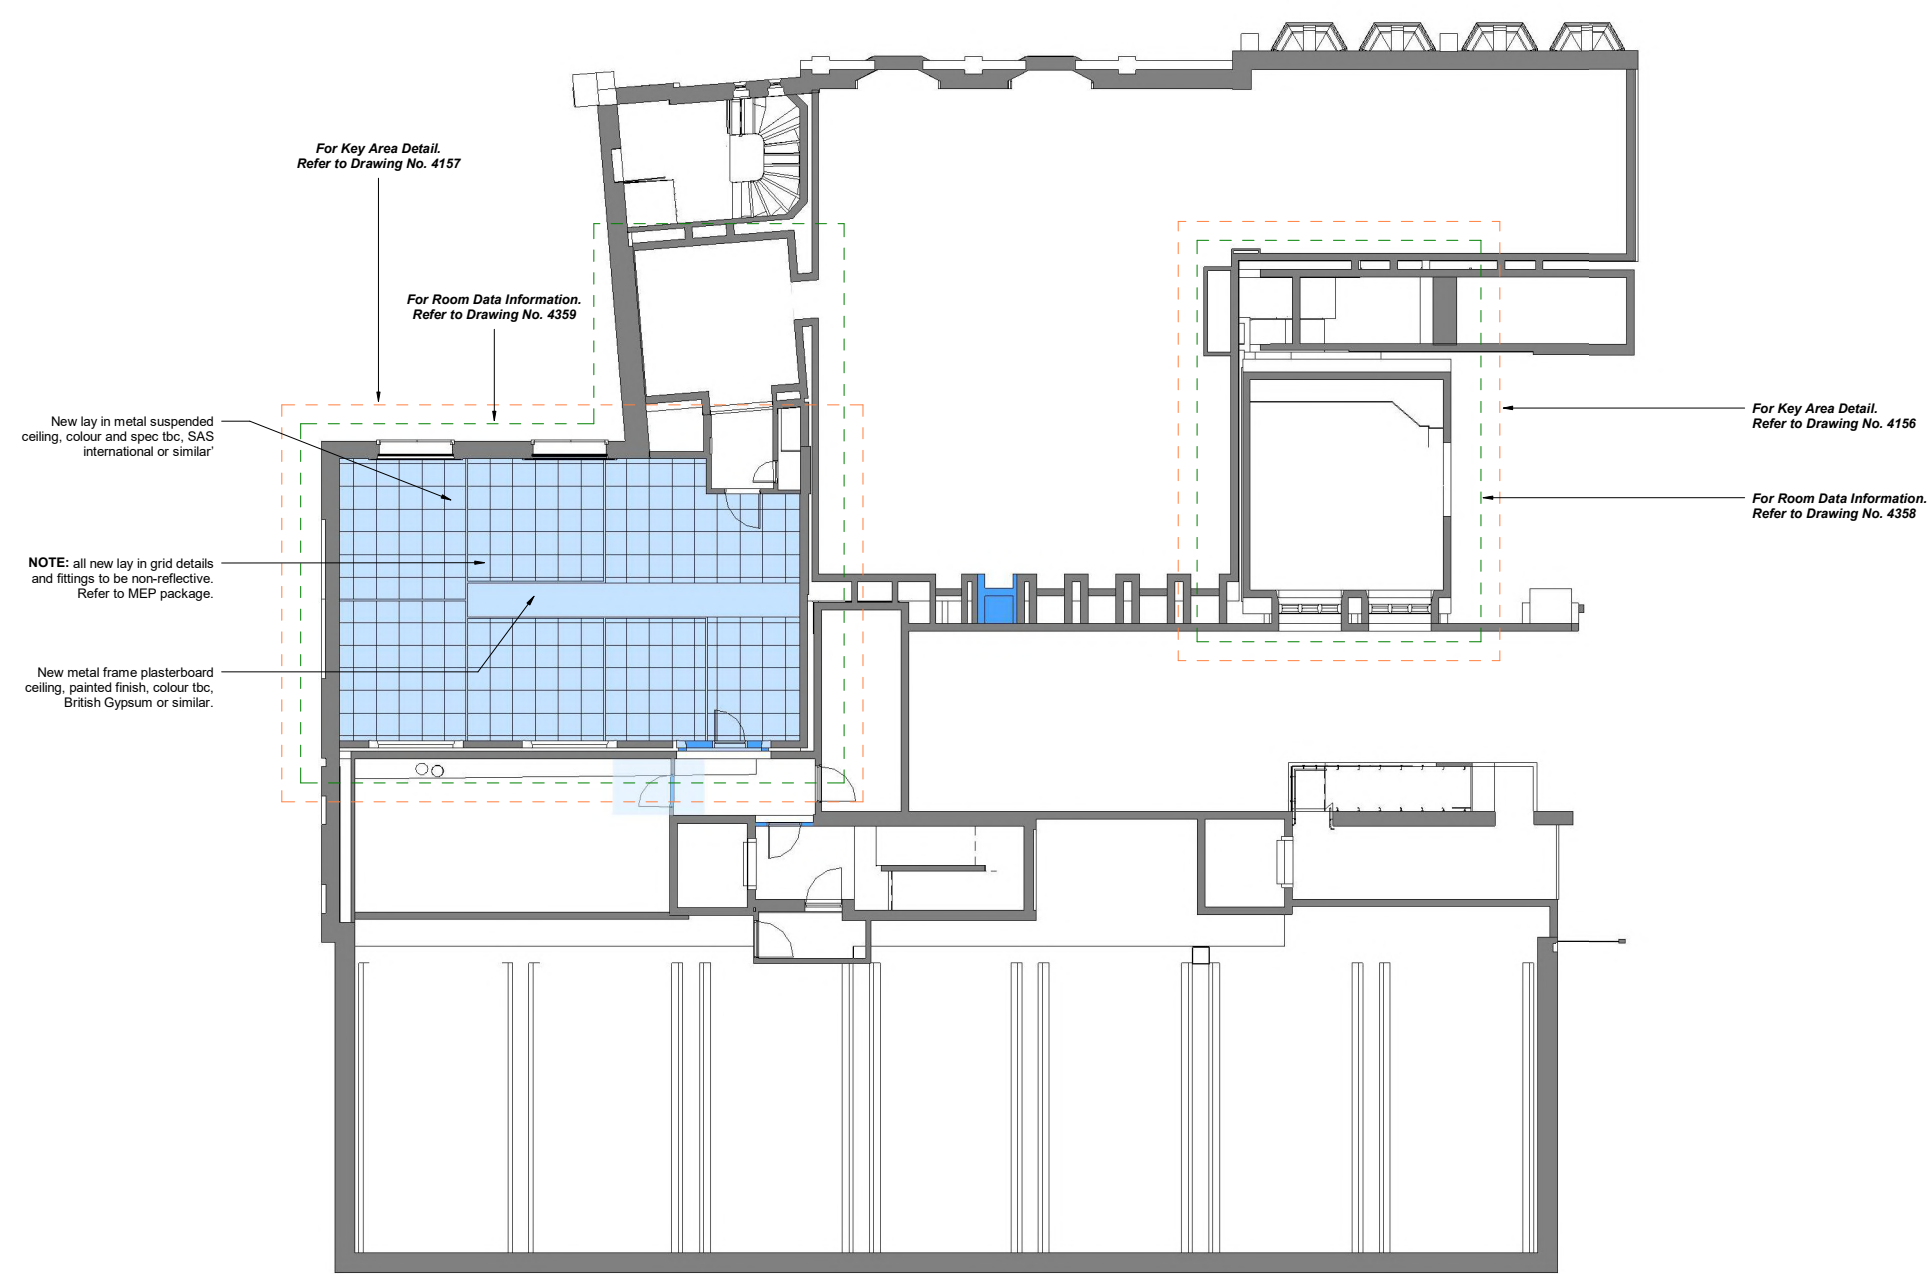

First Floor Reflected Ceiling Plan as Proposed
Scale 1 : 100

P3	27.06.23	JXW	RXC	Planning Permission and LBC Application
P2	09.05.23	JXW	RXC	For Costing
P1	13.04.23	JXW	RXC	Initial Issue
Rev.	Date	Dim.	Auth.	Description

Purpose of Issue

Planning Permission and LBC Application

Project Information

**The John Rylands
Research Institute and Library
Manchester, 'Next Chapter' Project**

Drawing Title

First Floor - Reflected Ceiling Plan as Proposed

Drawing Number		Functional Breakdown	Spatial Breakdown	Form	Discipline	Number
Project ID	Originator	Breakdown	Breakdown	Form	Discipline	Number
JRL	- DIA -	ZZ	- 20A -D60-	ACL	-	4252

Project Number	Scale at A1	Status	Revision
MAN_JRL_03	As indicated	S3	P3

Donald Insall Associates
Chartered Architects and Historic Building Consultants

Ducie House, 37 Ducie Street, Manchester M1 2JW
(+44) 0161 359 4326
Manchester@insall-architects.co.uk

© 2023 DONALD INSALL ASSOCIATES LTD



Information Note

Any drawing format is to be read in conjunction with and at the scale of accompanying documents.

Where colours other than black or grey are used the drawing must be plotted in colour.

All dimensions are to be checked on site by the Contractor, scaling is for Local Authority purposes only.

Unless otherwise indicated, all dimensions are in millimeters.

All information on this drawing is to be read in conjunction with the relevant Donald Insall Associates (Insall) specification and trade contractors' drawings and information by specialists.


In the event of any discrepancy, please contact Insall immediately.

This drawing may contain survey information by others and is to be used solely for the purposes for which it was issued.

These are uncontrolled documents issued for information purposes only. If you have any queries regarding the drawings, contact Insall immediately.

Insall cannot be held responsible for any errors arising from changes made to an uncontrolled file.

Drawings by Donald Insall Associates to be read in conjunction with full 'Next Chapter' drawing sets. Including those by Structural Engineer, MEP Engineer, Exhibition Designer, Fire Consultant and Acoustic Consultant.

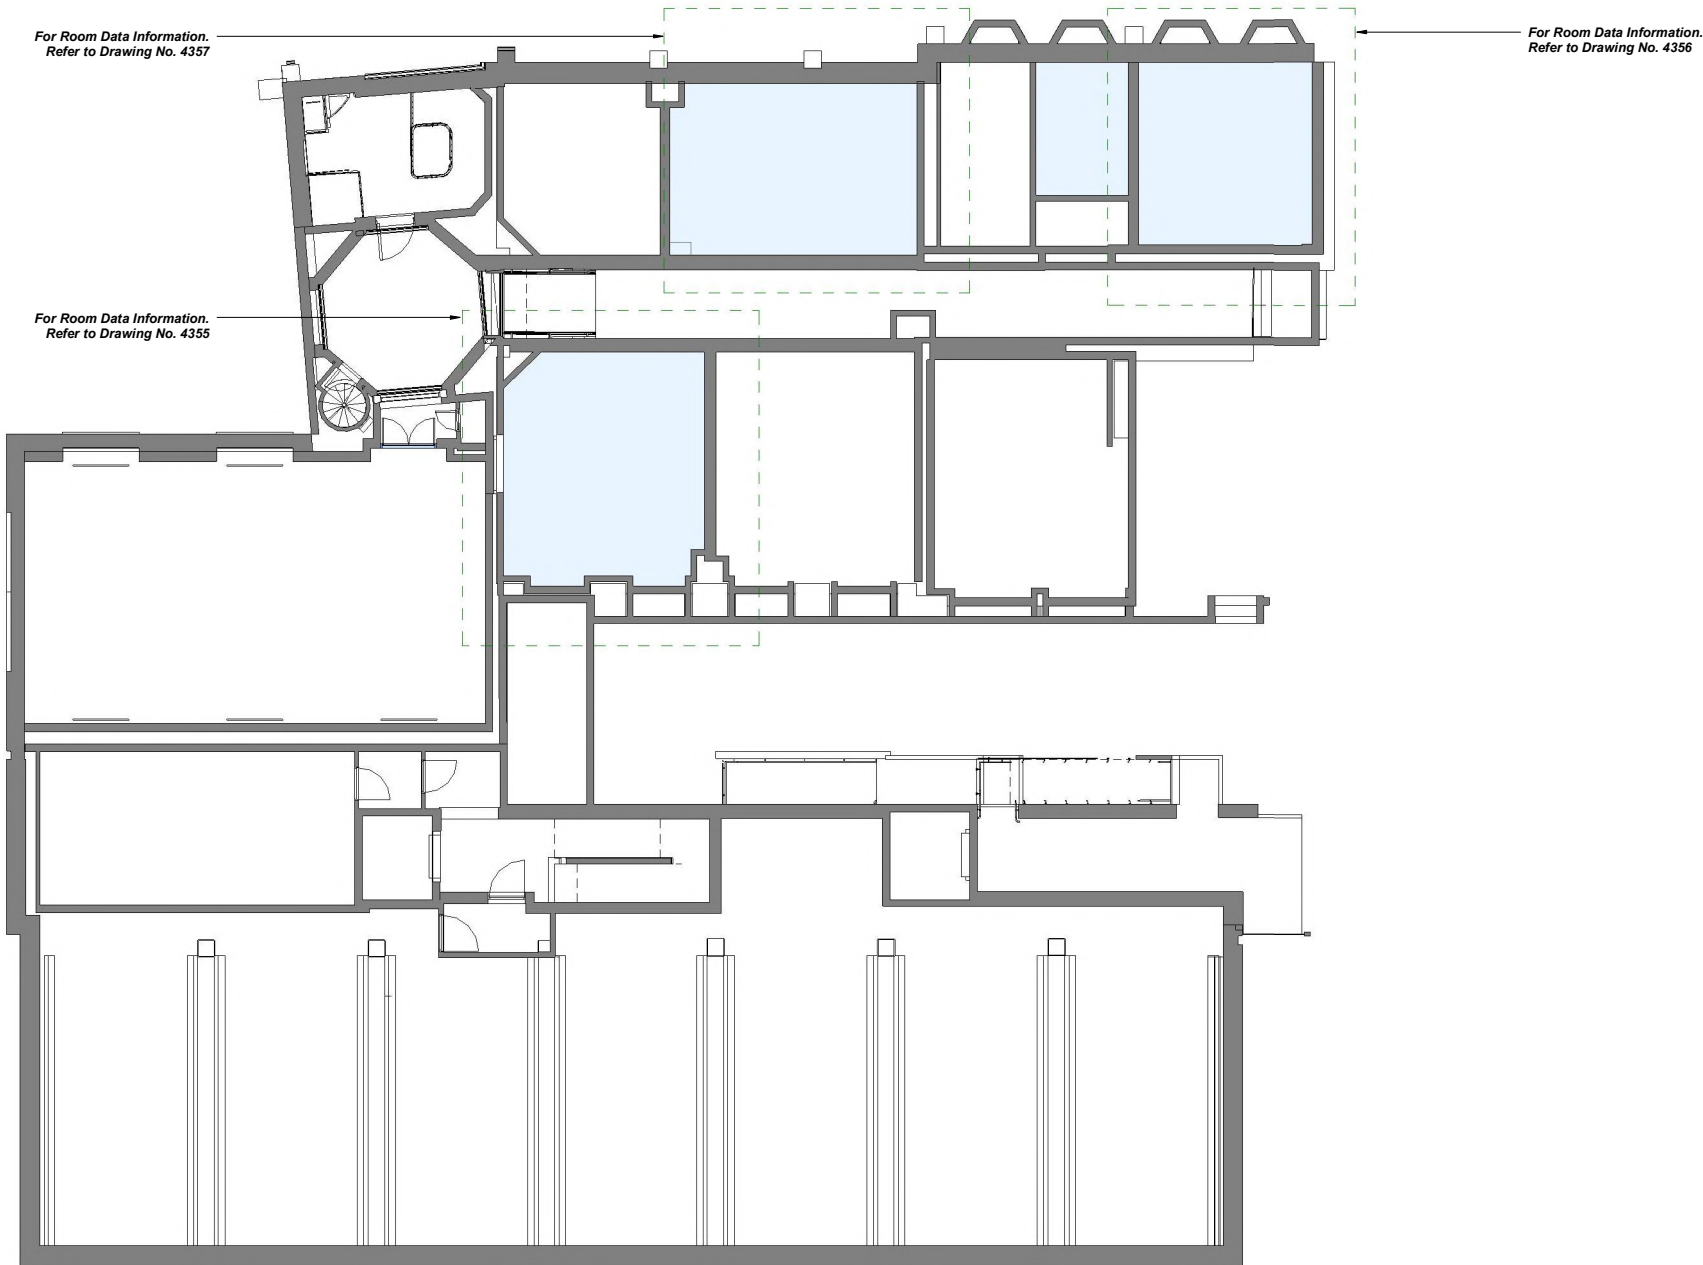

Second Floor Reflected Ceiling Plan as Proposed
Scale 1 : 100

P3	27.06.23	JXW	RXC	Planning Permission and LBC Application
P2	09.05.23	JXW	RXC	For Costing
P1	13.04.23	JXW	RXC	Initial Issue
Rev.	Date	Dim.	Auth.	Description

Purpose of Issue

Planning Permission and LBC Application

Project Information

**The John Rylands
Research Institute and Library
Manchester, 'Next Chapter' Project**

Drawing Title

Second Floor - Reflected Ceiling Plan as Proposed

Drawing Number		Functional Breakdown	Spatial Breakdown	Form	Discipline	Number
Project ID	Originator					
JRL	- DIA	- ZZ	- 30A	- D60-	ACL	- 4253


Project Number	Scale at A1	Status	Revision
MAN_JRL_03	As indicated	S3	P3

Donald Insall Associates
Chartered Architects and Historic Building Consultants

Ducie House, 37 Ducie Street, Manchester M1 2JW
(+44) 0161 359 4326
Manchester@insall-architects.co.uk

© 2023 DONALD INSALL ASSOCIATES LTD



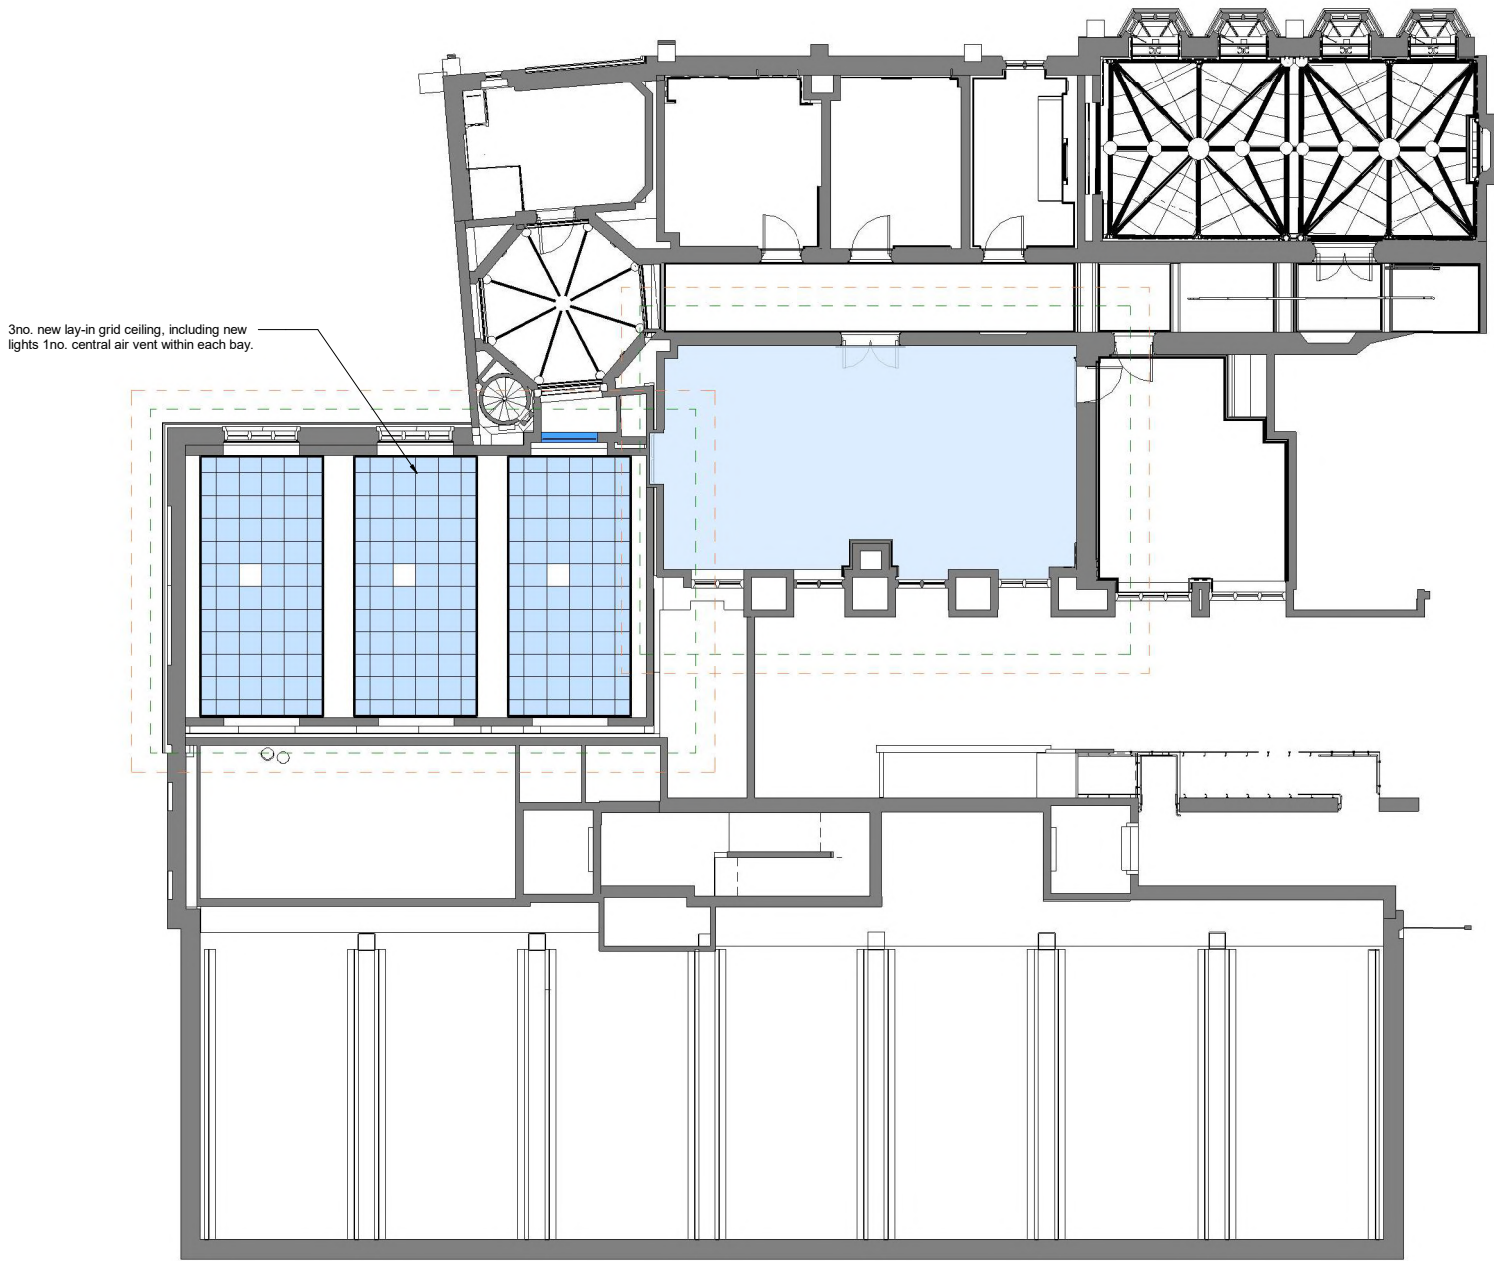

Third Floor Reflected Ceiling Plan as Proposed
Scale 1 : 100

Information Note

Any drawing format is to be read in conjunction with and at the scale of accompanying documents.

Where colours other than black or grey are used the drawing must be plotted in colour.

All dimensions are to be checked on site by the Contractor, scaling is for Local Authority purposes only.

Unless otherwise indicated, all dimensions are in millimeters.

All information on this drawing is to be read in conjunction with the relevant Donald Insall Associates (Insall) specification and trade contractors' drawings and information by specialists.

In the event of any discrepancy, please contact Insall immediately.

This drawing may contain survey information by others and is to be used solely for the purposes for which it was issued.

These are uncontrolled documents issued for information purposes only. If you have any queries regarding the drawings, contact Insall immediately.

Insall cannot be held responsible for any errors arising from changes made to an uncontrolled file.

Drawings by Donald Insall Associates to be read in conjunction with full 'Next Chapter' drawing sets. Including those by Structural Engineer, MEP Engineer, Exhibition Designer, Fire Consultant and Acoustic Consultant.

P3	27.06.23	JXW	RXC	Planning Permission and LBC Application	
P2	09.05.23	JXW	RXC	For Costing	
P1	16.03.23	JXW	ELE	Initial Issue	
Rev.	Date	Dim.	Auth.	Description	
Purpose of Issue					
Planning Permission and LBC Application					
Project Information					
The John Rylands					
Research Institute and Library					
Manchester, 'Next Chapter' Project					
Drawing Title					
Third Floor - Reflected Ceiling Plan as Proposed					
Drawing Number					
Project ID	Originator	Functional Breakdown	Spatial Breakdown	Form	Discipline Number
JRL	- DIA	- ZZ	- 40A -D60-	ACL	- 4254
Project Number		Scale at A1		Status	Revision
MAN_JRL_03		As indicated		S3	P3

Donald Insall Associates

Chartered Architects and Historic Building Consultants

Ducie House, 37 Ducie Street, Manchester M1 2JW
(+44) 0161 359 4326
Manchester@insall-architects.co.uk

© 2023 DONALD INSALL ASSOCIATES LTD

Any drawing format is to be read in conjunction with and at the scale of accompanying documents.

All dimensions are to be checked on site by the Contractor, scaling is for Local Authority purposes only.

Unless otherwise indicated, all dimensions are in millimeters.

All information on this drawing is to be read in conjunction with the relevant Donald Insall Associates (Insall) specification and trade contractors' drawings and information by specialists.

In the event of any discrepancy, please contact Insall immediately.

This drawing may contain survey information by others and is to be used solely for the purposes for which it was issued.

These are uncontrolled documents issued for information purposes only. If you have any queries regarding the drawings, contact Insall immediately.

Insall cannot be held responsible for any errors arising from changes made to an

Drawings by Donald Insall Associates to be read in conjunction with full 'Next Chapter' drawing sets. Including those by Structural Engineer, MEP Engineer, Exhibition Designer, Fire Consultant and Acoustic Consultant.



Purpose of Issue

Planning, Permission, and LDC Application

Project Information

The John Rylands
Research Institute and Library
Manchester, 'Next Chapter' Project

Drawing Title

Fourth Floor - Reflected Ceiling Plan as Proposed

Project Number	Scale at A1	Status	Revision
MAN_JRL_03	As indicated	S3	P3

Donald Insall Associates
Chartered Architects and Historic Building Consultants

Ducie House, 37 Ducie Street, Manchester M1 2JW
(+44) 0161 359 4326
Manchester@insall-architects.co.uk

© 2023 DONALD INSALL ASSOCIATES LTD