




FLOOR PLAN AS EXISTING 1:50

NORTH-EAST ELEVATION AS EXISTING 1:50

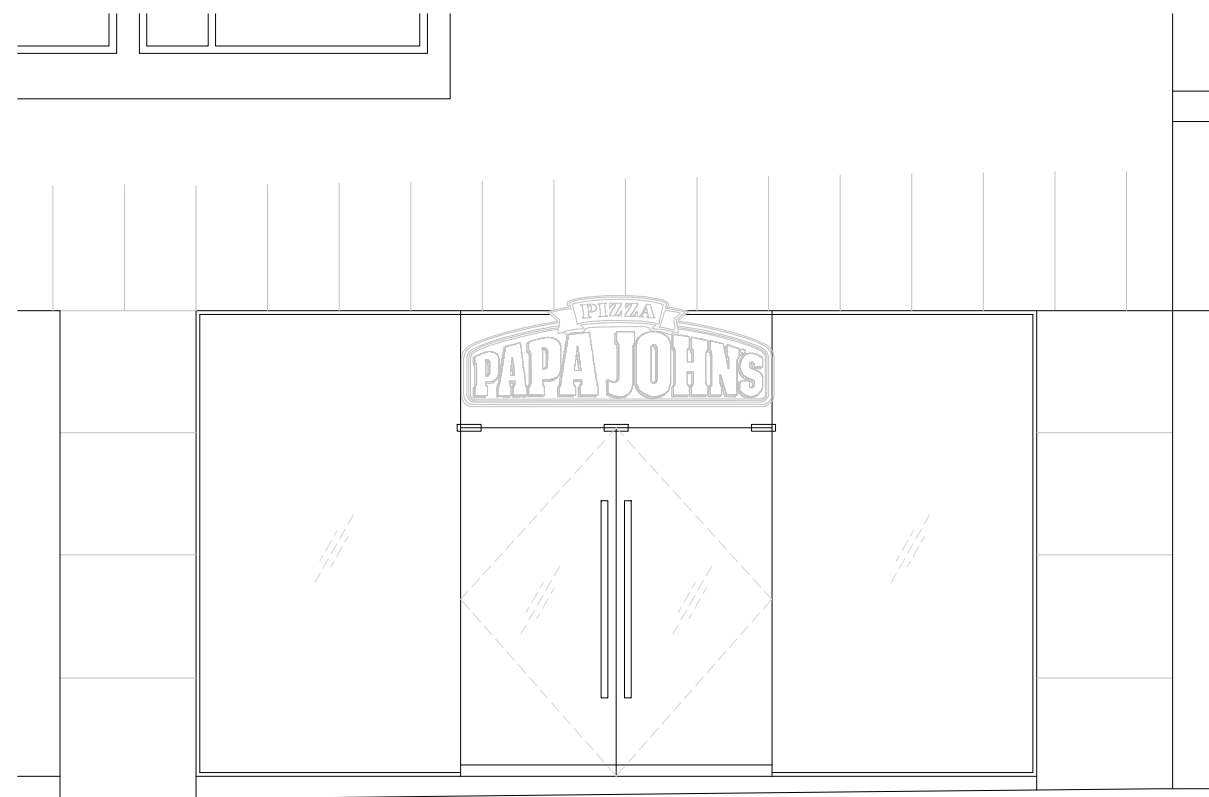

FD30 30MIN RATED DOOR	FD60 60MIN RATED DOOR	FD120 120MIN RATED DOOR
FOAM EXTINGUISHERS	GAS EXTINGUISHERS	WATER EXT.
POWDER EXT.	LIQUID EXT.	FIRE BLANKET
FIRE ALARM PANEL	SMOKE GLASS ALARM	AUTO FIRE DETECTOR
FINAL EXIT SIGN	EMERGENCY LIGHT	FIRE ALARM
SPROWLER	ESCAPE ROUTE	DOOR RELEASE
30MIN RATED WALL	60MIN RATED WALL	120MIN RATED WALL
ALARM PANEL	CCTV	LINE OF SHUTTERS
DIGITAL DOOR LOCK	SHUTTER CONTROLS	PIR DETECTOR
DISTRIBUTION BOARD	INCOMING ELECTRIC	ELECTRIC METER
DOUBLE SOCKET	LIGHT SWITCH	PULL CHORD SWITCH
POWER SPIN	FURNACE LIGHT	DISCHARGE LIGHT
TIME LIMIT	WATER HEATER	SPEAKER
ELECTRIC RADIATOR	DATA POINT	CORRIDOR CABINET
INCOMING WATER	INCOMING GAS	INCOMING DP
INCOMING BT	WATER METER	GAS METER
DRAINER	CEILING EXTRACT	WALL EXTRACT
RADIATOR	AIR OUTTAKE	EXTRACT CONTROLS
THERMOSTAT	A/C CONTROLS	CURTAIN CONTROLS
A/C CASSETTE	A/C CONDENSER	WALL MOUNTED A/C
COLD WATER FEED	HOT WATER FEED	POOL DRAIN RUN
SOLID WALL	STUD WALL	JOINT DIRECTION

2 ISSUED TO PLANNING	07/05/23
1 INITIAL ISSUE	00/02/23

PAPA JOHNS®
Better Ingredients. Better Pizza.

DMU DESIGNS
ARCHITECTURAL SERVICES LTD

PLANNING APPLICATIONS
BUILDING REGULATIONS
RESIDENTIAL BUILDING PERMITS
WORKING DRAWINGS
FEASIBILITY / BUDGET QUOTES
3D/2D PLANNING

MAIL@DMUDESIGNS.CO.UK
WWW.DMUDESIGNS.CO.UK
+44 (0)161 407385

CLIENT PAPA JOHNS		
STATUS PLANNING		
DRAWING NUMBER 2933-002	DRAWING TITLE PROPERTY AS EXISTING	
DRAWING REVISION 2	DATE FEBRUARY 2023	
SCALE AS SHOWN	PAPER SIZE A1	DRAWN BY PTM
PROPERTY 5 PETER HOUSE OXFORD ROAD MANCHESTER, M1 5AN		
DO NOT SCALE FROM THIS DRAWING. ANY DISCREPANCIES TO BE REPORTED IMMEDIATELY. DMU DESIGNS IS A LIMITED COMPANY REGISTERED IN ENGLAND AND WALES. REGISTERED NUMBER: 719897		