


Safety	
Protection class	IP 65
Impact resistance	IK07
Max. ambient temperature	40 °C
ENEC certification	✓
CE conformity	✓

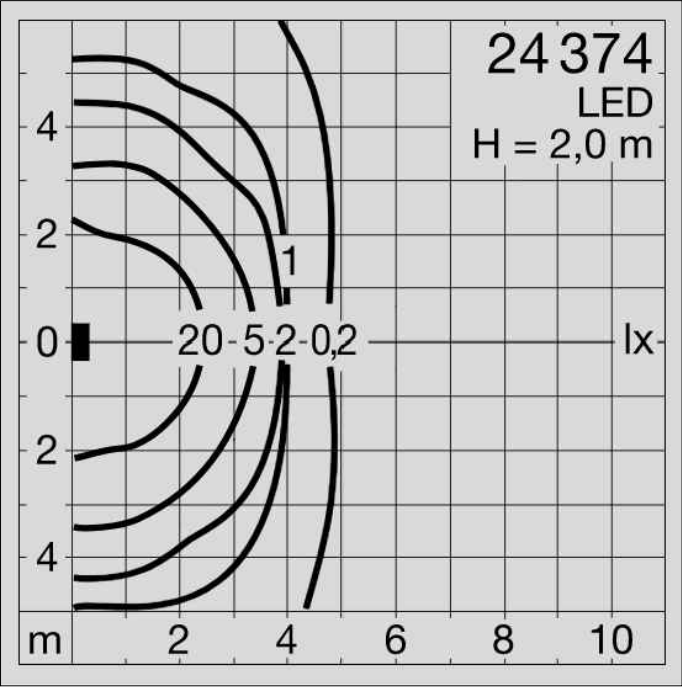

Bega 24 373 K3 - Graphite - 3000k

These lines measure 100mm in length when plotted correctly.

0 1 3 5 6m

1:100

0 1m 2m 3m



1:50

All scaled dimensions taken from this drawing shall be verified on site.

This drawing is the property of Marketaylor Ltd and no information contained hereon shall be copied, in whole or in part, or passed to any other party without written consent. Copyright 2018.

Notes

- This drawing shall be read in conjunction with the relevant Marketaylor Ltd specification(s) and all relevant Architect's and other Engineer's drawing(s).
- Details are for design purposes only and shall be verified on site by the Engineering Contractor where accuracy is critical. The exact location of all plant items/equipment and the route of all services shall be determined on site.
- All plant, equipment, distribution system components and ancillaries shall be installed in strict accordance with the manufacturer's guidelines.
- The installation personnel shall allow for changes in distribution system(s) invert levels (including any sets up and down etc.) as necessary to coordinate fully with the building structure and other M&E Services.

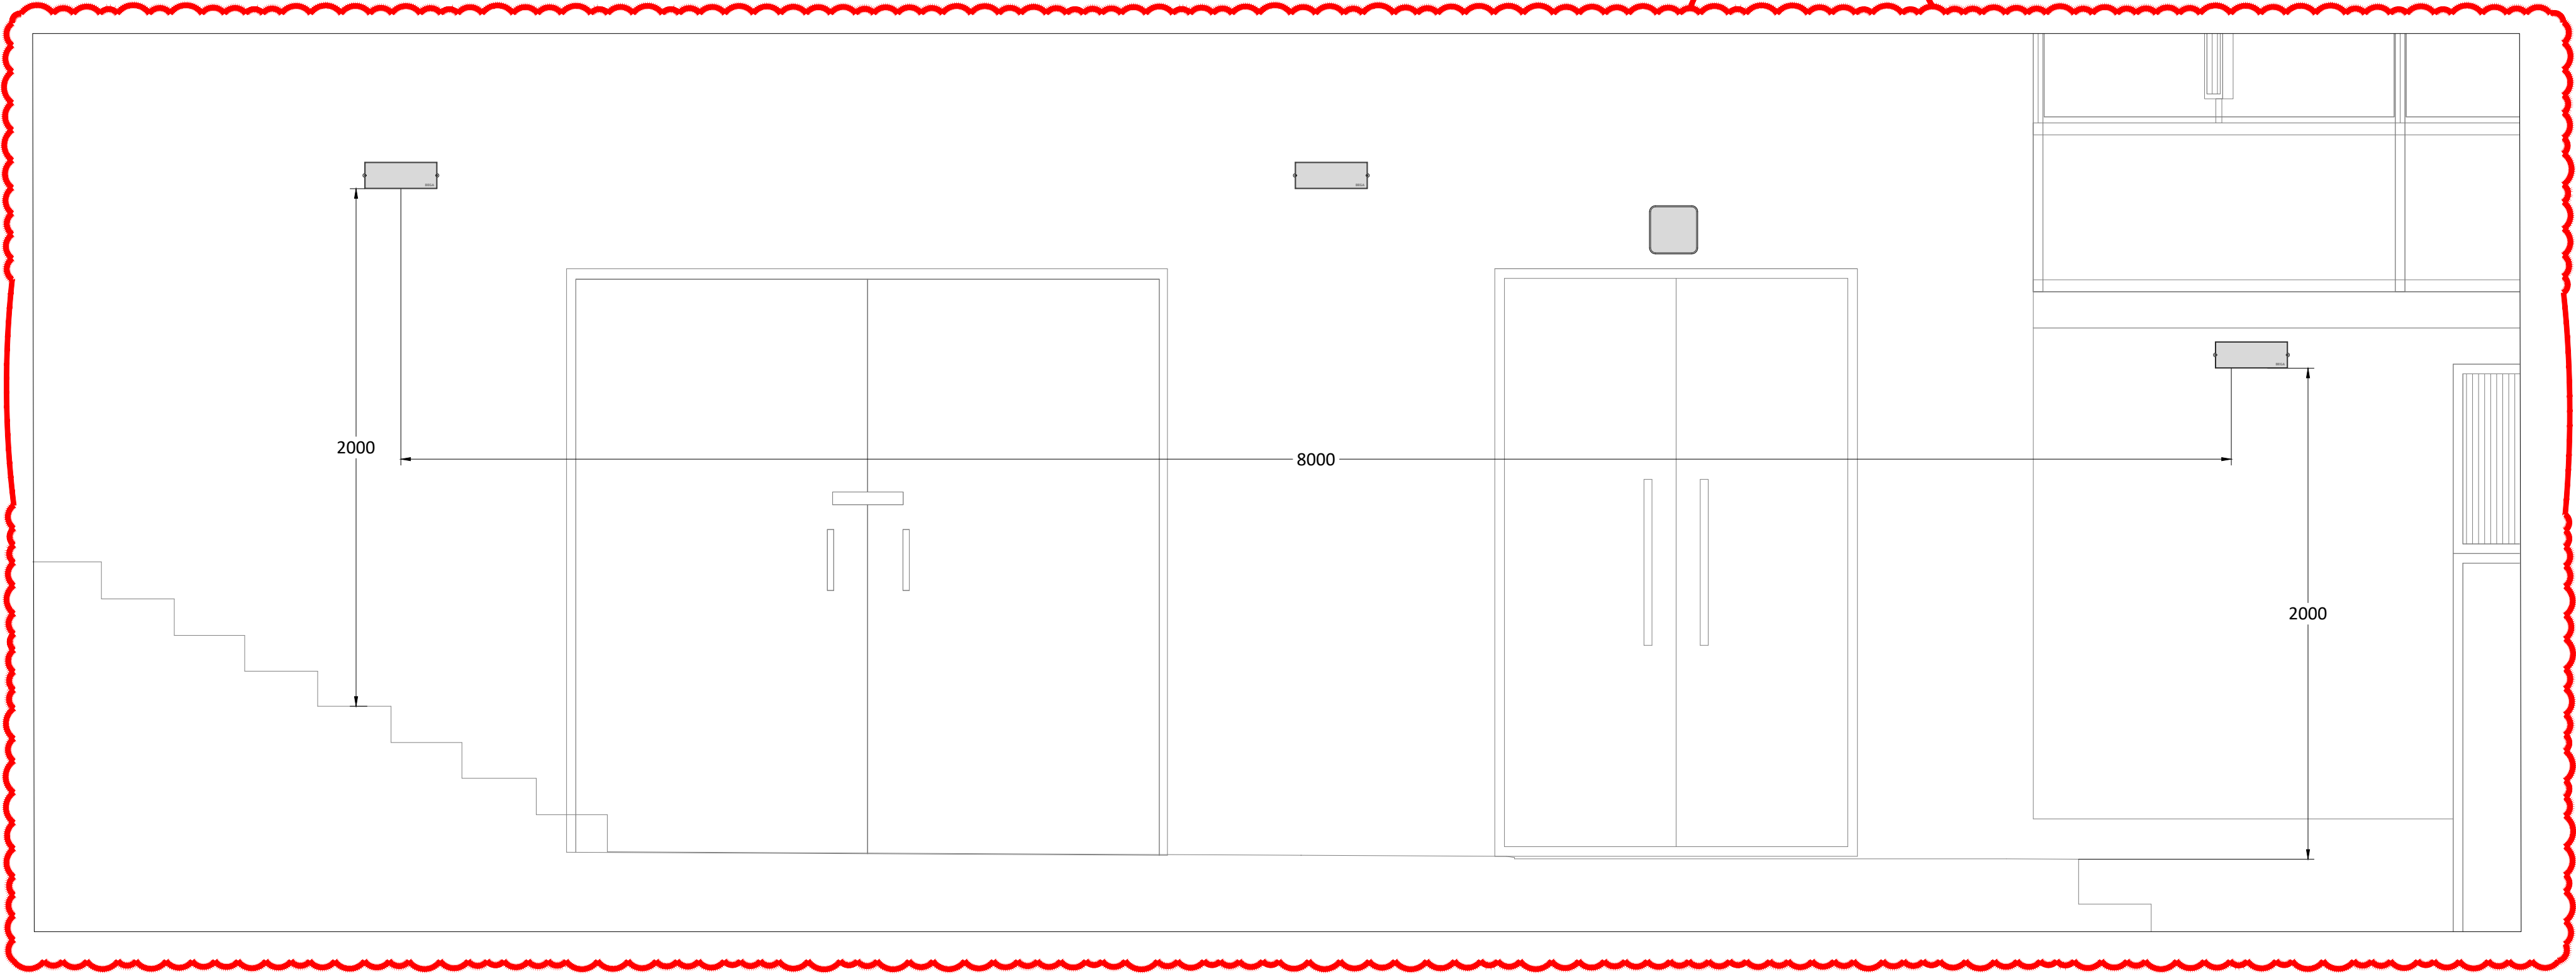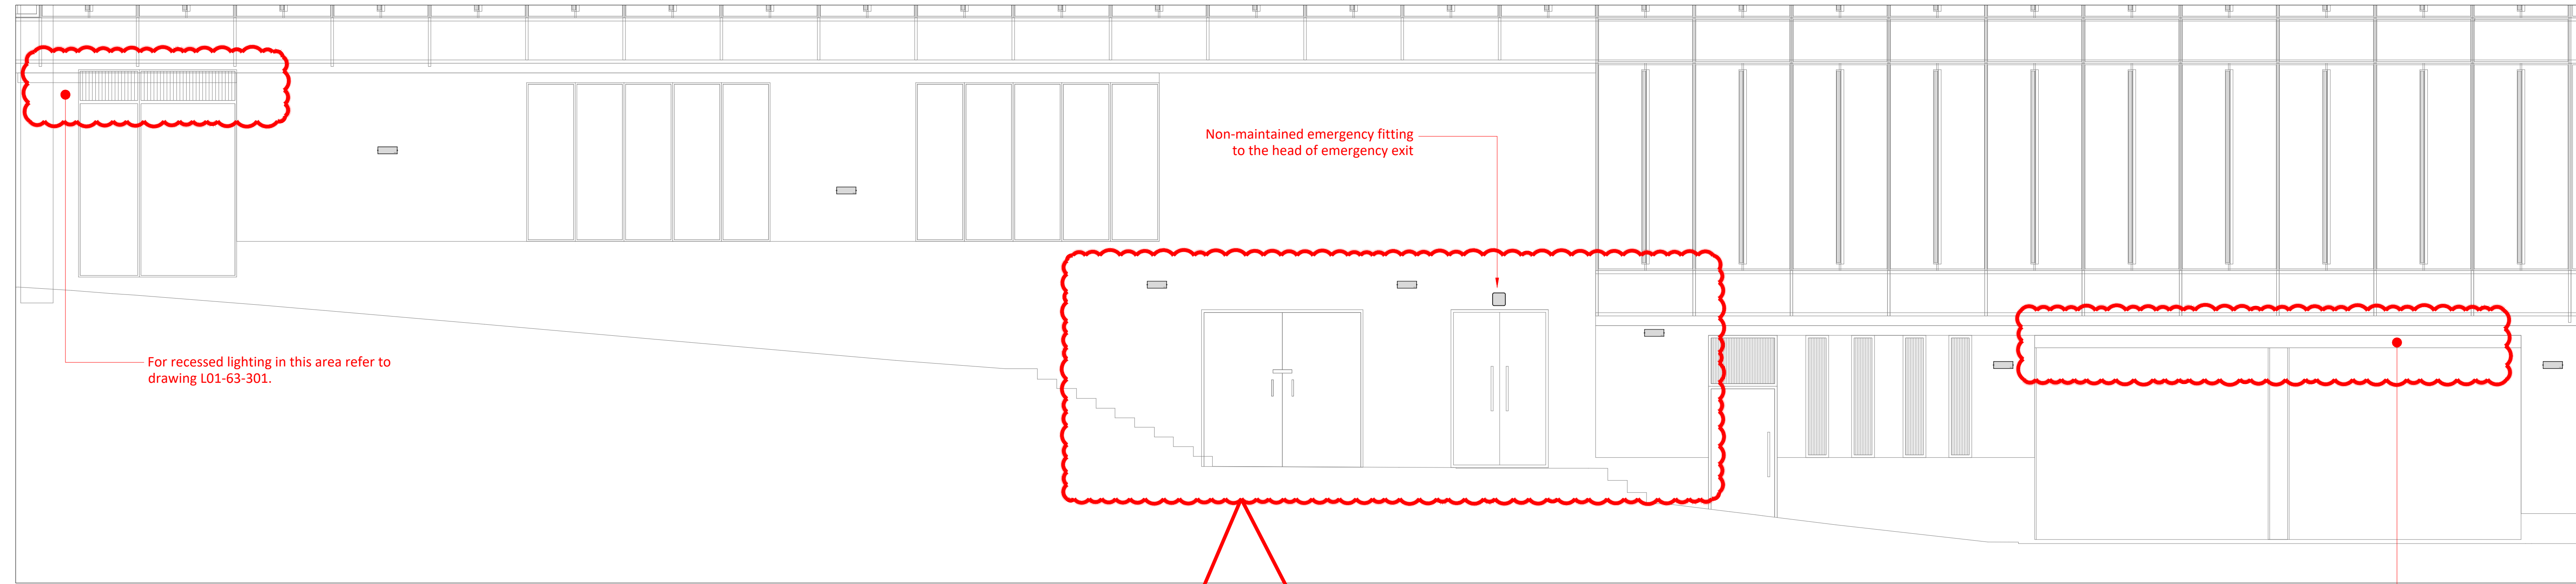

This drawing is indicative of a design. The contractor shall be responsible for the production of design calculations and drawings to the satisfaction of the client and engineer. This drawing has been provided for information purposes only and does not necessarily identify all elements of the works.

C2	BEGA LUMINAIRE ADDED TO CAR PARK ENTRANCE	27.01.23	JS	JN
C1	CONTRACT ISSUE	15.12.22	JS	JN
ISSUE	DESCRIPTION	DATE	DRN	CHD



Marketaylor Limited
37 Market Street
Hollingworth
Hyde
Greater Manchester
SK14 8NE

0161 820 9479 | info@marketaylor.co.uk | www.marketaylor.co.uk

STATUS

CONTRACT

CLIENT **Bridgewater Manchester
(Luxembourg) Holding Sarl**

CONTRACT **70 Bridgewater House
Manchester**

TITLE **West Elevation
External Lighting**

DATE	15.12.22	SCALE	n.t.s	
DRAWN	JS	JOB No.	DRG No.	REV
CHECKED	JN	C598	EL-E-63-303	C2
APPROVED	JN			
EXTERNAL REF.	n/a			

THIS DRAWING IS CONFIDENTIAL & IS THE PROPERTY OF MARKETAYLOR LTD. IT MUST NOT BE DISCLOSED TO A THIRD PARTY, COPIED OR LENT WITHOUT THEIR WRITTEN CONSENT.