


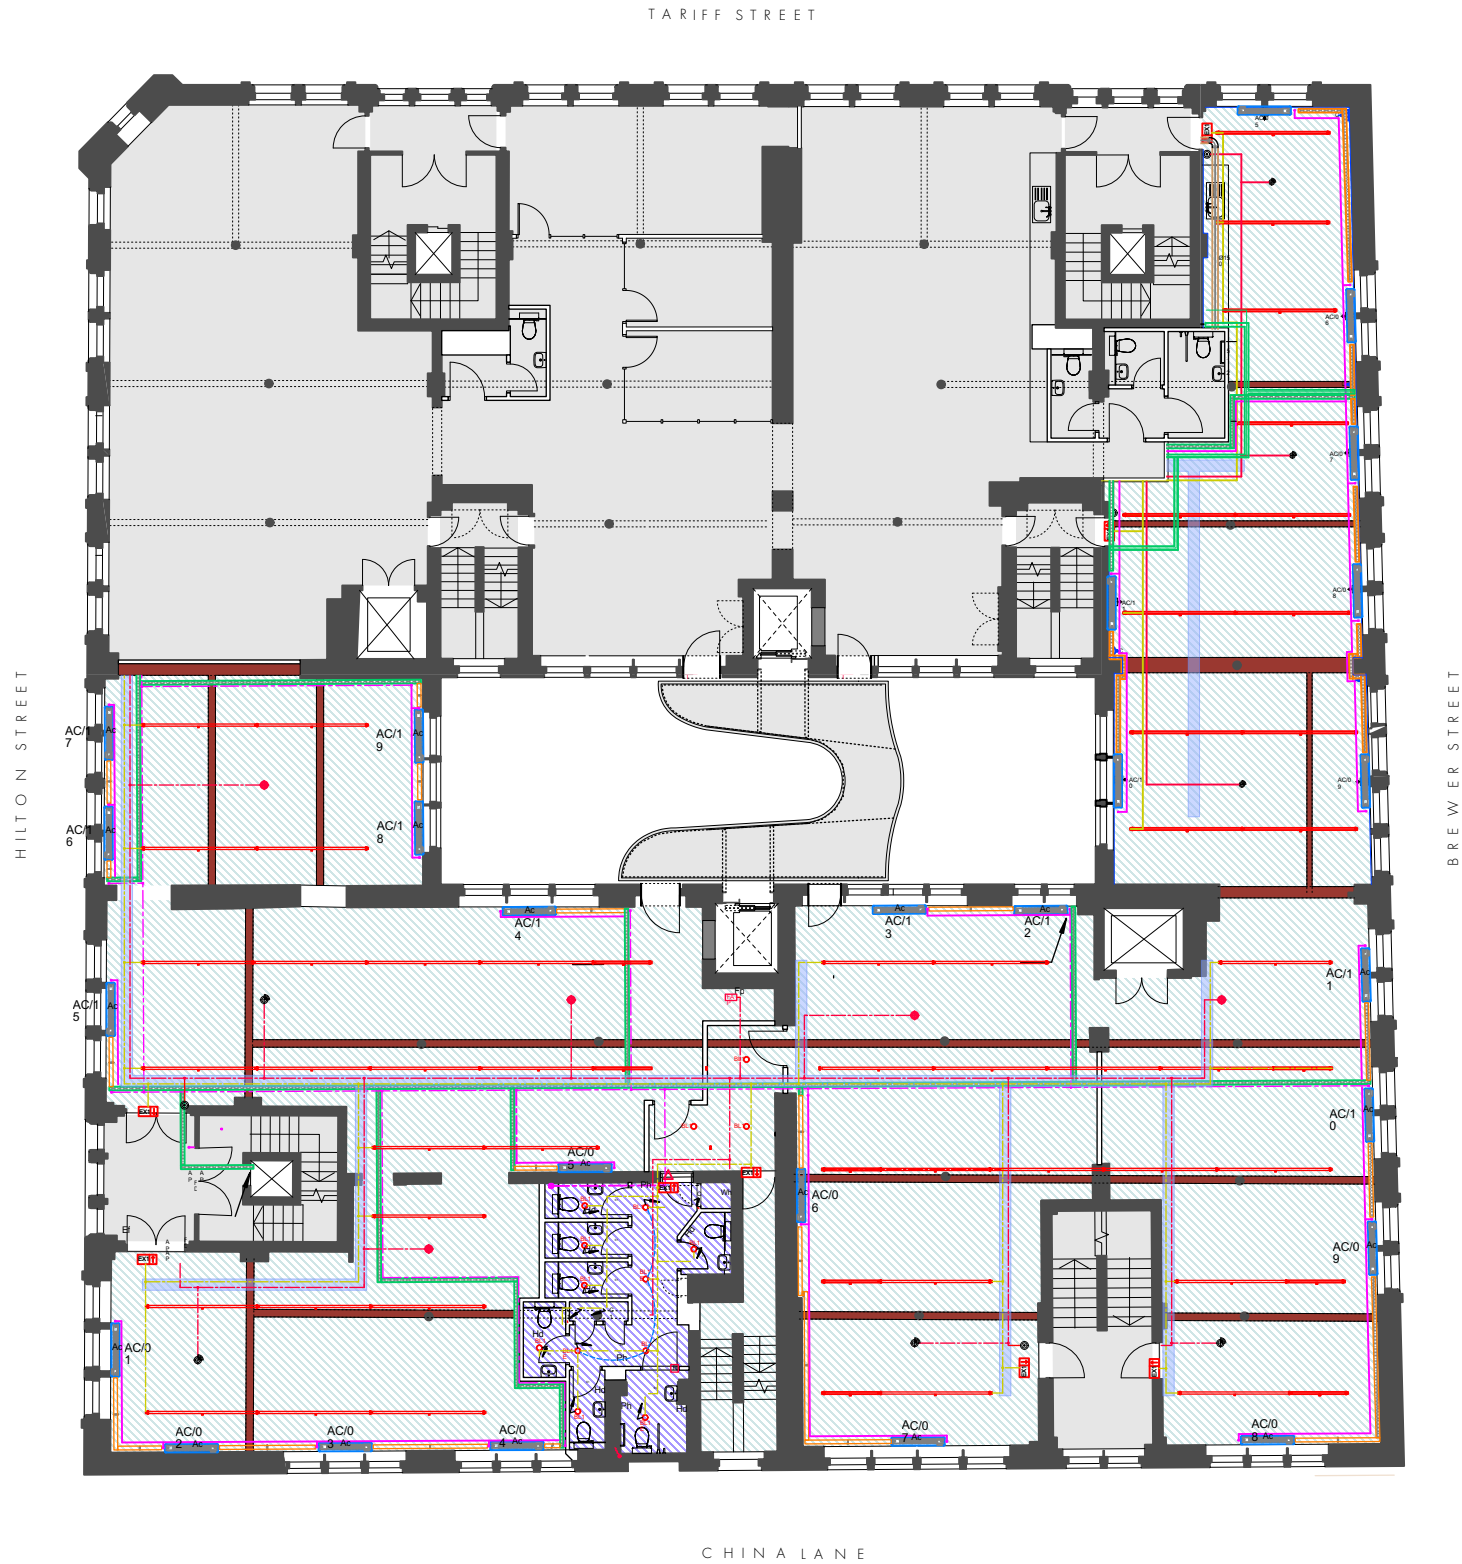

FOURWAYS HOUSE, SECOND FLOOR
PROPOSED REFLECTED CEILING PLAN

1:100 @ A3

REVISION	DATE	DESCRIPTION
P01	27.02.23	FOR COMMENT
P02	17.03.23	PLANNING ISSUE

REFLECTED CEILINGS KEY

EXISTING PLASTERED CEILING

EXISTING PLASTERED SUSPENDED CEILING

ORIGINAL TIMBER BEAM EXPOSED

AREA NOT SUBJECT OF THIS APPLICATION
SEE APPLICATIONS No.s 123242/FO/2019,
122935/LO/2019, 130337/LO/2021 & 134591/LO/20221

MECHANICAL AND ELECTRICAL KEY

ELECTRICAL SYMBOL LEGEND:

A1

Thorlux 30/45w LED 1500mm HI-Bar Suspended
Continuous Luminaire. Smart Scan (Colour TBC)

A1E

Thorlux 30/45w LED 1500mm HI-Bar Suspended
Continuous Luminaire. Smart Scan Emergency (Colour TBC)

A2

Thorlux 60/90w LED 3000mm HI-Bar Suspended
Continuous Luminaire. Smart Scan (Colour TBC)

A2E

Thorlux 60/90w LED 3000mm HI-Bar Suspended
Continuous Luminaire. Smart Scan Emergency (Colour TBC)

A3

Thorlux HI-Bar Suspended End Kit

A4

Thorlux HI-Bar Suspension Kit

VENTILATION LEGEND:

Extract Fan

Extract Grille

Volume Control Damper

Smoke & Fire Damper

Access Panel

300mm x 25mm Galvanised Cable Tray

 
Mitsubishi PEFY Series Fan Coil Unit
(Or Equal & Approved)

Supply Circular Swirl c/w Coanda
Plate
(Gilberts Or Equal & Approved)

Volume Control Damper

Supply Air Ductwork

Refrigerant Pipework (High Level)



PLANNING

OMIArchitects

31 Blackfriars Road, Salford, Manchester, M3 7AQ
+44(0)161 832 3242 / info@omiarchitects.com / www.omiarchitects.com

PROJECT	FOURWAYS					
DRAWING	SECOND FLOOR - PROPOSED CEILING PLAN					
DATE	FEB' 23	DRAWN BY	PE	SCALE	1:100	@A3
JOB NO.	1420	DWG.NO.	L 2327			