



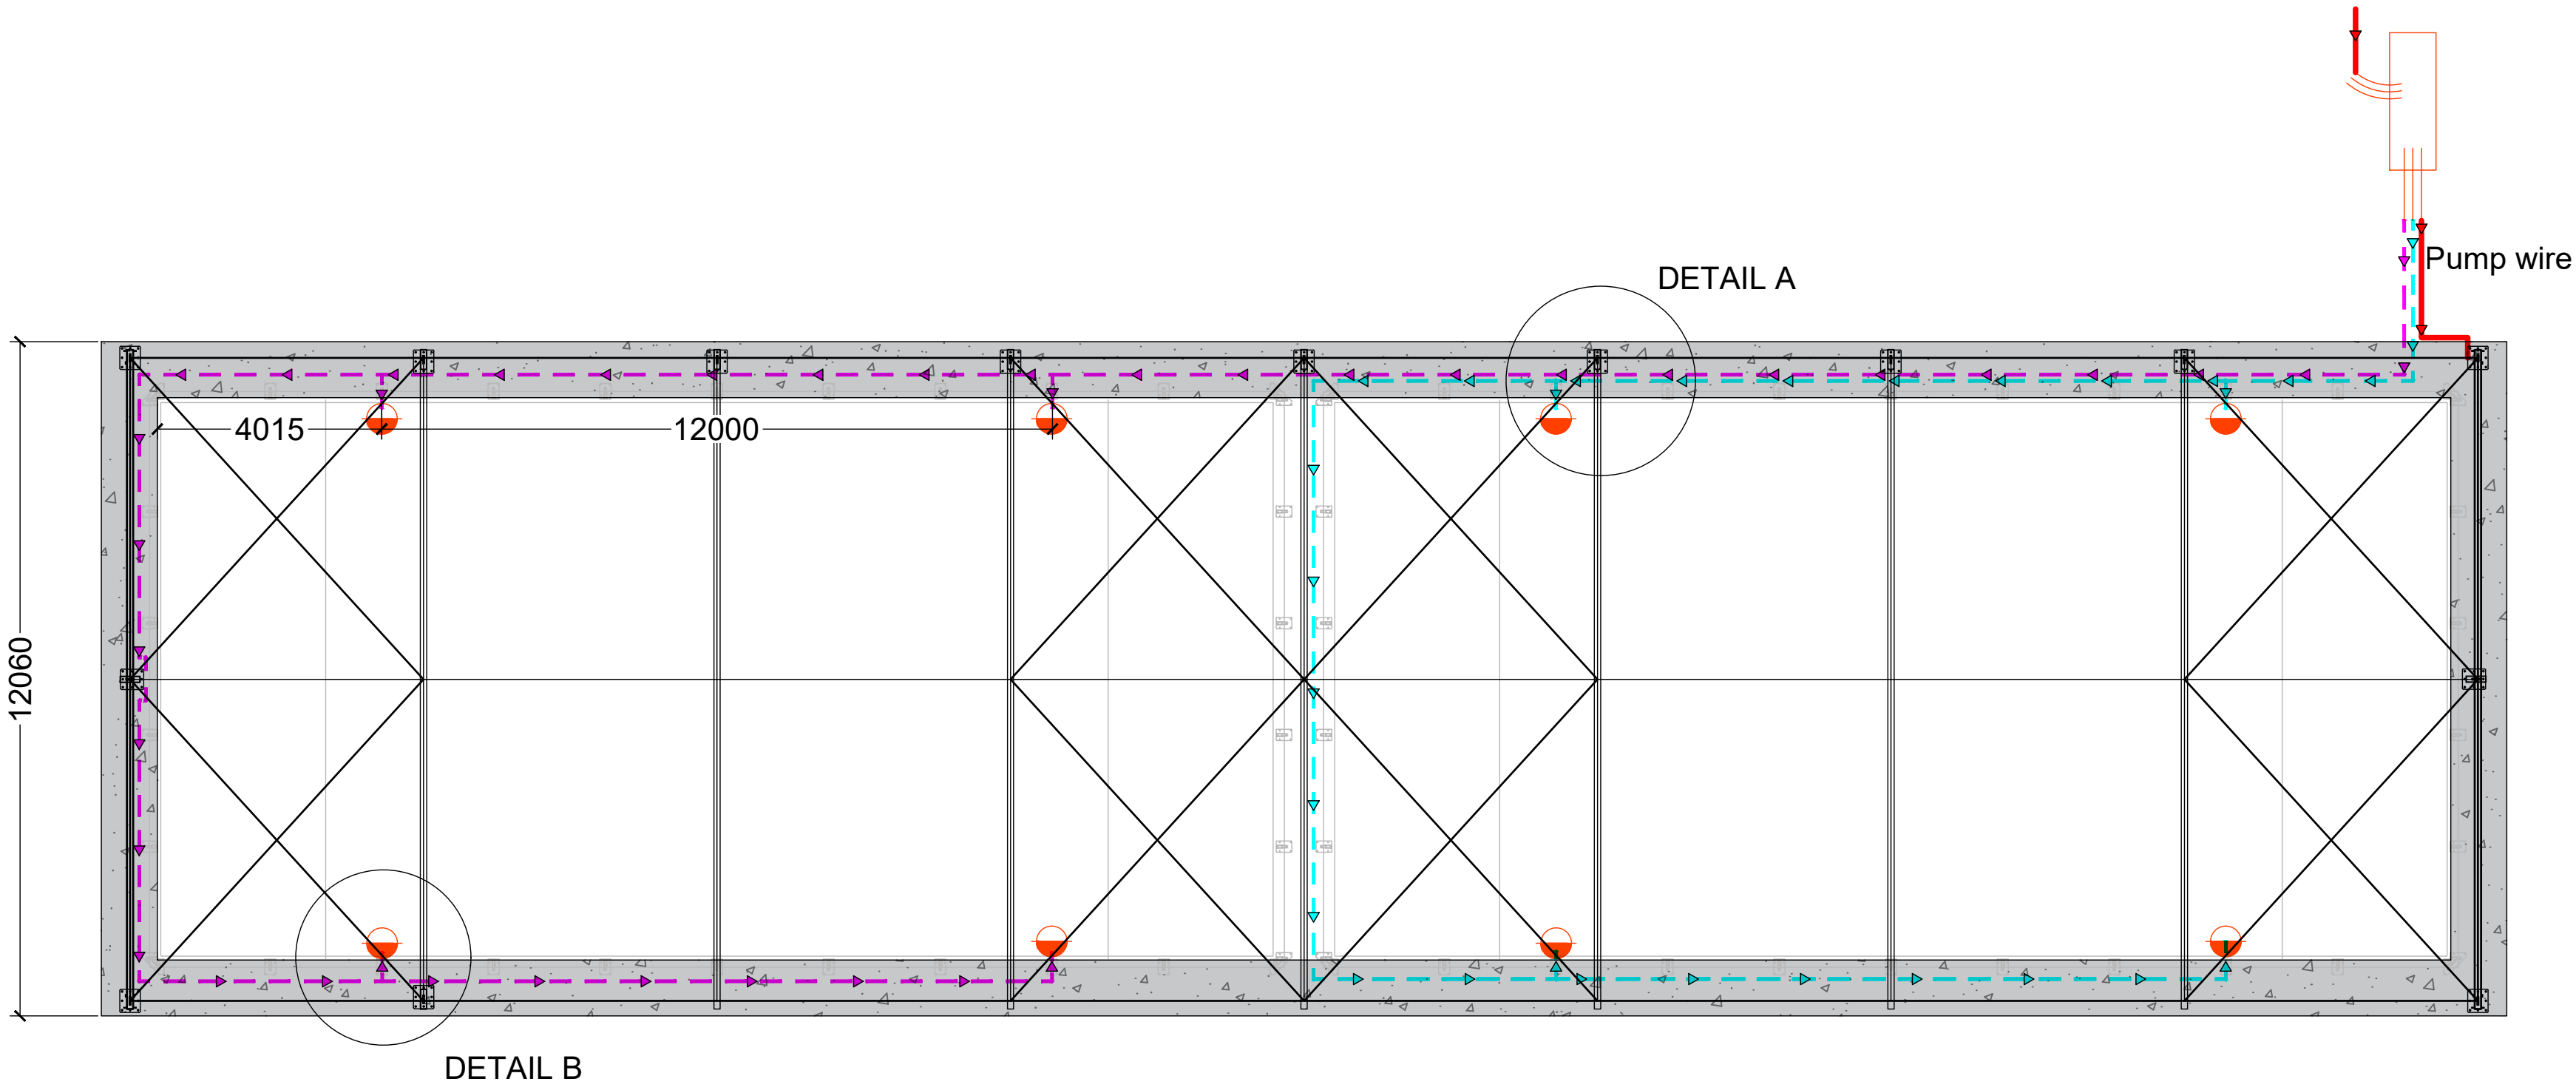


1:200
4m 0 4m 8m 12m

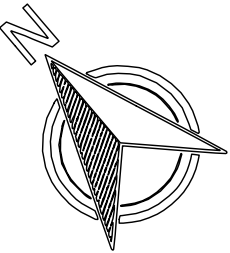


KEY

- Main line to connect to power chamber and feed pump.
- Circuit 1
- Circuit 2
- Floodlights
- Electrical feed to IP 65

02 DETAIL A
1:20

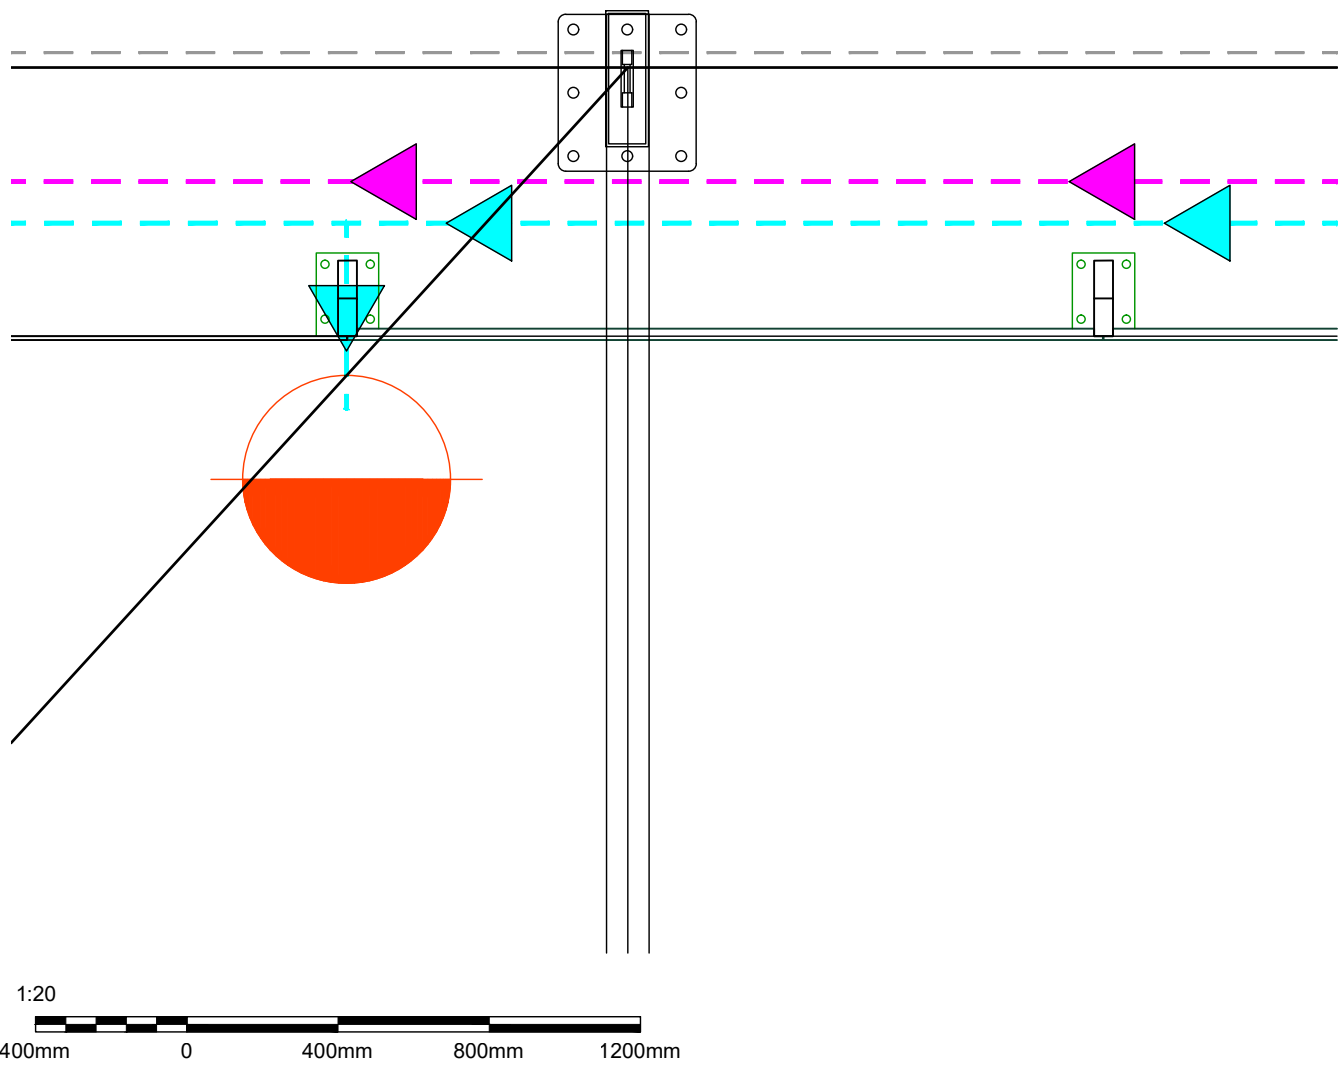

03 DETAIL B
1:5

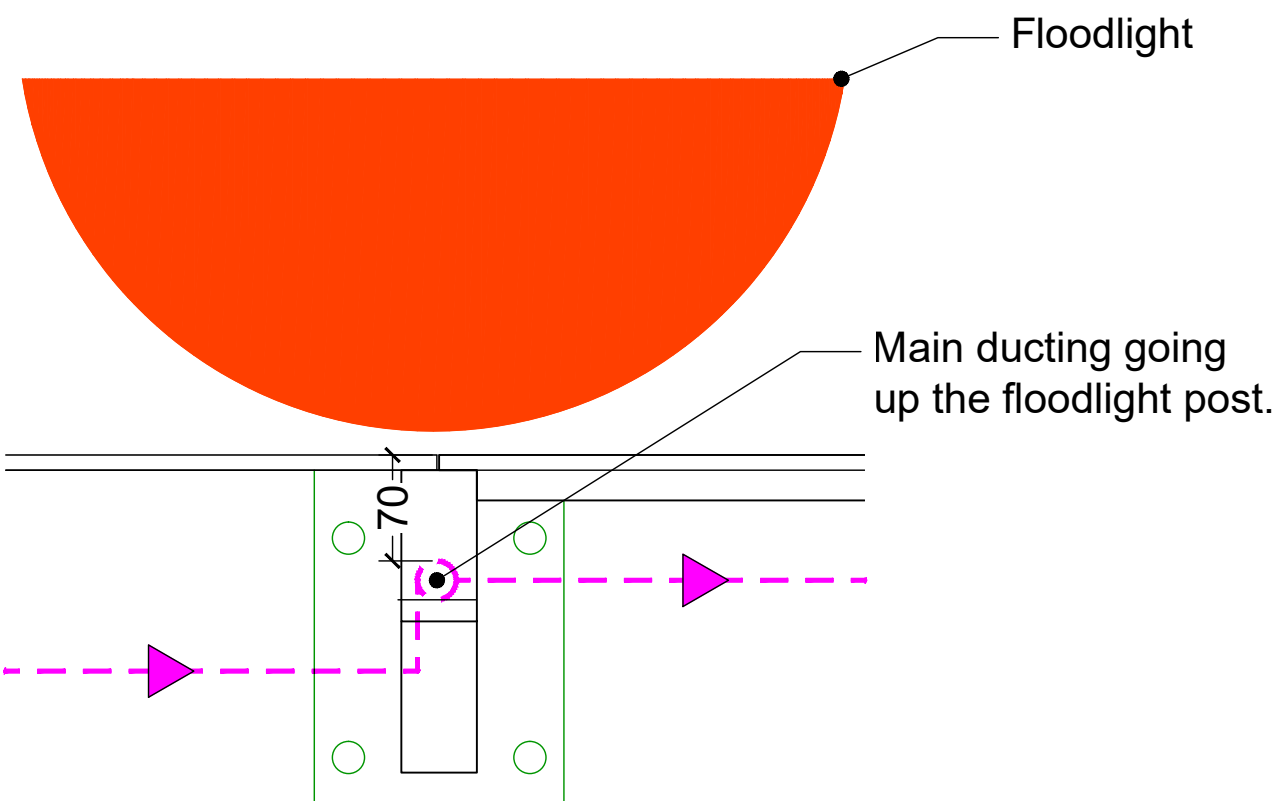

REV:	DESCRIPTION:	BY:	DATE:
STATUS:			
CLIENT:	The Northern LTC		
SITE:	The Northern LTC		
TITLE:	ELECTRICAL PLAN		
SCALE:	DATE:	DRAWN:	CHECKED:
As noted @A1	12.06.23	AC	LS
PROJECT No:	DRAWING No:	REVISION:	
2011-04	011	A	

PADELTECH

Head office
Unit 12, 4-5 Lochside Way, Edinburgh, EH12 9DT
+44(0)131 581 8683
Southern office
Suite 3, Lake View House, Wilton Drive, Tournament Fields,
Warwick, CV34 6RG
+44(0)1926 679 586