


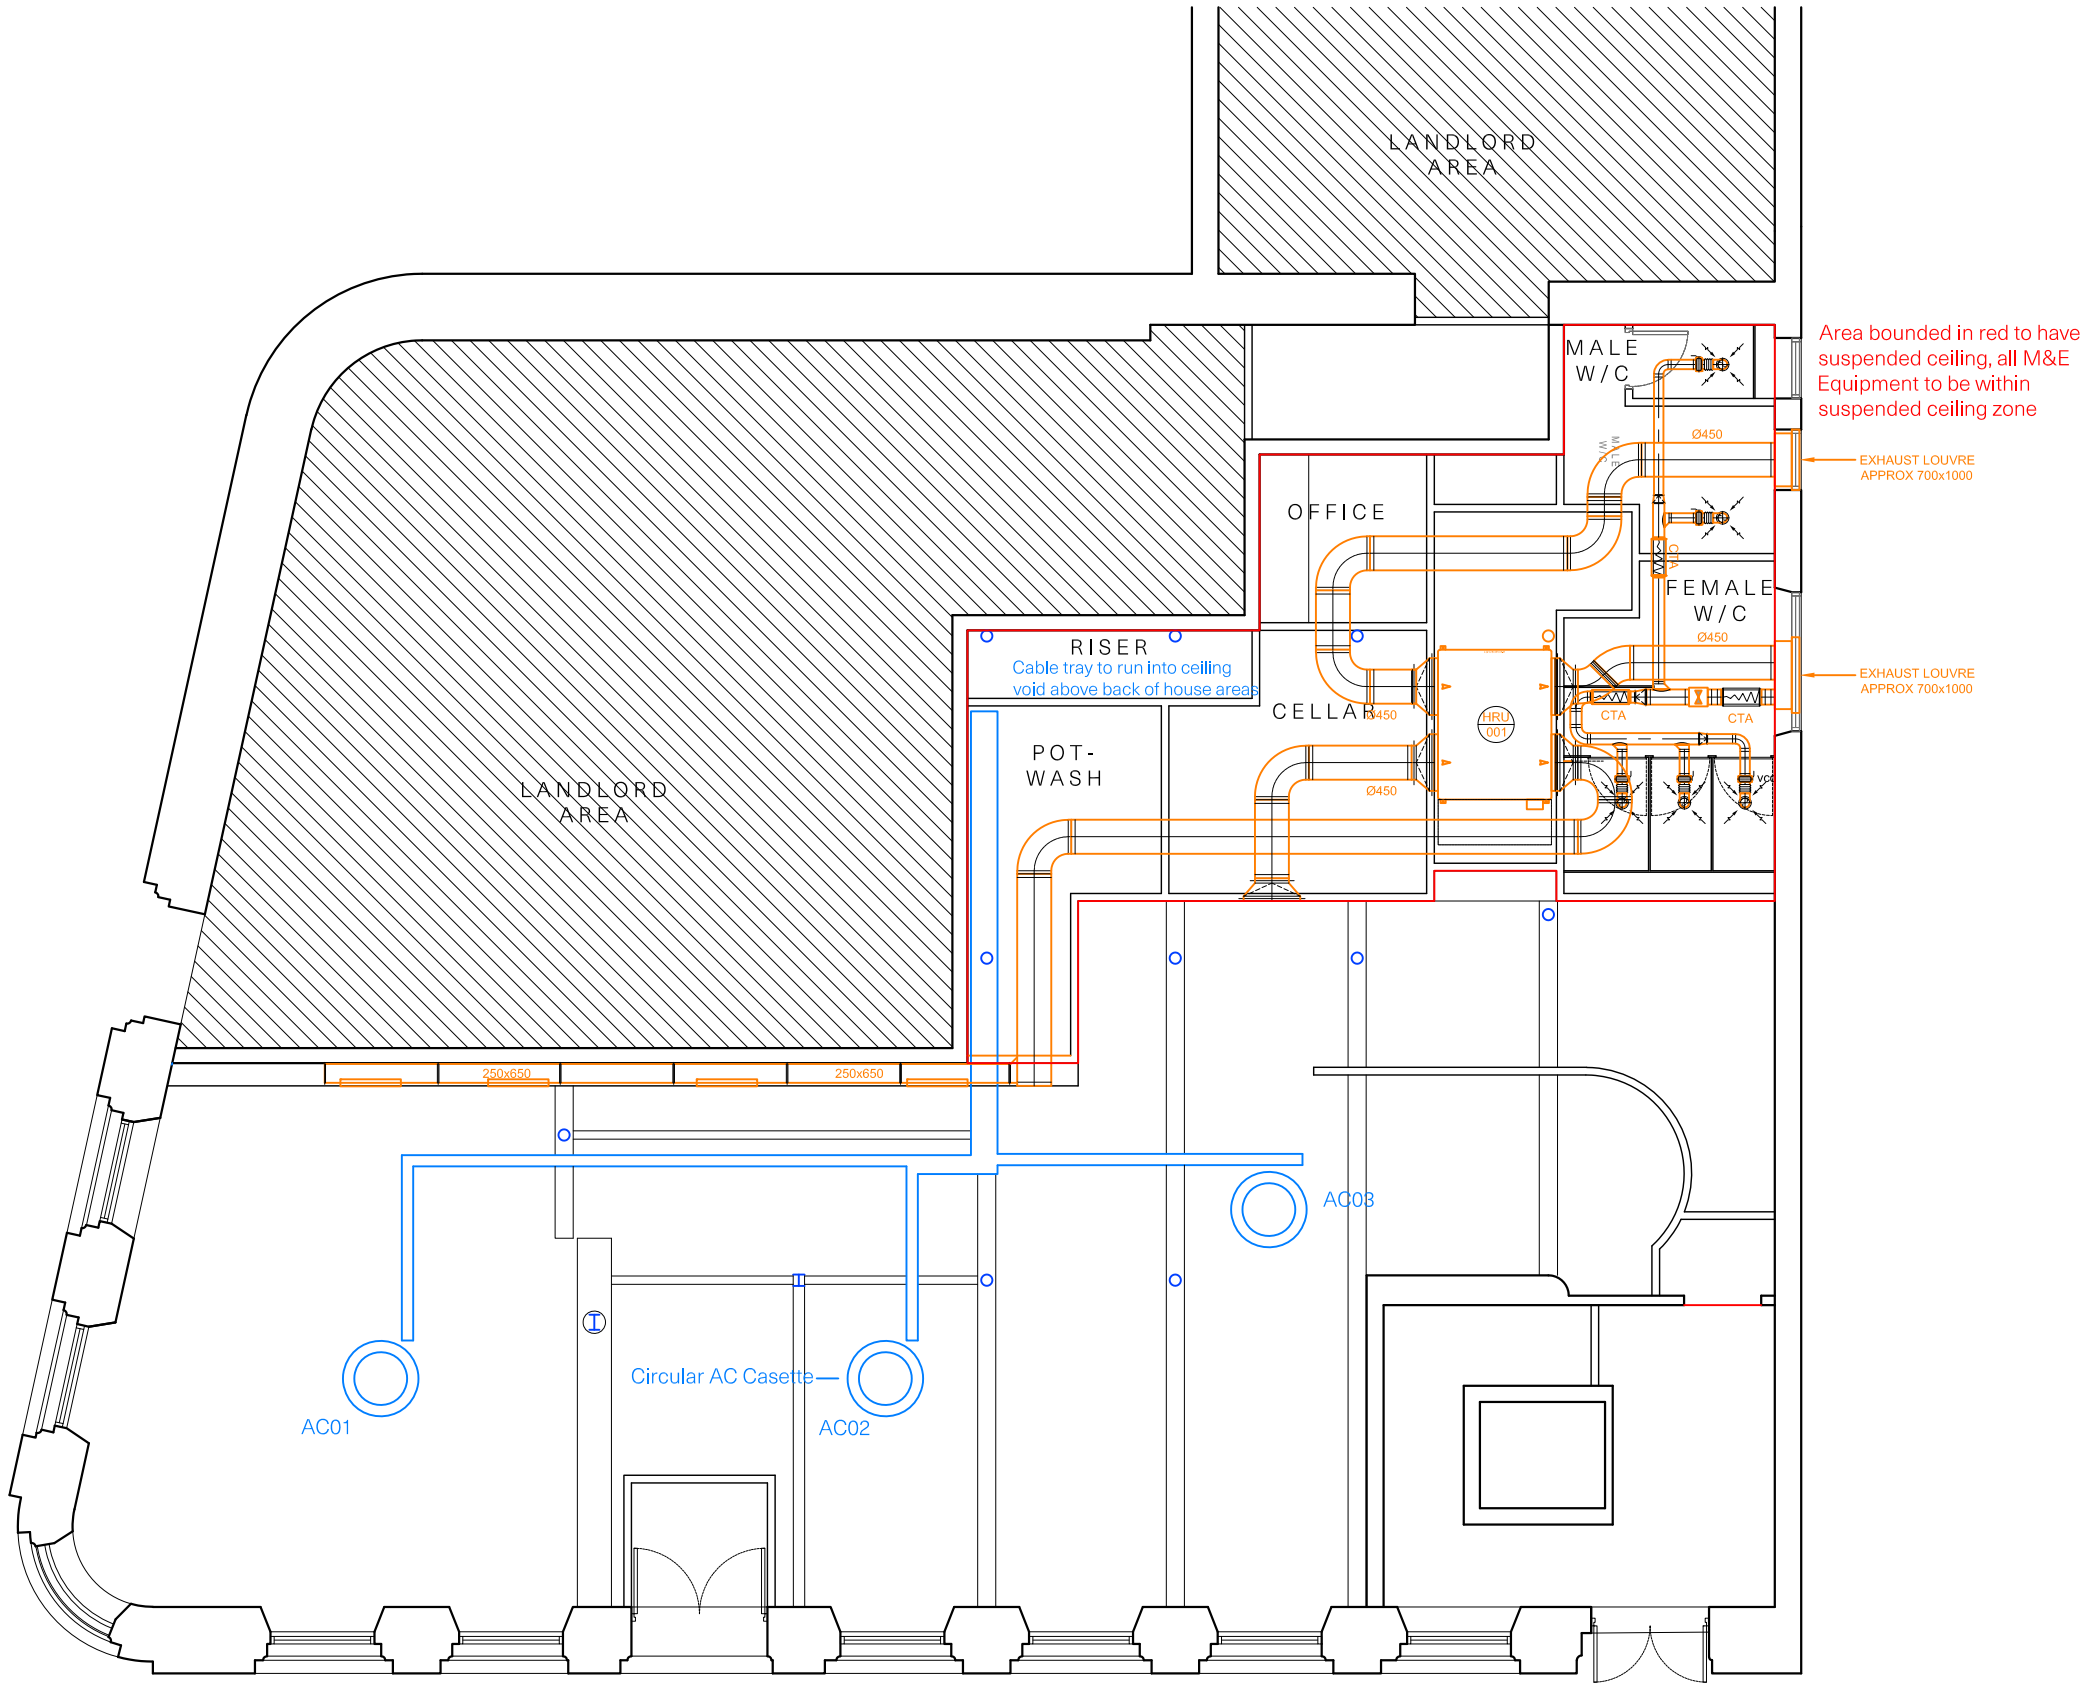

Area bounded in red to have
suspended ceiling, all M&E
Equipment to be within
suspended ceiling zone

EXHAUST LOUVRE
APPROX 700x1000

EXHAUST LOUVRE
APPROX 700x1000

RISER
Cable tray to run into ceiling
void above back of house areas

Circular AC Cassettes


All dimensions are to be checked on site, any discrepancies are to be reported to the Architect before work commences. Do not scale from this drawing.

This drawing is to be read in conjunction with all relevant consultants and specialists drawings / documents, any discrepancies are to be reported to the Architect before the affected work commences.

All structural components shown are indicative only. Details / calculations of structural members are to be provided by the Structural Engineer.

THIS DRAWING NOT FOR CONSTRUCTION

Revisions

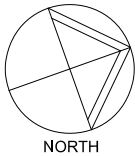

Project, location
North-Westward Ho!, Pall Mall

RIBA Workstage
3 - Spatial Coordination

Drawing purpose
For Information

This drawing copyright 2020 by Up North Architects Ltd. and is licensed to the client for the purposes related to the RIBA work stage above only

Up North Architects

Up North Architects Ltd. Plane Tree House, Oldham Street, Manchester UK M1 1JG
Company No. 10437056 TEL: 0161 237 1871 E-MAIL: mail@upnortharchitects.com

Client
Pomona

Drawing Title
M&E Reflected Ceiling Plan

Job No.
M867

Drawing no.
084

Revision
-

Scale
1:100 @ A3

Date
Apr 2023