


Last saved by: R:\ORD\2021-07-21 - Last Plotted: 2021-07-21
Filename: C:\USERS\R\ORD\HEC\HURSTWOOD\FILESTORE - CURRENT PROJECTS\PROJECTS\C3666 - 27 TRENCHARD DRIVE\C3666-57 SERIES-MECH (REV A).DWG

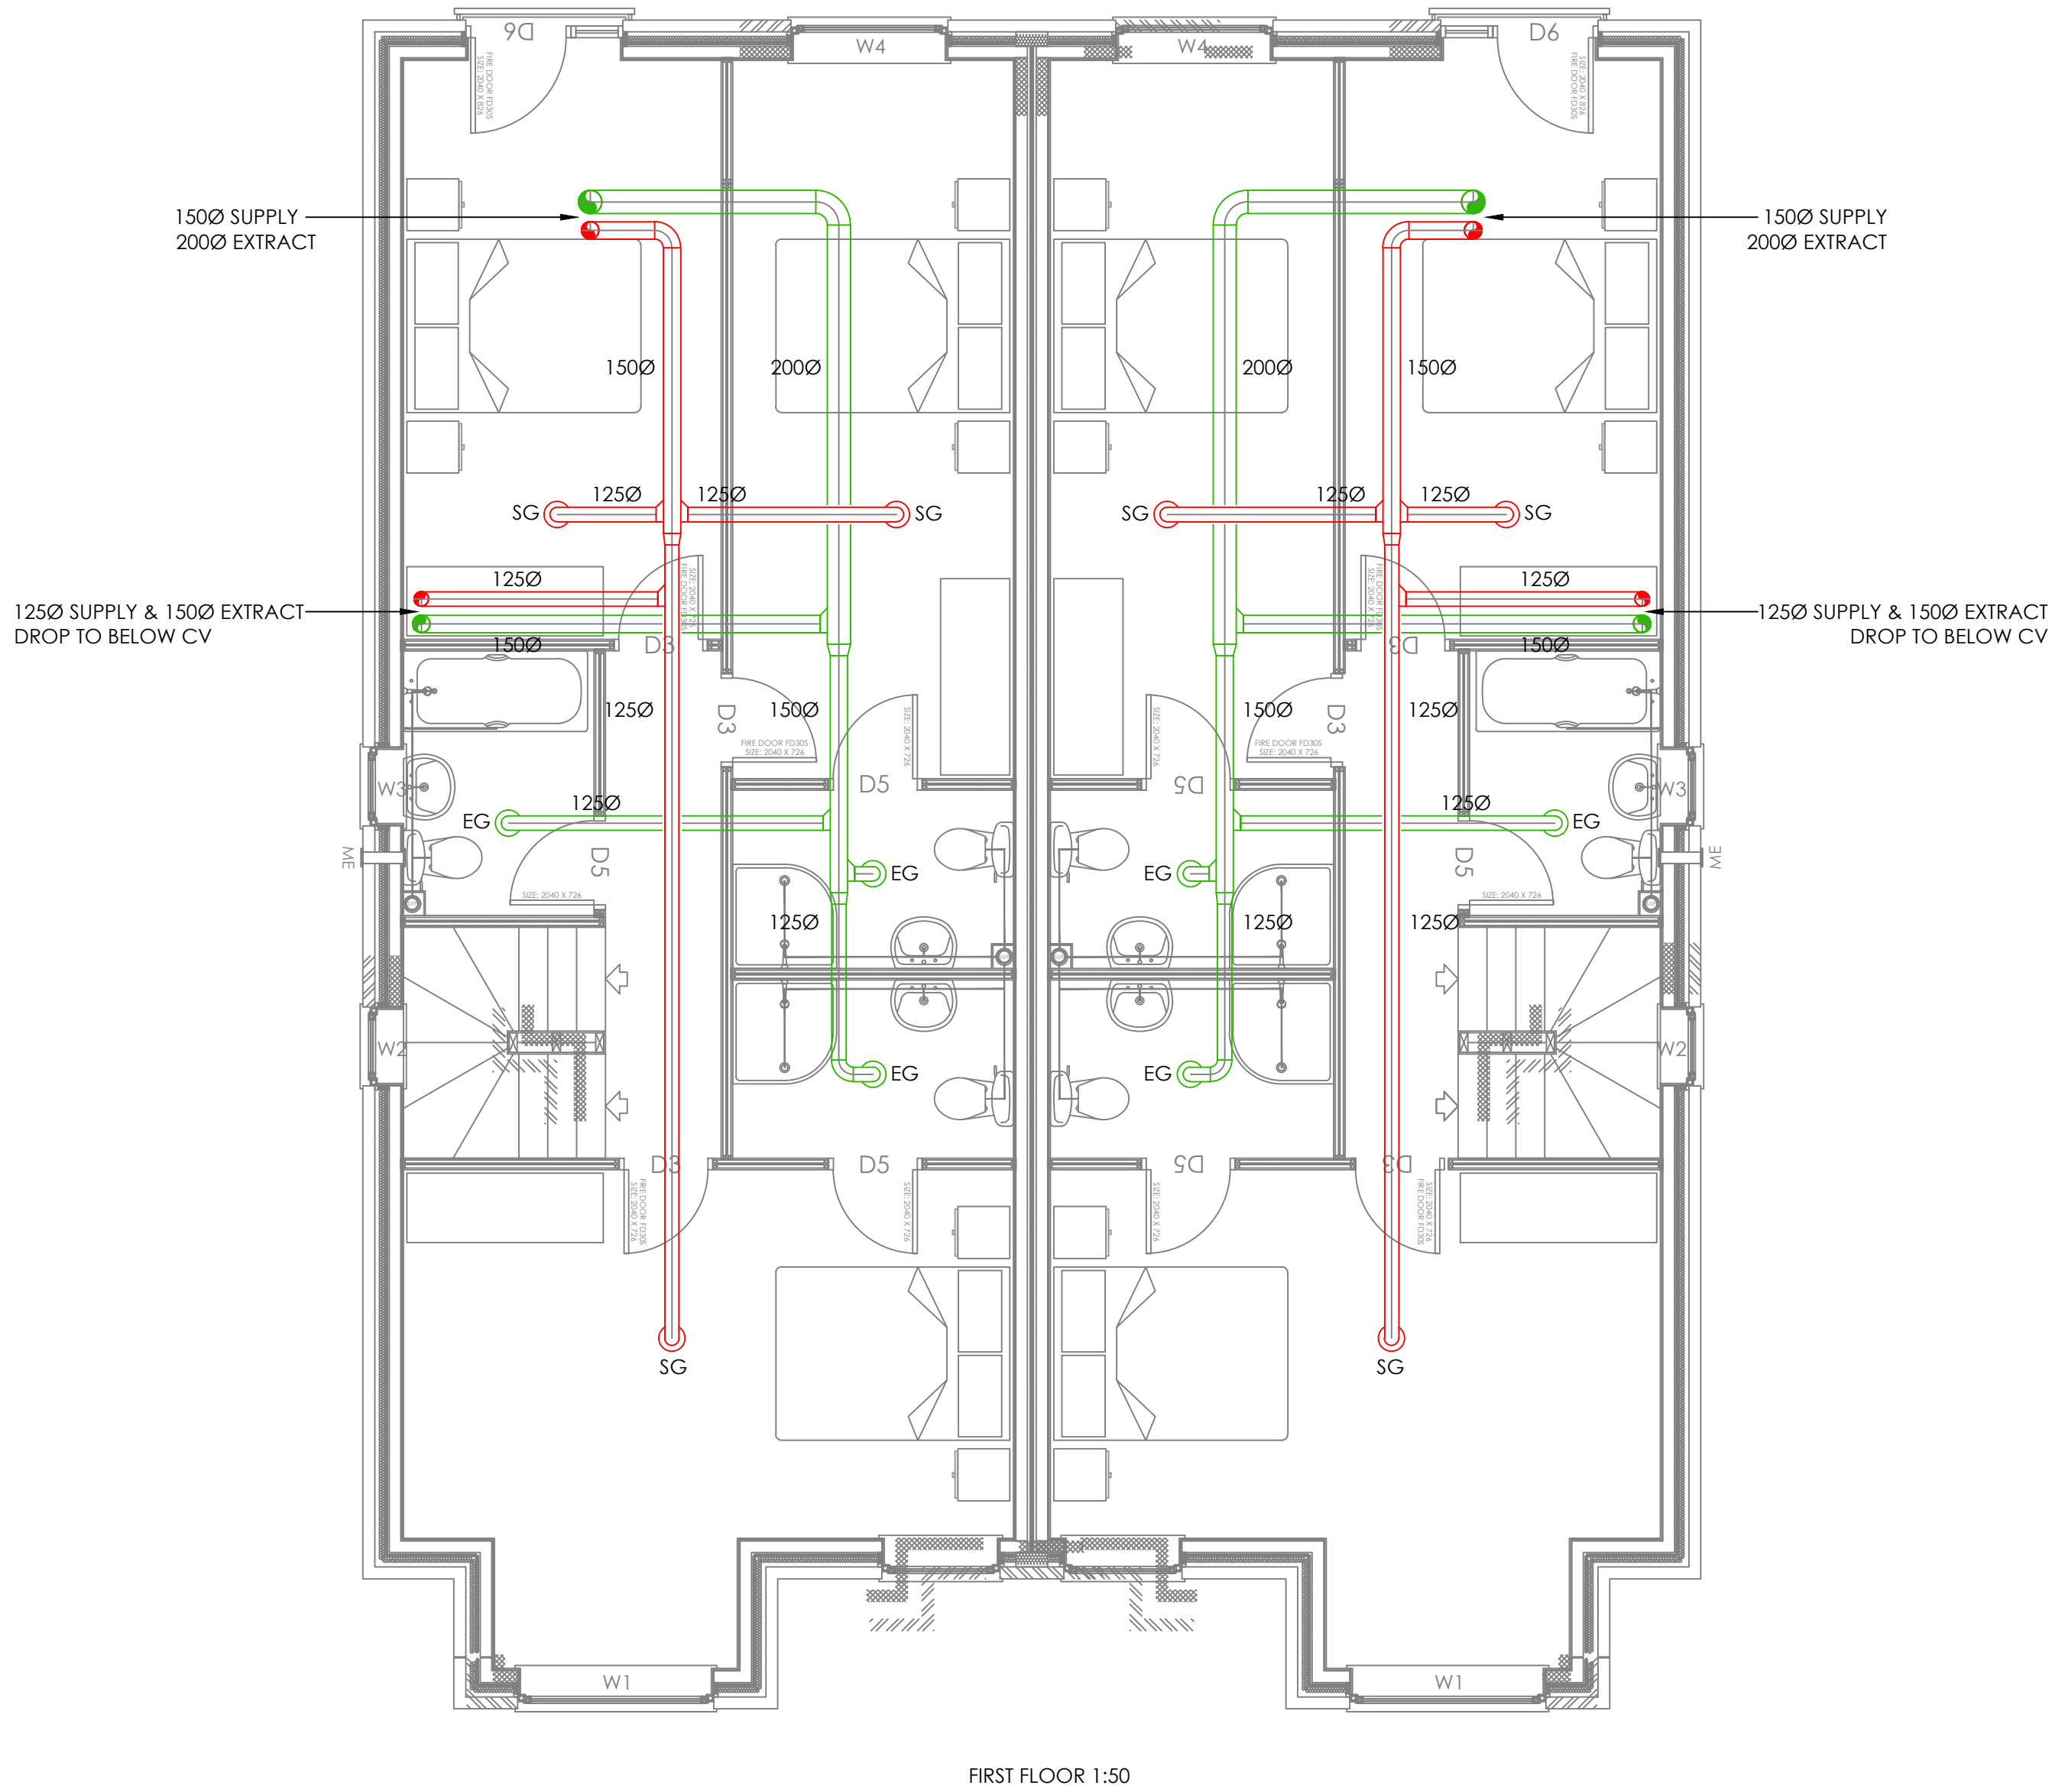



consultancy engineering business environment
member




ISO 9001:2015
Certified to Standard



Constructionline

© This drawing is copyright protected, and remains the property of hurstwood environmental consulting, it must not be reproduced, used, disclosed or transmitted to third parties in any form without prior written permission.

- VENTILATION NOTES
- ALL MVHR DUCTWORK SHALL BE MANUFACTURED IN RIGID PLASTIC & ALL MVHR DUCTWORK SHALL BE MANUFACTURED IN RIGID PLASTIC & IN ACCORDANCE WITH THE DOMESTIC VENTILATION COMPLIANCE GUIDE.
 - MVHR UNIT IS TO RUN AT CONTINUOUS TRICKLE WITH BOOST BEING MVHR UNIT IS TO RUN AT CONTINUOUS TRICKLE WITH BOOST BEING ACTIVATED VIA AN INTERNAL BOOST HUMIDISTAT.
 - ALL AIR VALVES SHALL BE 125mm. ALL AIR VALVES SHALL BE 125mm.
 - FIRE SLEEVES SHALL BE PROVIDED WHERE DUCTWORK PASSES FIRE SLEEVES SHALL BE PROVIDED WHERE DUCTWORK PASSES THROUGH ANY FIRE RATED STRUCTURE.
 - FLEXIBLE DUCTWORK SHALL BE USED FOR FINAL CONNECTIONS ONLY. FLEXIBLE DUCTWORK SHALL BE USED FOR FINAL CONNECTIONS ONLY. FLEXIBLE DUCTWORK SHALL BE MORE THAN 500mm IN LENGTH. FLEXIBLE DUCTWORK SHALL BE ACOUSTIC TYPE ON MVHR CONNECTIONS.
 - THE DUCTWORK SUB-CONTRACTOR SHALL PROVIDE AN INSULATED THE DUCTWORK SUB-CONTRACTOR SHALL PROVIDE AN INSULATED PLENUM BOX TO ALLOW FOR TRANSFORMATION OF THE RIGID PLASTIC DUCTWORK TO THE EXTERNAL LOUVER.
 - THE DUCTWORK SUB-CONTRACTOR SHALL ALLOW FOR A VISUAL SITE THE DUCTWORK SUB-CONTRACTOR SHALL ALLOW FOR A VISUAL SITE SURVEY OF THE BUILDING STRUCTURE PRIOR TO FABRICATION OF DUCTWORK.
 - THERMAL INSULATION SHALL BE APPLIED TO THE FOLLOWING AREAS: INTAKE AND EXHAUST DUCTWORK.
 - BATHROOM / WC DOORS SHALL BE UNDERCUT TO PROVIDE BATHROOM / WC DOORS SHALL BE UNDERCUT TO PROVIDE VENTILATION AIR PATH ROUTES.

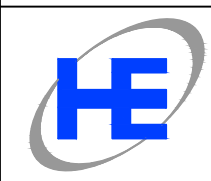T2	RJ	21.07.21	TENDER ISSUE		
T1	RJ	15.07.21	TENDER ISSUE		
REV	CHK	DATE	DESCRIPTION		
Architectural X-Ref Drawings:					
FF&E X-Ref Drawings:					
Drawing Status:		STAGE 3 - TENDER			
 hurstwood environmental Consulting Engineers www.hurstwood-eng.co.uk ■ Bolton Office Altra Spa Road Bolton BL1 4AG T: 01204 770 041 E: bolton@hurstwood-eng.co.uk □ Liverpool Office 23 Goodlass Road Speke Liverpool L24 9HJ T: 0151 728 3360 E: liverpool@hurstwood-eng.co.uk □ London Office 344 Gray's Inn Road Bloomsbury London WC1X 8BP T: 0203 755 3711 E: london@hurstwood-eng.co.uk					
Drawn: R JORDAN		Chkd: P CHAMBERS	App: P CHAMBERS		
Date: JAN 2021		Scale: 1:50			
Client:					
HOWARD AND SEDDON					
Project:					
27 TRENCHARD DRIVE					
Drawing Title:					
VENTILATION LAYOUT PLOT 3&4 FIRST FLOOR					
Project No:			Rev:		
C3666-HEC-DR-FF-M-5702			T2		