
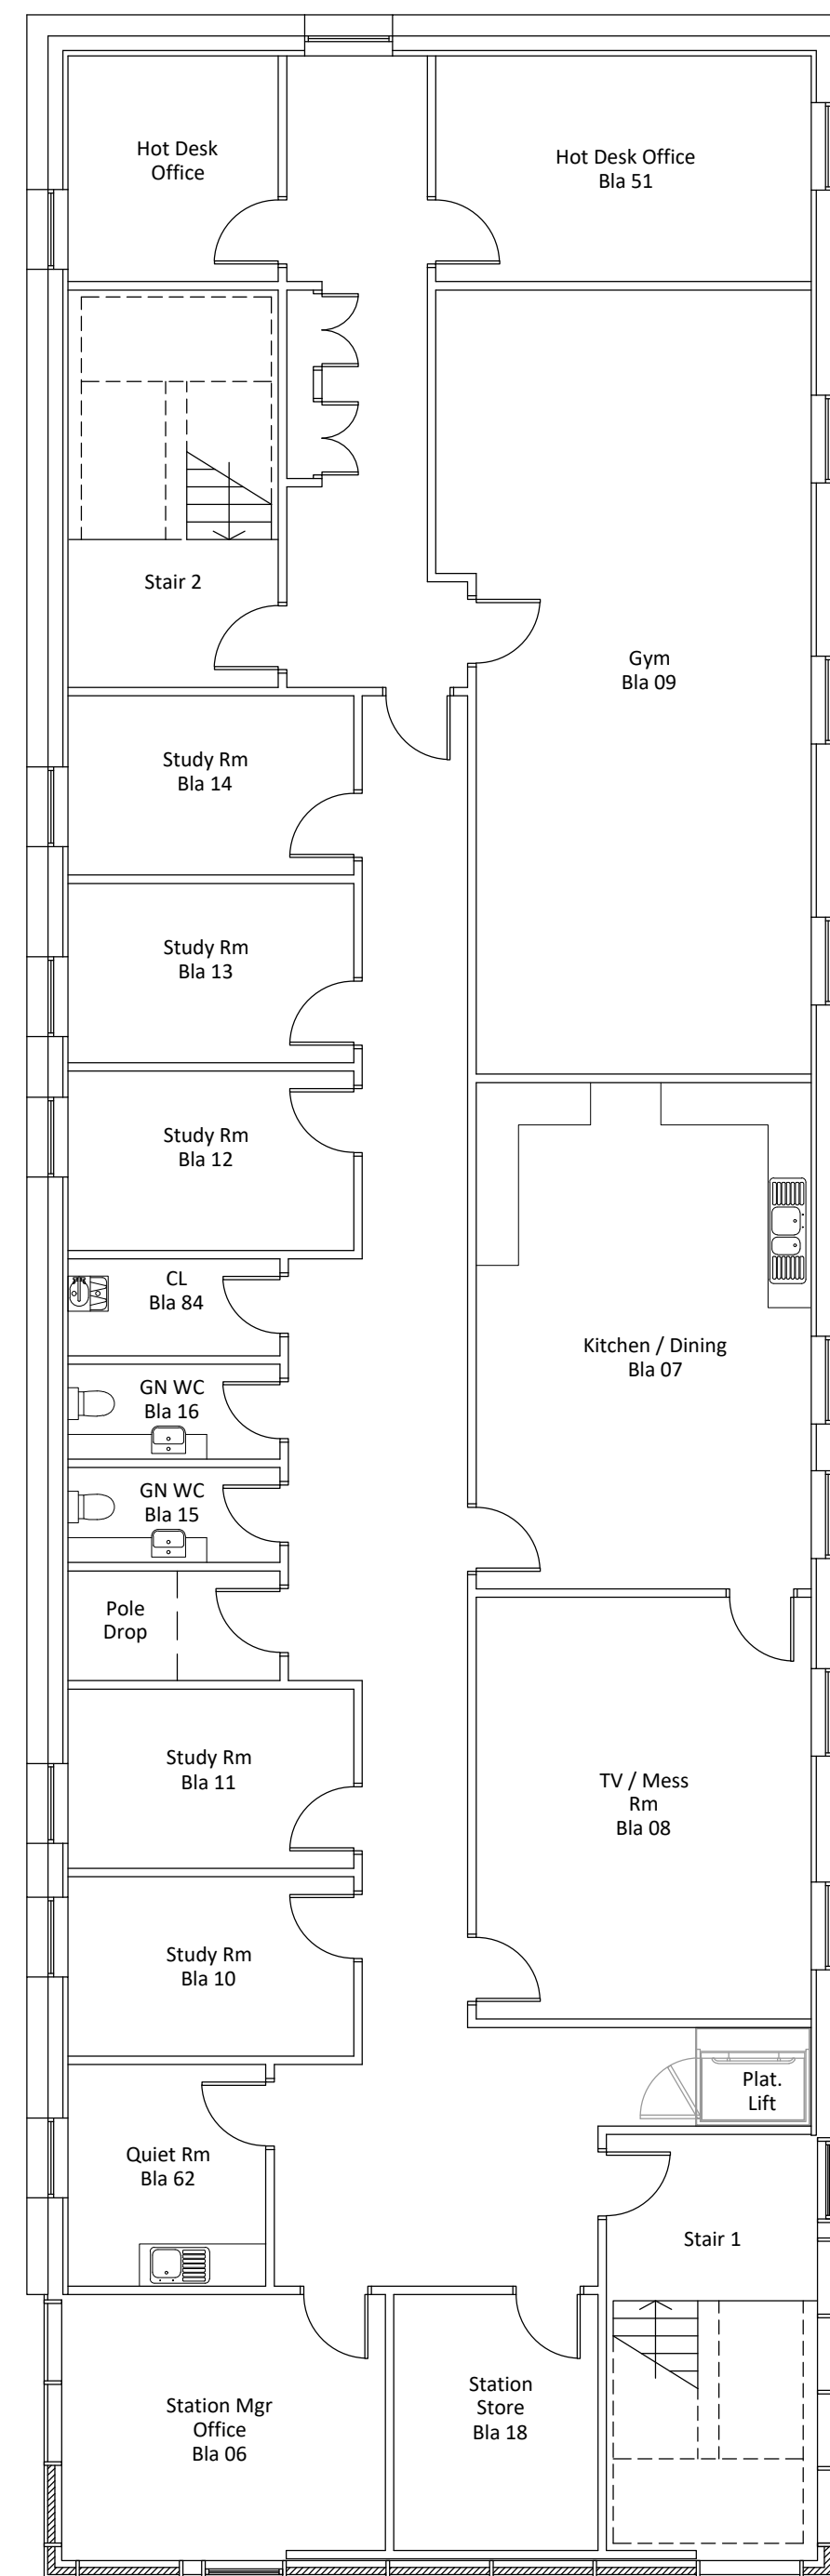


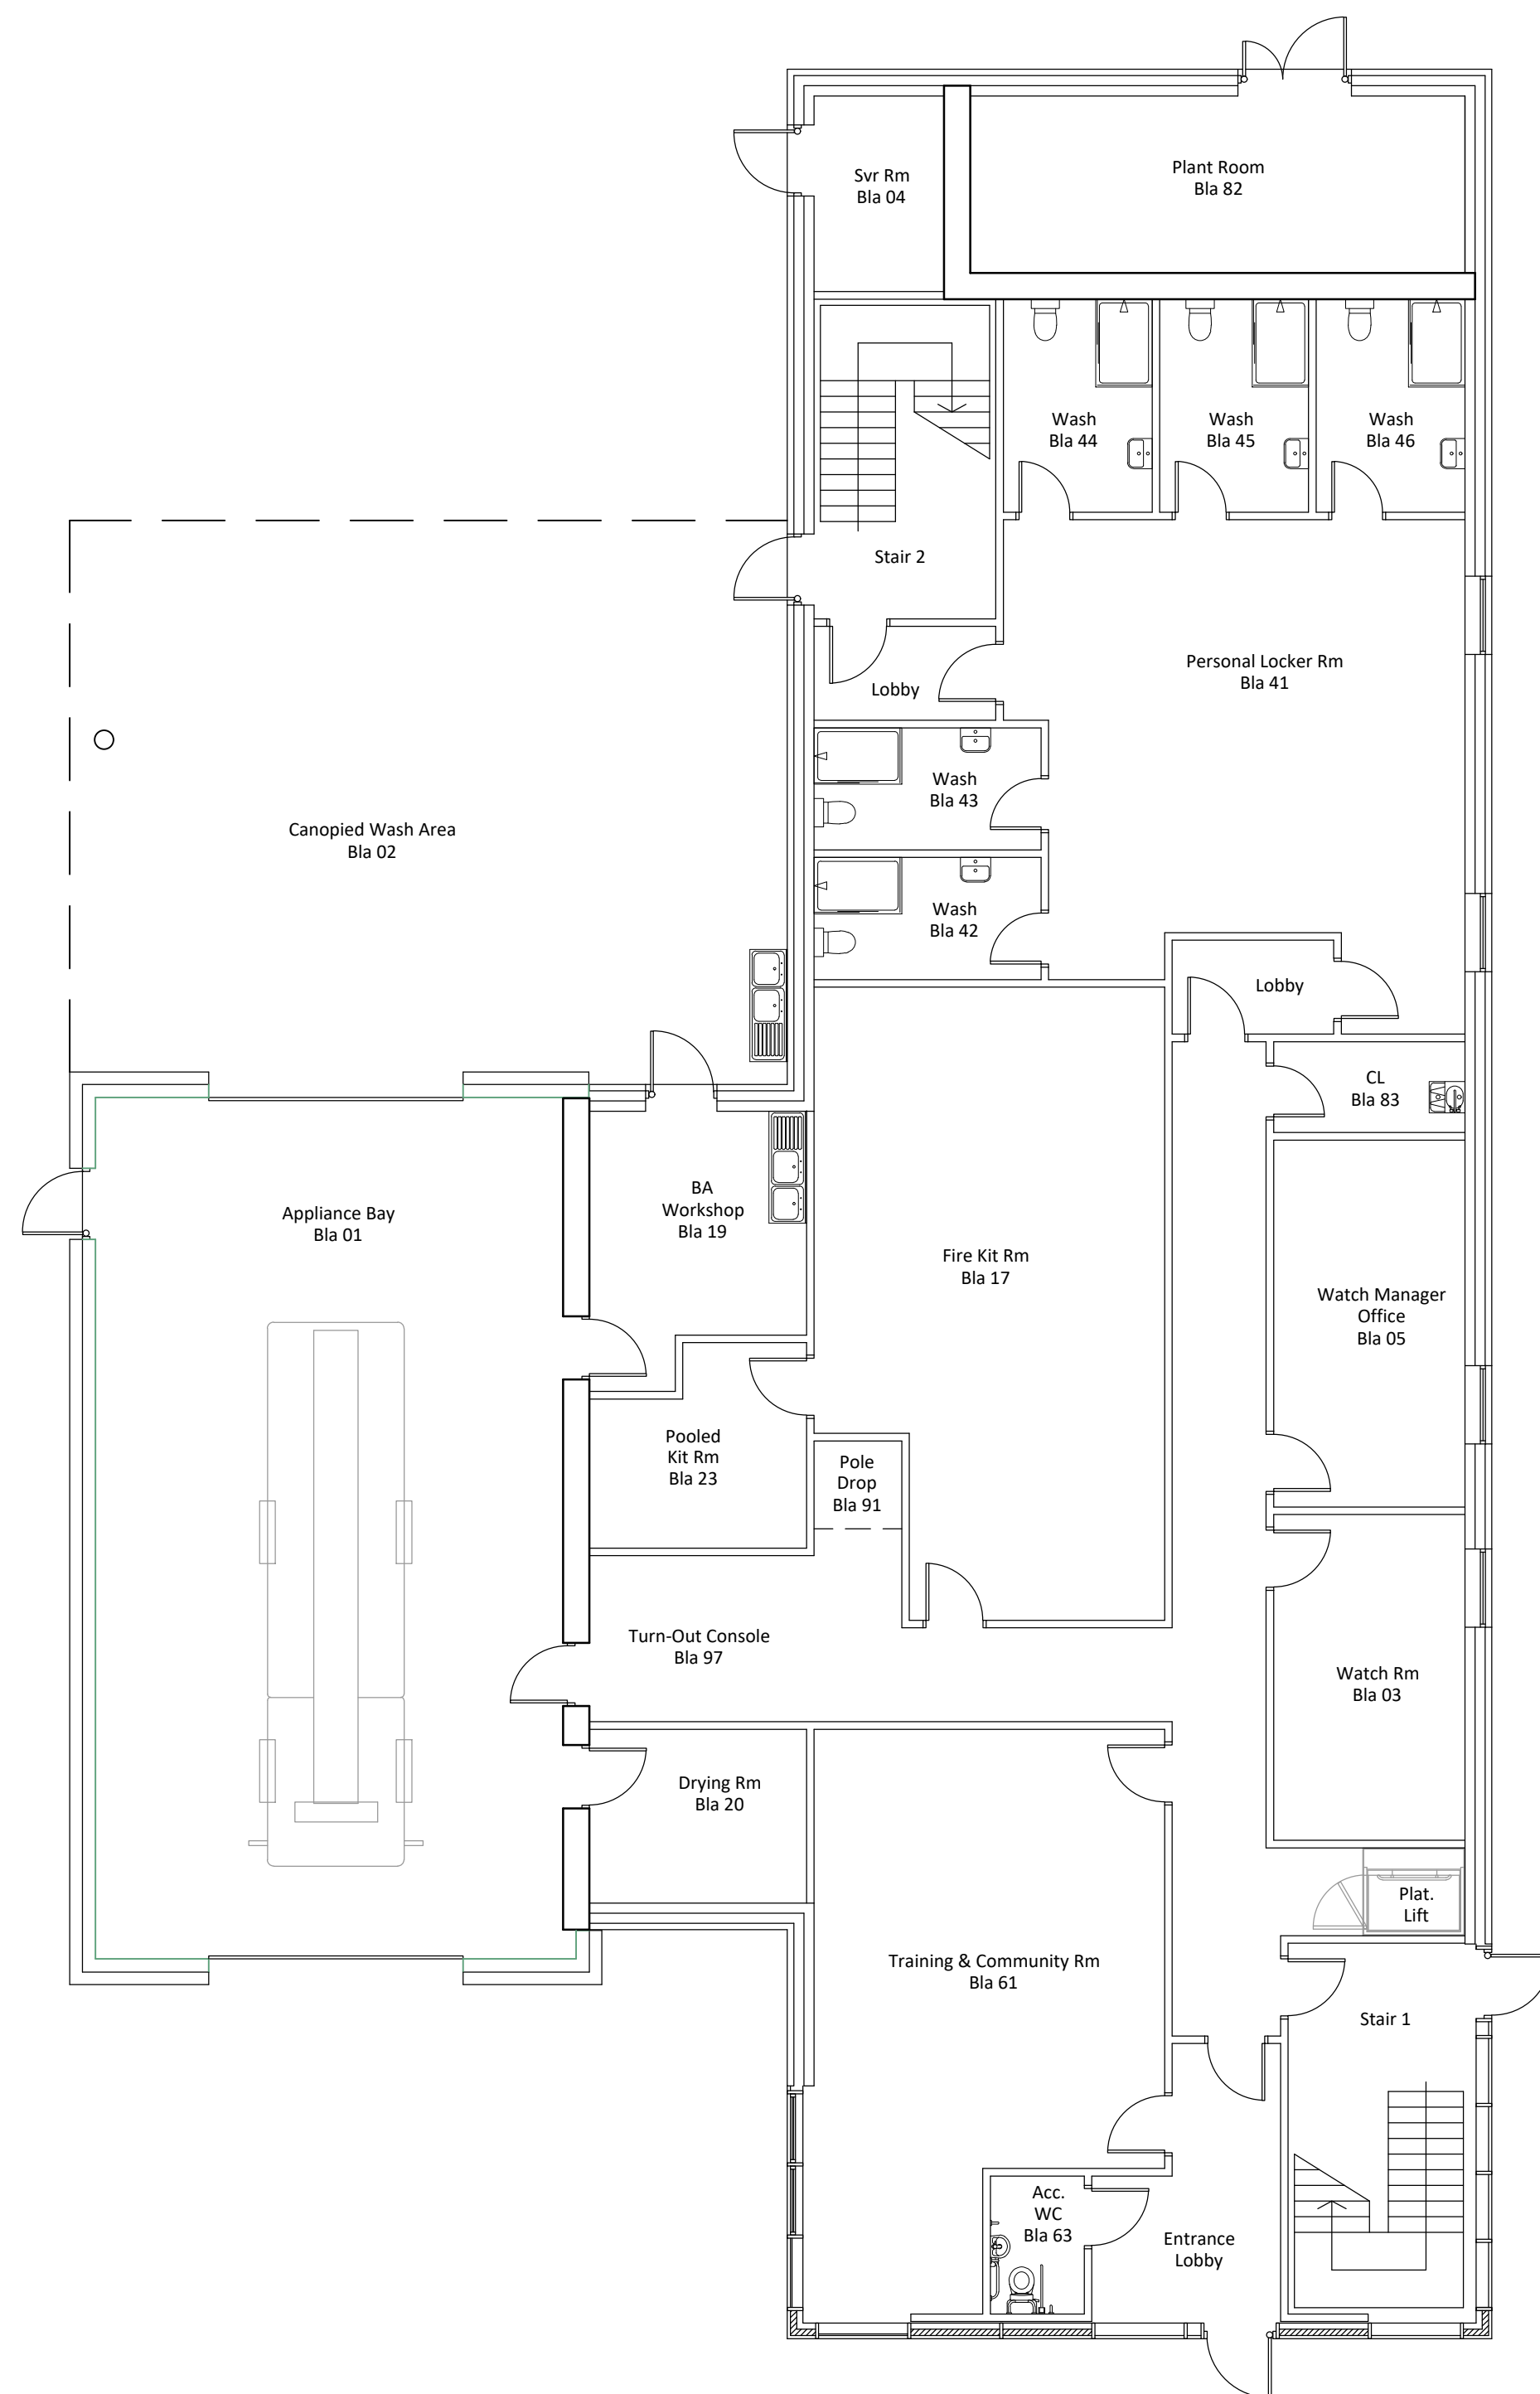

status

PLANNING

This drawing is ©Bradshaw Gass & Hope LLP and is not to be copied, reproduced or re-distributed either in whole or in part without the prior written permission of the originator.

The originator shall have no responsibility for any liability, loss, cost, damage or expense arising from or relating to any use of this document other than for its intended purpose on this project.

This drawing shall be read in conjunction with all other relevant drawings, specifications and associated documentation. Any discrepancies, errors or omissions are to be reported to the originator before proceeding with work.

All dimensions are to be checked on site by the contractor prior to proceeding with any work.

Hazard Identification		
ref	hazard	date

P3	PLANT ROOM / SERVER ROOM ADJUSTED. WINDOW TO HOT DESK OFFICE MOVED TO SIDE WALL.	ST	12.04.23
P2	PLANS UPDATED TO REFLECT LATEST ADJUSTMENTS / DEVELOPMENT	ST	29.03.23
P1	FIRST ISSUE	ST	07.10.22
ref	revision	by	date



Architects
Consulting Engineers
Quantity Surveyors

21 Silverwell Street
Bolton
BL1 1PR
t: 01204 525321
email@bghbolton.co.uk
www.bghbolton.co.uk

Bradshaw Gass & Hope LLP

client		GREATER MANCHESTER COMBINED AUTHORITY	
project		NEW FIRE STATIONS FEASIBILITY STUDIES	
drawing		BLACKLEY FIRE STATION PROPOSED FLOOR PLANS	
drawn by	ST	date	MAR 23
checked by		date	
scale	1:100		A1
dwg no	1978.35.1352		rev P3