


SHIP CANAL HOUSE, MANCHESTER

GROUND FLOOR - PROPOSED CEILING LAYOUT

This drawing is the property of **bluesky** Design and must not be copied or otherwise reproduced. All dimensions must be checked on site before commencing work. This drawing was produced using AutoCAD 2019.

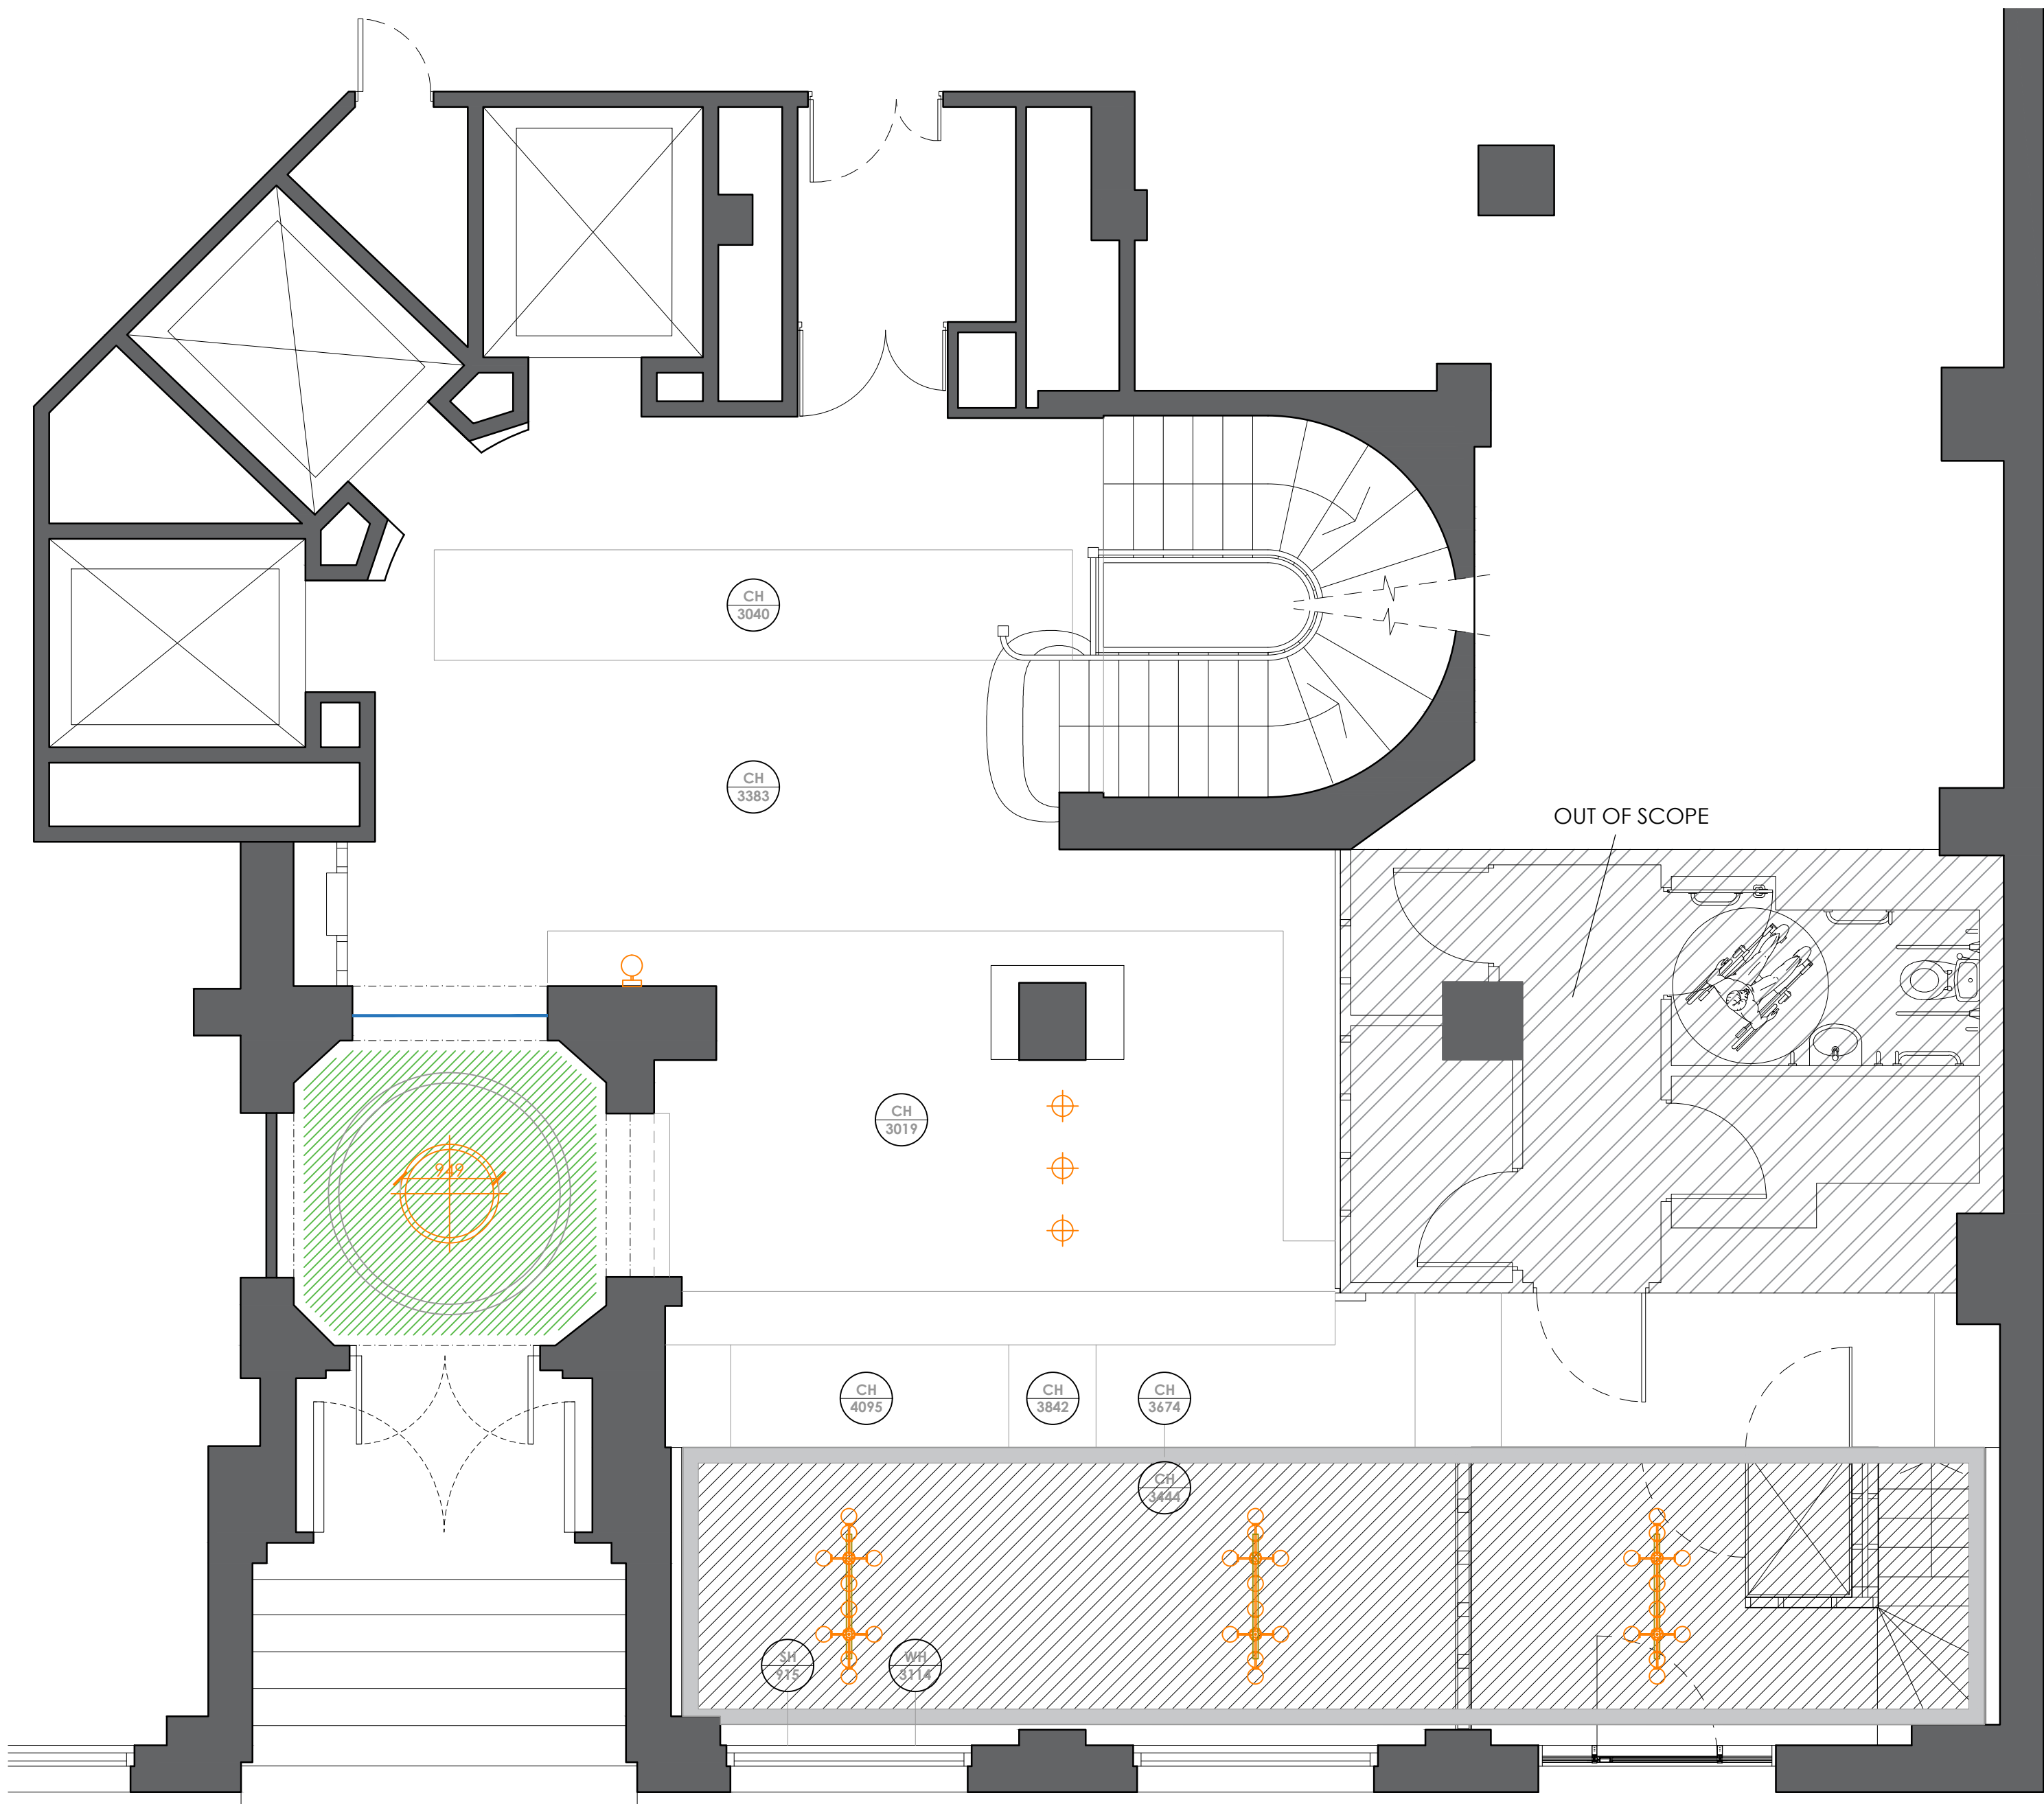


LIGHTING KEY



TYPE 1. ENTRANCE LOBBY PENDANT
Superloop Slim Out 90 SBL 930 GC (in Gold) by DeltaLight.
www.deltalight.com Light Suspension height TBC on site.
Size: 949mm Diameter Ref: 20577 9300GC
With a central rose suspension option



 TYPE 2. 3 X PENDANTS OVER RECEPTION
'TR Bulb' pendant light by Menuspace-Brass Matt Globe.
Reference: SKU 1493939 www.menuspace.com
Light Suspension height TBC on site. Size 200mm Diameter



TYPE 3. 3 X LINEAR CHANDELIER OVER WAITING AREA
'Trevi Multi 10' suspended light by CTO. ctolighting.co.uk
Satin Brass with Matt Opal Glass
Light Suspension height TBC on site.




TYPE 4. 1 X WALL LIGHT
'Dali' wall light by Aromas Del Campo.
www.aromasdelcampo.com
Metal: **Aged Gold** / Marble: **Green** / Glass Shade: **Opal**
Light wall height TBC on site.


FEATURE LIGHTING SHOWN ONLY - ALL EXISTING LIGHTS TO BE CHANGED TO MATCH WITH A WARM WHITE. REPLACE LED STRIP LIGHTS AND RELAMP EXISTING RECESSED CEILING LIGHTS FOR FULL SPECIFICATION REFER TO M&E CONSULTANT DRAWING PACKAGE.

IMPORTANT NOTE
ANY ADDITIONAL SUPPORT OR PATRESSING REQUIRED WITHIN CEILING TBC BY STRUCTURAL ENGINEER & LIGHT MANUFACTURER PRIOR TO INSTALLATION

CEILING KEY

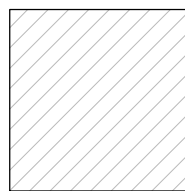

 Lowered Plasterboard bulkhead to painted Farrow & Ball- Elephants Breath No.229 Modern Matt Emulsion.
Paint sides to match - See 3D visuals in presentation



Existing Walnut panels to ceiling to be painted to match painted walnut side walls and lift surrounds - See DC-01 for reference

DECORATION NOTE:
ALL OTHER PLASTERBOARD CEILINGS AND DROPPED BULKHEADS TO PAINTED DULUX DIAMOND MATT EMULSION RAL 9010 WHITE

Rev	Date	Description	Initials
E	06.04.23	UPDATES FROM CLIENT MEETING	PB
D	16.03.23	NEW SCHEME DESIGN FOR COSTING	PB
C		NOT ISSUED CHANDELIER SPEC REVISED	ST
B	13.12.22	HERITAGE ISSUE	ST
A	05.12.22	SUSPENDED CEILING REPLACED WITH MF/PLASTERBOARD ISSUED FOR TENDER	ST

Client:	GROSVENOR
Project:	SHIP CANAL HOUSE CAT A REFURBISHMENT
Address:	KING STREET MANCHESTER
Drawing Title:	GROUND FLOOR CEILING & LIGHTING LAYOUT
Date:	07.12.2022
Project Number:	1308
Scale:	1:50@A1
Drawn by:	ST
Drawing Number:	1308-0G-CL-01E




TYPE 1



TYPE 2



TYPE 3

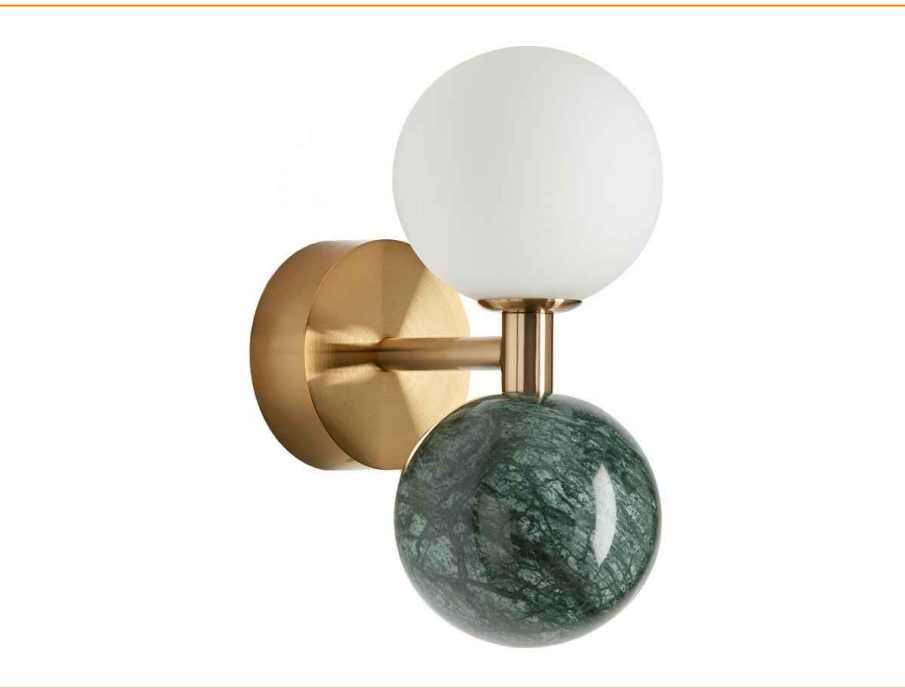

TYPE 4

FOR TENDER