



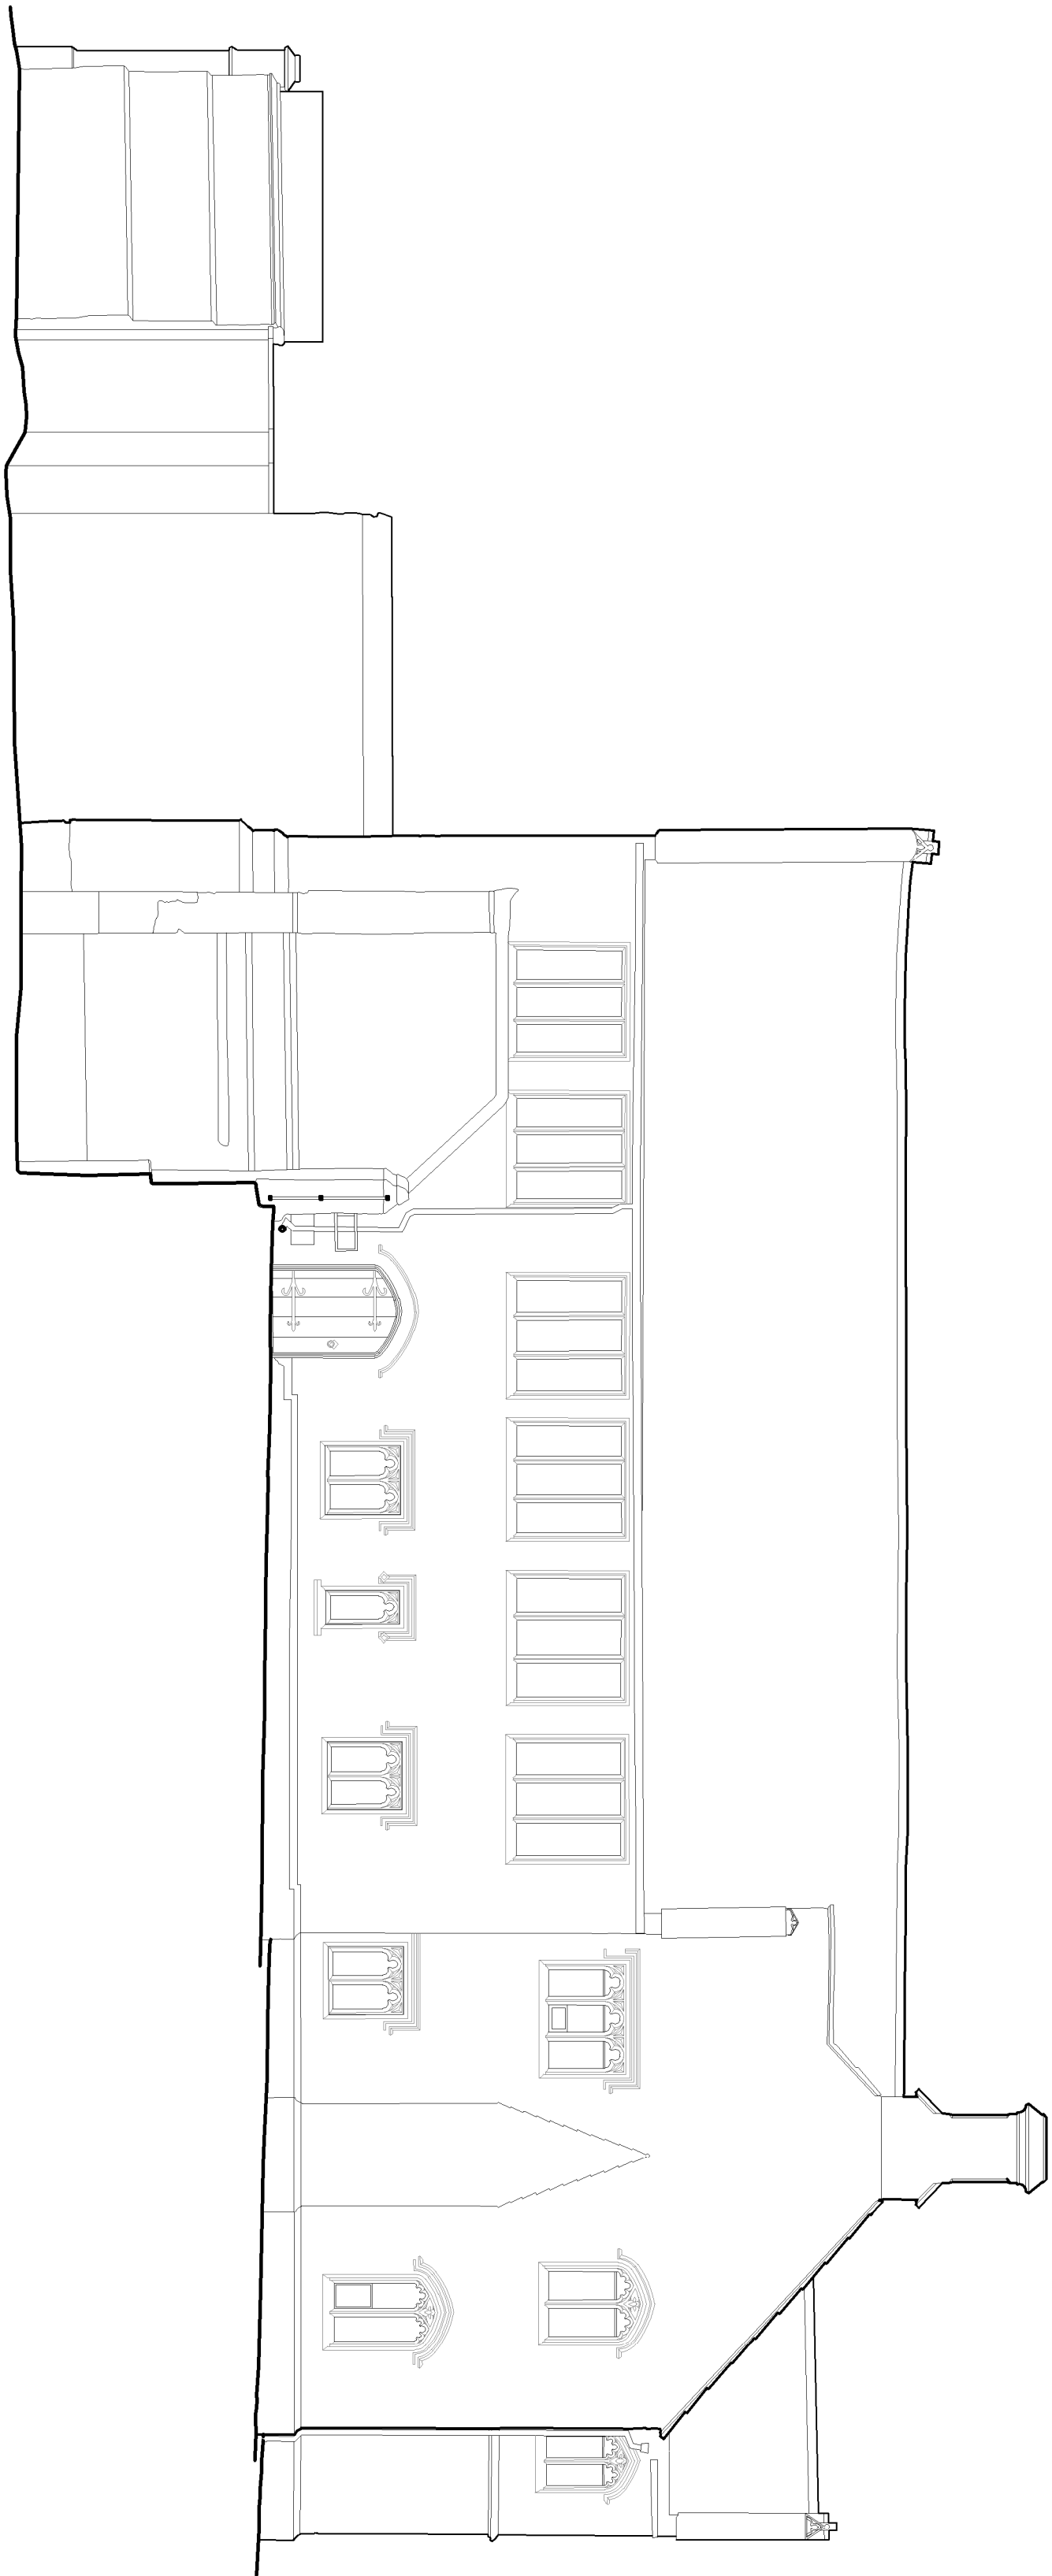

Library South Elevation 01

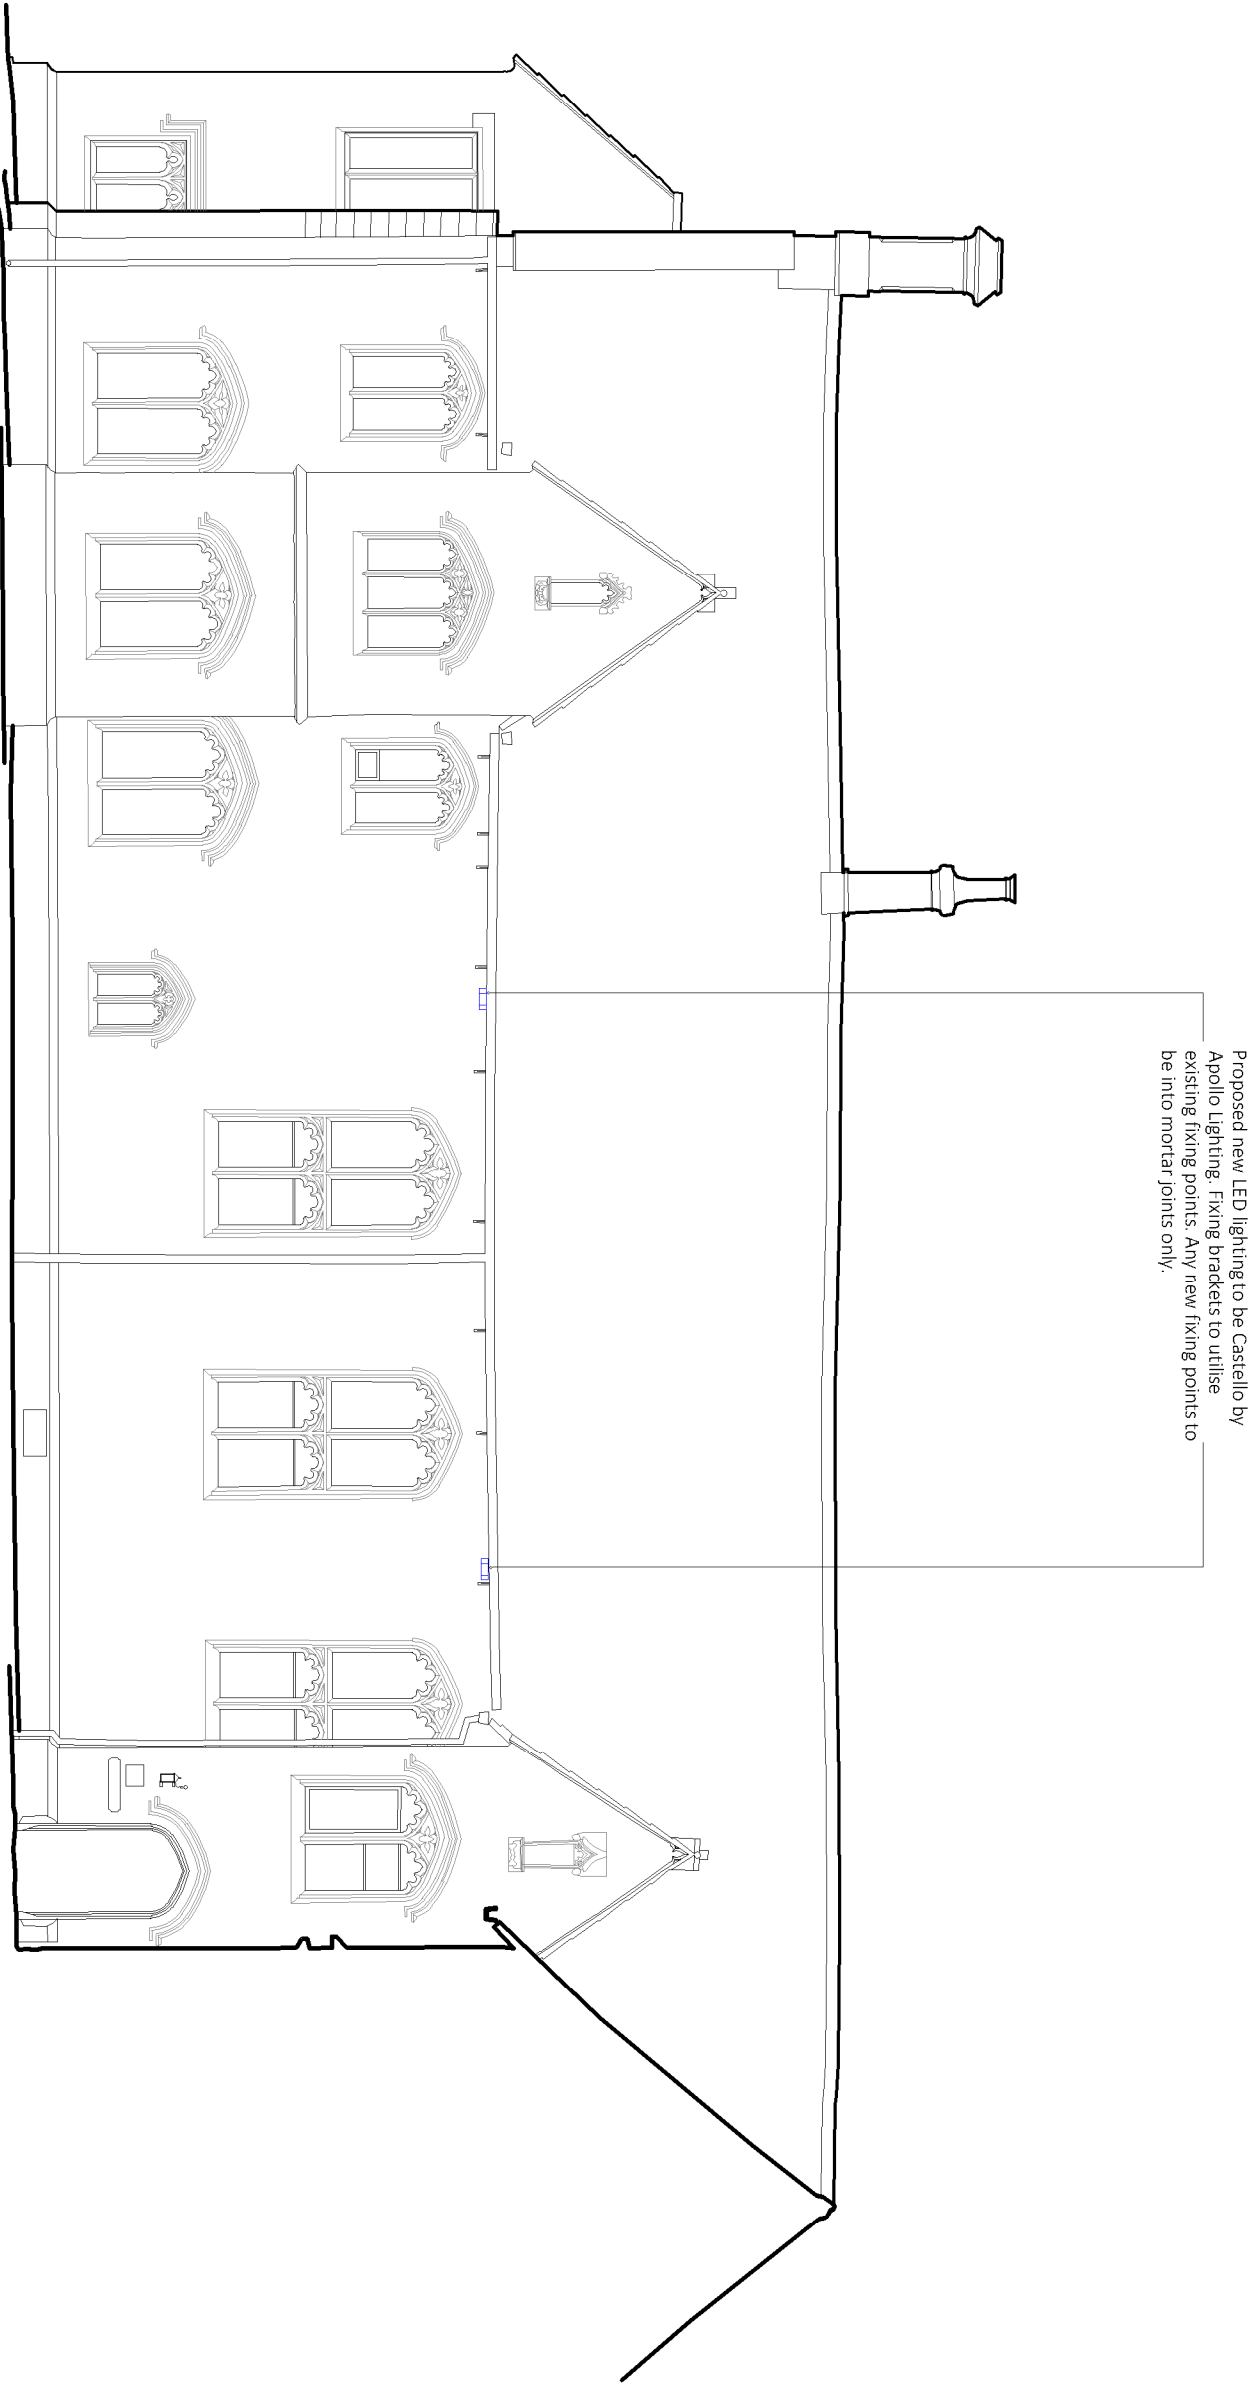

Proposed new LED lighting to be Caselle by Apollo Lighting. Fixing brackets to utilise existing mortar joints. Fixing points to be into mortar joints only.

Library East Elevation 02


Carefully remove existing 20th century smokeboats and associated metal brackets from all elevations. All work to be made good in lime-based mortar to match the existing and adjacent in every respect.

Remove existing 20th century halide lighting and replace with new LED lighting to be Caselle by Apollo's lighting. All electrical works to Service Engineer's specification and design.

Ensure existing rainwater goods meet the following requirements:

- Gutter - 100x75 outlet, 65mm

Where rainwater goods are less than this allow to replace in cast iron with all profiles and fixings to match the existing in every respect.

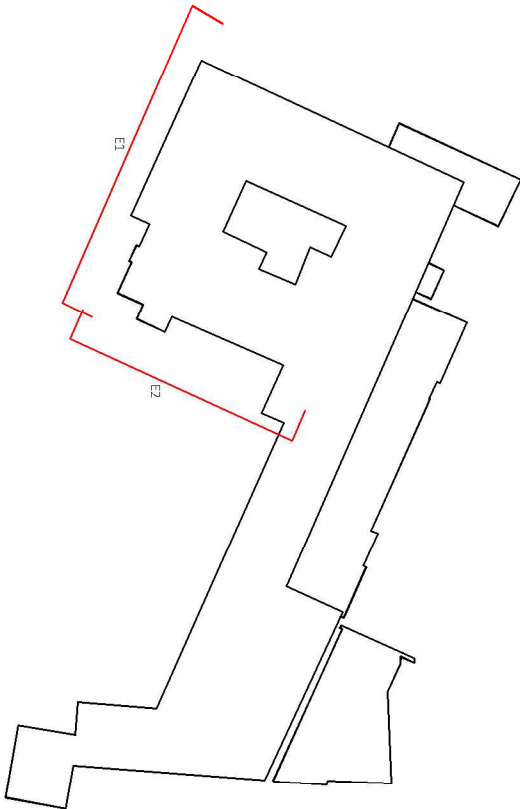

Key

Proposed works



Proposed new LED lighting - Apollo Caselle external floodlight

Proposed new external luminance to be installed at existing locations/fixing points. Any new fixings are to be into mortar joints only.

Specification:

Apollo Caselle external floodlight:

W : 283mm X H : 97mm X : 395mm

Rev DD/MM/YY Revision Details

Initial

Rev Date/note Details

© The most rights in this plan are reserved by the author. All rights reserved. No part of this plan may be reproduced without the author's permission. All rights reserved. If reproduced without the author's permission, the author will be held liable for any damages.

Buttress

41 Bengali St
41 Bengali St
M4 6AP
T 0161 236 3303
E contact@butress.net
W www.butress.net

Project Title CSM - College House

Client Chetham's School of Music

Location Manchester

Drawing Title Library South Elevation 01 and East Elevation 02

As Proposed

Date 19/10/22 Scale 1:100

Checked EK Orig Paper Size A1

State PLANNING

Project: Origin: Zone: Level: Type: Desc: Number: Rev:

9424 - BA - ZZ - ZZ - DR - A - (05)001 - -