



GENERAL NOTES

FOR GENERAL NOTES AND REFERENCE DRAWINGS SEE
DWG No. 100138-00350.

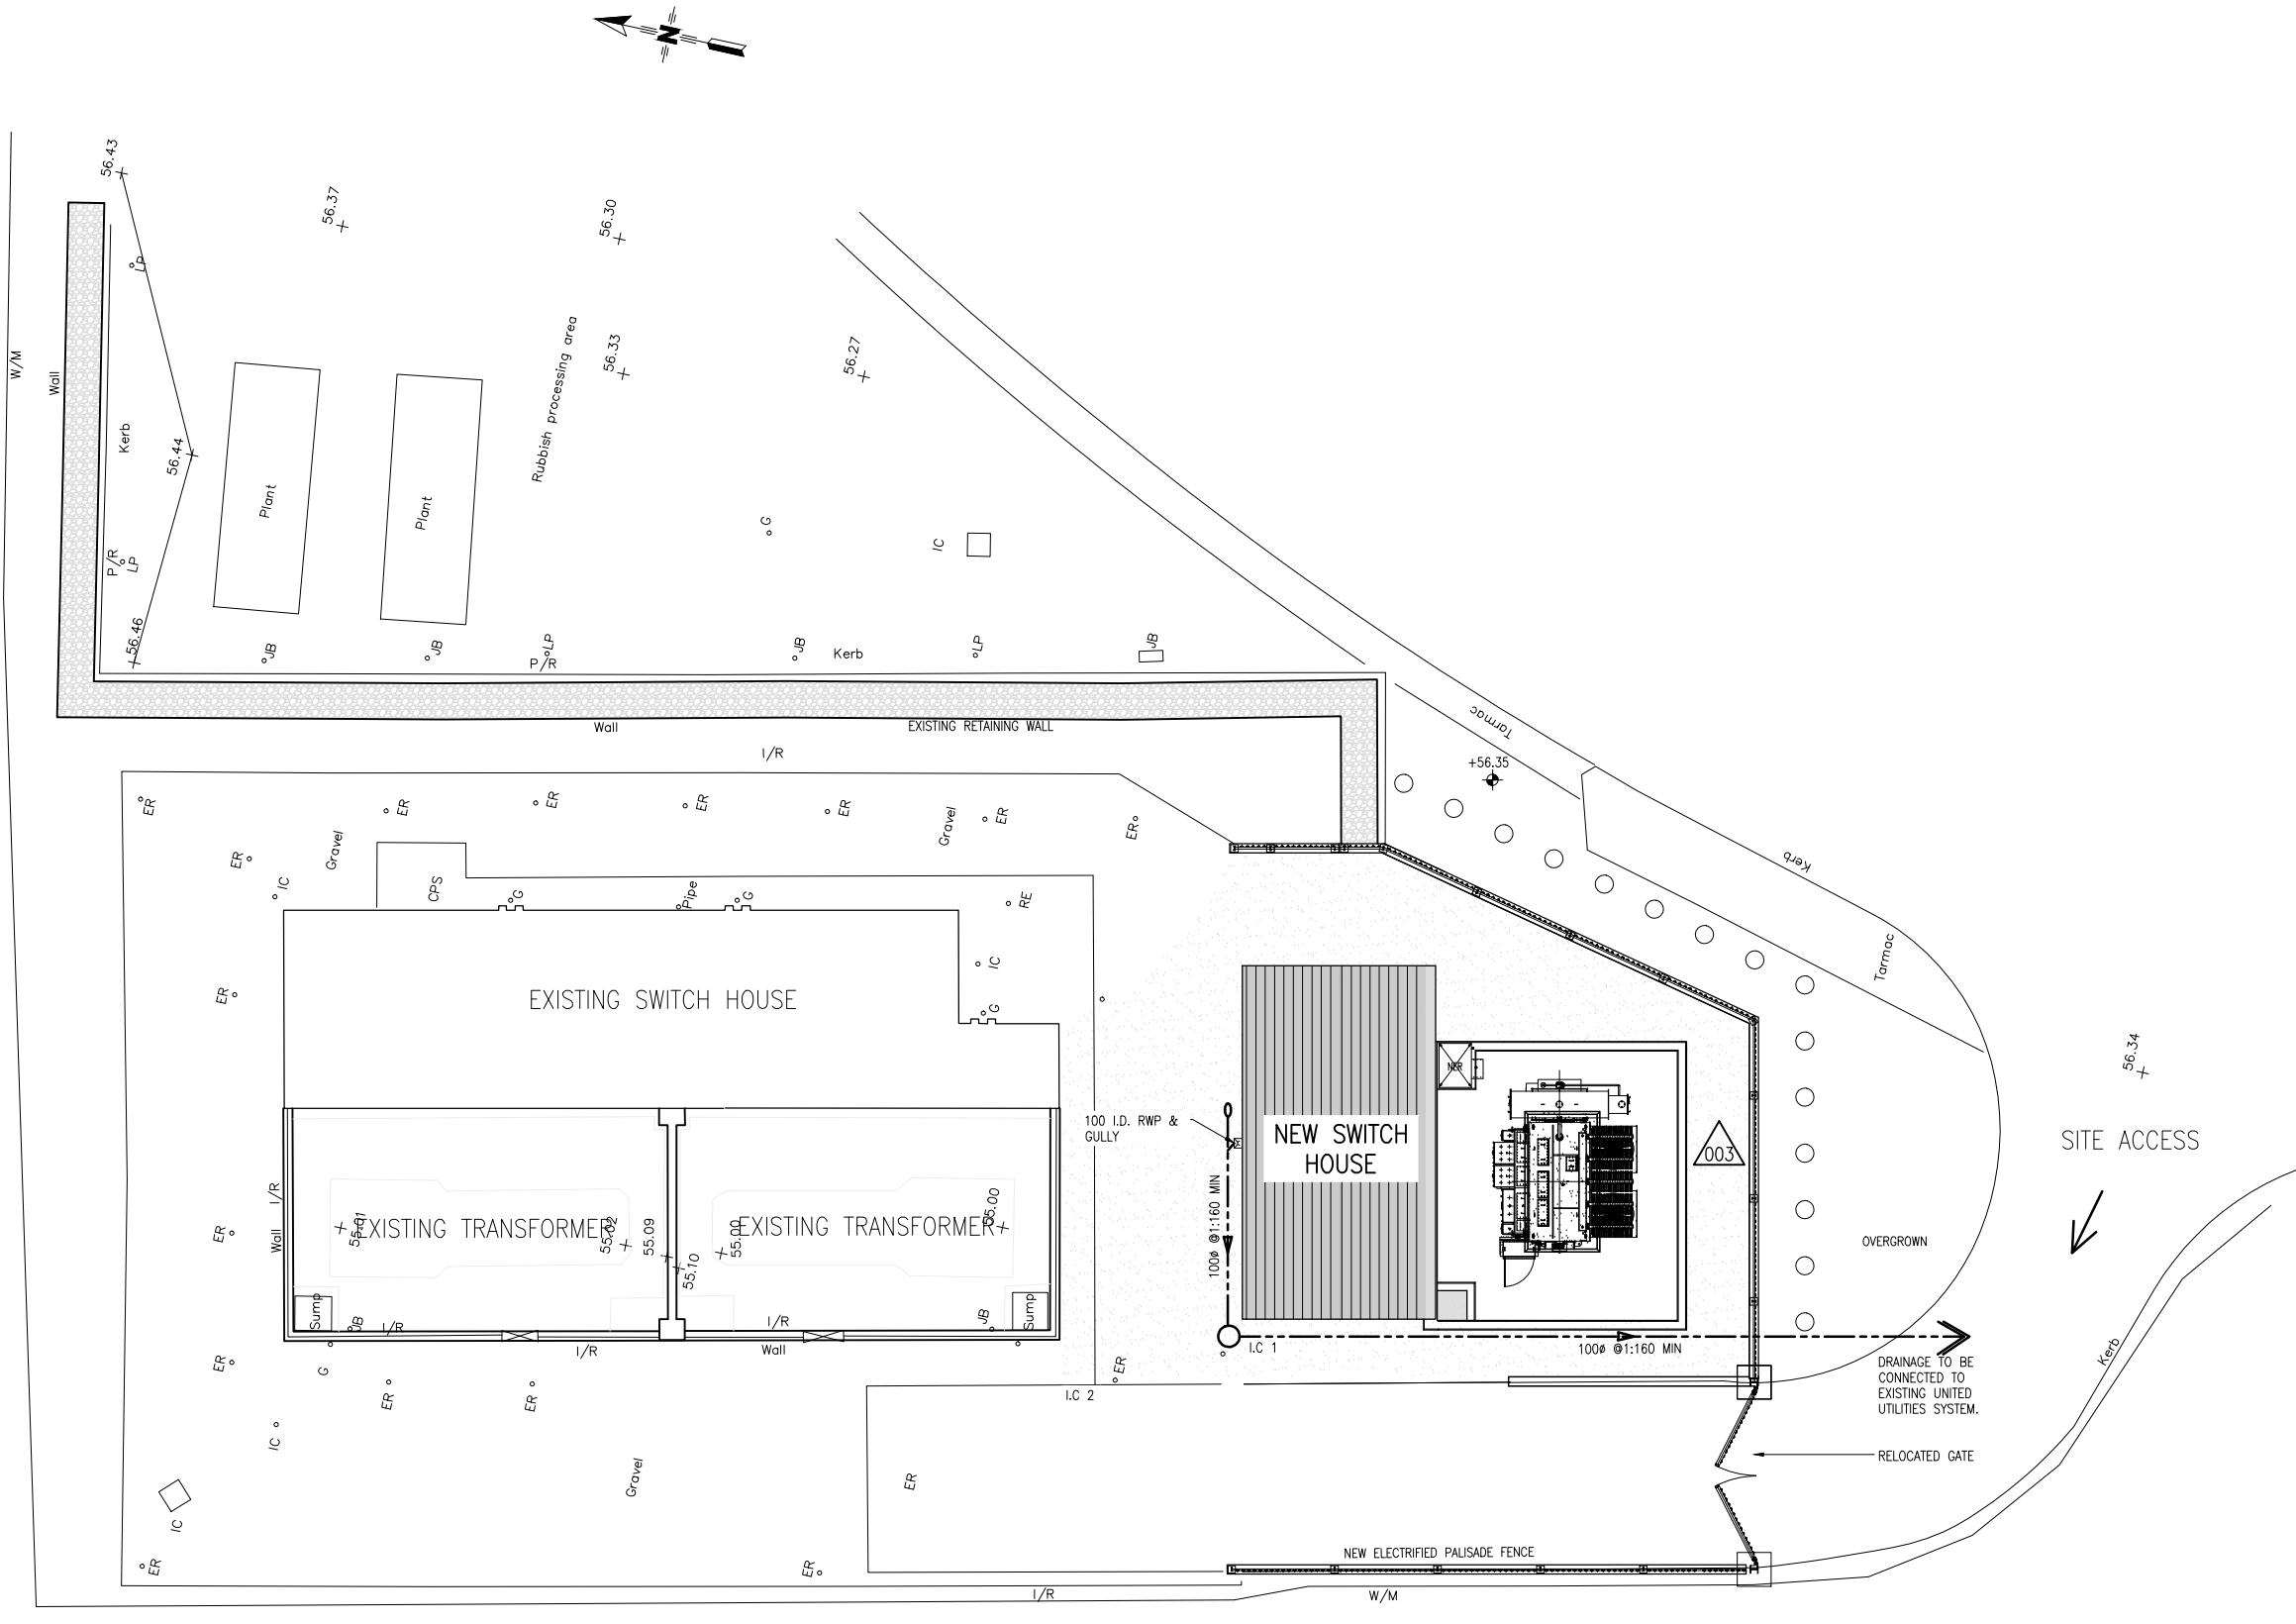

PROPOSED DRAINAGE LAYOUT

 (SCALE 1:100)



REVISION 003
EXTERNAL BRICKWORK WALL REPLACED
WITH PALISADE FENCING.

THIS DRAWING AND ANY INFORMATION OR DESCRIPTIVE MATTER SET OUT HEREON ARE THE CONFIDENTIAL AND COPYRIGHT PROPERTY OF ELECTRICITY NORTH WEST LIMITED AND MUST NOT BE DISCLOSED, LOANED, COPIED OR USED FOR ANY PURPOSE WITHOUT WRITTEN PERMISSION.				
NOT TO BE SCALED. UNLESS OTHERWISE STATED DIMENSIONS ARE IN MILLIMETRES.				
REV	AMENDMENTS	DRAWN	APP.	DATE
001	ISSUED FOR PLANNING	JEWB	ASR	19-10-22
002	ISSUED FOR PLANNING	JEWB	ASR	16-02-23
003	ISSUED FOR PLANNING	JEWB	ASR	22-03-23

		ELECTRICITY NORTH WEST FREDERICK ROAD SALFORD M6 6QH	
EASTLANDS PRIMARY SUBSTATION T13 TRANSFORMER AND SWITCH HOUSE			
DRAINAGE LAYOUT			
SCALE	AS SHOWN AT A1	SITE NAME	EASTLANDS PRIMARY SUBSTATION
DRAWN	JEWB	PROJECT	T13 TRANSFORMER AND SWITCH HOUSE
APPROVED	JAB	P.F.R. NO.	100138 DWG STATUS RELEASED
DATE	FEB 23	DRAWING NUMBER	
SHEET SIZE	A1	REVISION	
OLD DWG NO	-	100138-00356 003	