
 


SITE LOCATION

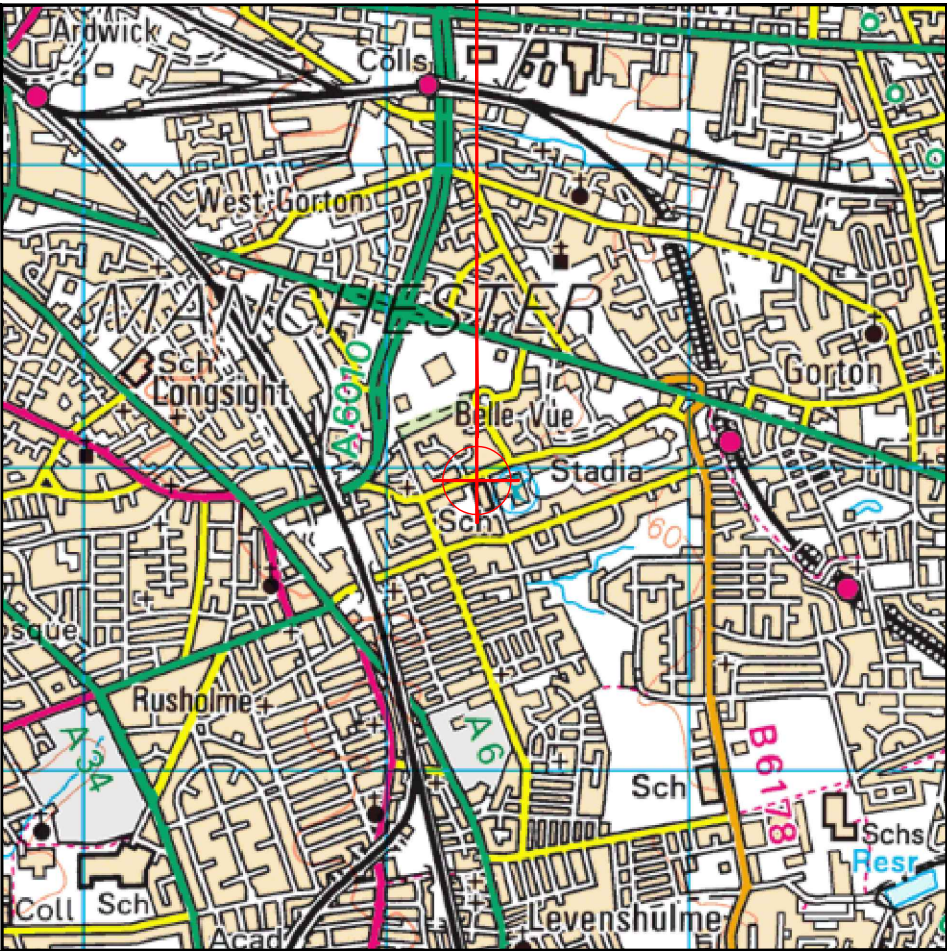

Reproduced by permission of Ordnance Survey on behalf of the Controller of Her Majesty's Stationery Office
All rights reserved. © Crown Copyright licence no. 100022432


SITE AREA PLAN



SITE PHOTOGRAPH




SITE LOCATION

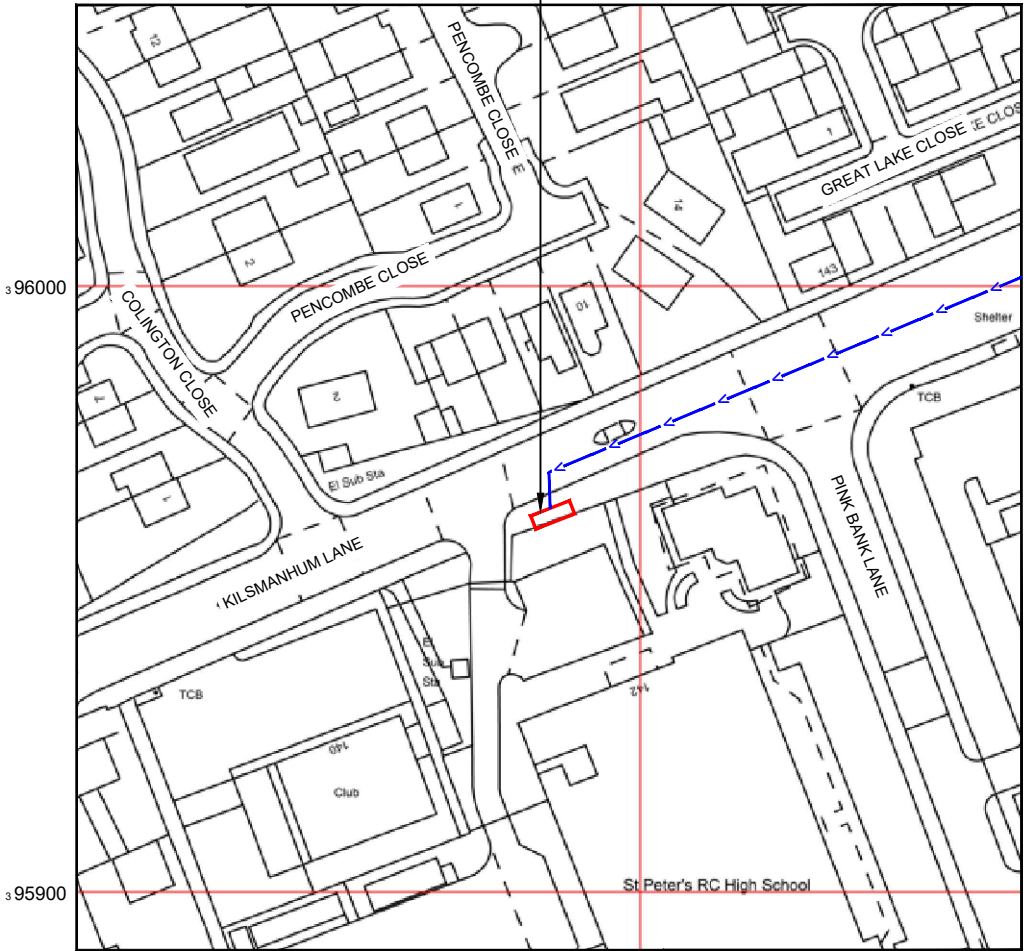

Reproduced by permission of Ordnance Survey on behalf
of the Controller of Her Majesty's Stationery Office
All rights reserved. © Crown Copyright licence no. 100022432

NGR E: 387286 N: 395964

 SITE LOCATION PLAN



GOOGLE MAPS QR CODE

GOOGLE MAPS - <https://goo.gl/maps/gr6BDVLWSriXHDzU7>

GOOGLE STREETVIEW - <https://goo.gl/maps/Q5NJ1i7CDqR4fQUG7>

NOTES:

1. ALL DIMENSIONS IN MM UNLESS OTHERWISE NOTED.

DIRECTIONS TO SITE:
HEAD NORTH ON M60, AT JUNCTION 24, USE THE LEFT LANE TO TAKE THE A57/M67
EXIT TO MCR CITY CENTRE/DENTON/HYDE/SHEFFIELD AND AFTER 0.1MILE, KEEP
LEFT AT THE Y JUNCTION AND MERGE WITH MANCHESTER RD/A57 AND AFTER
2.1MILES, TURN LEFT ONTO MOUNT RD/B6178 AND AFTER 236FEET, TURN RIGHT
ONTO KIRKMANSHULME LN AND AFTER 0.5MILE, PROPOSED SITE LOCATION WILL
BE ON THE LEFT SIDE.

Site Provider's
Property Boundary:



Access Route To Site:



Access Route:



Master:	MBNL / EE / H3G:	Project:	Purpose of Issue:	Issue:
M001	H3G	DENSIFICATION SW	Planning	A
Date:	11/05/2023	Revision / Upgrade Description:		
Drawn:	M.Bagya	First Issue		
Checked:	R.Brown			
Approved:	R.Brown			



Hutchison 3G UK Limited
Green Park, 450 Longwater Avenue
Reading, RG30 3UR
Tel: 01628 765 000
Fax: 01628 765 001

H3G Base Station Information line:
0845 6043000
Available 8am-8pm Monday to Friday

Design Consultant & Principal Contractor:



Unit E, Madison Place, Northampton Road,
Manchester, M40 5AG
Tel: 0161 785 4500 Fax: 0161 785 4501
Web: www.clarke-telecom.com

Site Name:

KIRKMANSHULME LANE

Site ID:

MAN26959

Address:

KIRKMANSHULME LANE
BELLE VUE
GORTON
MANCHESTER
M12 4WB

Title:

002 SITE LOCATION PLAN


Project:

H3G DENSIFICATION STREETWORKS

Purpose of Issue:

PLANNING

Master Drawing No:	MBNL Cell ID:	3UK Cell ID:	Issue:
MAN26959_NA_NA_M001_H3G_DNSW_GA_A	N/A	N/A	A

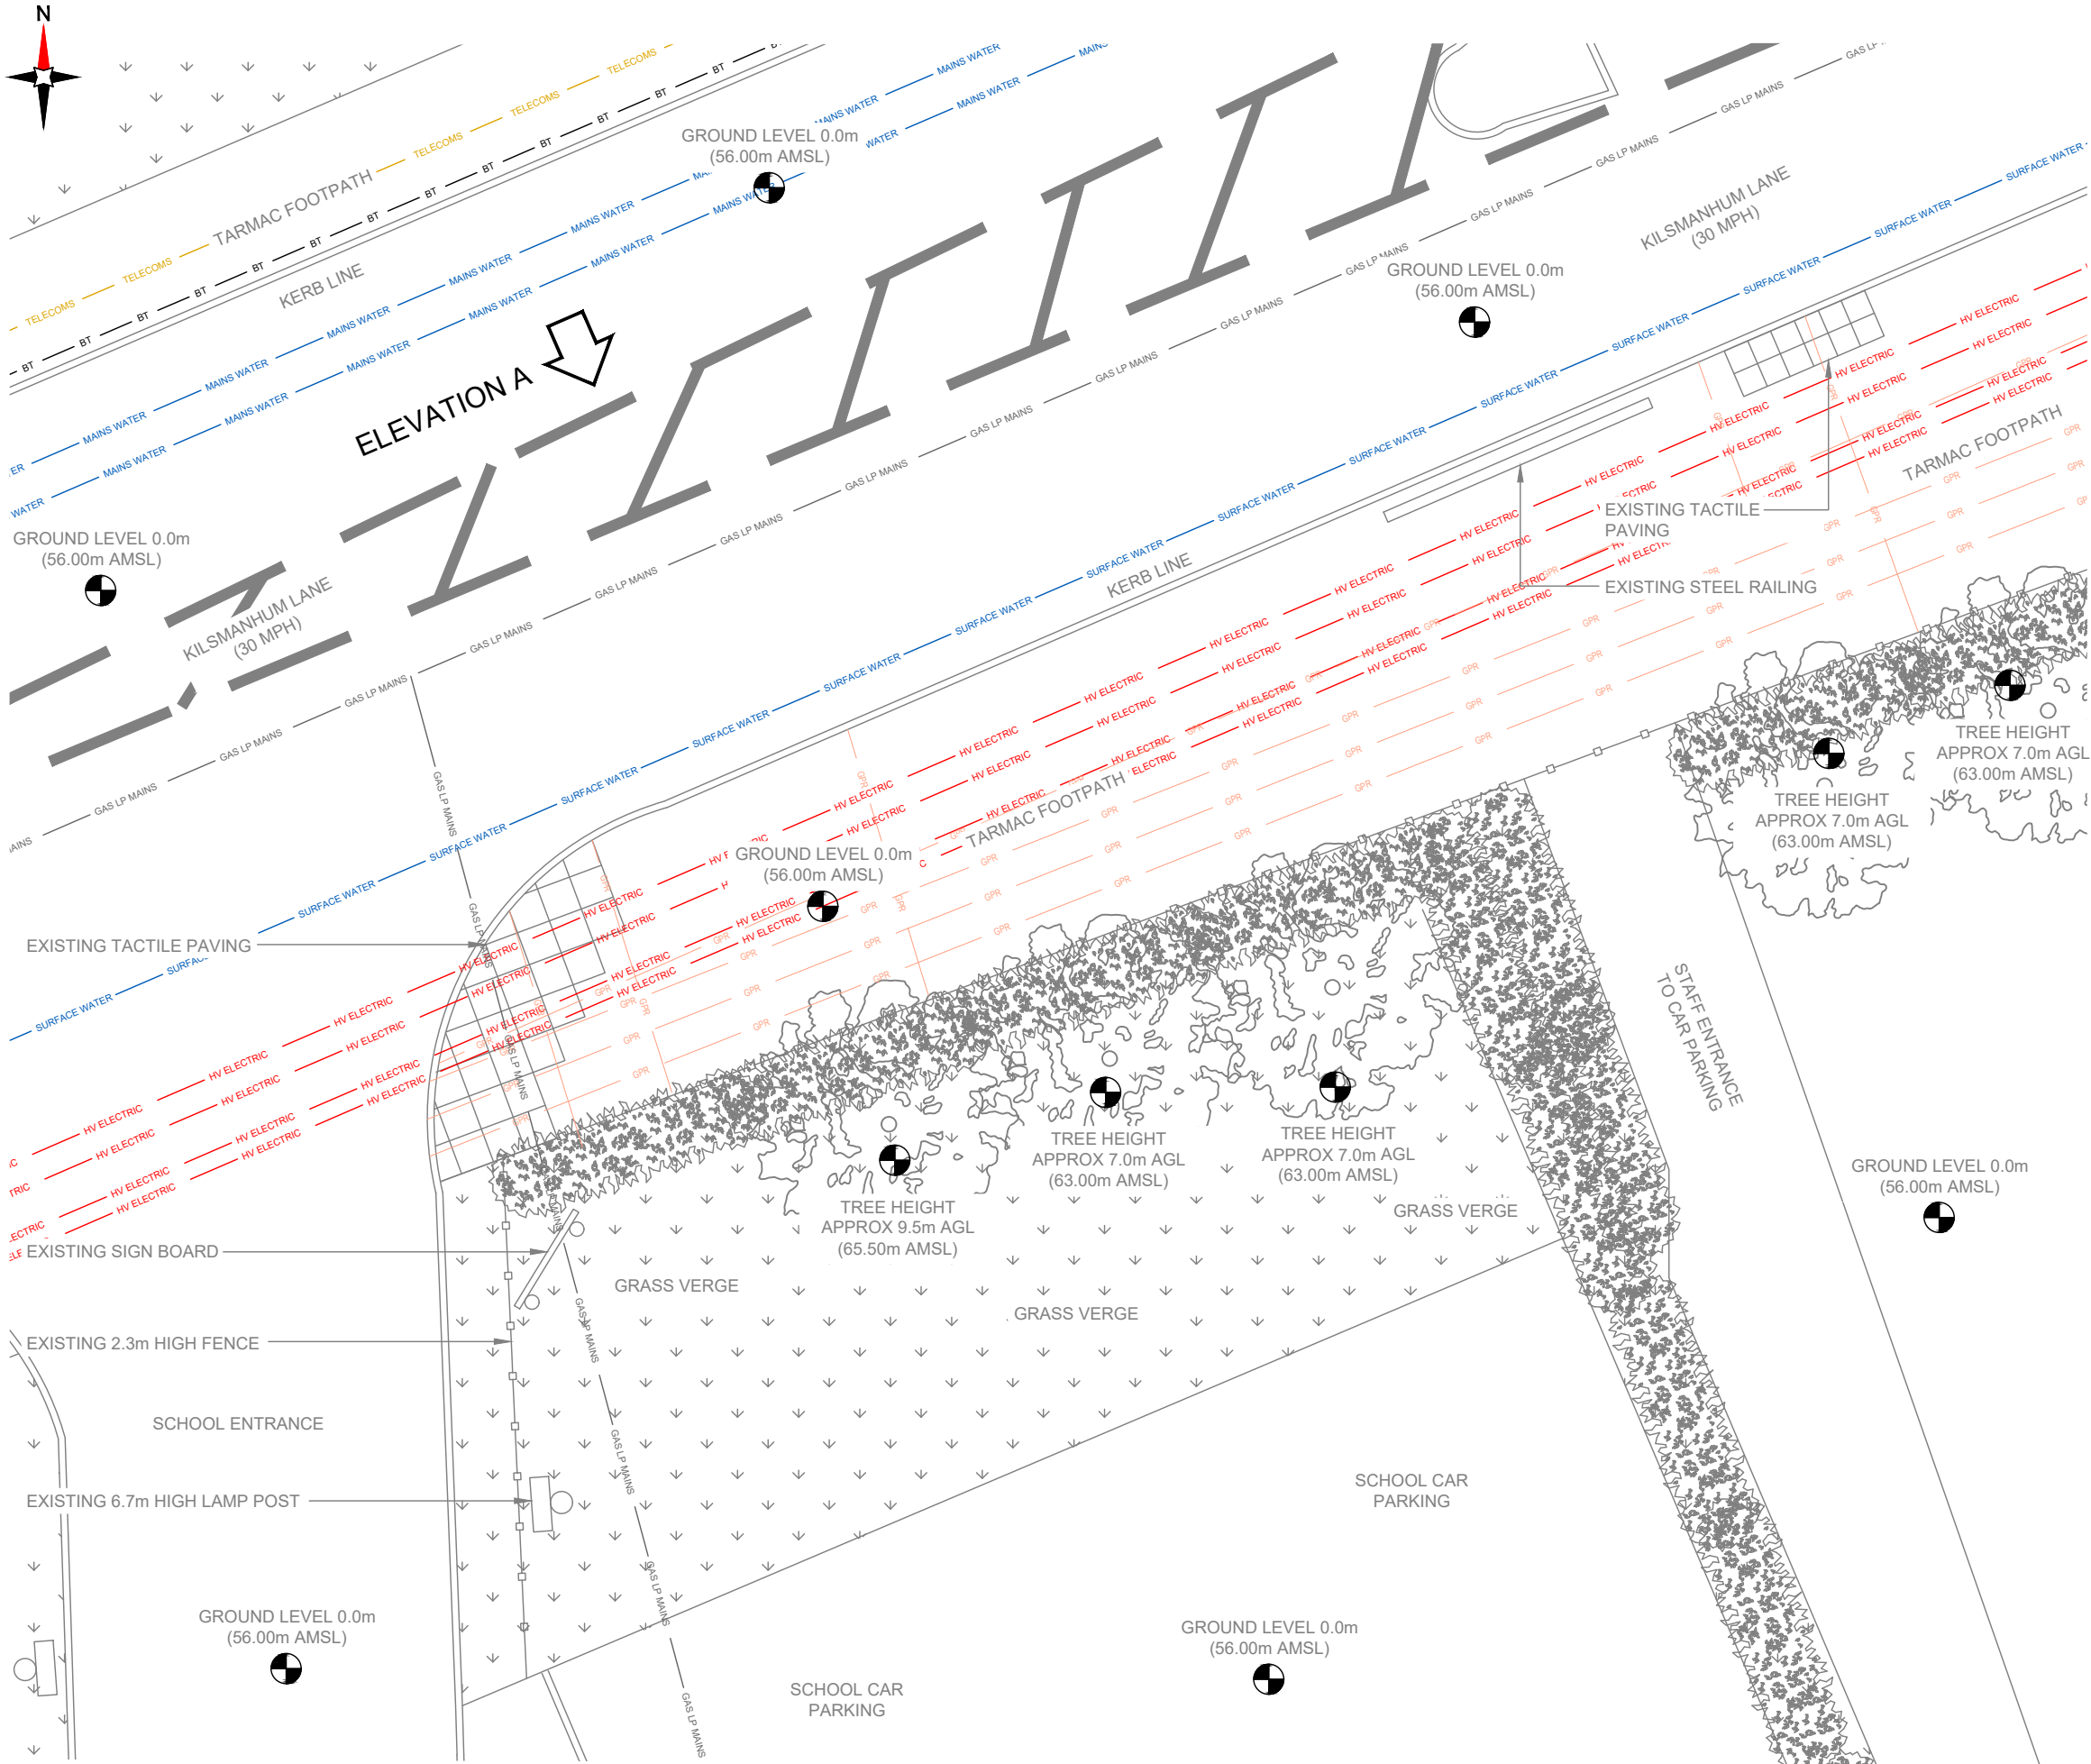

- NOTES:
1. ALL DIMENSIONS IN MM UNLESS OTHERWISE NOTED.
- SERVICES:
- HV ELECTRIC
 - LV ELECTRIC
 - ELECTRIC
 - GAS LP MAINS
 - MAINS WATER
 - SEWAGE WATER
 - TELECOMS
 - GPR

Master:	MBNL / EE / H3G:	Project:	Purpose of Issue:	Issue:
M001	H3G	DENSIFICATION SW	Planning	A
Date:	11/05/2023	Revision / Upgrade Description:		
Drawn:	M.Bagya	First Issue		
Checked:	R.Brown			
Approved:	R.Brown			



Hutchison 3G UK Limited
Green Park, 450 Longwater Avenue
Reading, RG30 3UR
Tel: 01628 765 000
Fax: 01628 765 001

H3G Base Station Information line:
0845 6043000
Available 8am-8pm Monday to Friday

Design Consultant & Principal Contractor:



Unit E, Madison Place, Northampton Road,
Manchester, M40 5AG
Tel: 0161 785 4500 Fax: 0161 785 4501
Web: www.clarke-telecom.com

Site Name:
KIRKMANSHULME LANE

Site ID:
MAN26959

Address:
KIRKMANSHULME LANE
BELLE VUE
GORTON
MANCHESTER
M12 4WB


Title:
100 EXISTING SITE PLAN

Project:
H3G DENSIFICATION STREETWORKS


Purpose of Issue:
PLANNING

MBNL Cell ID:	3UK Cell ID:
N/A	N/A

Master Drawing No: MAN26959_NA_NA_M001_H3G_DNSW_GA_A	Issue: A
---	-------------

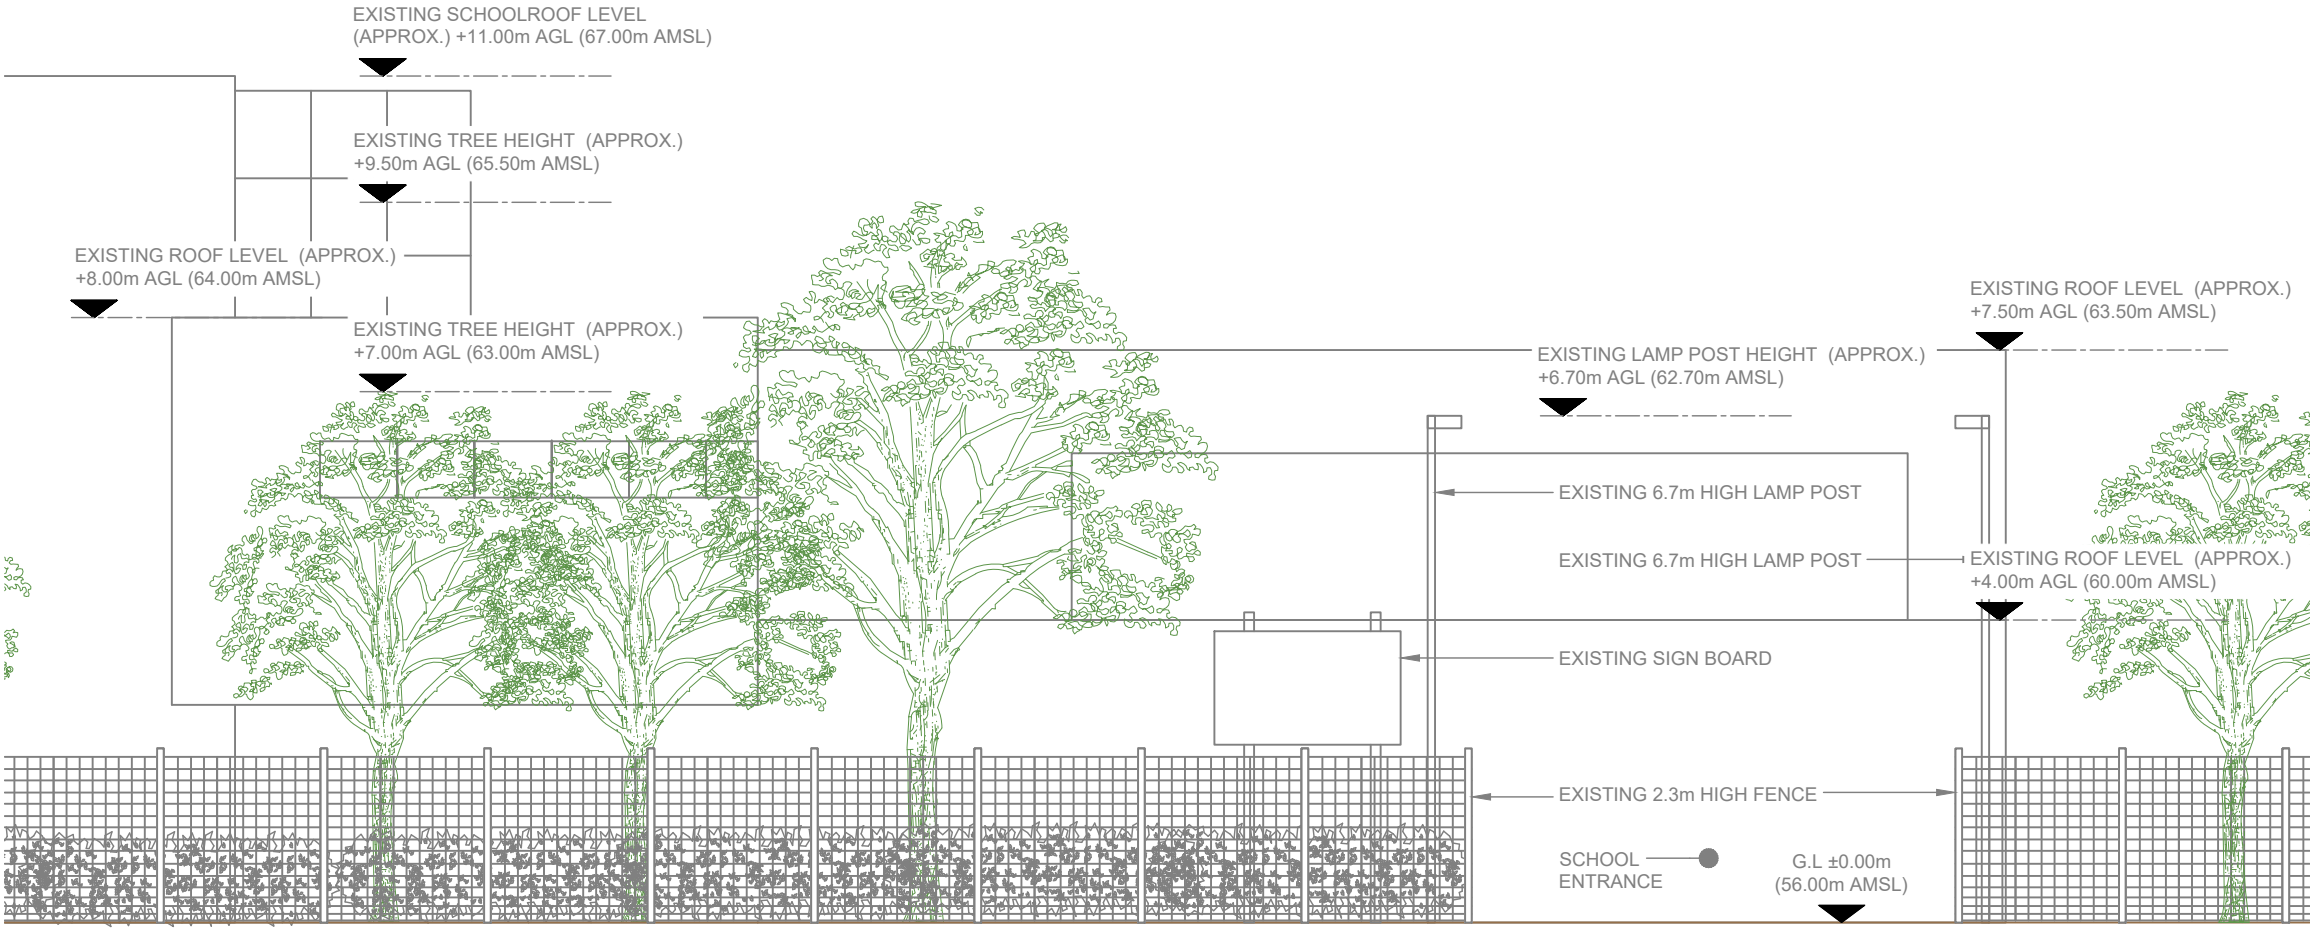

EXISTING SITE ELEVATION A

 

- NOTES:
1. ALL DIMENSIONS IN MM UNLESS OTHERWISE NOTED.

Master:	MBNL / EE / H3G:	Project:	Purpose of Issue:	Issue:
M001	H3G	DENSIFICATION SW	Planning	A
Date:	11/05/2023	Revision / Upgrade Description:		
Drawn:	M.Bagya	First Issue		
Checked:	R.Brown			
Approved:	R.Brown			



Hutchison 3G UK Limited
Green Park, 450 Longwater Avenue
Reading, RG30 3UR
Tel: 01628 765 000
Fax: 01628 765 001

H3G Base Station Information line:
0845 6043000
Available 8am-8pm Monday to Friday

Design Consultant & Principal Contractor:



Unit E, Madison Place, Northampton Road,
Manchester, M40 5AG
Tel: 0161 785 4500 Fax: 0161 785 4501
Web: www.clarke-telecom.com

Site Name:
KIRKMANSHULME LANE

Site ID:
MAN26959

Address:
KIRKMANSHULME LANE
BELLE VUE
GORTON
MANCHESTER
M12 4WB


Title:
150 EXISTING SITE ELEVATION A

Project:
H3G DENSIFICATION STREETWORKS

Purpose of Issue:
PLANNING

MBNL Cell ID:	3UK Cell ID:
N/A	N/A

Master Drawing No: MAN26959_NA_NA_M001_H3G_DNSW_GA_A	Issue: A
---	-------------

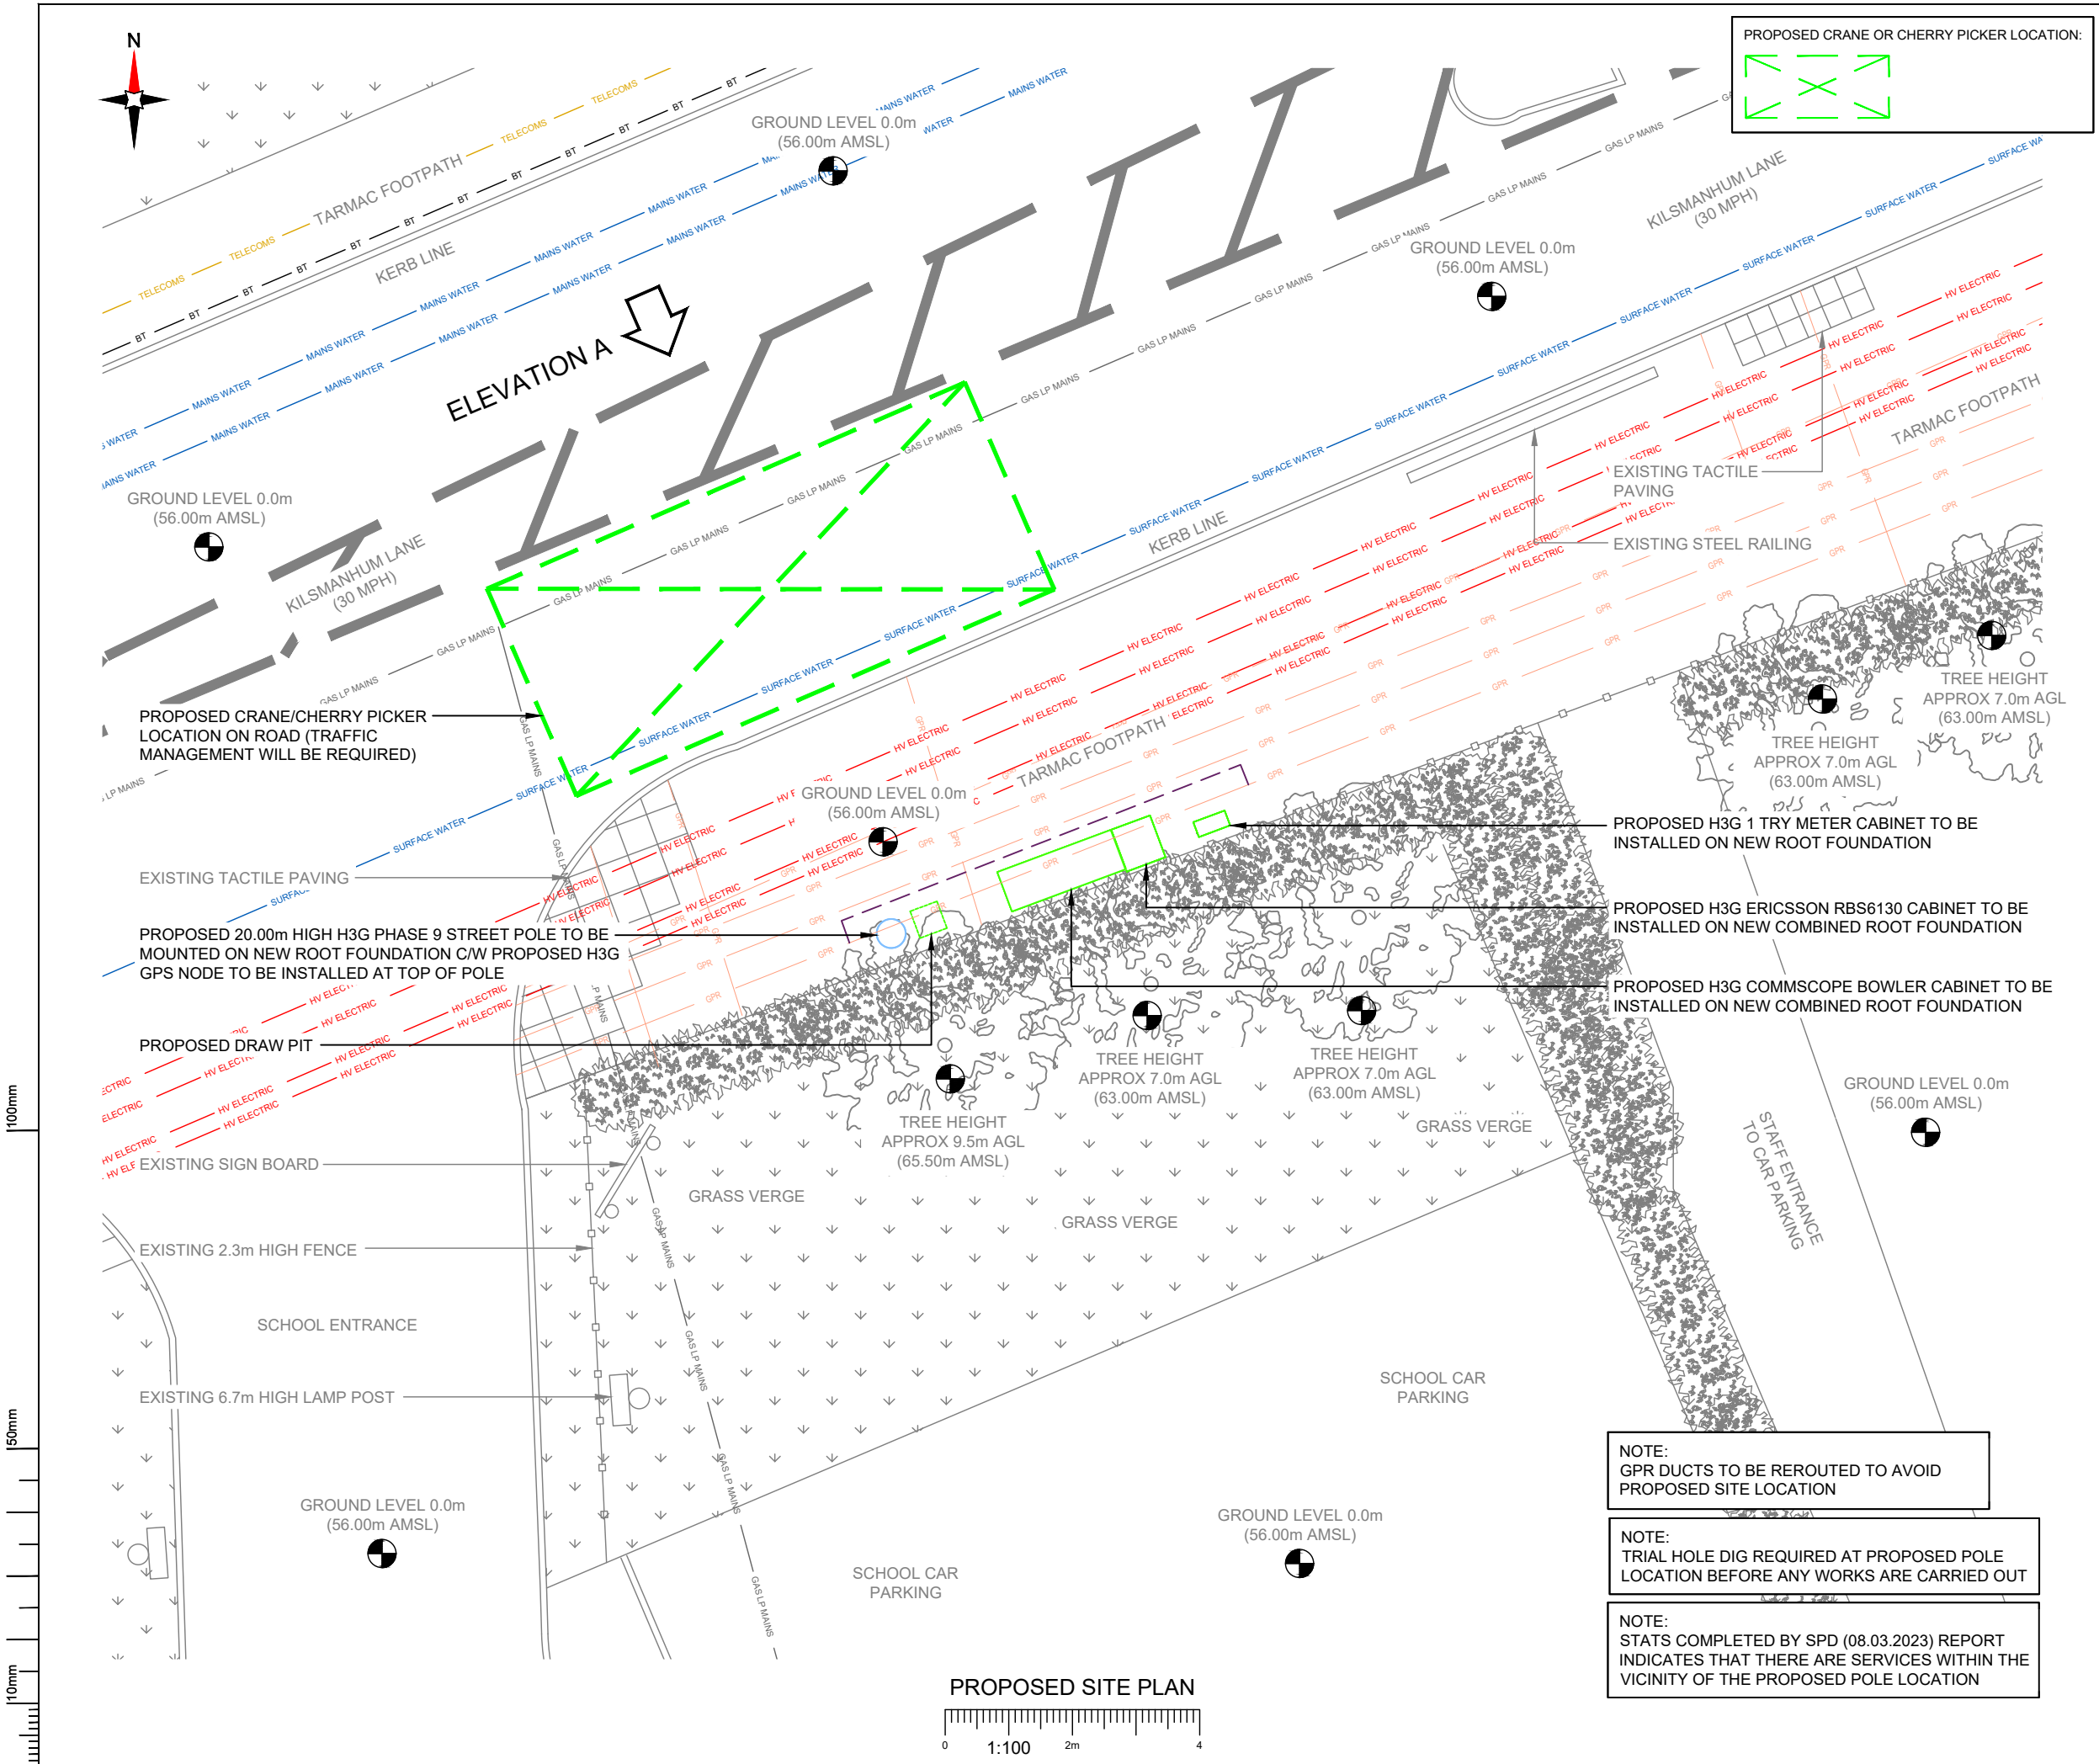

PROPOSED CRANE OR CHERRY PICKER LOCATION:

- NOTES:
1. ALL DIMENSIONS IN MM UNLESS OTHERWISE NOTED.
- SERVICES:
- HV ELECTRIC
 - LV ELECTRIC
 - ELECTRIC
 - GAS LP MAINS
 - MAINS WATER
 - SEWAGE WATER
 - TELECOMS
 - GPR
 - DIVERT

Master:	MBNL / EE / H3G:	Project:	Purpose of Issue:	Issue:
M001	H3G	DENSIFICATION SW	Planning	A
Date:	11/05/2023	Revision / Upgrade Description:		
Drawn:	M.Bagya	First Issue		
Checked:	R.Brown			
Approved:	R.Brown			



Hutchison 3G UK Limited
Green Park, 450 Longwater Avenue
Reading, RG30 3UR
Tel: 01628 765 000
Fax: 01628 765 001

H3G Base Station Information line:
0845 6043000
Available 8am-8pm Monday to Friday

Design Consultant & Principal Contractor:

CLARKE telecom


Unit E, Madison Place, Northampton Road,
Manchester, M40 5AG
Tel: 0161 785 4500 Fax: 0161 785 4501
Web: www.clarke-telecom.com

Site Name:	KIRKMANSHULME LANE
Site ID:	MAN26959
Address:	KIRKMANSHULME LANE BELLE VUE GORTON MANCHESTER M12 4WB
Title:	210 PROPOSED SITE PLAN
Project:	H3G DENSIFICATION STREETWORKS
Purpose of Issue:	PLANNING
Master Drawing No:	MAN26959_NA_NA_M001_H3G_DNSW_GA_A
3UK Cell ID:	N/A
Issue:	A


NOTE:
GPR DUCTS TO BE REROUTED TO AVOID
PROPOSED SITE LOCATION

NOTE:
TRIAL HOLE DIG REQUIRED AT PROPOSED POLE
LOCATION BEFORE ANY WORKS ARE CARRIED OUT

NOTE:
STATS COMPLETED BY SPD (08.03.2023) REPORT
INDICATES THAT THERE ARE SERVICES WITHIN THE
VICINITY OF THE PROPOSED POLE LOCATION

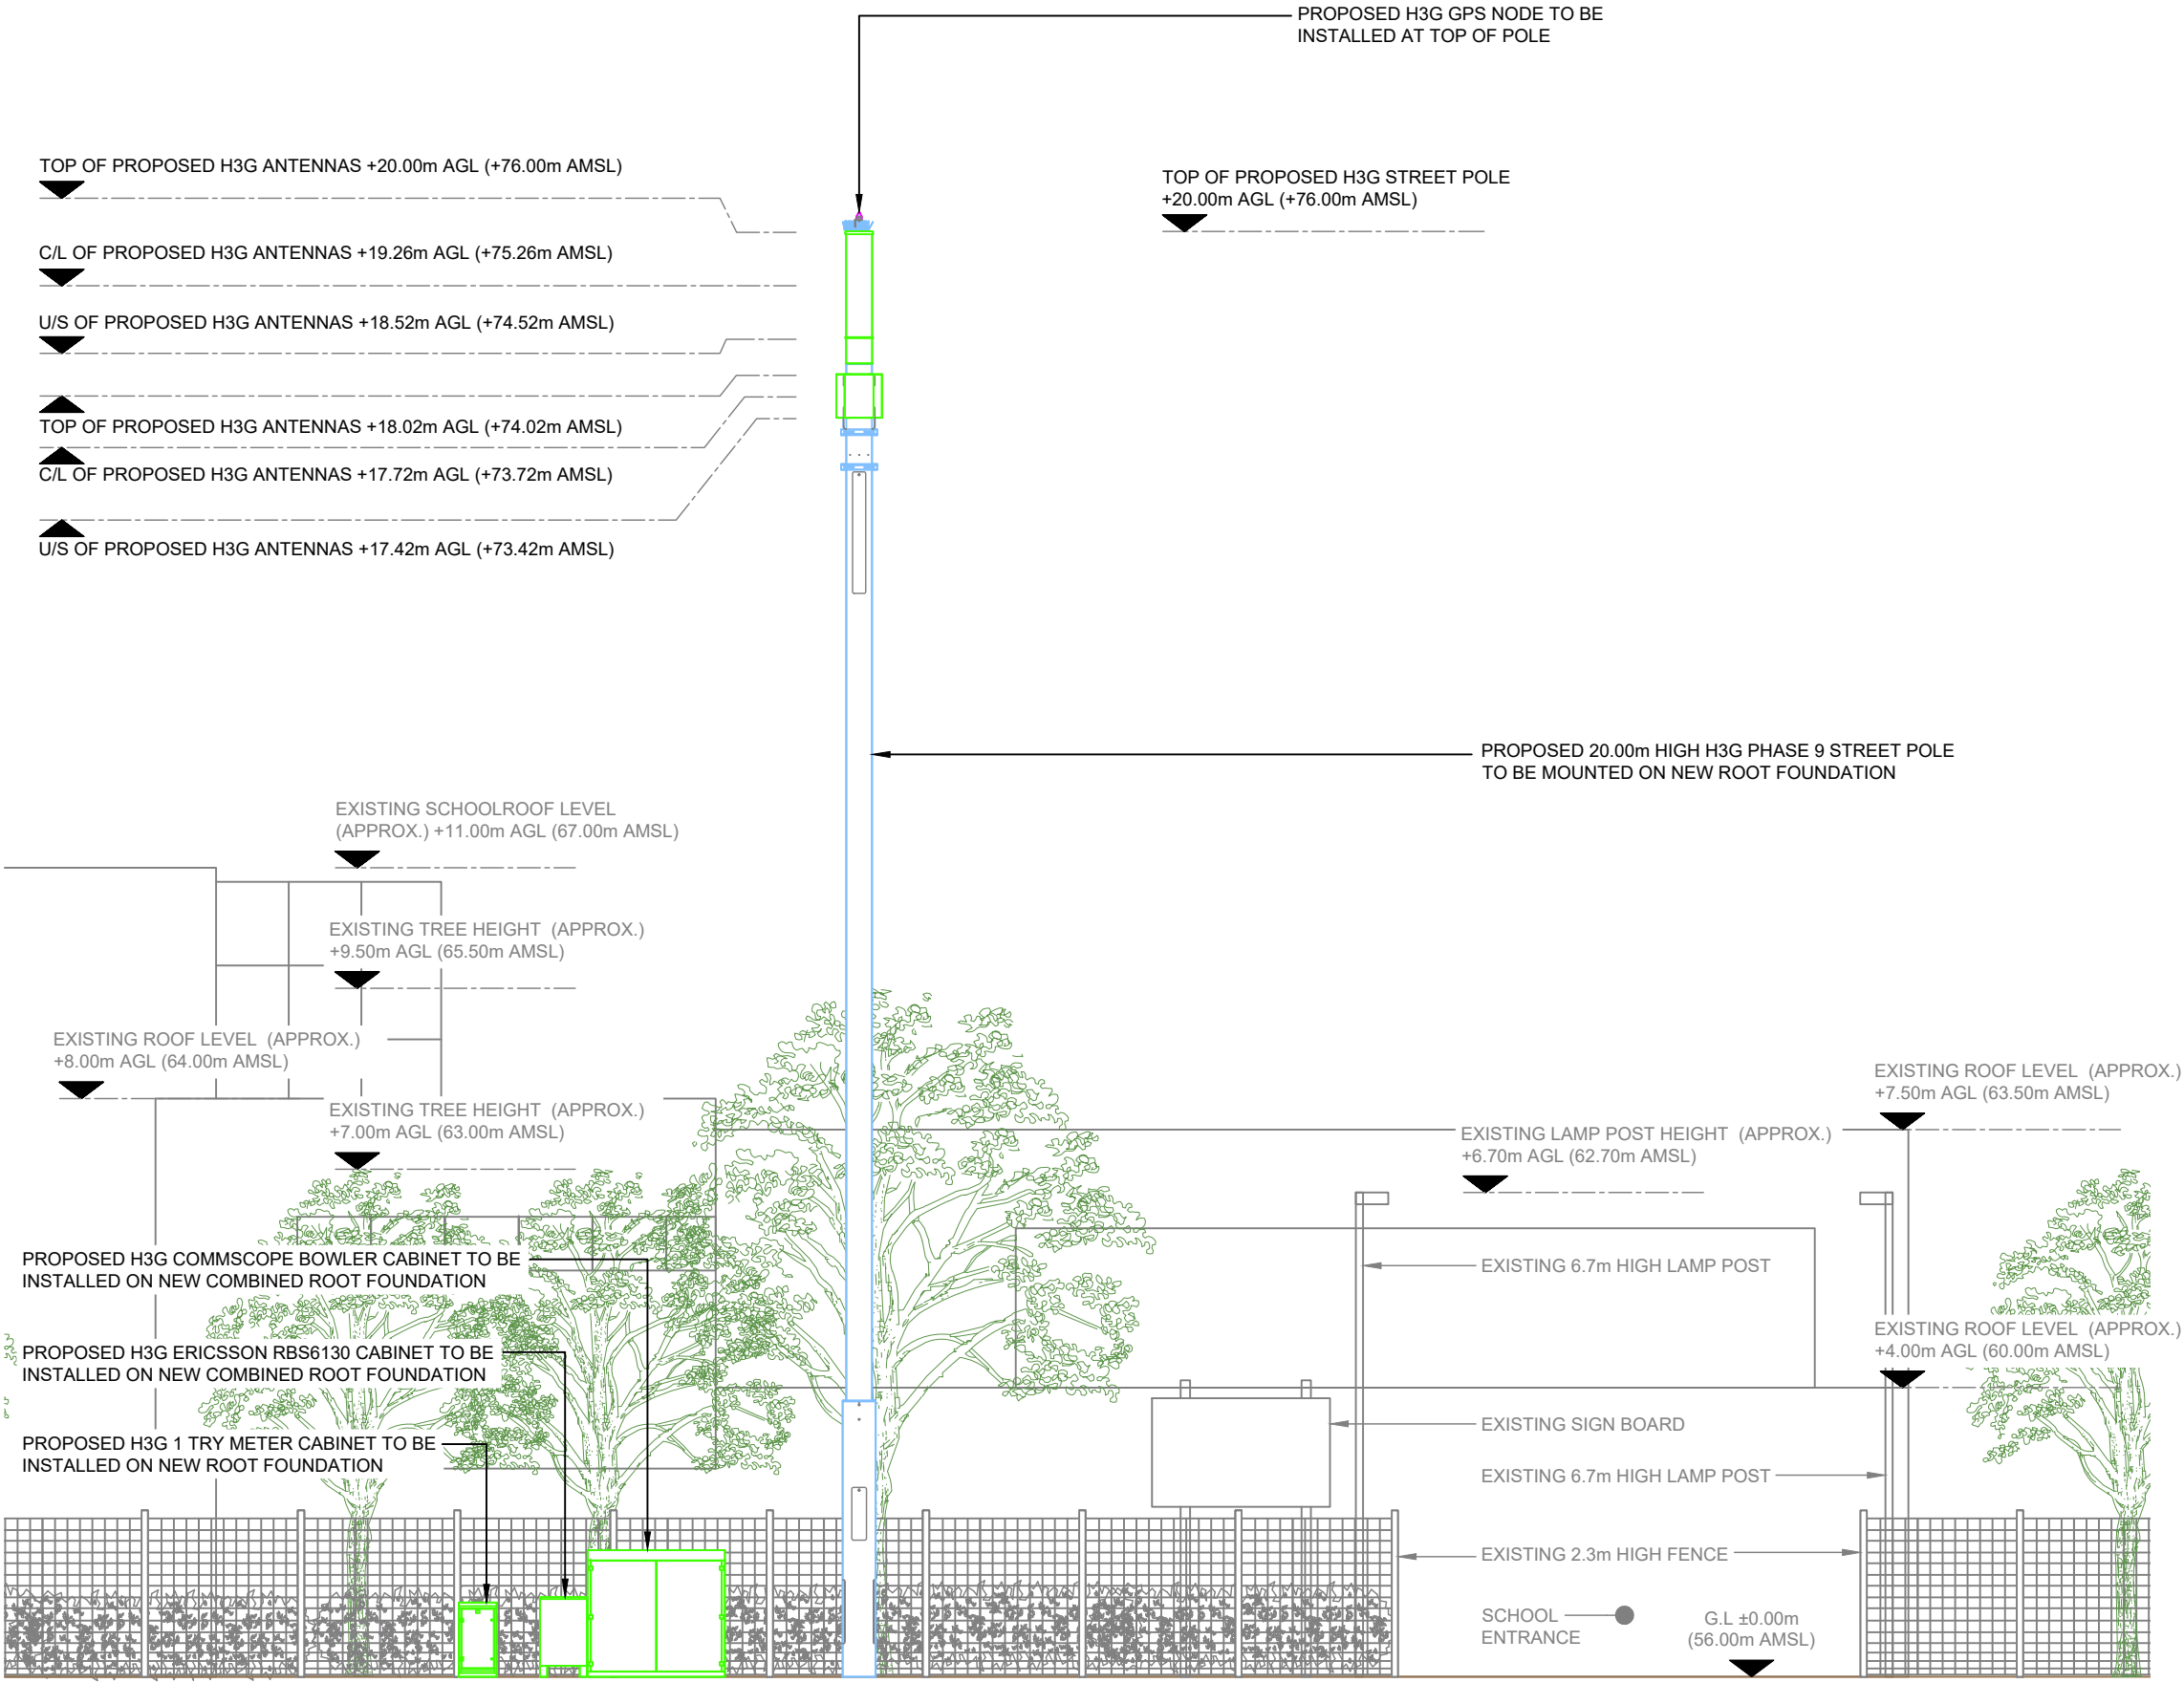

PROPOSED SITE ELEVATION A

 

- NOTES:
- ALL DIMENSIONS IN MM UNLESS OTHERWISE NOTED.

Master:	MBNL / EE / H3G:	Project:	Purpose of Issue:	Issue:
M001	H3G	DENSIFICATION SW	Planning	A
Date:	11/05/2023	Revision / Upgrade Description:		
Drawn:	M.Bagya	First Issue		
Checked:	R.Brown			
Approved:	R.Brown			



Hutchison 3G UK Limited
Green Park, 450 Longwater Avenue
Reading, RG30 3UR
Tel: 01628 765 000
Fax: 01628 765 001

H3G Base Station Information line:
0845 6043000
Available 8am-8pm Monday to Friday

Design Consultant & Principal Contractor:



Unit E, Madison Place, Northampton Road,
Manchester, M40 5AG
Tel: 0161 785 4500 Fax: 0161 785 4501
Web: www.clarke-telecom.com

Site Name:

KIRKMANSHULME LANE

Site ID:

MAN26959

Address:

KIRKMANSHULME LANE
BELLE VUE
GORTON
MANCHESTER
M12 4WB

Title:

260 PROPOSED SITE ELEVATION A

Project:

H3G DENSIFICATION STREETWORKS

Purpose of Issue:

PLANNING

	MBNL Cell ID:	3UK Cell ID:
	N/A	N/A
Master Drawing No:		Issue:
MAN26959_NA_NA_M001_H3G_DNSW_GA_A		A