


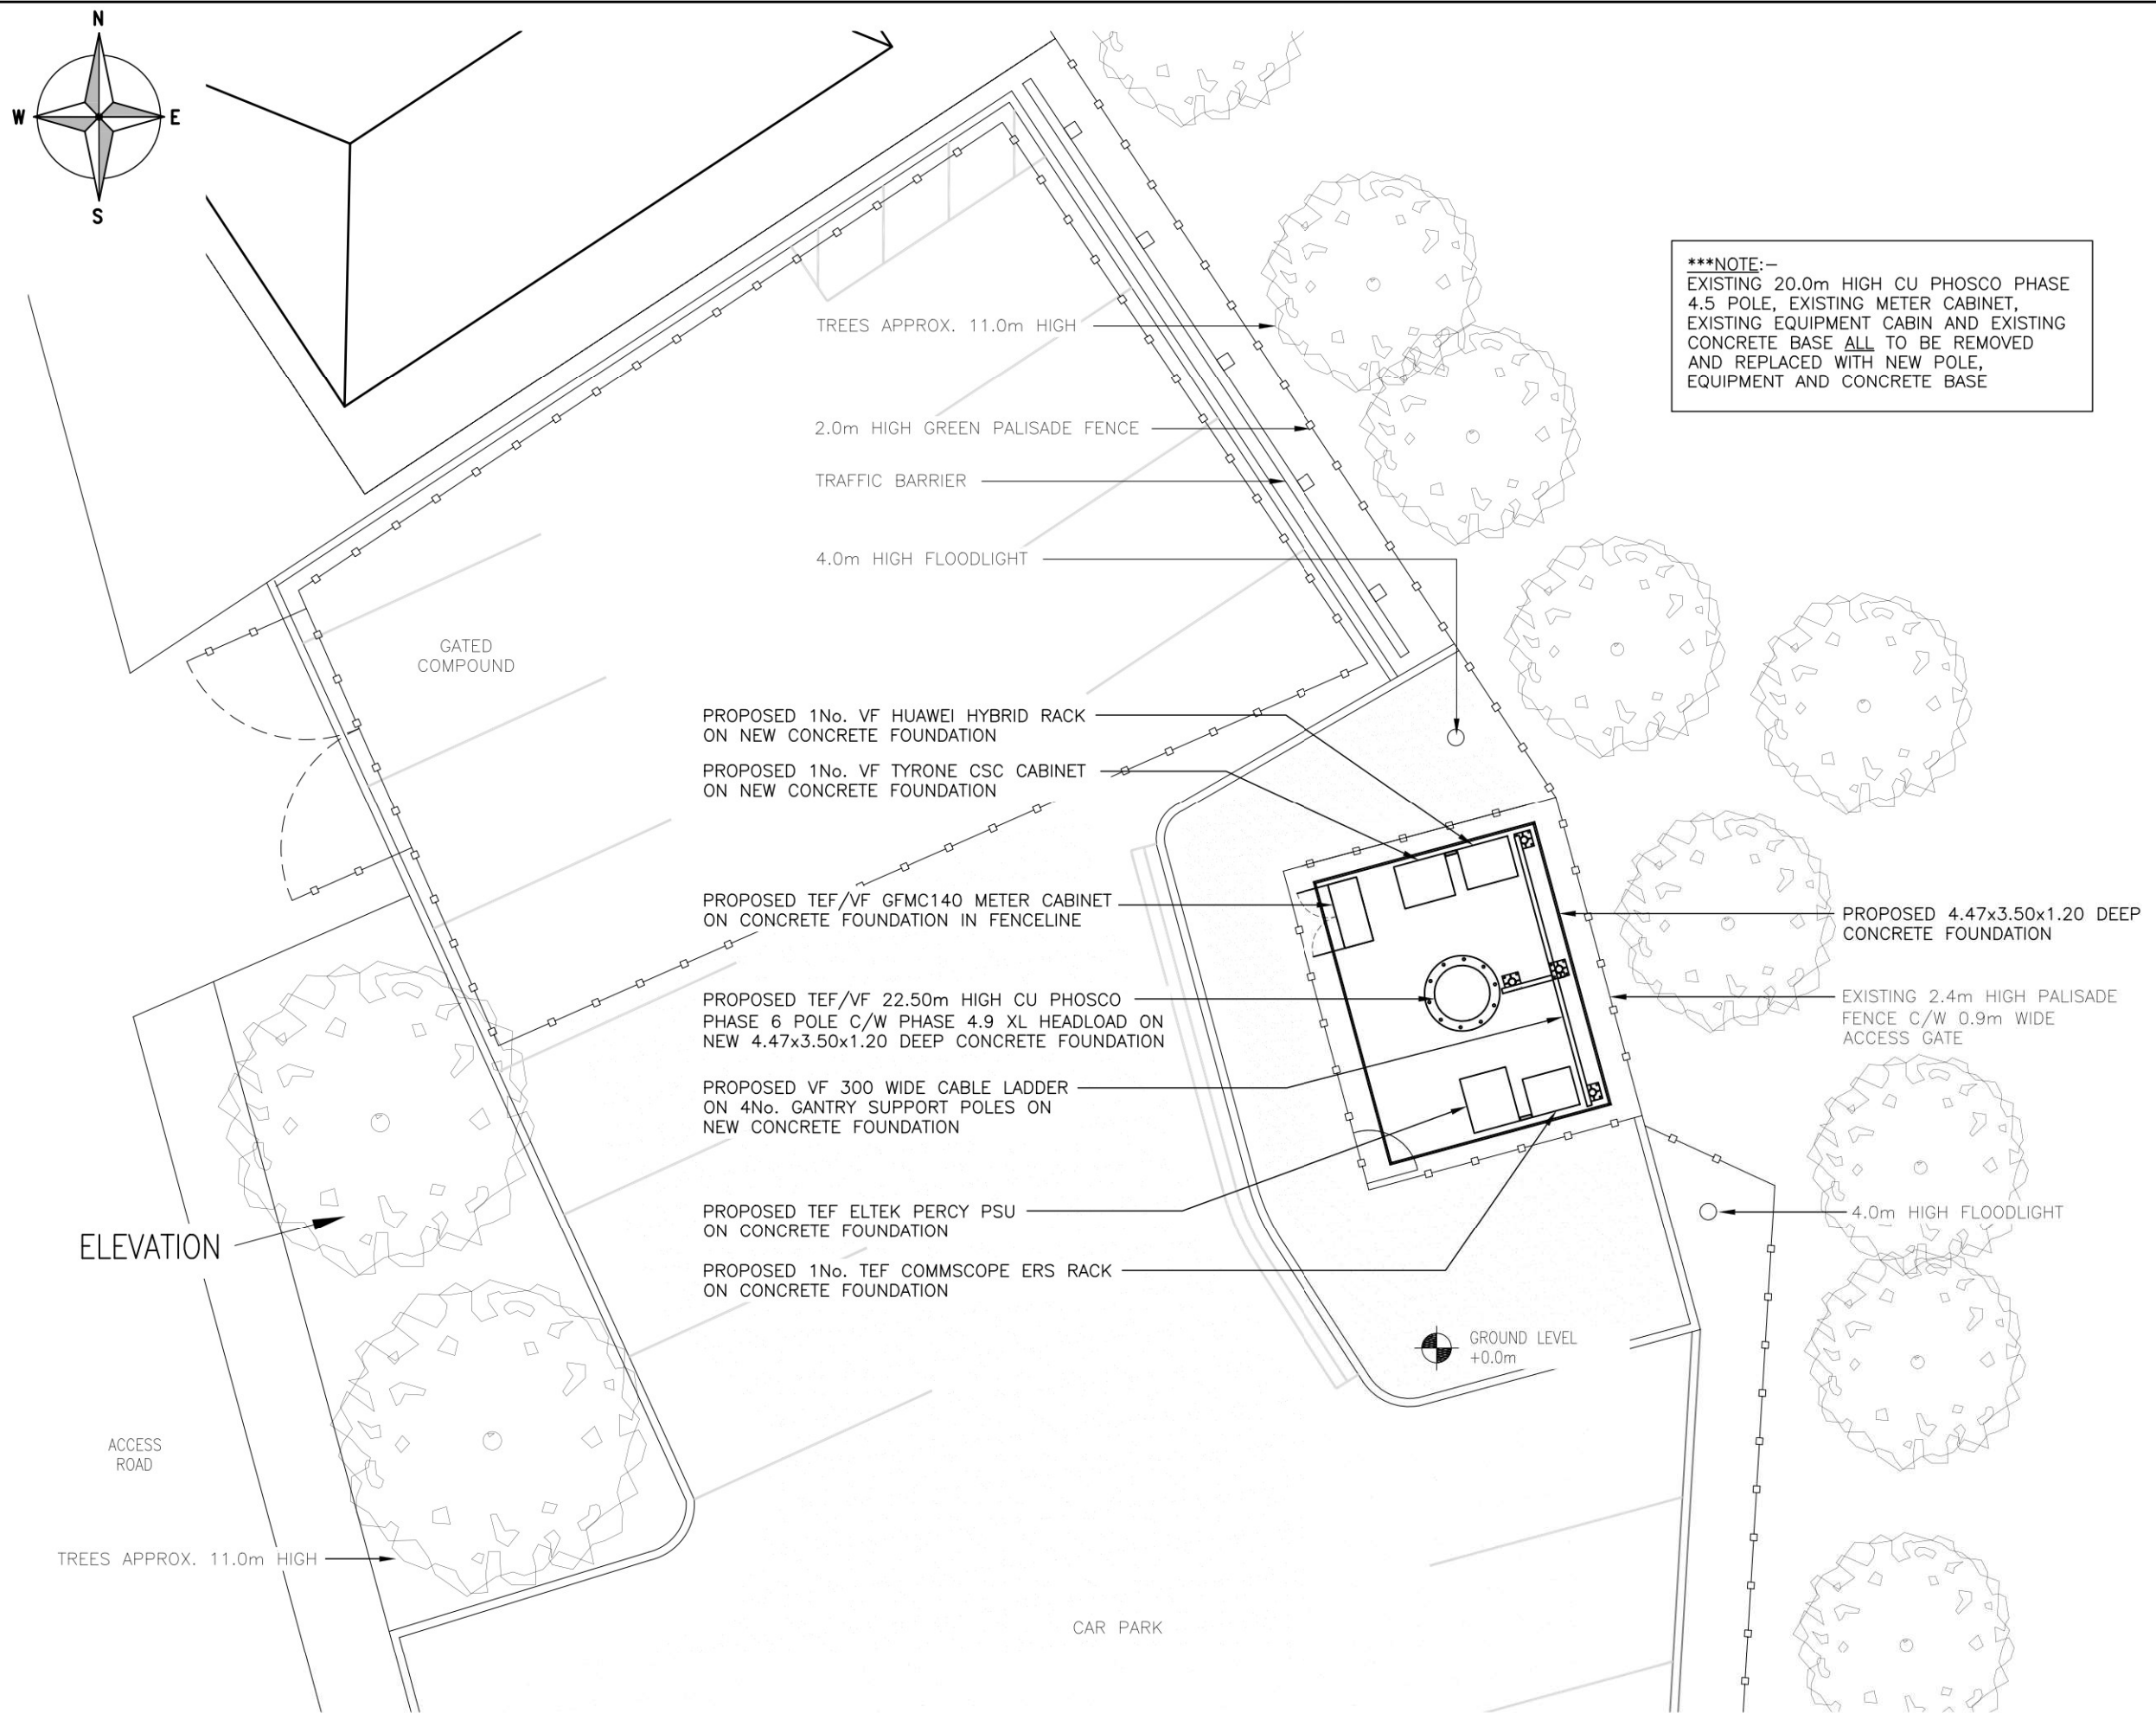

***NOTE:-
EXISTING 20.0m HIGH CU PHOSCO PHASE
4.5 POLE, EXISTING METER CABINET,
EXISTING EQUIPMENT CABIN AND EXISTING
CONCRETE BASE ALL TO BE REMOVED
AND REPLACED WITH NEW POLE,
EQUIPMENT AND CONCRETE BASE

ALL DIMENSIONS ARE IN mm UNLESS NOTED OTHERWISE

N.G.R	E: 385165	N: 402452
-------	-----------	-----------

NOTES:

C	Site Design Updated	KS	–	17.01.23
B	TEF ERS rack added	DP	MC	14.01.21
A	Issued for Approval	KS	SSH	09.12.20
REV	MODIFICATION	BY	CH	DATE



Unit E, Madison Place, Northampton Road,
Manchester, M40 5AG
Tel: 0161 785 4500
Fax: 0161 785 4501
Web: www.clarke-telecom.com



CORNERSTONE - BEACON 3

Cell Name	Opt
NORTH MANCHESTER GENERAL HOSPITAL	A

Cell ID No		
CORNERSTONE	TEF	VF
121636_28 E311989	092725	01658

Site Address / Contact Details

NORTH MANCHESTER GENERAL HOSPITAL
CHEETHAM HILL
MANCHESTER
GREATER MANCHESTER
M8 5RB


Drawing Title: PROPOSED SITE PLAN

Purpose of issue:	PLANNING	Dwg: Rev:
-------------------	----------	--------------

Drawing Number:	201	C
-----------------	-----	---

Surveyed By: SSH		Original Sheet Size: A3		Pack Issue
Drawn: KS	Date: 09.12.20	Checked: SSH	Date: 09.12.20	C

The drawings comply with TEF & Vodafone Standard ICNIRP guidelines.
Designed in accordance with CORNERSTONE document: SDN0013 & SDN0009

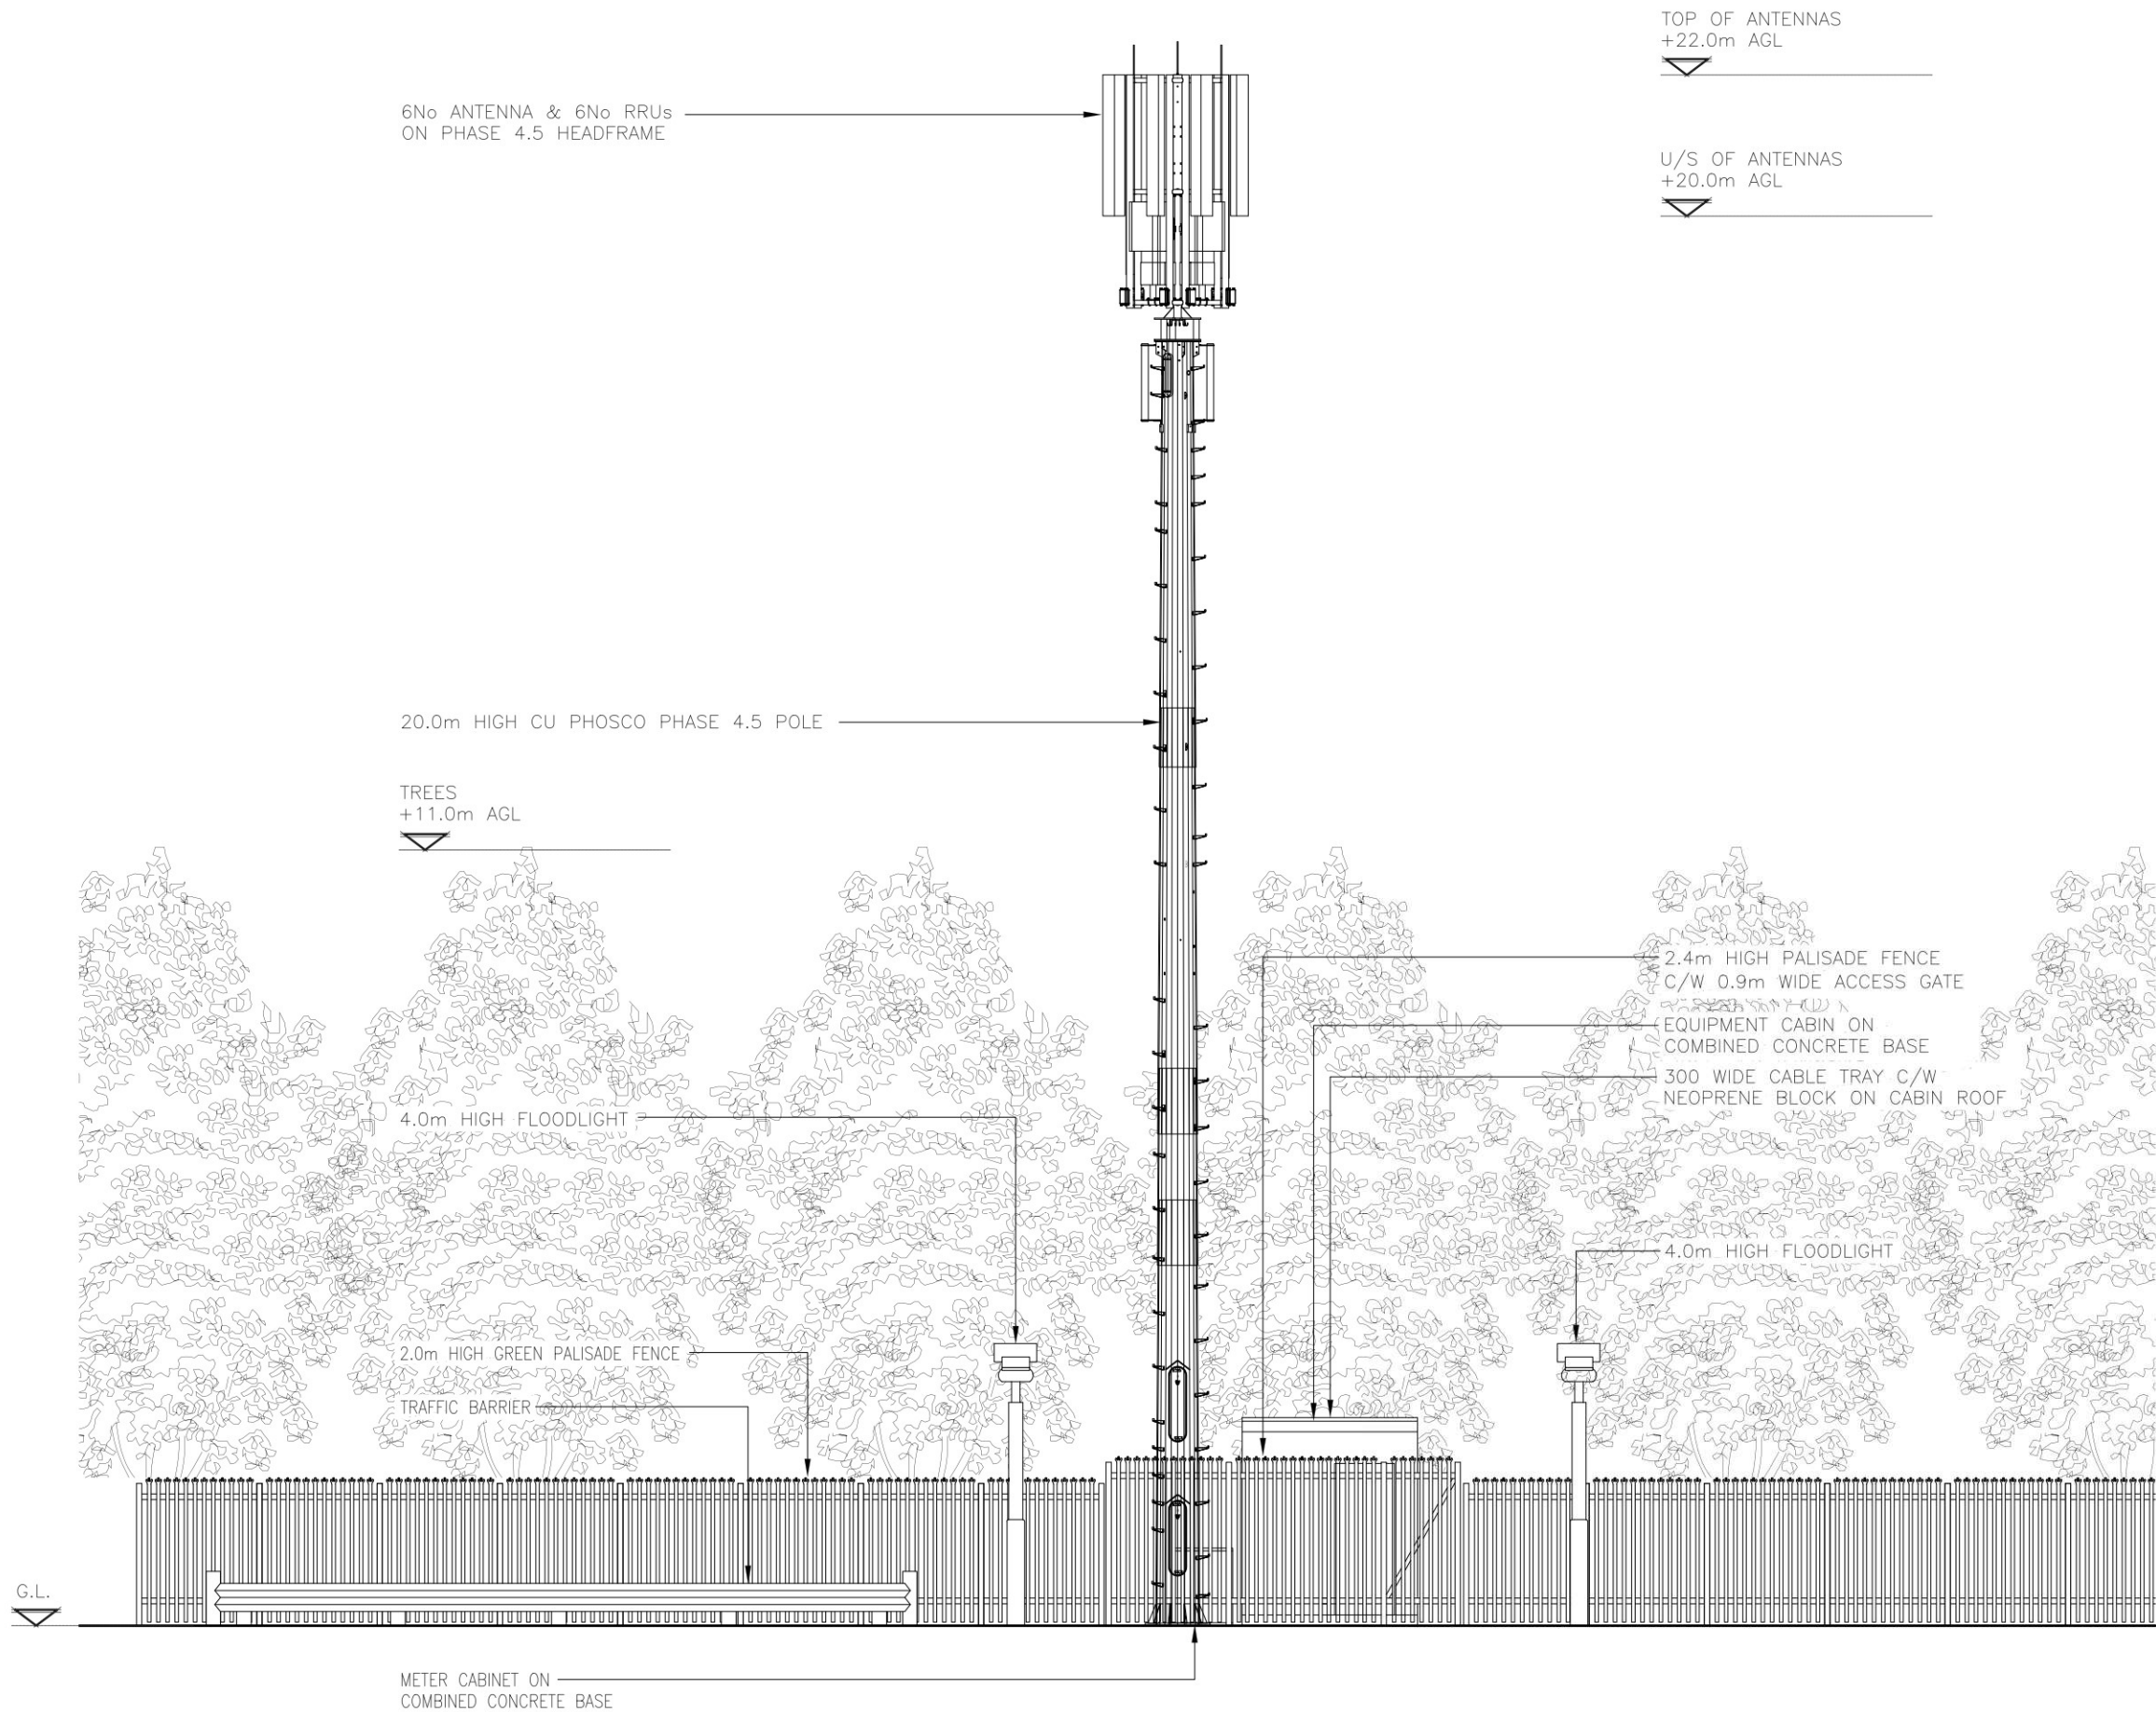

EXISTING SOUTH WEST ELEVATION
(1:100)

ALL DIMENSIONS ARE IN mm UNLESS NOTED OTHERWISE

N.G.R | E: 385165 N: 402452

NOTES:

REV	MODIFICATION	BY	CH	DATE
A	Issued for Approval	KS	SSH	09.12.20



Unit E, Madison Place, Northampton Road,
Manchester, M40 5AG
Tel: 0161 785 4500
Fax: 0161 785 4501
Web: www.clarke-telecom.com



CORNERSTONE - BEACON 3

Cell Name	Opt.
NORTH MANCHESTER GENERAL HOSPITAL	A

Cell ID No		
CORNERSTONE	TEF	VF
121636_28 E311989	092725	01658


Site Address / Contact Details
NORTH MANCHESTER GENERAL HOSPITAL
CHEETHAM HILL
MANCHESTER
GREATER MANCHESTER
M8 5RB

Drawing Title:
EXISTING SITE ELEVATION

Purpose of issue:	Dwg Rev:
PLANNING	A

Drawing Number:	Pack Issue:
300	C

Surveyed By:	Original Sheet Size:	Pack Issue:
SSH	A3	C
Drawn: KS	Date: 09.12.20	Checked: SSH Date: 09.12.20

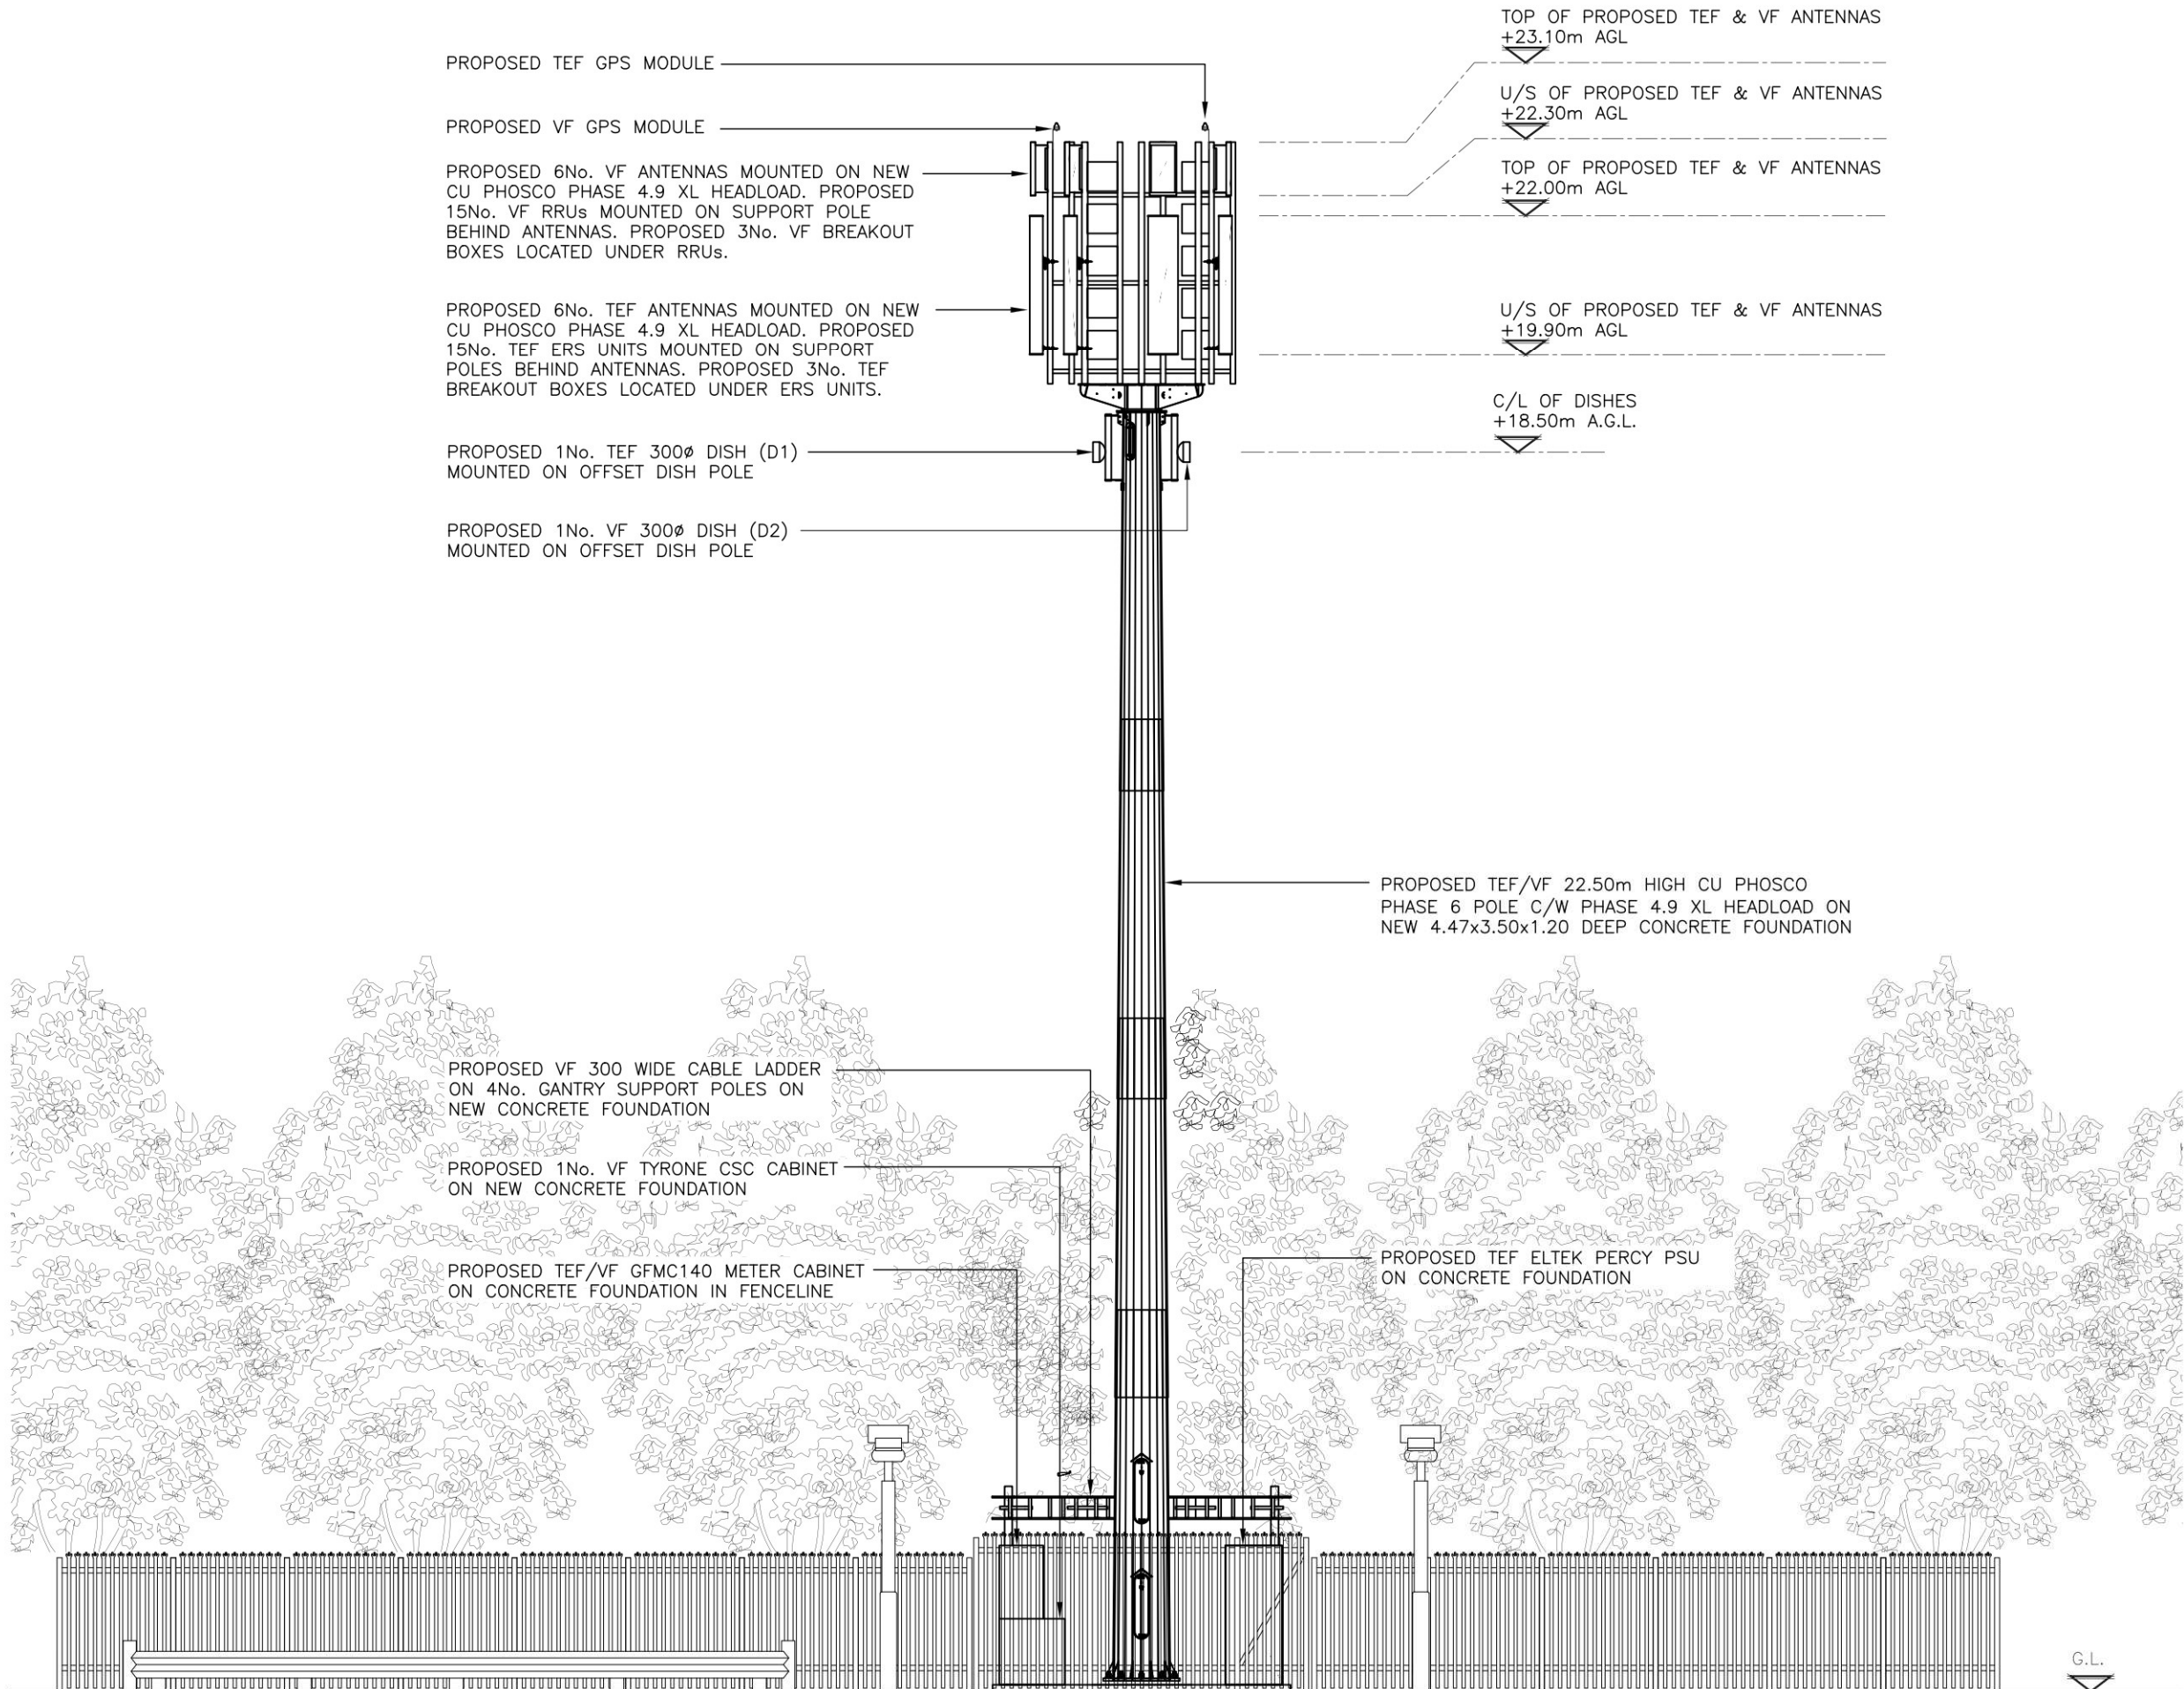

PROPOSED SOUTH WEST ELEVATION
(1:100)

The drawings comply with TEF & Vodafone Standard ICNIRP guidelines.
Designed in accordance with CORNERSTONE document: SDN0013 & SDN0009

ALL DIMENSIONS ARE IN mm UNLESS NOTED OTHERWISE

N.G.R | E: 385165 N: 402452

NOTES:

***NOTE:-
EXISTING 20.0m HIGH CU PHOSCO PHASE 4.5 POLE, EXISTING METER CABINET, EXISTING EQUIPMENT CABIN AND EXISTING CONCRETE BASE ALL TO BE REMOVED AND REPLACED WITH NEW POLE, EQUIPMENT AND CONCRETE BASE

C	Site Design Updated	KS	-	17.01.23
B	Dish details added	DP	MC	14.01.21
A	Issued for Approval	KS	SSH	09.12.20

REV	MODIFICATION	BY	CH	DATE
-----	--------------	----	----	------

CLARKE
telecom
Unit E, Madison Place, Northampton Road,
Manchester, M40 5AG
Tel: 0161 785 4500
Fax: 0161 785 4501
Web: www.clarke-telecom.com

O₂

CORNERSTONE - BEACON 3

Cell Name	Opt.
NORTH MANCHESTER GENERAL HOSPITAL	A

Cell ID No		
CORNERSTONE	TEF	VF
121636_28 E311989	092725	01658

Site Address / Contact Details	
NORTH MANCHESTER GENERAL HOSPITAL CHEETHAM HILL MANCHESTER GREATER MANCHESTER M8 5RB	

Drawing Title: PROPOSED SITE ELEVATION			
Purpose of issue: PLANNING			Dwg Rev: C
Drawing Number: 301			Pack Issue: C
Surveyed By: SSH	Original Sheet Size: A3		
Drawn: KS	Date: 09.12.20	Checked: SSH	Date: 09.12.20