


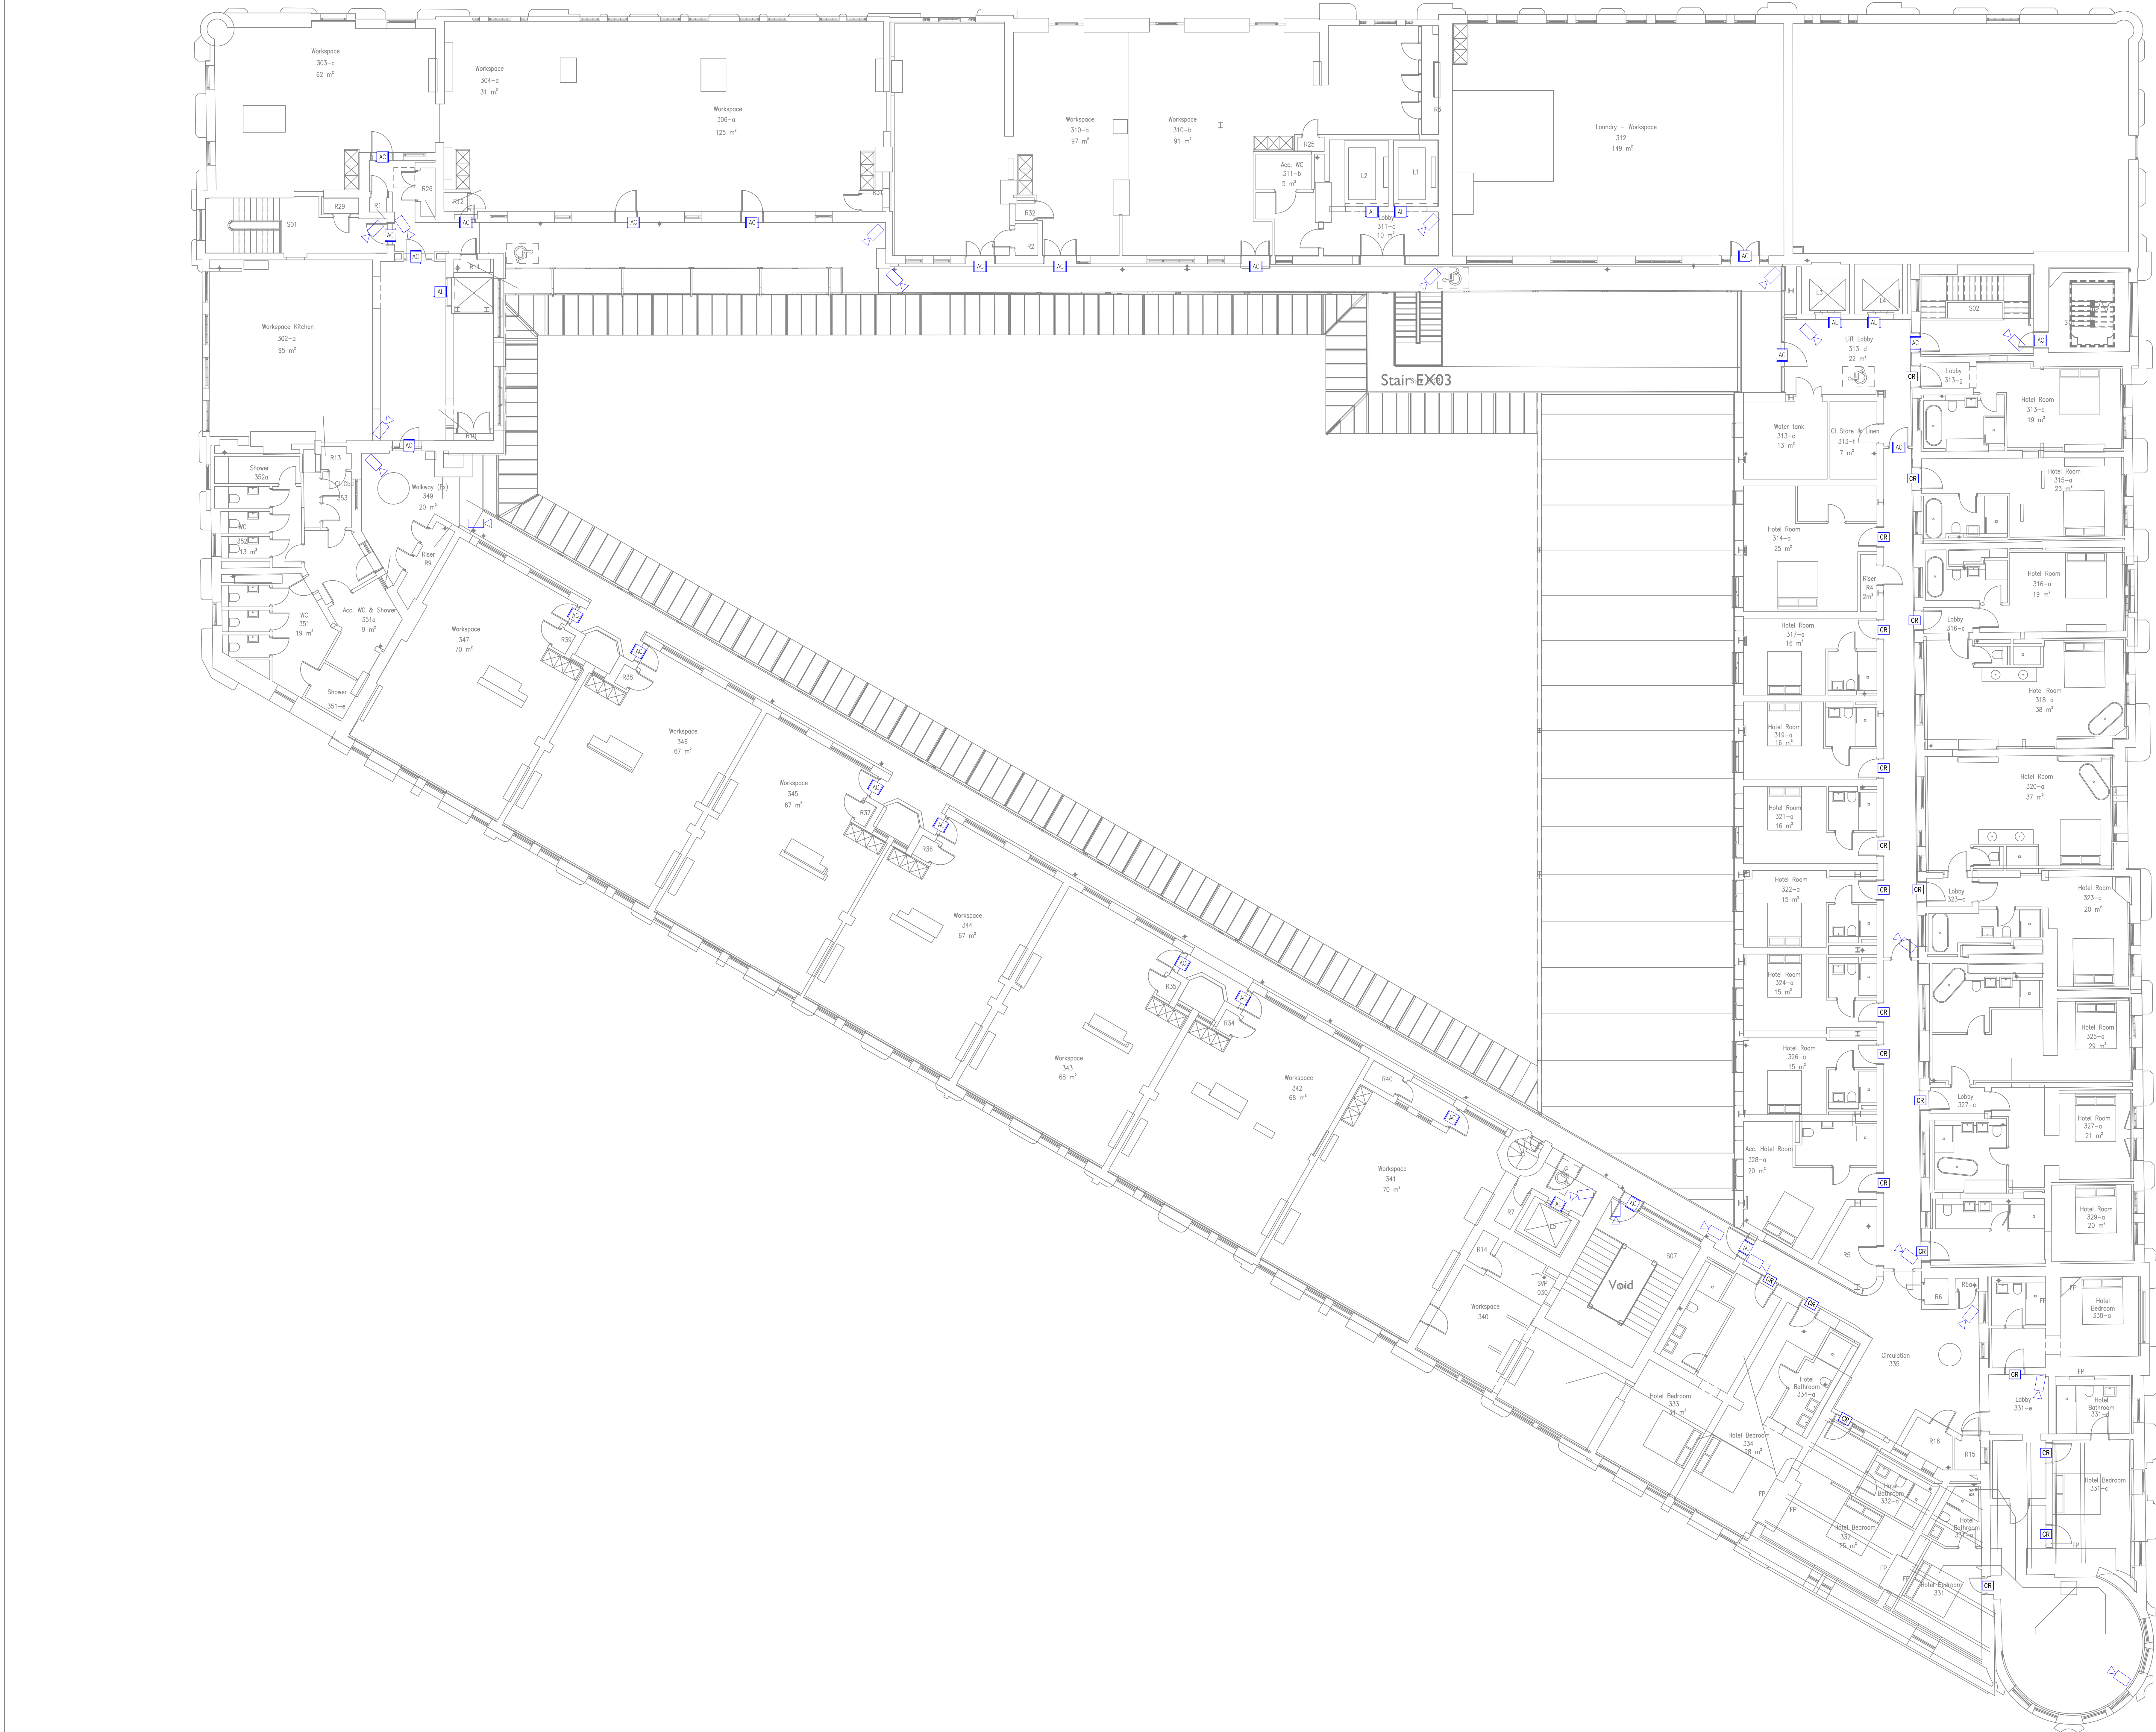

- NOTES
1. DO NOT SCALE FROM THIS DRAWING
 2. ALL DIMENSIONS TO BE CHECKED ON SITE BY THE CONTRACTOR PRIOR TO PREPARATION OF SHOP DRAWINGS, FABRICATION OF PARTS, ORDERING MATERIALS OR COMMENCING WORKS
 3. THIS DRAWING IS TO BE READ IN CONJUNCTION WITH ALL OTHER CONSULTANTS DRAWINGS, SPECIFICATIONS AND SCHEDULES.
 4. ANY PENETRATION THROUGH FLOOR, SEEX STRUCTURAL ENGINEERS APPROVAL, BEFORE COMMENCEMENT.
 5. ALL PLANT AND EQUIPMENT SHALL BE INSTALLED FULLY IN ACCORDANCE WITH MANUFACTURER'S RECOMMENDATIONS

LEGEND

- AC CCTV CAMERA
- WP WEATHER PROOF CCTV CAMERA IP65
- AC ACCESS CONTROLLED DOOR COMPRISED OF: MAGLOCK (PSU) GREEN BREAK GLASS PUSH TO EXIT BUTTON (MANUFACTURER - SALTO BLUENET - WIRELESS & W+I (BASIC SYSTEM)
- AL ACCESS CONTROL FOR LIFT (FINAL DETAILS TO BE CONFIRMED WITH LIFT SPECIALIST/MANUFACTURER)
- DI DOOR INTERCOM PHONE SYSTEM
- CR CARD READER (HOTEL ROOM) TYPICALLY OFF-LINE. FINAL DETAILS TBC BY THE ACCESS CONTROL SPECIALIST (MANUFACTURER - AFSO SALTO - RFID, WIRELESS & BLUETOOTH SMART)
- DR DOOR HOLD OPEN DEVICES

NOTE

ALL DOOR HOLD OPEN DEVICES, ACCESS CONTROLLED DOORS & LIFTS TO BE INTERFACED WITH THE FIRE ALARM SYSTEM

FOR COMMENT
NOT FOR SITE USE

16.08.22	TENDER ISSUE	T6	AM	SI
13.04.22	TENDER ISSUE	T5	AL	SE
07.02.22	TENDER ISSUE	T4	AL	IS
24.11.21	BUILDING LAYOUT UPDATED SECURITY LAYOUT AMENDED TO SUIT	T3	AL	IS
02.06.21	INCORPORATES INTERIOR DESIGNER COMMENTS	T2	FR	SE
21.05.21	TENDER ISSUE	T1	FR	SE
26.03.21	INTERIM ISSUE FOR CLIENT COMMENTS	P1	FR	FR
26.02.21	PRELIMINARY ISSUE	P1	FR	FR
Date	Description	Rev	Drawn	Scale

CONSOLUX
CONSOLUX M&E CONSULTING LTD.
MECHANICAL & ELECTRICAL CONSULTING ENGINEERS

Liverpool Office
35 Piccadilly
Liverpool L3 5BW
Tel: +44 (0)207 734 3030
Fax: +44 (0)207 617 7788
mail@consolux.co.uk

The Cavern Exchange
Liverpool L3 5BW
Tel: +44 (0)151 758 9469
Fax: +44 (0)151 709 7184
www.consolux.co.uk

Project
LONDON ROAD FIRE STATION
FIRE STATION, LONDON ROAD
MANCHESTER, M1

Drawing Title
ELECTRICAL INSTALLATION SERVICES
THIRD FLOOR
SECURITY LAYOUT

Date	Design By	Drawn By	Scale
24.03.21	FR	FR	1:100

Issue Status
TENDER

Drawing Number
647-E-644-03-01

Rev
16