


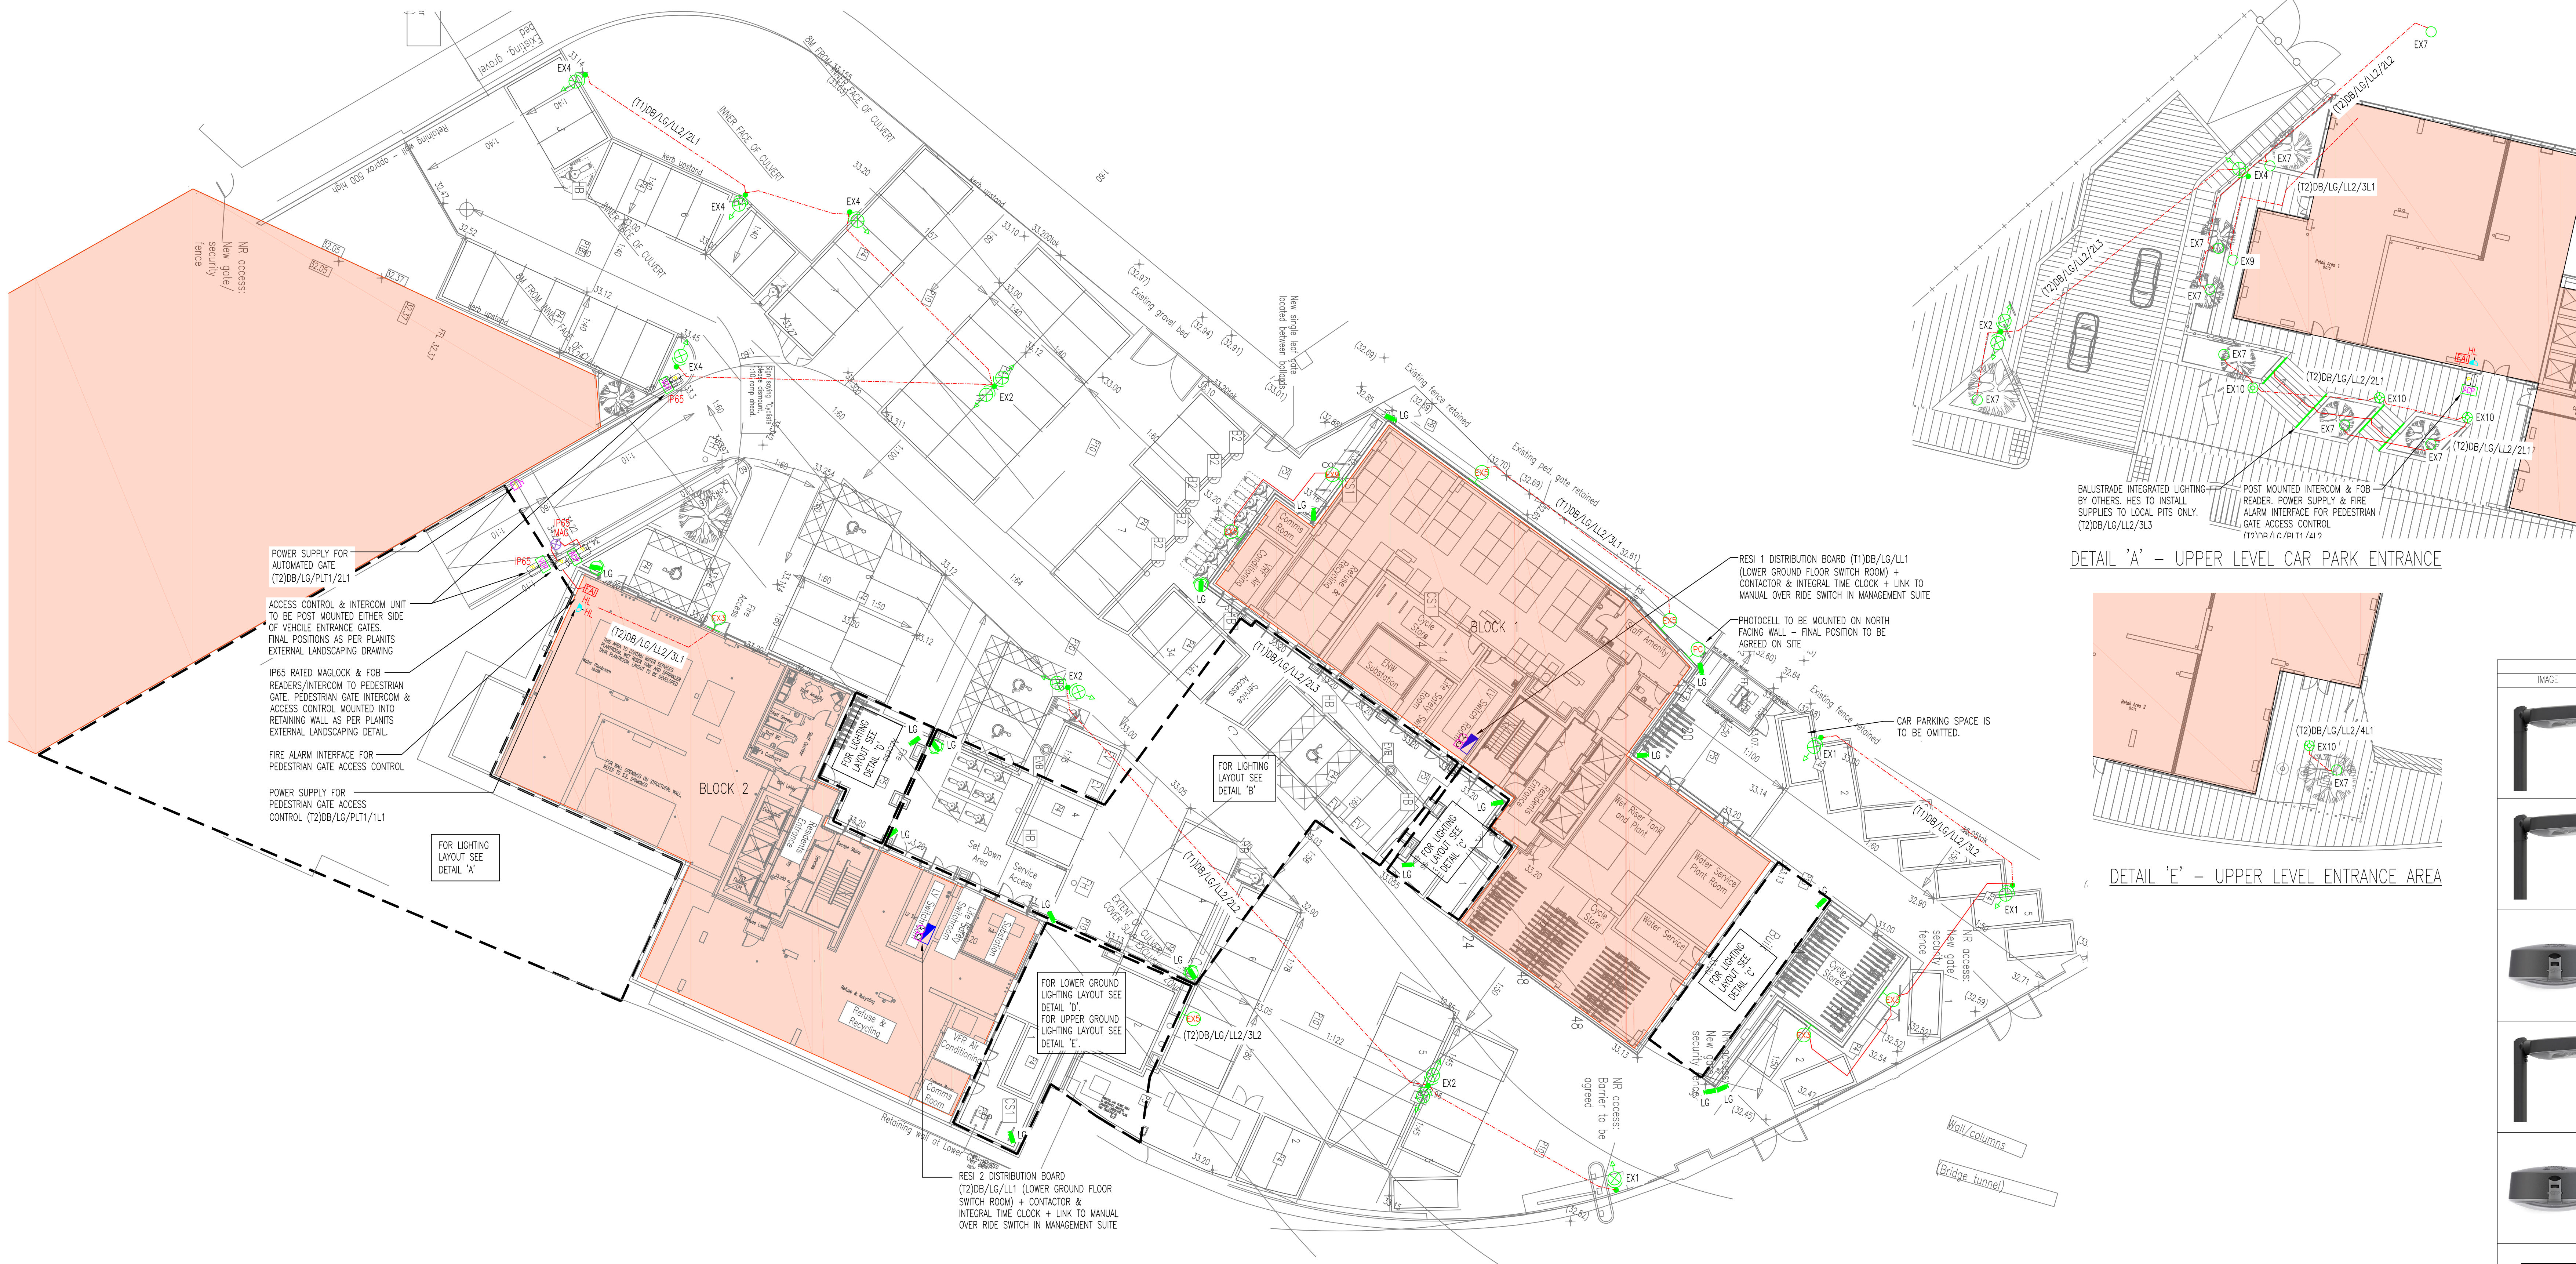


- NOTES**
- THIS DRAWING MUST BE READ IN CONJUNCTION WITH THE ELECTRICAL PERFORMANCE SPECIFICATION.
 - WIRING TO BUILDING MOUNTED EXTERNAL CCTV CAMERAS TO BE ROUTED THROUGH CEILING VOIDS AND FEED CAMERA CONCEALED FROM REAR OF BODY.
 - NO LOCAL POWER SUPPLIES ARE REQUIRED TO CCTV CAMERAS (ALL SUPPLIES TO BE TAKEN FROM PSU'S LOCATED WITHIN THE COMMS ROOM).
 - EACH EXTERNAL LIGHTING CIRCUIT TO BE SUPPLIED FROM EXTERNAL LIGHTING DB (LOCATED WITHIN LV SWITCHROOM) VIA INDIVIDUAL CONTACTOR CONTROLLED VIA PHOTOCELL AND 7 DAY MULTIZONE TIMSWITCH. NOTE: OVER RIDE SWITCH ON/OFF TO BE PROVIDED WITHIN THE MANAGEMENT OFFICE TO GIVE ON/OFF CONTROL OF ALL EXTERNAL LIGHTING.

LEGEND - GENERAL POWER

- COLOUR FIXED VANDAL RESISTANT MINI DOME CAMERA 470W/0.3LUX/792x596 PIXELS BUILDING MOUNTED WITH BRACKET AND REMOTE PSU
- 'LG' DENOTES LOWER GROUND FLOOR LOCATION
- 'UG' DENOTES UPPER GROUND FLOOR LOCATION
- 'VR' DENOTES VEHICLE NUMBER PLATE RECOGNITION CAMERA
- VANDAL RESISTANT DIGITAL ACCESS CONTROL PANEL WITH INTEGRAL INTERCOM FOR 2-WAY COMMUNICATION BETWEEN PEDESTRIAN ENTRY GATE & EACH APARTMENT & MANAGEMENT OFFICE. C/W INTEGRAL PROXIMITY READER (MOUNTING HEIGHT T.B.C.) & 2-WAY REMOTE RELEASE ON EXIT SIDE WITH PUSH TO RELEASE BUTTON ON THE EXIT TO THE PEDESTRIAN GATE
- VANDAL RESISTANT DIGITAL ACCESS CONTROL PANEL WITH INTEGRAL INTERCOM FOR 2-WAY COMMUNICATION BETWEEN PEDESTRIAN ENTRY GATE & EACH APARTMENT & MANAGEMENT OFFICE. C/W INTEGRAL PROXIMITY READER (MOUNTING HEIGHT T.B.C.) & PUSH TO RELEASE BUTTON ON THE EXIT TO THE PEDESTRIAN GATE
- VANDAL RESISTANT ACCESS CONTROL PANEL PROXIMITY FOB READER MOUNTED 1200MM AFTL TO TOP OF READER
- EXTERNAL IP65 RATED MAGLOCK
- BALUSTRADE INTEGRATED LIGHTING BY OTHERS.

DETAIL 'A' - UPPER LEVEL CAR PARK ENTRANCE

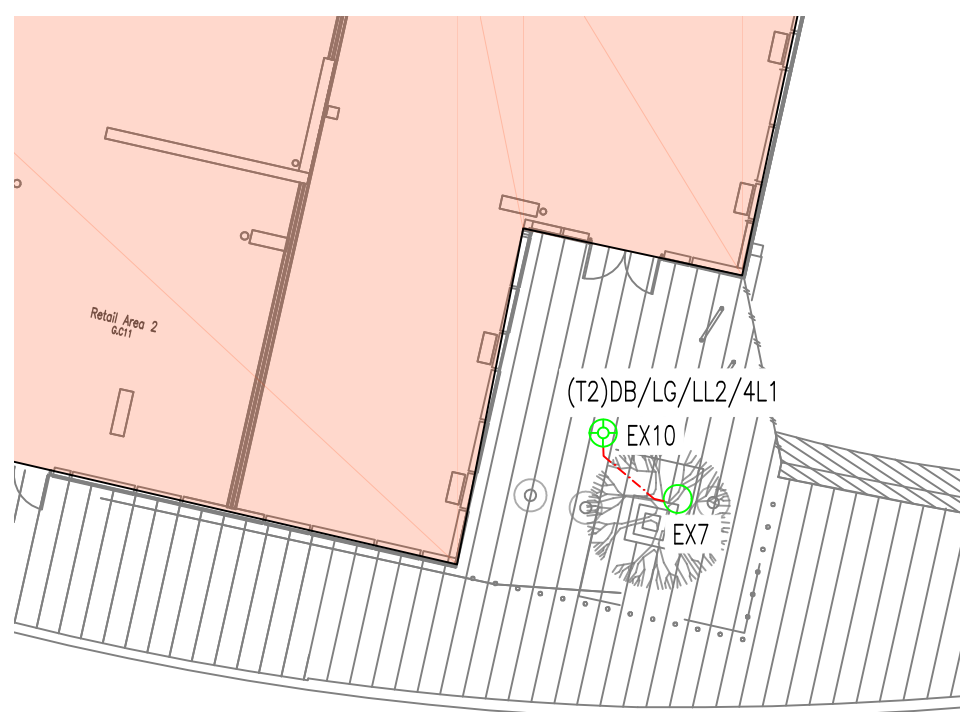


DETAIL 'E' - UPPER LEVEL ENTRANCE AREA

LEGEND - LIGHTING


IMAGE	SYMBOL	LABEL	ARRANGEMENT	DESCRIPTION
		EX1	SINGLE COLUMN MOUNTED (4M)	COLUMN MOUNTED LED FLOODLIGHT WITH WIDE ASYMMETRIC DISTRIBUTION, 3000K, 4739 LUMENS, 35W AS ATP ENUR MICRO
		EX2	TWIN COLUMN MOUNTED (4M)	COLUMN MOUNTED LED FLOODLIGHT WITH WIDE ASYMMETRIC DISTRIBUTION, 3000K, 4739 LUMENS, 35W AS ATP ENUR MICRO
		EX3	WALL MOUNTED	WALL MOUNTED LED FLOODLIGHT WITH WIDE ASYMMETRIC DISTRIBUTION, 3000K, 4739 LUMENS, 35W AS ATP ENUR MICRO
		EX4	SINGLE COLUMN MOUNTED (4M)	COLUMN MOUNTED LED FLOODLIGHT WITH LONG ASYMMETRIC DISTRIBUTION, 3000K, 4658 LUMENS, 35W AS ATP ENUR MICRO
		EX5	WALL MOUNTED	WALL MOUNTED LED FLOODLIGHT WITH LONG ASYMMETRIC DISTRIBUTION, 3000K, 4658 LUMENS, 35W AS ATP ENUR MICRO
		EX7	GROUND RECESSED	ADJUSTABLE GROUND MOUNTED SPOTLIGHT WITH MEDIUM BEAM ANGLE AS ARES MARTINA
		EX8	CEILING RECESSED	CEILING RECESSED LED, 14.5W, AS PHILIPS 100 SERIES, FINISHED IN BLACK
		EX9	SURFACE MOUNTED	INDO CANOPY LIGHT, 60W, FINISHED IN BLACK. (BY LIGHTING PROJECT SOLUTIONS)
		EX10	POST TOP	2.9W 39W LED 4000K DECORATIVE POST TOP LUMINAIRE AS CHIONI LIGHTING TRET UP (BY LIGHTING PROJECT SOLUTIONS)




DETAIL 'B' - UNDERSIDE OF AMENITY LINK BRIDGE USING FITTING EX8 - 100 SERIES BY PHILIPS

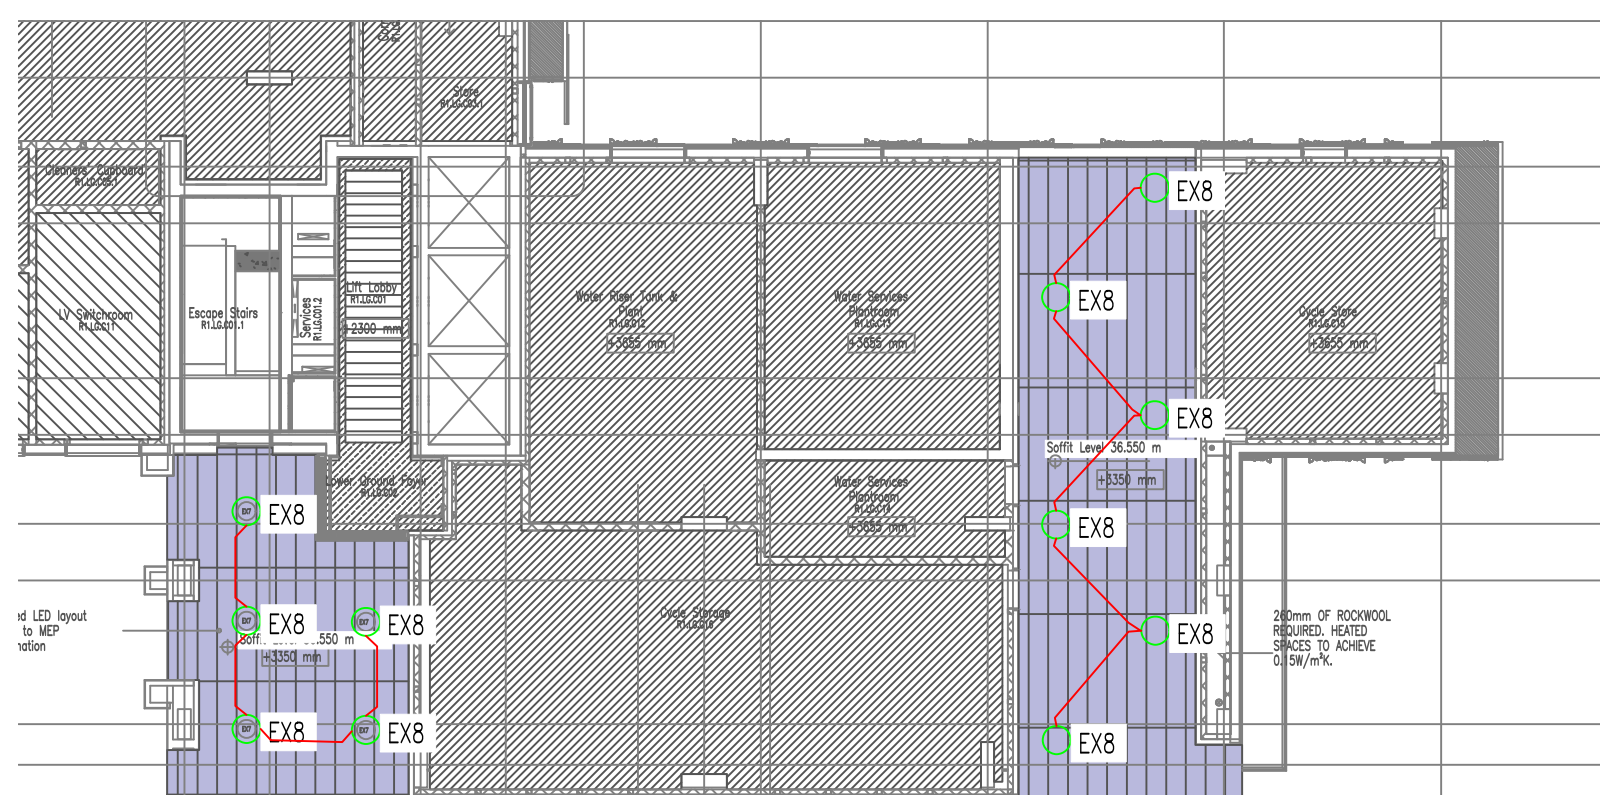

DETAIL 'C' - BLOCK 1 UNDERCOVER AREAS

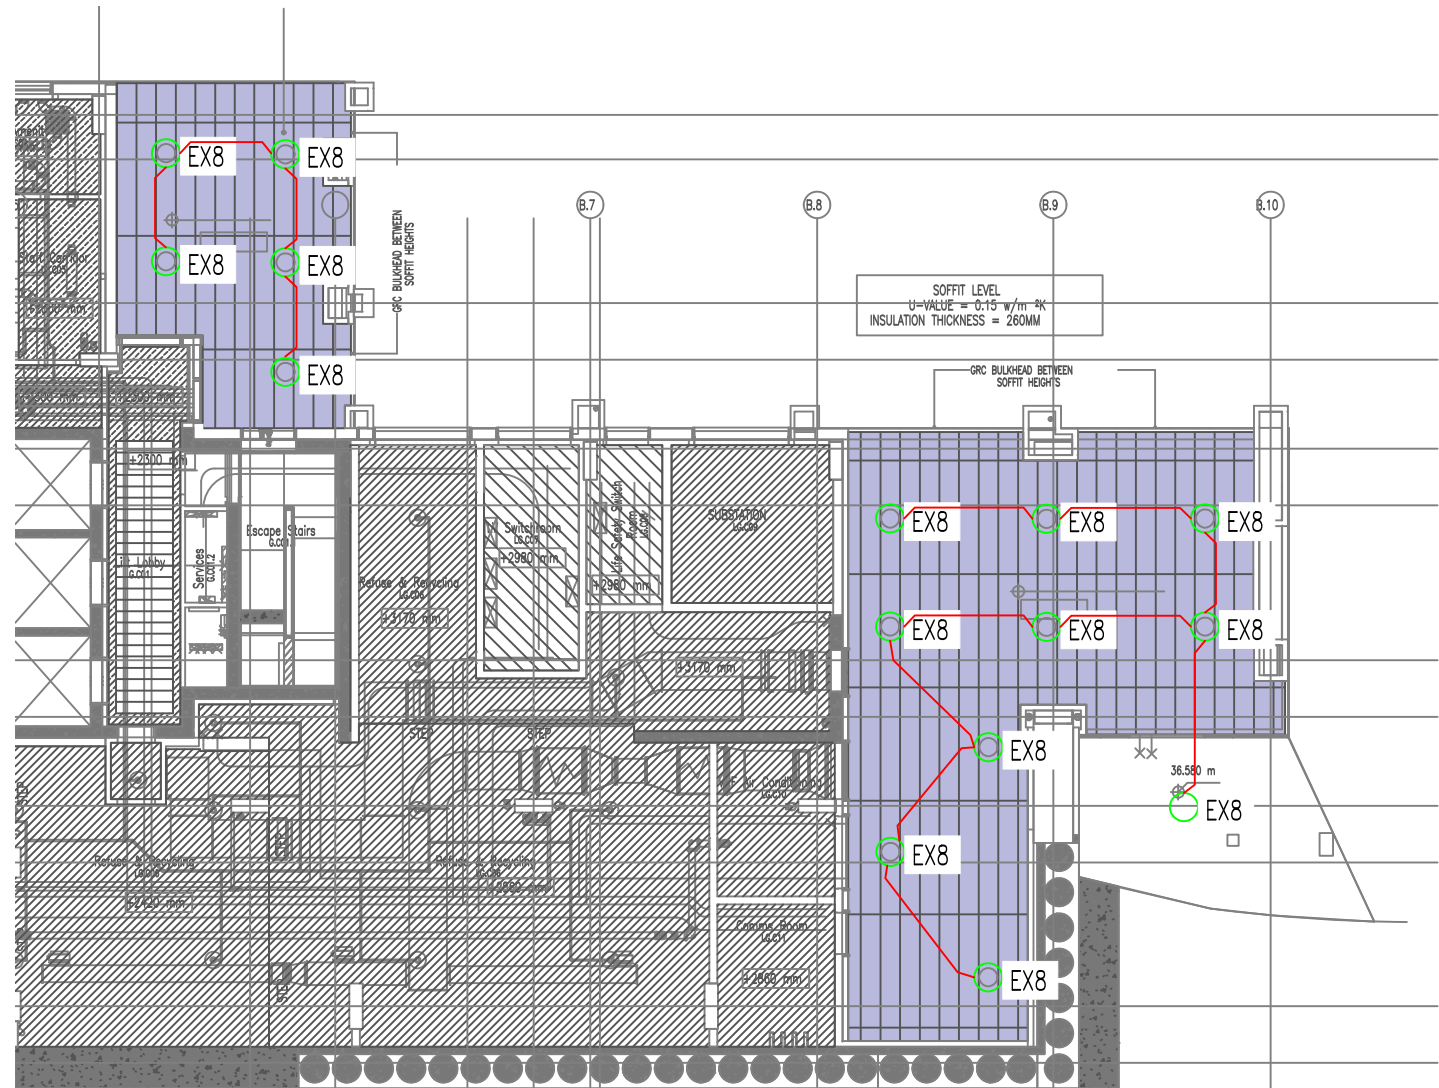

DETAIL 'D' - BLOCK 2 UNDERCOVER AREAS

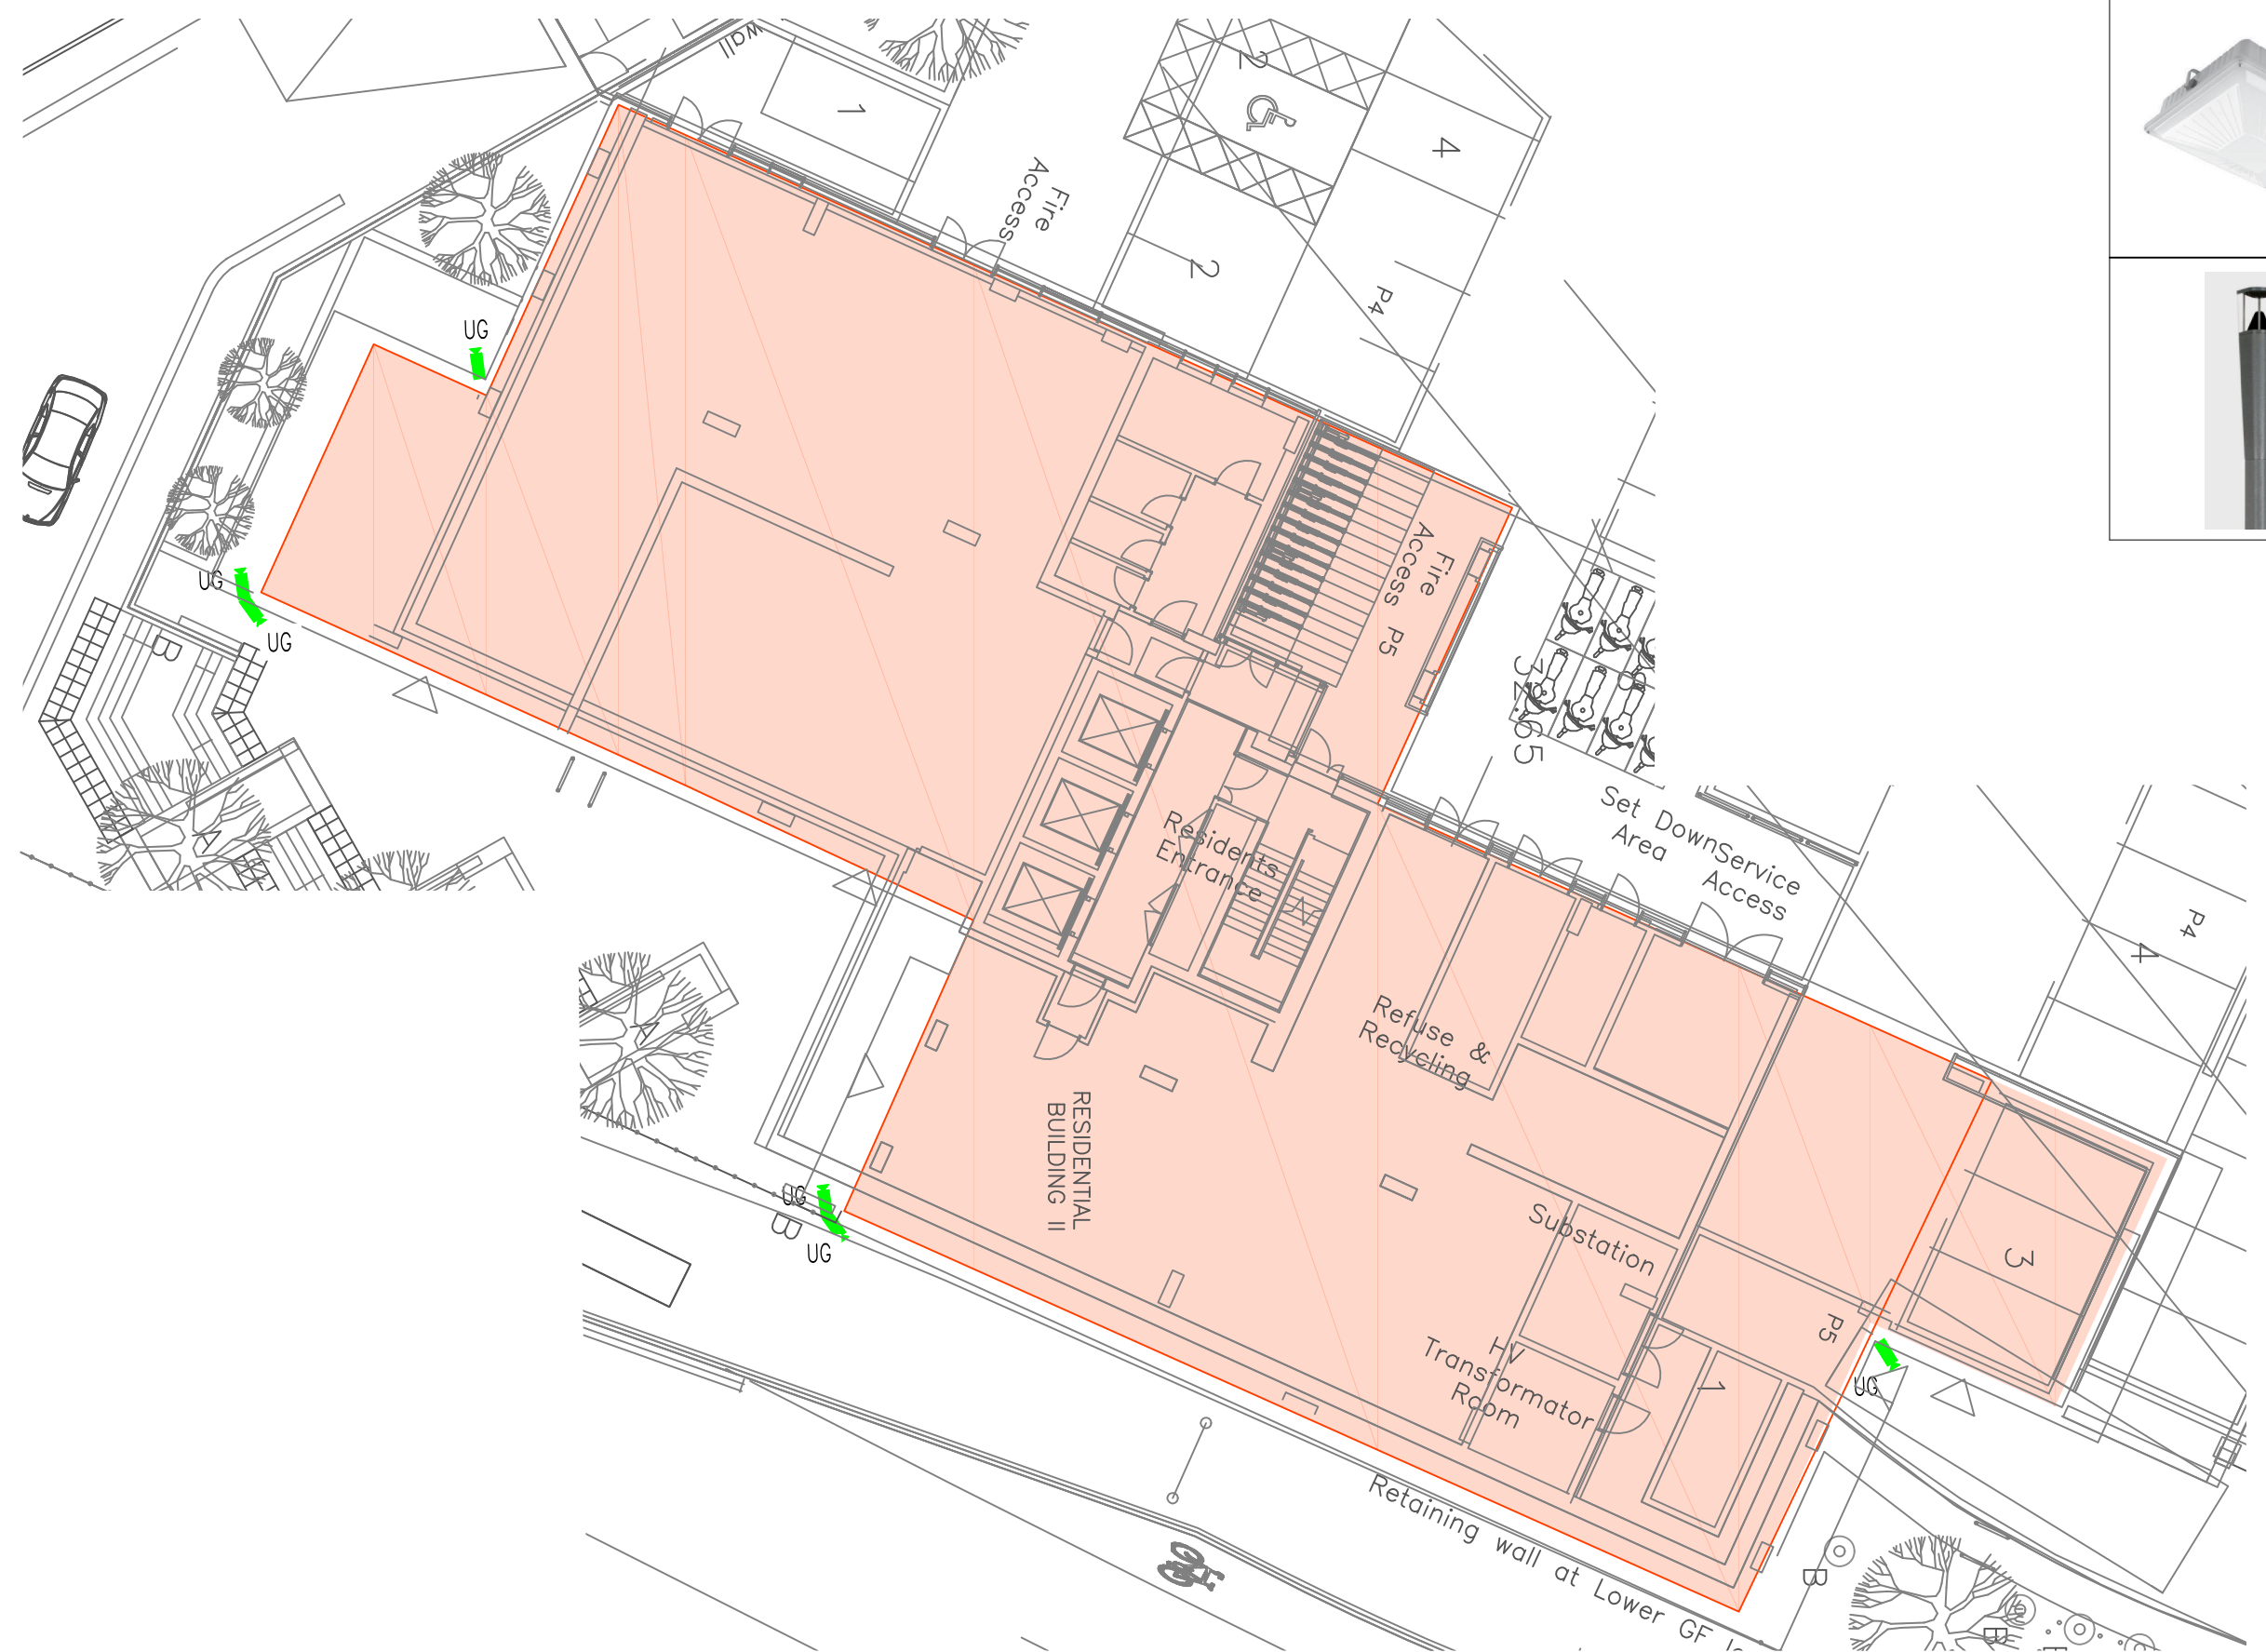

BLOCK 2 - UPPER GROUND FLOOR CCTV CAMERA LAYOUT

C04	Updated to suit new xref	SC 19/01/2023	DM 19/01/2023
C03	Updated following Regalis interface review	SC 17/09/2022	DM 17/09/2022
C02	Revised to updated landscape design and 3rd substation	SC 09/03/2022	DM 09/03/2022
C01	Construction issue	SC 06/03/2021	DM 06/03/2021
Rev	Amendment	Checked By Date	Approved By Date

HE Simm
ENGINEERING EXCELLENCE

HEAD OFFICE
Gurnee 5 & 6 Spinnaker House
141 Sefton Street
Liverpool L8 5SH

Tel: 0151 707 3222
Email: info@hesimm.co.uk
hesimm.co.uk

Project Name:
New Victoria
Sheet Title:
Tower 1 & 2
Site Plan
External Lighting & Security Layout
Scale (© A0):
NTS
BS1192 Document Number:
VIC-HES-22-XX-DR-E-60001

Drawn: RIBA Stage:
MG 5 - Construction

Status:
A5
Revision:
C04