




ABB CHARGE POST FOUNDATION PLAN
SCALE 1:50

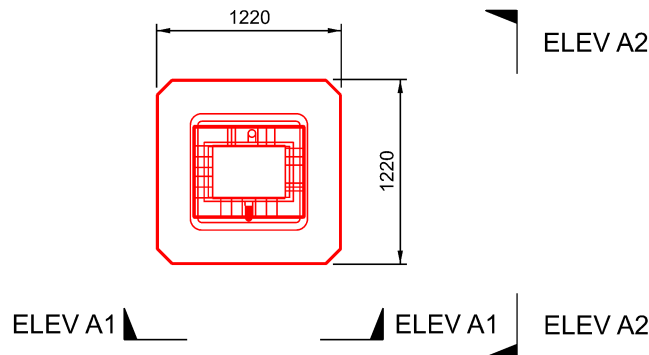


HP CABINET FOUNDATION PLAN
SCALE 1:50

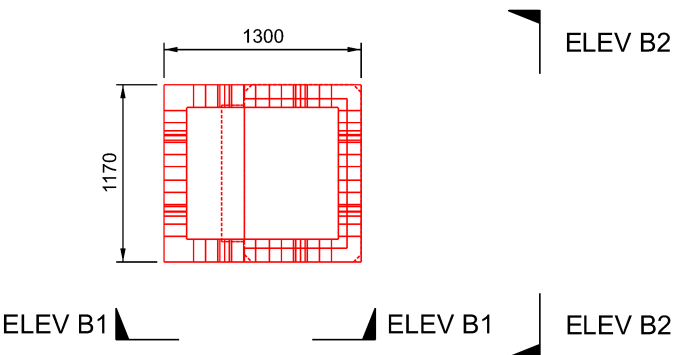


ELEVATION A1
SCALE 1:50

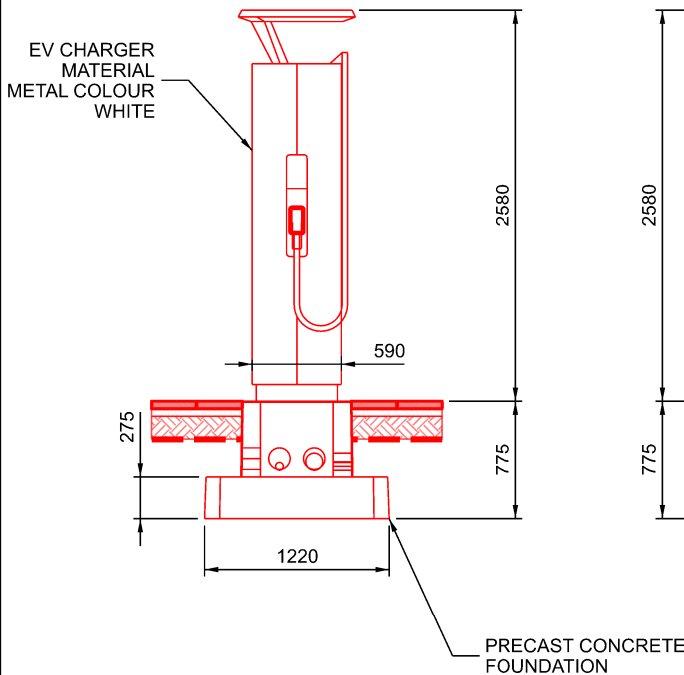


ELEVATION A2
SCALE 1:50

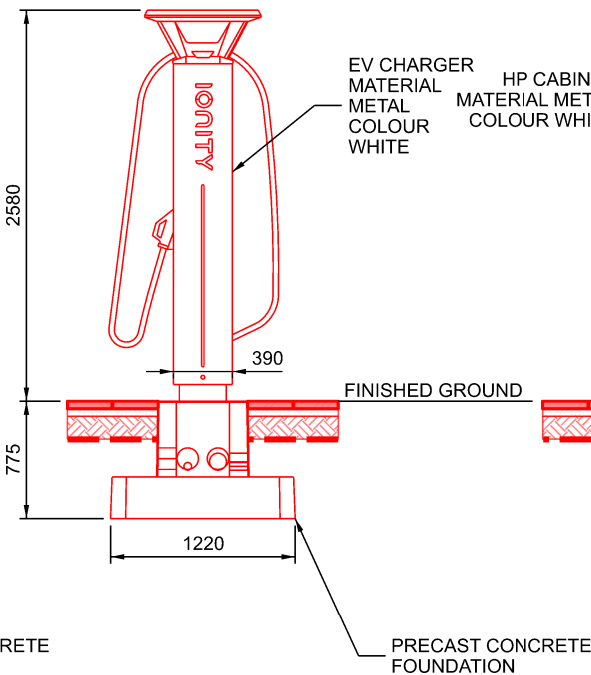



ELEVATION B1
SCALE 1:50

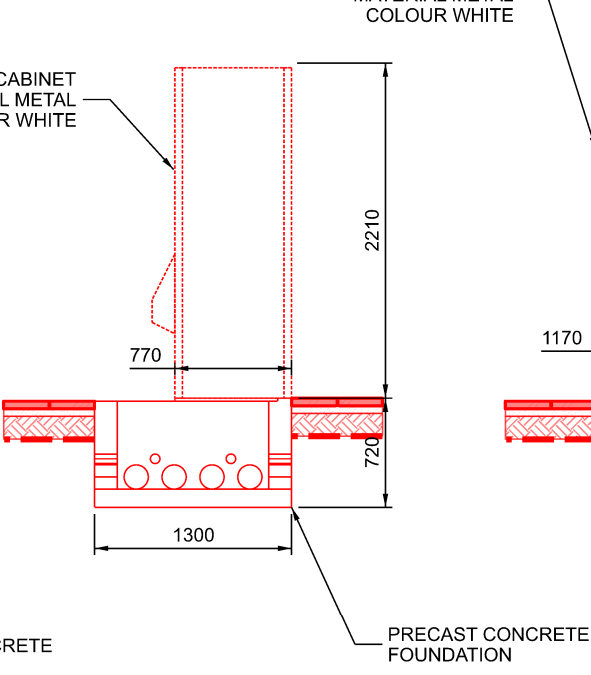

ELEVATION B2
SCALE 1:50

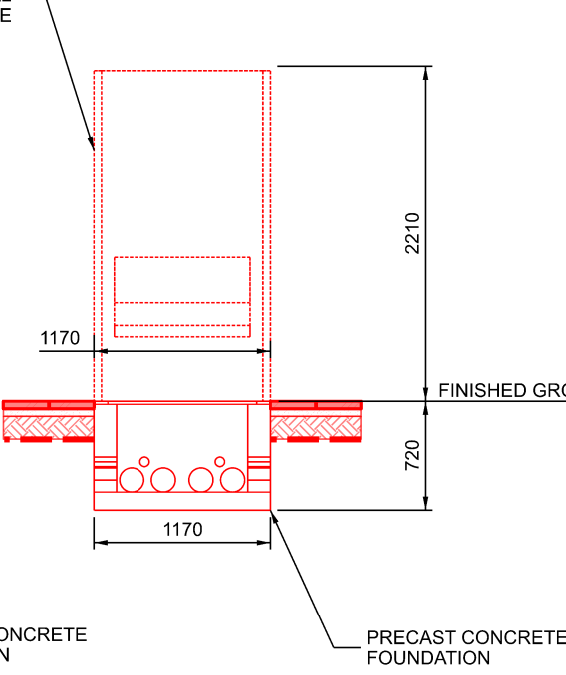

LV PANEL ELEVATION
SCALE 1:50

 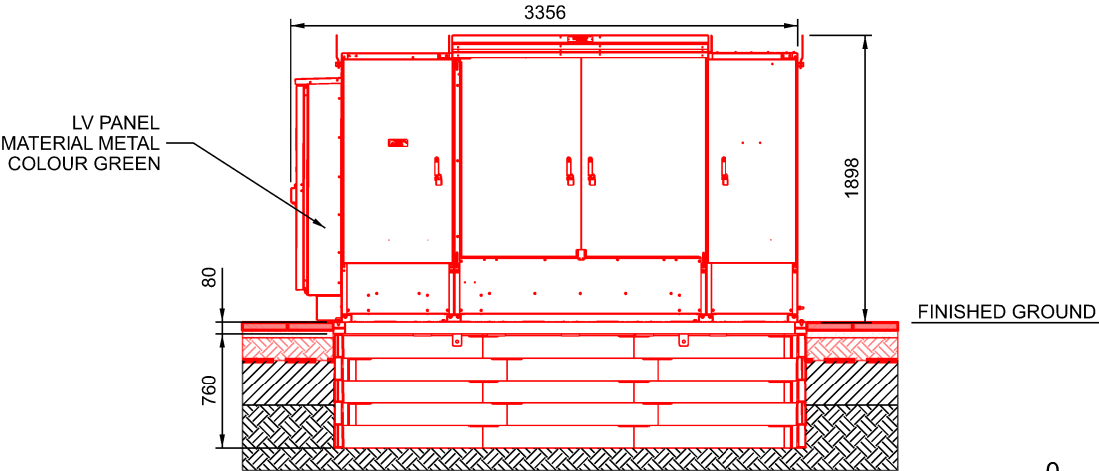

NOTES:

COLOUR CONVENTIONS

- BLACK - EXISTING OR UNCHANGED
- BLUE - MODIFIED OR TO BE MOVED
- GREEN - REDUNDANT OR TO BE REMOVED
- RED - PROPOSED OR ADDITIONAL
- PURPLE - WORKS BY OTHERS

P02	07/02/23	REVISED AS PER CLIENT COMMENT	RK	Chk	App
P01	18/01/23	ISSUED FOR REVIEW	RK	Chk	App
Rev	Date	Description of Revisions	Drawn	Chkd	Appr

S0 - WORK IN PROGRESS



Poise Group Ltd
124 City Road
London
EC1V 2NX

Contractor(s)
IONITY
Ionity GmbH
Moosacher Strasse 84,
D-80809 Munich
Germany

Project
**IONITY
MANCHESTER DEBDAL**

Drawing Title
**IONITY MANCHESTER DEBDAL
ELECTRIC VEHICLE CHARGING
TYPICAL PLANNING DETAILS**

Designed	D SHILLIBEER	Signed		Date	26/03/22
Drawn	D SHILLIBEER	Signed		Date	14/09/22
Checked	Checked	Signed		Date	Date3
Approved	Approved	Signed		Date	Date4
Scale(s)	R.T.D	ELR & Mileage	ELR&Mileage	Sheet	01 of 01
Alternative Reference	-			Revision	P02
Drawing Number	3195-POI-DRG-CIV-200018				