




N°	DATE	DESCRIPTION
REVISION		

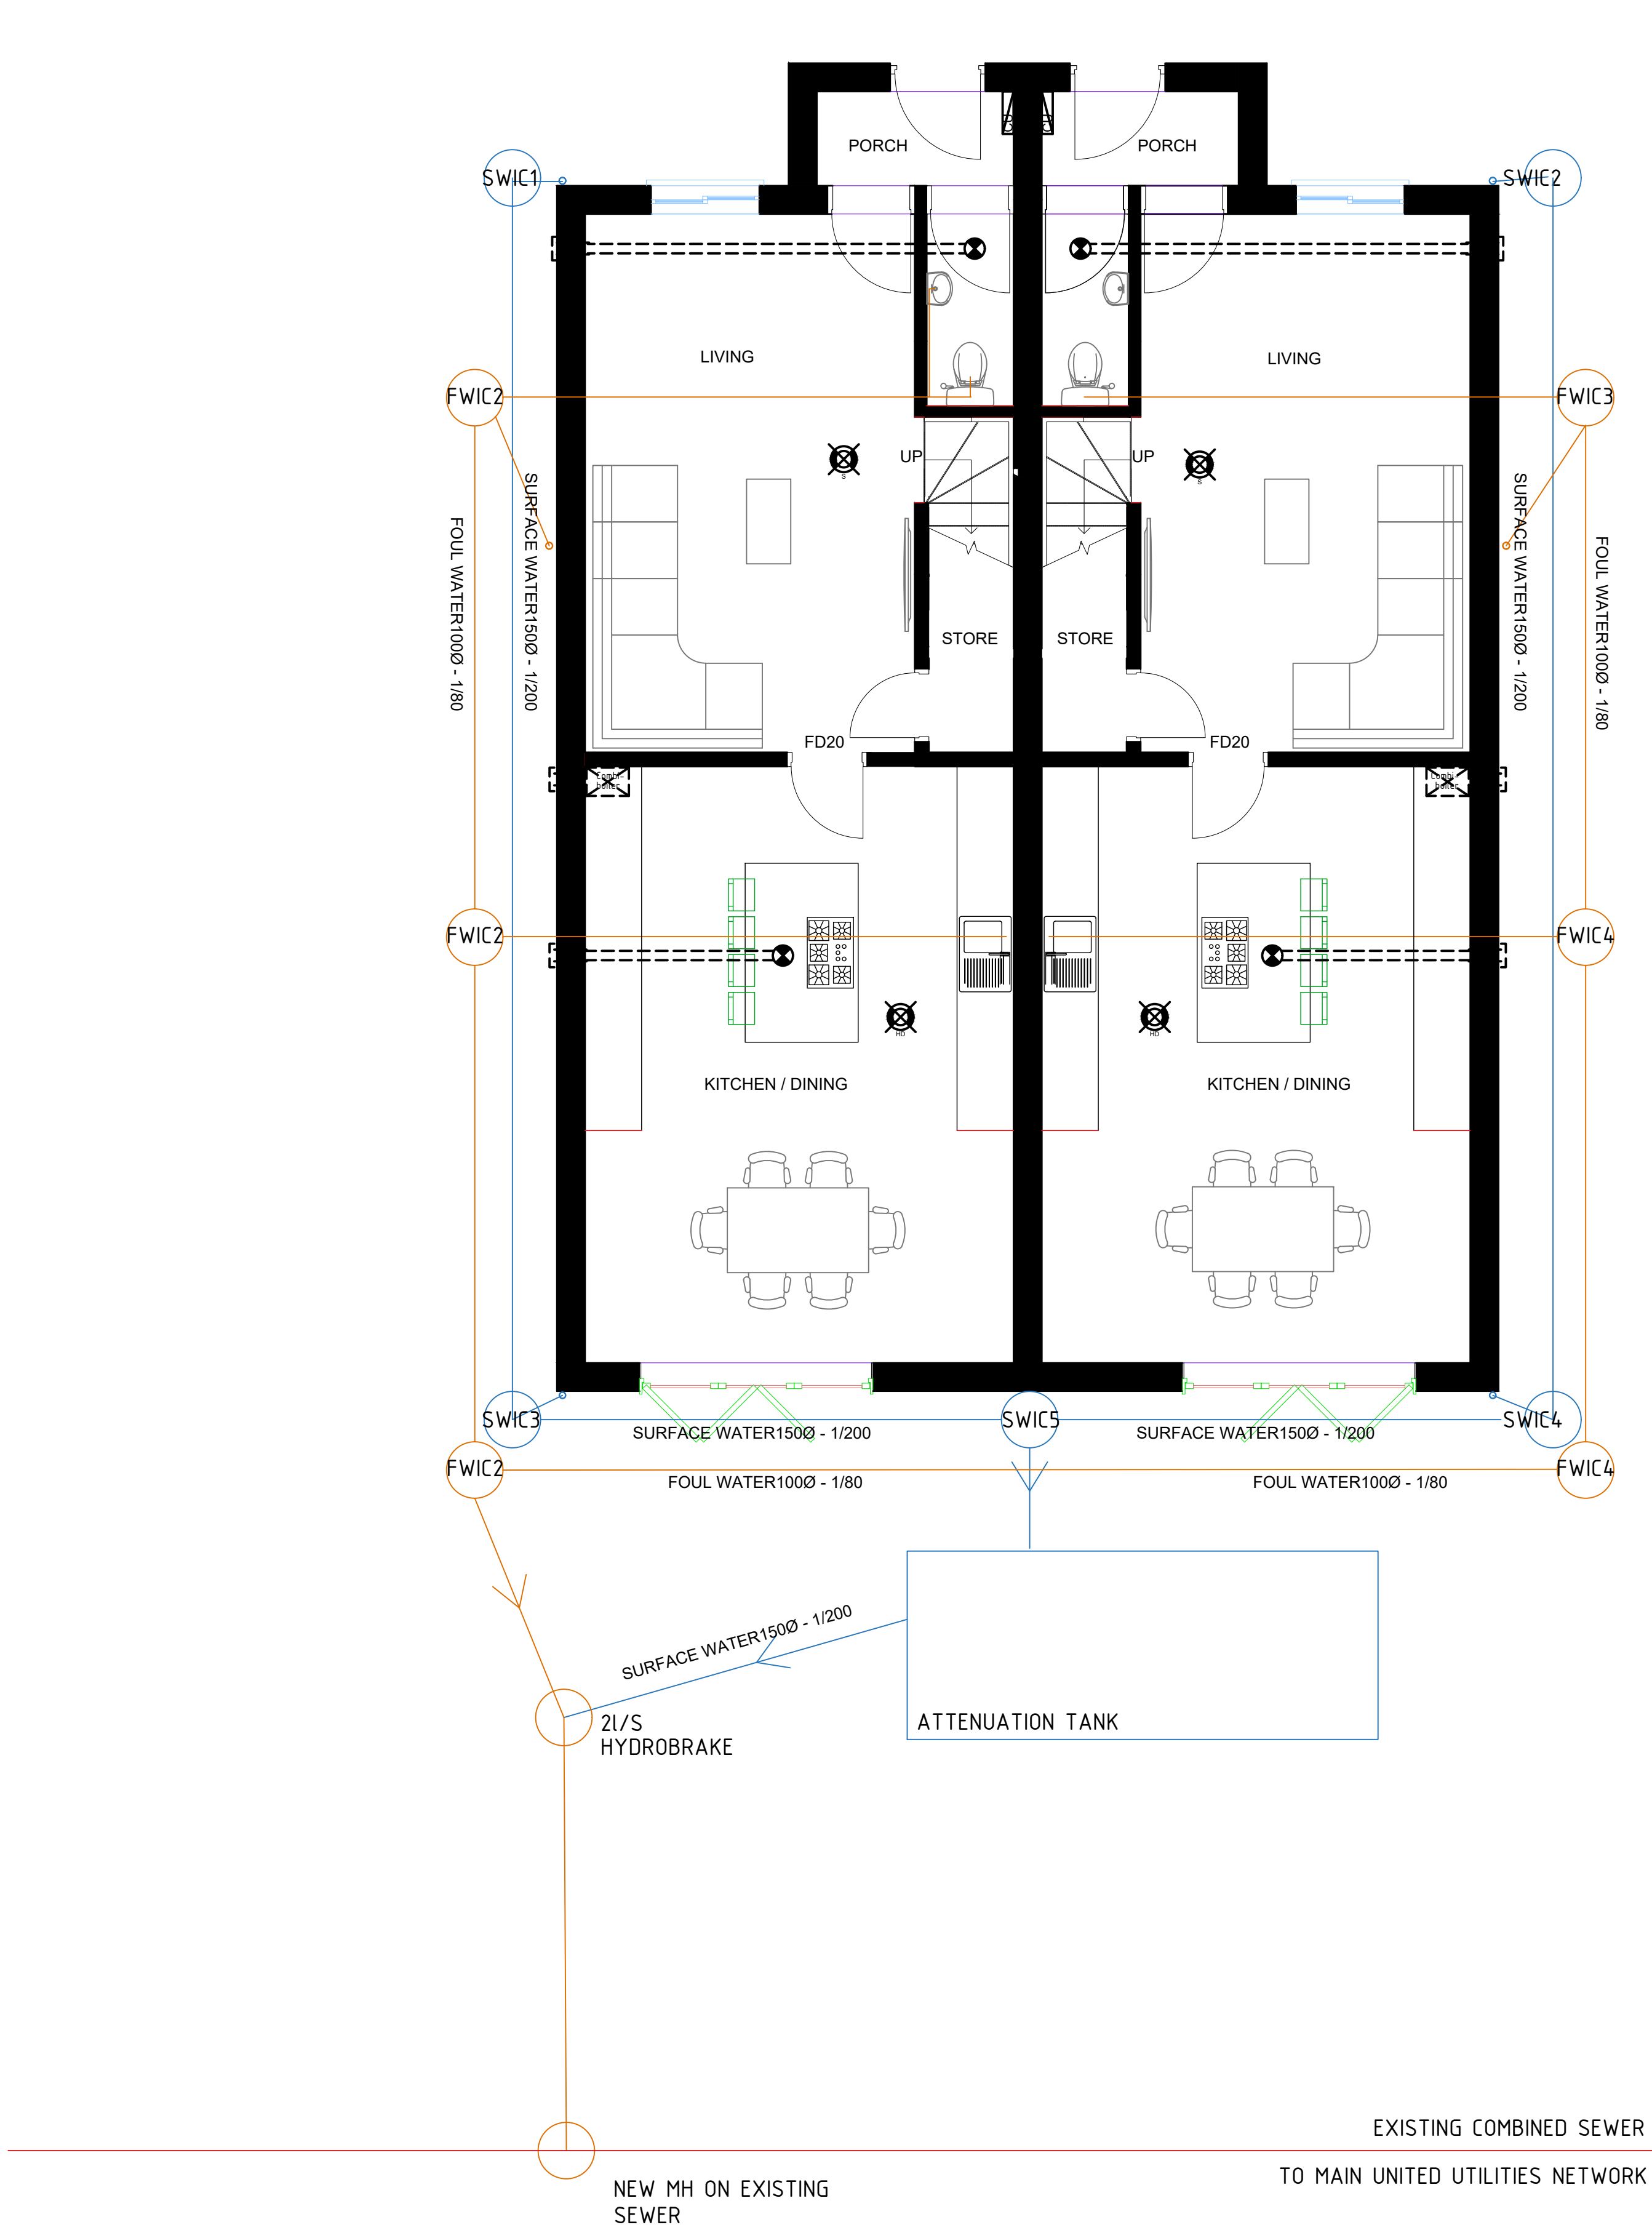


HARDSTANDING AREA
PARKING
2 X 2.4 X 5.5 = 26.4
PATHS
2 X 0.75 X 13 = 19.5
REAR PATIO
3 X 12 = 36
ROOF
10 X 12 = 120
TOTAL = 212m2

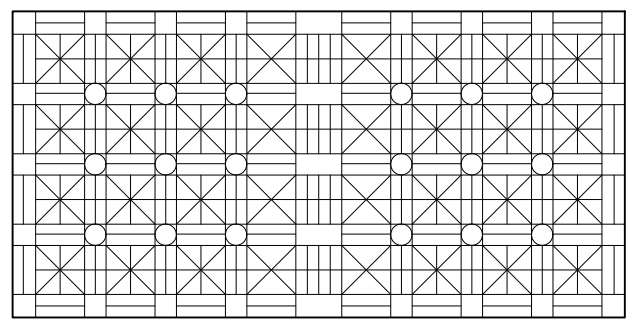

PLAN

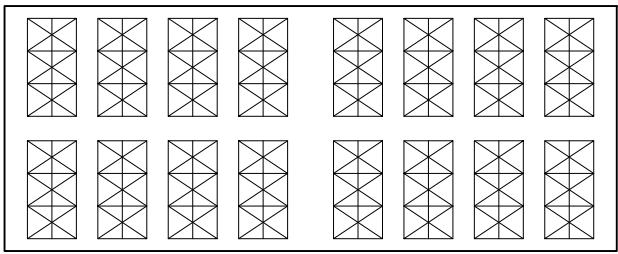


SIDE

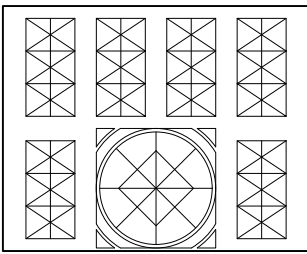

FRONT

AQUACELL UNIT 6LB075
ONE UNIT = 0.2m³ (200 LITRES)

DESIGN STORAGE SYSTEM TO LIMIT DISCHARGE
TO SEWER TO 2 LITRES / SECOND / HECTARE.

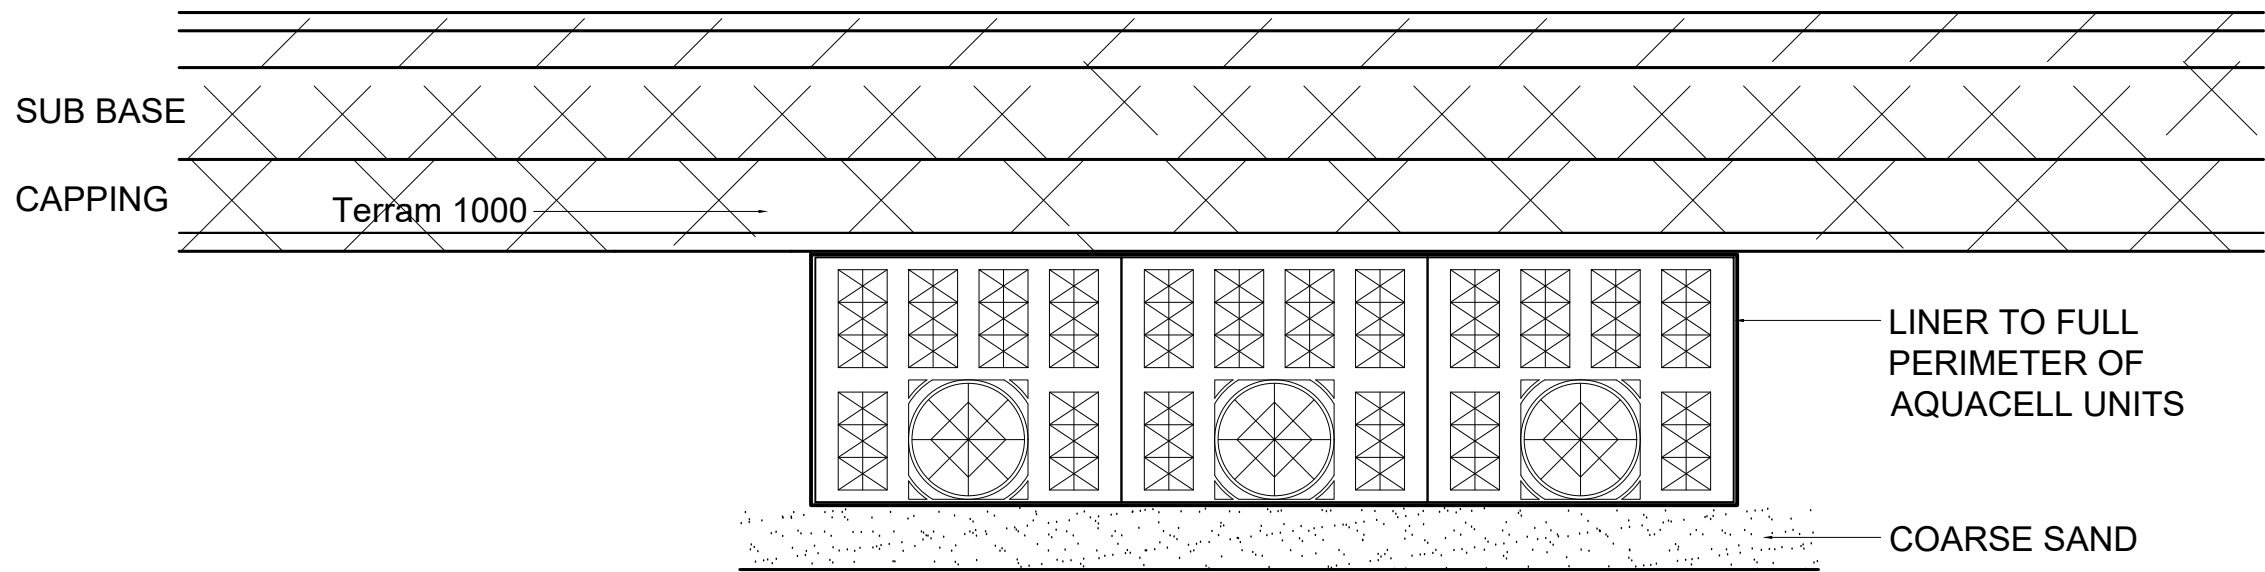

**TYPICAL SECTION THROUGH
AQUACELL SYSTEM**

(1/20)

Client: AIRSHACK	Drawing Title: Proposed Drainage Layout		PLANNING:	•	SCALE:	1/50	ARG DESIGN CONSULTING ENGINEERING Suite 125 Imperial House Hornby St Bury
			BUILDING REGS:		DATE:	27.09.2021	
Contract: MOSELEY RD NEW BUILD	Project N°:	21.11.006	TENDER:		Drawn by:	AG	
	Drg N°:	D.001	CONSTRUCTION:		Checked:		