

| KITCHEN EQUIPMENT |                                     |
|-------------------|-------------------------------------|
| REF               | DESCRIPTION                         |
| 1                 | 1200x812 CHARGRILL                  |
| 2                 | 500x812 PLANCHA                     |
| 3                 | 500x812 INFILL TABLE                |
| 4                 | 450x812 FRYER                       |
| 5                 | 450x812 FRYER                       |
| 6                 | 1500x700 SINK UNIT                  |
| 7                 | 305X305 HAND WASH BASIN             |
| 8                 | 1000x650 SINK WITH DISHWASHER UNDER |
| 9                 | 1365x700 3 DOOR PREP TABLES         |
| 10                | 900x700 2 DOOR PREP TABLE           |
| 11                | 900x550 COOLER                      |


LIGHTING LEGEND

- F

LED FLOODLIGHT
- P
- PENDANT
- W
- WALL LIGHT
- T
- TABLE LAMP
- G
- GU10 DBLE
- 
- LED STRIP – WARM WHITE
- 
- LED TUBE LIGHT
- 
- TRACK LIGHT 1m WITH 3xGU10

POWER LEGEND

- 
- SOCKETS
- E
- EMERGENCY CIRCUITING
- R
- RUNNING MAN SIGN
- 32
- 32 AMP ROTARY 1SO
- C
- CCTV
- S
- SPEAKER
- 
- FUSED SPUR
- F
- FIRE ALATM SENSOR
- FAP
- FIRE ALARM PANEL

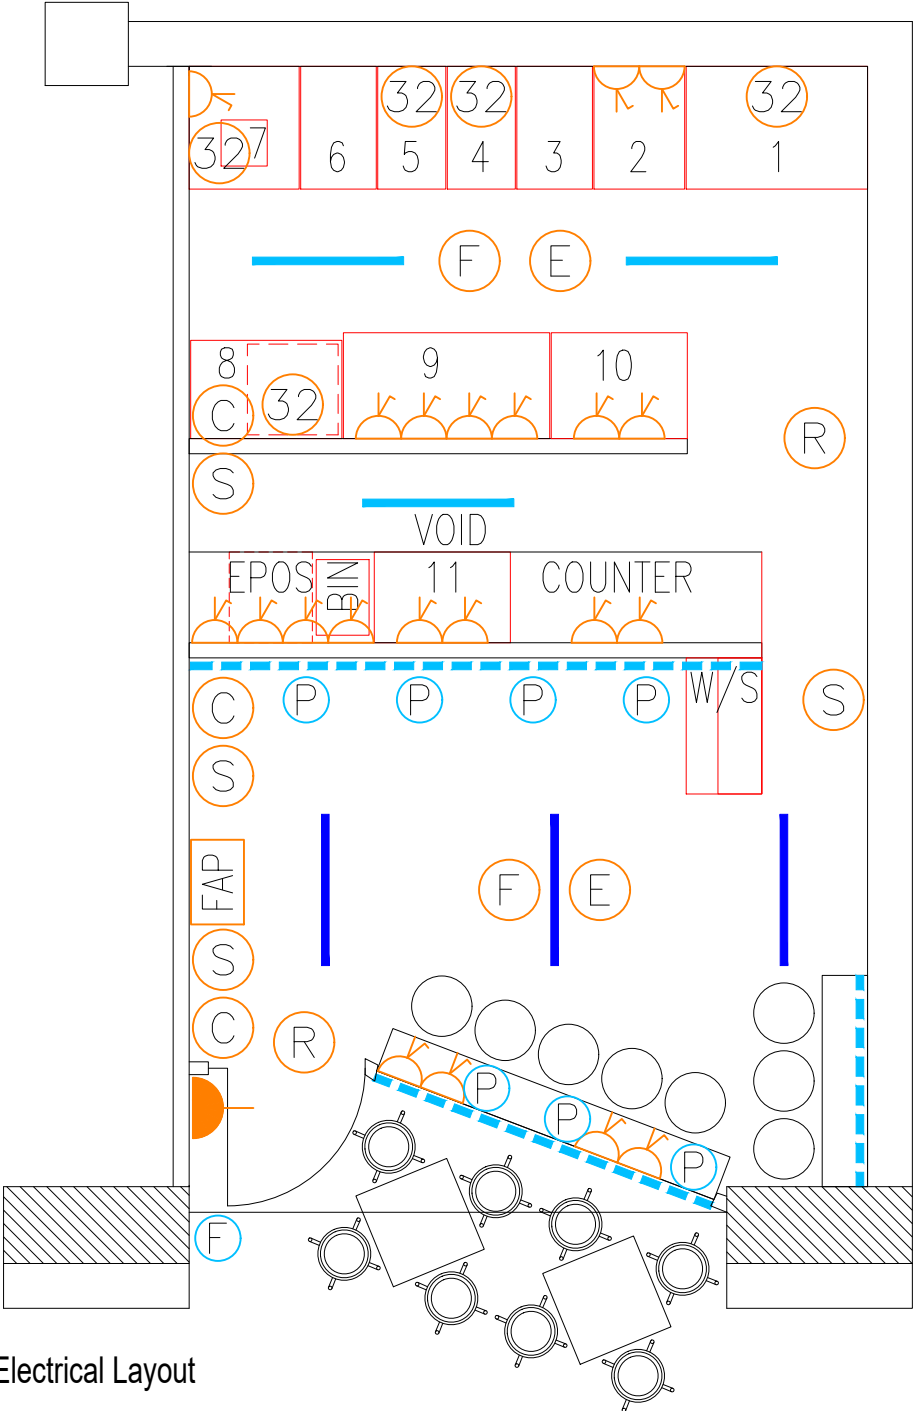

Proposed Electrical Layout  
1-50 @ A3

This drawing is to be read in conjunction with all relevant drawings.

The main contractor/builder is to interpret the requirements in relationship to the site conditions encountered and as agreed with the Building Control officer.

All dimensions and sizes to be verified on site, any discrepancies to be reported to the client/project manager. These annotations were prepared for planning and/or building control submission only.

This drawing and design is the (© 2020) property of Commercial Kitchen and Bar Consultants and should not be reproduced without written permission.

|                           |                      |    |          |
|---------------------------|----------------------|----|----------|
|                           |                      |    |          |
| A                         | Planning Application | RH | 25.08.22 |
| Rev                       | Description          | By | Date     |
| Initial Issue: 04.08.2022 |                      |    |          |

| CLIENT                                                    |                 |
|-----------------------------------------------------------|-----------------|
| Cheeky Deanos<br>95 Oxford Street<br>Manchester<br>M1 6ET |                 |
| PROJECT TITLE                                             |                 |
| Re-Fit                                                    |                 |
| DRAWING TITLE                                             |                 |
| Proposed Ground Floor<br>Electrical Layouts               |                 |
| Drawn by: CL                                              | Checked by: RH  |
| Date: 02.08.2022                                          | Scale: 1:50 @A3 |

Manchester. UK.  
www.commercialkitchenandbar.com  
0161 266 1000 | 07732 096 418

|          |             |          |
|----------|-------------|----------|
| Job Ref. | Drawing No. | Revision |
| CD       | 04          | A        |