

DO NOT SCALE FROM THIS DRAWING.  
ALL DIMENSIONS TO BE CHECKED ON SITE.  
(DRAWINGS MAYBE SCALED FOR LOCAL AUTHORITY & PLANNING PURPOSE ONLY)  
COPYRIGHT PROTECTED.

FOR PLANNING  
DO NOT USE FOR CONSTRUCTION

CONSULTANT REFERENCES IN DRAWING:

STRUCTURAL - REF/REVISION

GENERAL NOTES:

THE CONTRACTOR IS NOT TO SCALE FROM THIS DRAWING BUT FOLLOW THE WRITTEN FINISHED DIMENSIONS. ANY DISCREPANCIES BETWEEN THE DRAWING AND THE OTHER CONTRACT DOCUMENTS OR ANY DISCREPANCIES WITHIN A DRAWING OR BETWEEN DRAWINGS MUST BE REPORTED IMMEDIATELY TO THE ARCHITECT.

THE CONTRACTOR IS TO INSPECT THE SITE PRIOR TO TENDER AND IS RESPONSIBLE FOR STRIPPING OUT IN ACCORDANCE WITH THE DRAWINGS ENSURING THAT THE WORK IS UNDERTAKEN SAFELY.

THE CONTRACTOR WILL BE RESPONSIBLE FOR THE SETTING OUT OF THE WORKS.

CONTRACTOR IS TO ALLOW FOR ALL FIRE STOPPING THROUGH WALLS, CEILINGS AND FLOORS.

THE ELECTRICAL INSTALLATION IS TO BE IN ACCORDANCE WITH THE CURRENT EDITION OF THE IEE REGULATIONS AND ALL CABLING TO BE LSF.

THE CONTRACTOR IS RESPONSIBLE FOR THE DETAILED SERVICES DESIGN INCLUDING LOADINGS, CABLE AND PIPEWORK ROUTES AND PIPEWORK / CABLE SIZING AND SPECIFICATION. ALL CABLE TRAY, MS CONDUIT AND OTHER SERVICES ARE TO BE EXPOSED BELOW SLAB/ CEILINGS.

ANY H&V PROPOSAL IS INDICATIVE ONLY AND THE SPECIALIST CONTRACTOR IS TO BE RESPONSIBLE FOR THE DETAIL DESIGN & ALL SWITCH/ SOCKET OUTLETS TO COMPLY WITH CLIENT'S STANDARD SPECIFICATION. ANY SOCKETS IN RETAIL AREA TO BE FINISHED BRUSHED STAINLESS STEEL.

NOTE - ALL EXISTING FIRE RESISTING ENCLOSURES TO SERVICE RISERS TO BE MAINTAINED OR MADE GOOD WHERE DISTURBED. NEW AND EXISTING CABLES, PIPES AND DUCTS PASSING THROUGH FIRE RESISTING CONSTRUCTION TO BE ADEQUATELY FIRE STOPPED. NEW AND EXISTING DUCTWORK PASSING THROUGH FIRE RESISTING CONSTRUCTION TO HAVE FIRE DAMPERS.



ANY WALL, CEILING LININGS TO BE TO EUROCLASS A (CLASS O EQUIVALENT).

CONTRACTOR AND SUPPLIERS OF SPECIALIST JOINERY/ EQUIPMENT TO ENSURE ALL TIMBER MATERIALS ARE TREATED WITH FIRE RETARDANT FINISH TO ACHIEVE CLASS 0 RATING. MDF TO BE ACHIEVE CLASS 0 RATED.



CONTRACTOR AND SUPPLIERS OF SPECIALIST EQUIPMENT TO PROVIDE FIRE RATING CERTIFICATES FOR ALL SPECIALIST LININGS AND LAMINATES TO BE USED FOR NWR APPROVAL.

ALL PAINTS TO BE WATER BASED


ALL DIMENSIONS TO BE CHECKED ON SITE PRIOR TO ANY MANUFACTURE OR CONSTRUCTION OF EQUIPMENT, FINISH, SIGNAGE ETC.

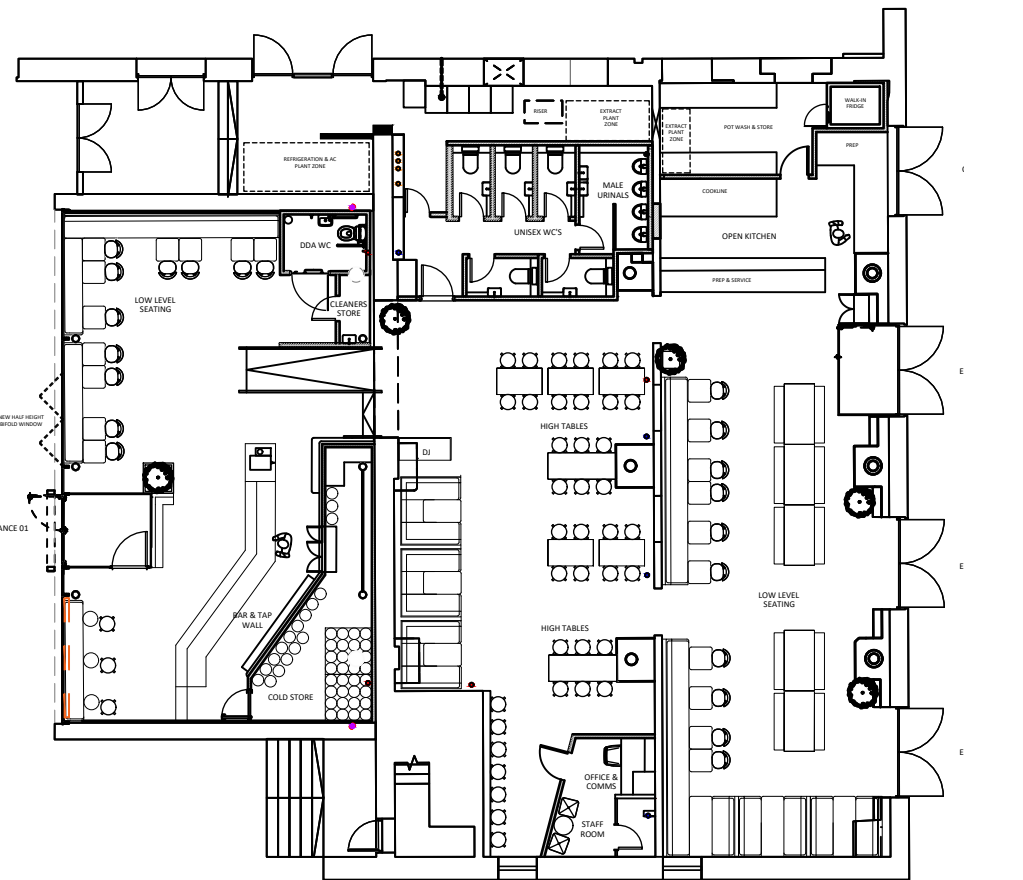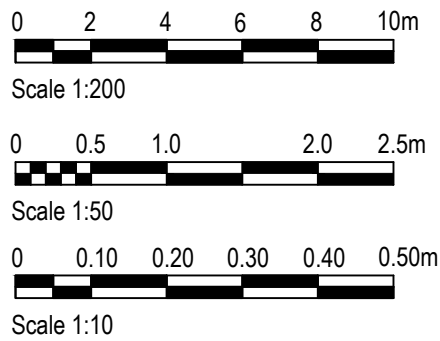

 01 GROUND FLOOR PLAN AS PROPOSED  
831 SCALE - 1:200 @ A1 PLAN

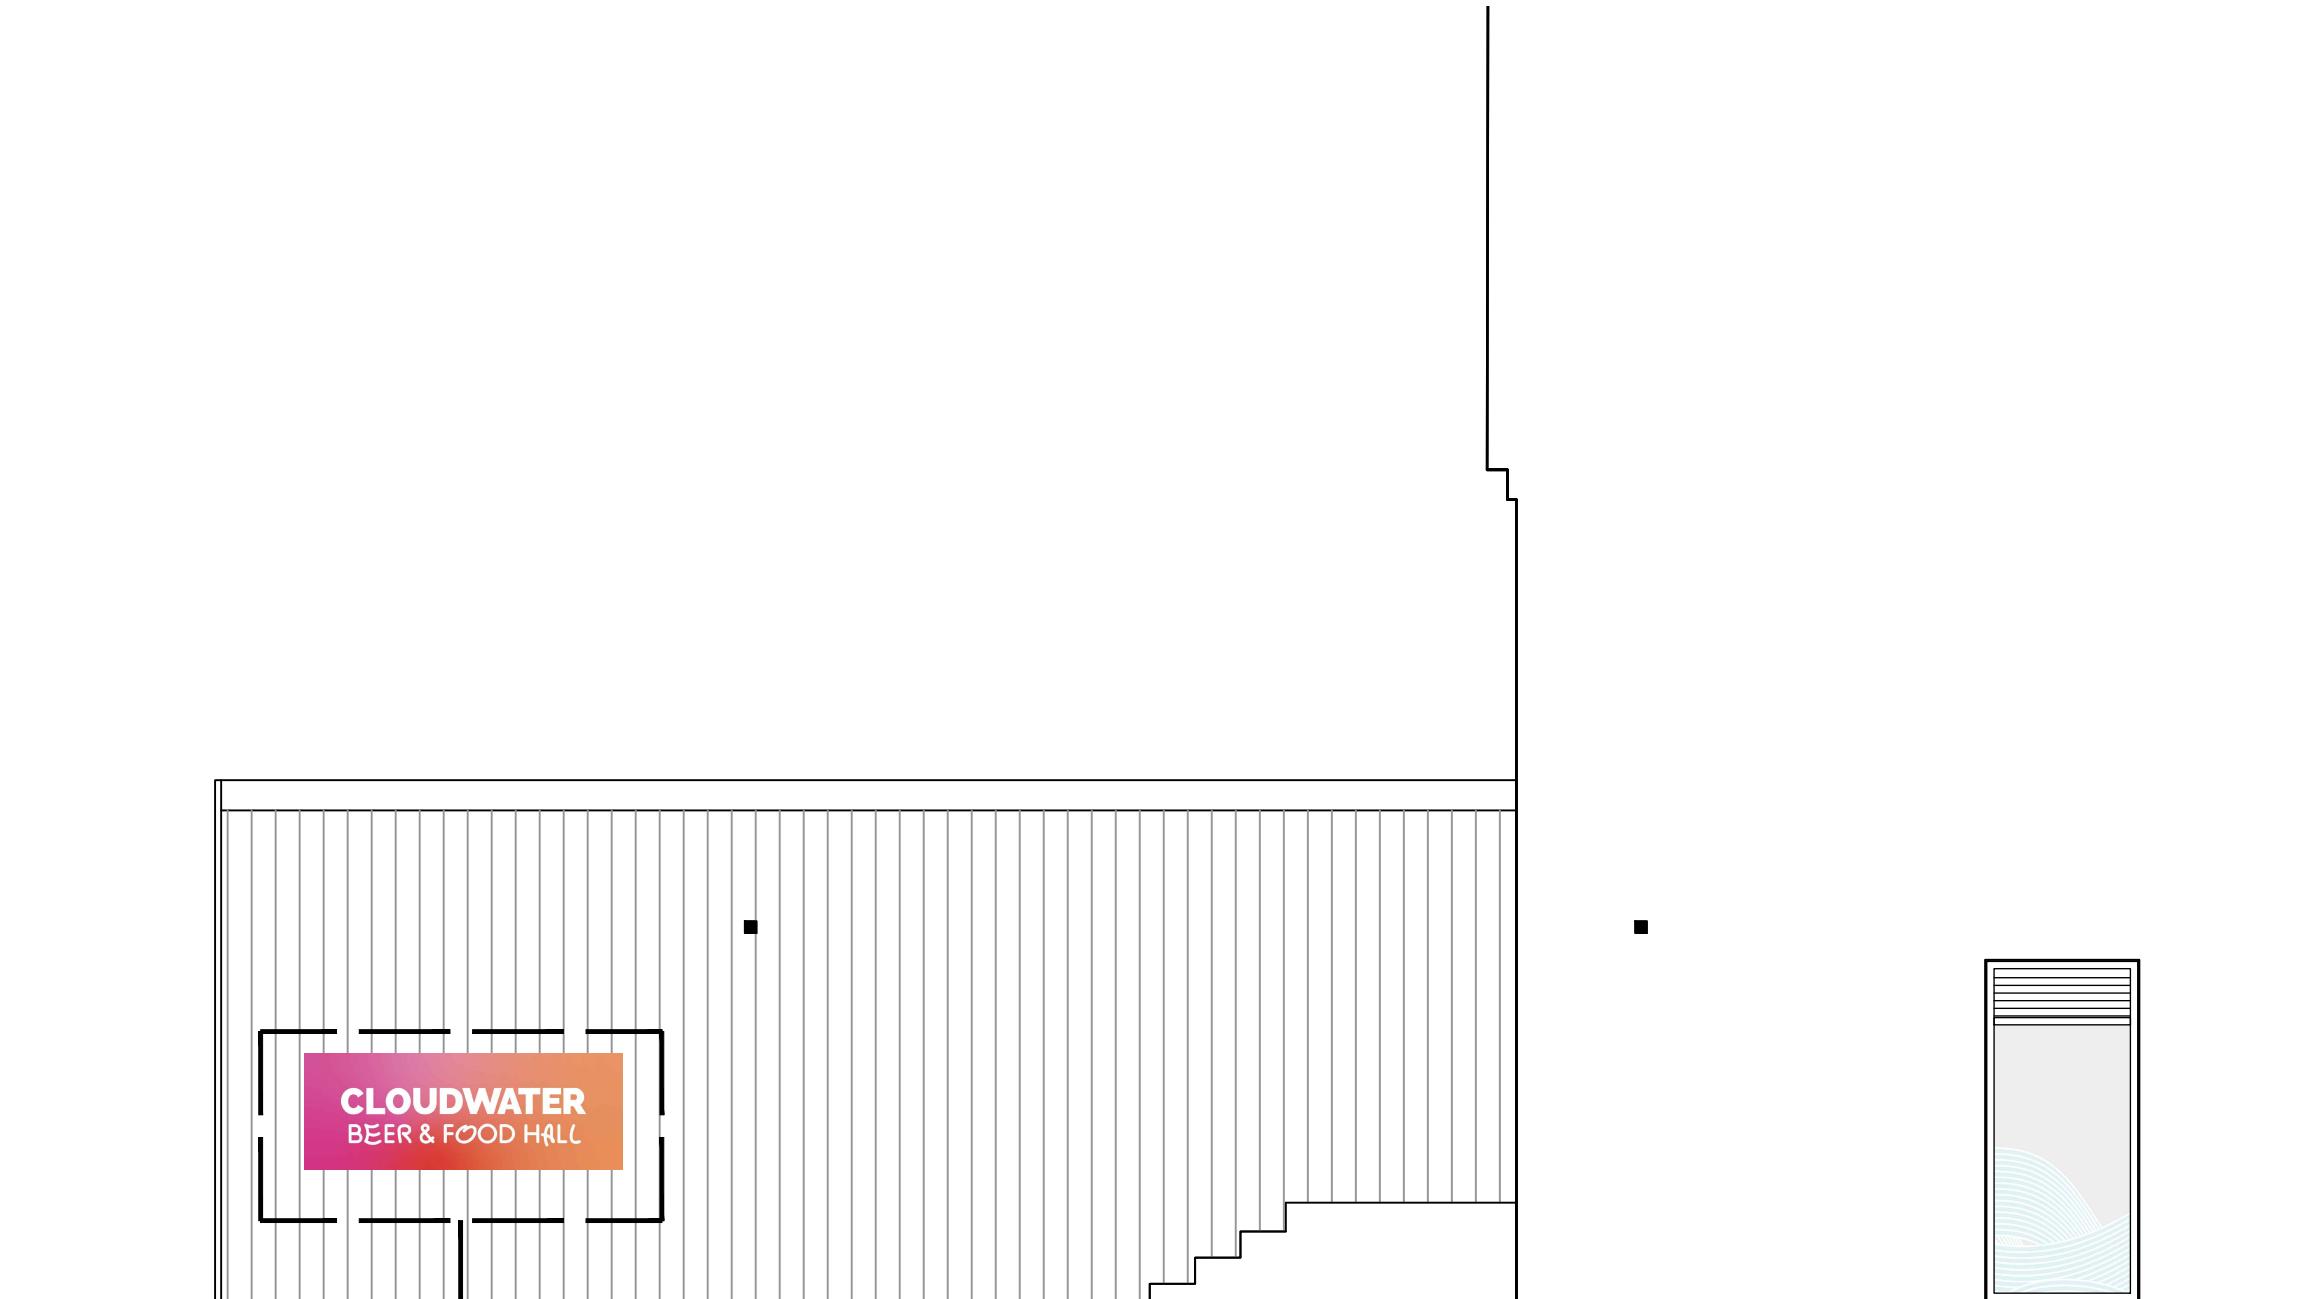


02 SOUTH FACING ELEVATION AS PROPOSED  
831 SCALE - 1:50 @ A1 ELEVATION

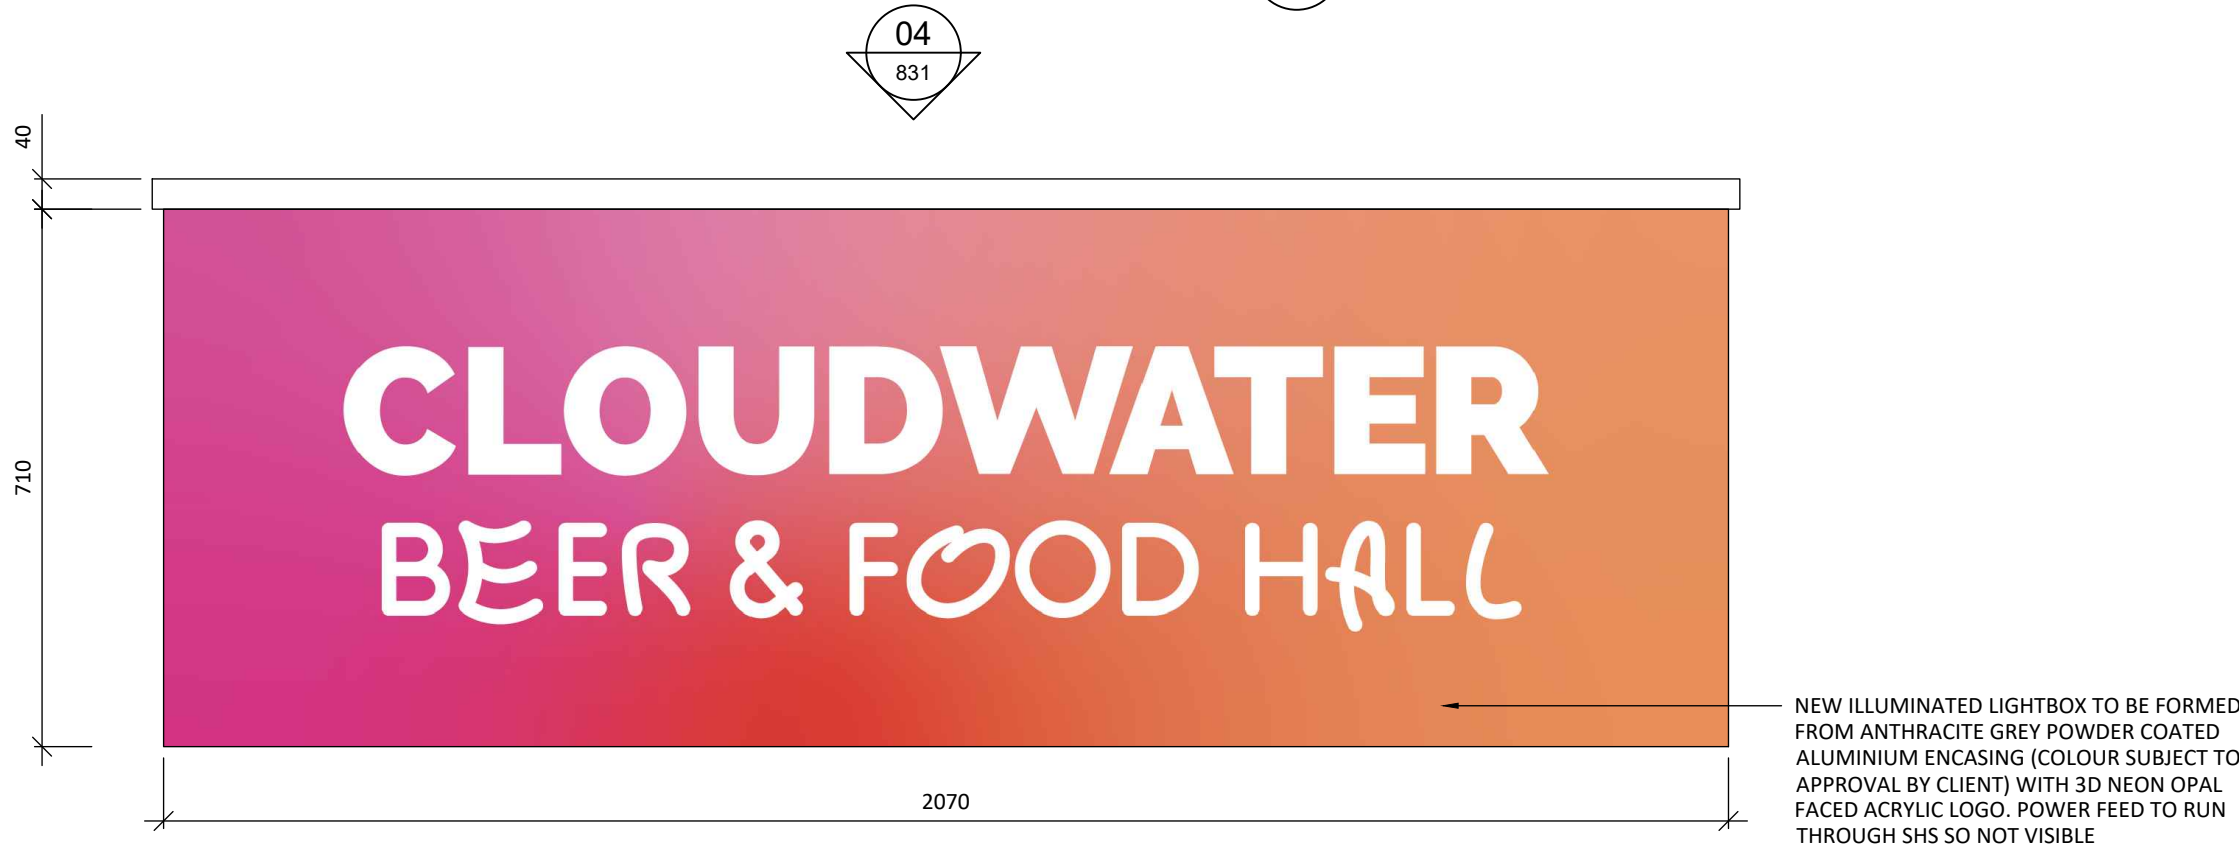

NEW ILLUMINATED LIGHTBOX TO BE FORMED FROM ANTHRACITE GREY POWDER COATED ALUMINIUM ENCASING (COLOUR SUBJECT TO APPROVAL BY CLIENT) WITH 3D NEON OPAL FACED ACRYLIC LOGO. POWER FEED TO RUN THROUGH SHS SO NOT VISIBLE

03 ILLUMINATED SIGN AS PROPOSED  
831 SCALE - 1:10 @ A1 ELEVATION

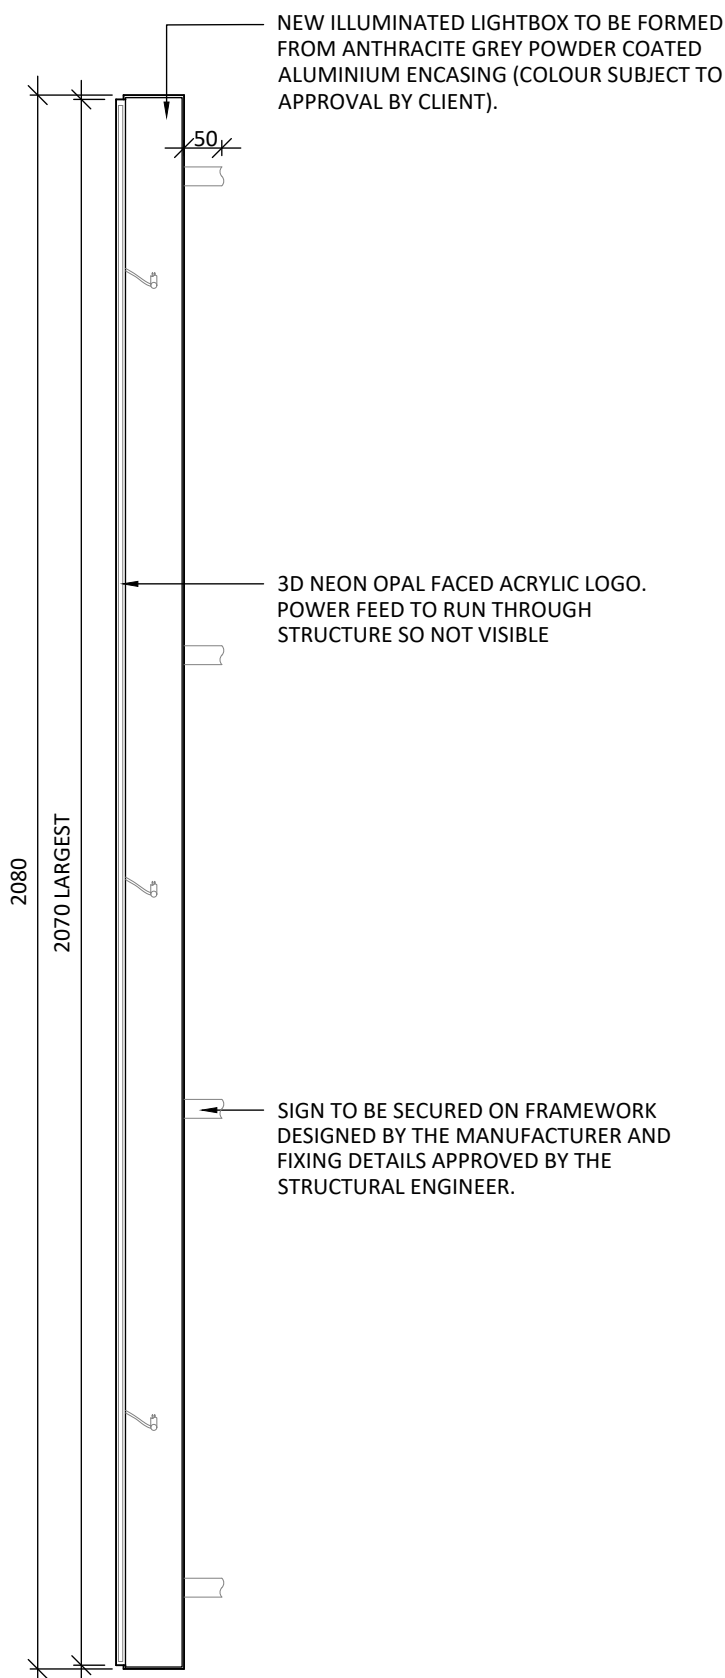

NEW ILLUMINATED LIGHTBOX TO BE FORMED FROM ANTHRACITE GREY POWDER COATED ALUMINIUM ENCASING (COLOUR SUBJECT TO APPROVAL BY CLIENT).

3D NEON OPAL FACED ACRYLIC LOGO. POWER FEED TO RUN THROUGH STRUCTURE SO NOT VISIBLE


SIGN TO BE SECURED ON FRAMEWORK DESIGNED BY THE MANUFACTURER AND FIXING DETAILS APPROVED BY THE STRUCTURAL ENGINEER.

04 ILLUMINATED SIGN AS PROPOSED  
831 SCALE - 1:10 @ A1 ELEVATION

|      |          |                                            |       |         |
|------|----------|--------------------------------------------|-------|---------|
| 3.00 | 03/01/23 | ISSUED FOR PLANNING<br>Issued for planning | JW    | ARB     |
| REV  | DATE     | DESCRIPTION                                | DRAWN | CHECKED |

A X I

ADDRESS : 4th FLOOR CALICO 53-55 MOSLEY STREET,  
MANCHESTER, M2 3HQ  
TELEPHONE : +44 (0)161 879 7337  
EMAIL : www.ahstudio.co  
COMPANY No : 11847325

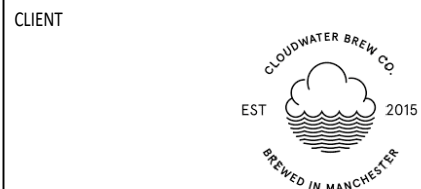

PROJECT  
CLOUDWATER  
KAMPUS, MINSULL ST  
MANCHESTER

DRAWING REFERENCE  
SOUTH FACING ELEVATION SIGNAGE  
DETAILS  
AS PROPOSED

|                   |               |          |       |         |
|-------------------|---------------|----------|-------|---------|
| JOB REFERENCE     | DRAWING SCALE | DATE     | DRAWN | CHECKED |
| 22 - 108          | VAR @ A1      | 03/01/23 | JW    | ARB     |
| DRAWING REFERENCE | STAGE         | REV      |       |         |
| AXI - 831         | 3             | 00       |       |         |