


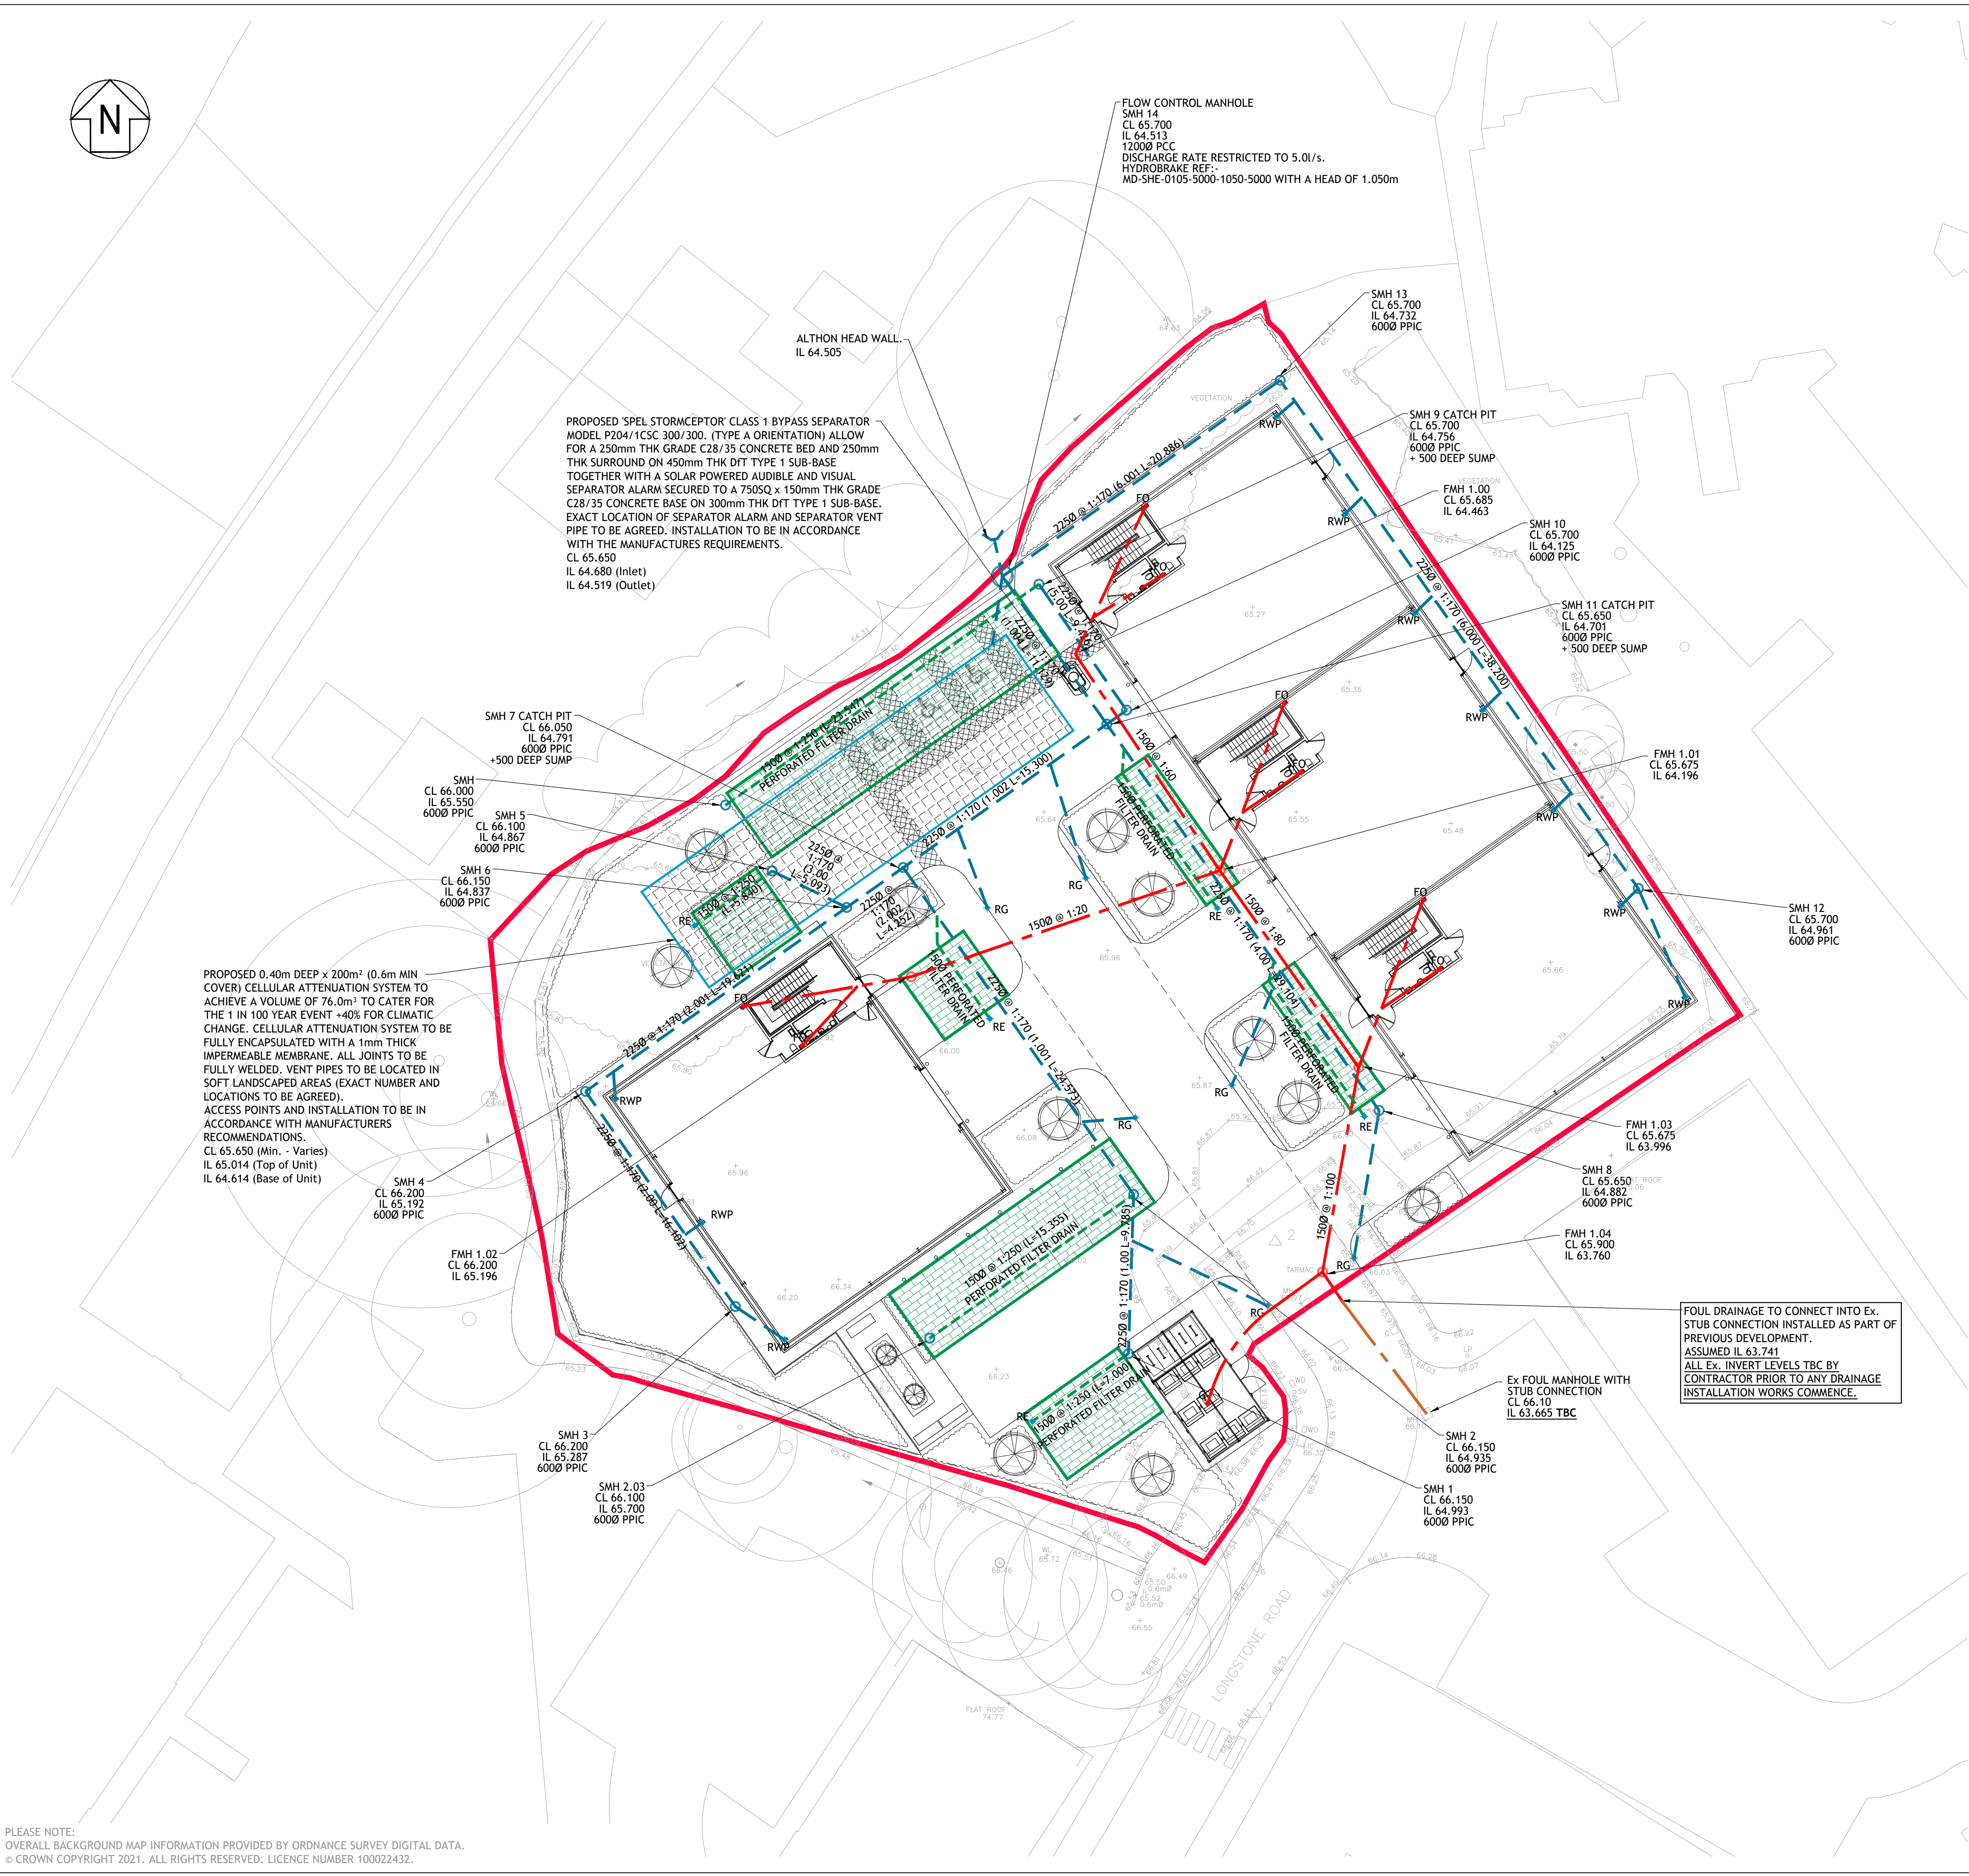

PLEASE NOTE:
OVERALL BACKGROUND MAP INFORMATION PROVIDED BY ORDNANCE SURVEY DIGITAL DATA.
© CROWN COPYRIGHT 2021. ALL RIGHTS RESERVED. LICENCE NUMBER 100022432.

Legend

PROPOSED SURFACE WATER DRAIN.
(TYPICALLY 1000 FROM RWP AND 1500 FROM RG/SU UNO)

PROPOSED SURFACE WATER PPIC.

PROPOSED TRAPPED ROAD GULLY.

PROPOSED BACK INLET GULLY.

PROPOSED SURFACE WATER CELLULAR ATTENUATION SYSTEM.

PROPOSED FOUL DRAIN (TYPICALLY 1000 UNO).

PROPOSED TANKED PERMEABLE BLOCK PAVING WITH FILTER DRAIN.

PROPOSED FOUL PPIC.

PROPOSED FOUL OUTLET.

NOTE:

ALL EXISTING DRAINAGE TBC.

ALL SURFACE WATER CHAMBERS ARE TO HAVE C250 COVERS IN SOFT LANDSCAPE OR FOOTWAY AREAS AND D400 IN ACCESS ROAD AND CARPARK AREAS.UNO.

ALL FOUL CHAMBERS ARE TO BE MIN 4500 HD PPIC WITH C250 COVERS IN SOFT LANDSCAPE OR FOOTWAY AREAS AND D400 IN ACCESS ROAD AND CARPARK AREAS.UNO.

ALL DRAINAGE WITH LESS THAN 750 COVER IS TO BE ENCASED IN MIN 150THK C32/40 CONCRETE - SEE DETAIL DRAWING FOR ENCASING DETAILS.

Notes

- THIS DRAWING IS THE COPYRIGHT OF TIER CONSULT LTD AND CANNOT BE REPRODUCED IN ANY FORM WITHOUT WRITTEN CONSENT FROM THE COMPANY.
- THIS DRAWING IS TO BE READ IN CONJUNCTION WITH ALL OTHER RELEVANT ARCHITECT'S, ENGINEER'S AND SPECIALIST'S DRAWINGS TOGETHER WITH THE APPROPRIATE SPECIFICATION.
- ALL DIMENSIONS ARE IN MILLIMETRES UNO, FOR THE PURPOSES OF CONSTRUCTION THIS DRAWING MUST NOT BE SCALED AND ONLY WRITTEN DIMENSIONS USED. IT IS THE CONTRACTOR'S RESPONSIBILITY TO CHECK ALL DIMENSIONS ON SITE PRIOR TO CONSTRUCTION AND ANY DISCREPANCIES TO BE BROUGHT TO THE IMMEDIATE ATTENTION OF THE ENGINEER IN WRITING.
- ALL LEVELS ARE IN METRES UNO & TO OS DATUM.
- THE WORKS SHALL BE IN ACCORDANCE WITH THE NATIONAL BUILDING SPECIFICATION.
- THE LOCATION LINE & LEVEL OF ALL KNOWN EXISTING DRAINAGE PIPEWORK INDICATED ON THE DRAWINGS ARE APPROXIMATE AND FOR GUIDANCE PURPOSES ONLY.
- CONNECTION TO THE EXISTING PUBLIC SEWERS WILL BE SUBJECT TO THE RELEVANT APPROVALS FROM THE STATUTORY UNDERTAKER.
- IT IS THE CONTRACTOR'S RESPONSIBILITY TO DETERMINE THEIR EXACT LINE AND LEVEL, BY WAY OF HAND EXCAVATED TRIAL PITS, PRIOR TO THE COMMENCEMENT OF ANY EXCAVATION WORKS ON SITE. THE CONTRACTOR SHALL TAKE ALL NECESSARY PRECAUTIONS AND MAINTAIN THE STRUCTURAL INTEGRITY OF ALL ABOVE AND BELOW GROUND SERVICE INSTALLATIONS.
- THE CONTRACTOR SHALL IMPLEMENT AND MAINTAIN THROUGHOUT THE DURATION OF THE CONTRACT A FULL TRAFFIC MANAGEMENT SYSTEM TO ENSURE SAFE PASSAGE OF VEHICLES/PEDESTRIANS IN THE VICINITY OF THE WORKS. ALL TRAFFIC SIGNS, SIGNALS, BARRIERS ETC. SHALL BE IN ACCORDANCE WITH CHAPTER 8 OF THE TRAFFIC SIGNS MANUAL.
- THE CONTRACTOR SHALL MAKE ADEQUATE PROVISION FOR DEALING WITH AND DISPOSING OF GROUND/SURFACE WATER ENCOUNTERED DURING EXCAVATIONS
- ALL SOFT / HARD PAVED AREAS AFFECTED BY THE WORKS SHALL BE FULLY REINSTATED FOLLOWING THE INSTALLATION OF ALL DRAINAGE WORKS. ALL SURFACE MARKINGS AFFECTED BY THE WORKS SHALL BE FULLY REINSTATED.
- ALL SURPLUS EXCAVATED MATERIAL SHALL BE DISPOSED IN A DESIGNATED AREA ON SITE.
- UPON COMPLETION OF THE WORKS THE CONTRACTOR SHALL PROVIDE AS BUILT SETTING OUT CO-ORDINATE AND LEVEL INFORMATION.
- PIPEWORK WITH LESS THAN 750mm OF COVER IN TRAFFICKED AREAS TO BE CONCRETE ENCASED. (BEDDING CLASS Z)
- PIPEWORK WITH MORE THAN 750mm OF COVER TO HAVE CLASS 5 GRANULAR BED AND SURROUND.
- POLYPROPYLENE INSPECTION CHAMBERS OF 5000 >1.2m DEEP TO BE FITTED WITH A REDUCED ACCESS FITTING.
- SOIL STACKS - WHERE SOIL STACKS SERVE MULTIPLE STOREYS THE STACK REST BEND IS TO BE MINIMUM 750mm BELOW THE LOWEST BRANCH CONNECTION. WHERE SEPARATE STACKS ARE PROVIDED FOR GROUND FLOOR, REST BENDS MAY BE 450mm MINIMUM BELOW THE LOWEST CONNECTION.
- SVP CONNECTIONS TO BE 100mm DIA UNO.
- ALL FO AND RWP LOCATIONS TO BE TO BE COMPLETE WITH A LOW LEVEL ACCESS PLATE FOR RODDING.
- WHERE PROPOSED DRAINAGE PIPEWORK RUNS ARE IN CLOSE PROXIMITY TO THE NEW FOUNDATIONS, THE CONTRACTOR SHALL ALLOW FOR EXTENDING THE DEPTH OF NEW FOUNDATIONS IN LEAN MIX CONCRETE DOWN TO THE PROPOSED PIPE BEDDING LEVEL.
- THE HYDRAULIC DESIGN HAS BEEN CARRIED OUT IN ACCORDANCE WITH 'CIRIA REPORT C753 THE SUDS MANUAL' AND THE HYDRAULIC DESIGN OF PIPELINES AND OTHER CONDUITS HAS BEEN CARRIED OUT IN ACCORDANCE WITH 'BS EN 16933-2'.

T5	07.10.2022	CCF	DRAINAGE LAYOUT UPDATED	CCF	PJB
T4	04.10.2022	CCF	FOUL LAYOUT UPDATED	CCF	PJB
T3	28.09.2022	CCF	UPDATED TO COMMENTS	CCF	PJB
T2	16.09.2022	CCF	UPDATED TO LATEST SITE PLAN	CCF	PJB
T1	06.09.2022	CCF	TENDER ISSUE	CCF	PJB

Rev	Date	By	Description	CHK	APP
Status					

TENDER

TIER CONSULT.
Richmond House,
Sandpiper Court,
Chester Business Park,
Chester | CH4 9QZ
T: 01244 684 900

Client

Project

ASHBROOK MOSS NOOK.

Title

PROPOSED FOUL AND SURFACE WATER DRAINAGE LAYOUT.

Scale	Drawn	Revision
1:200@A1	C.C.FITTON	T5
Date	Checked	
06.08.2021	W.N.LLOYD	

Drawing No :
T_21_2463-55-01

© Tier Consult