
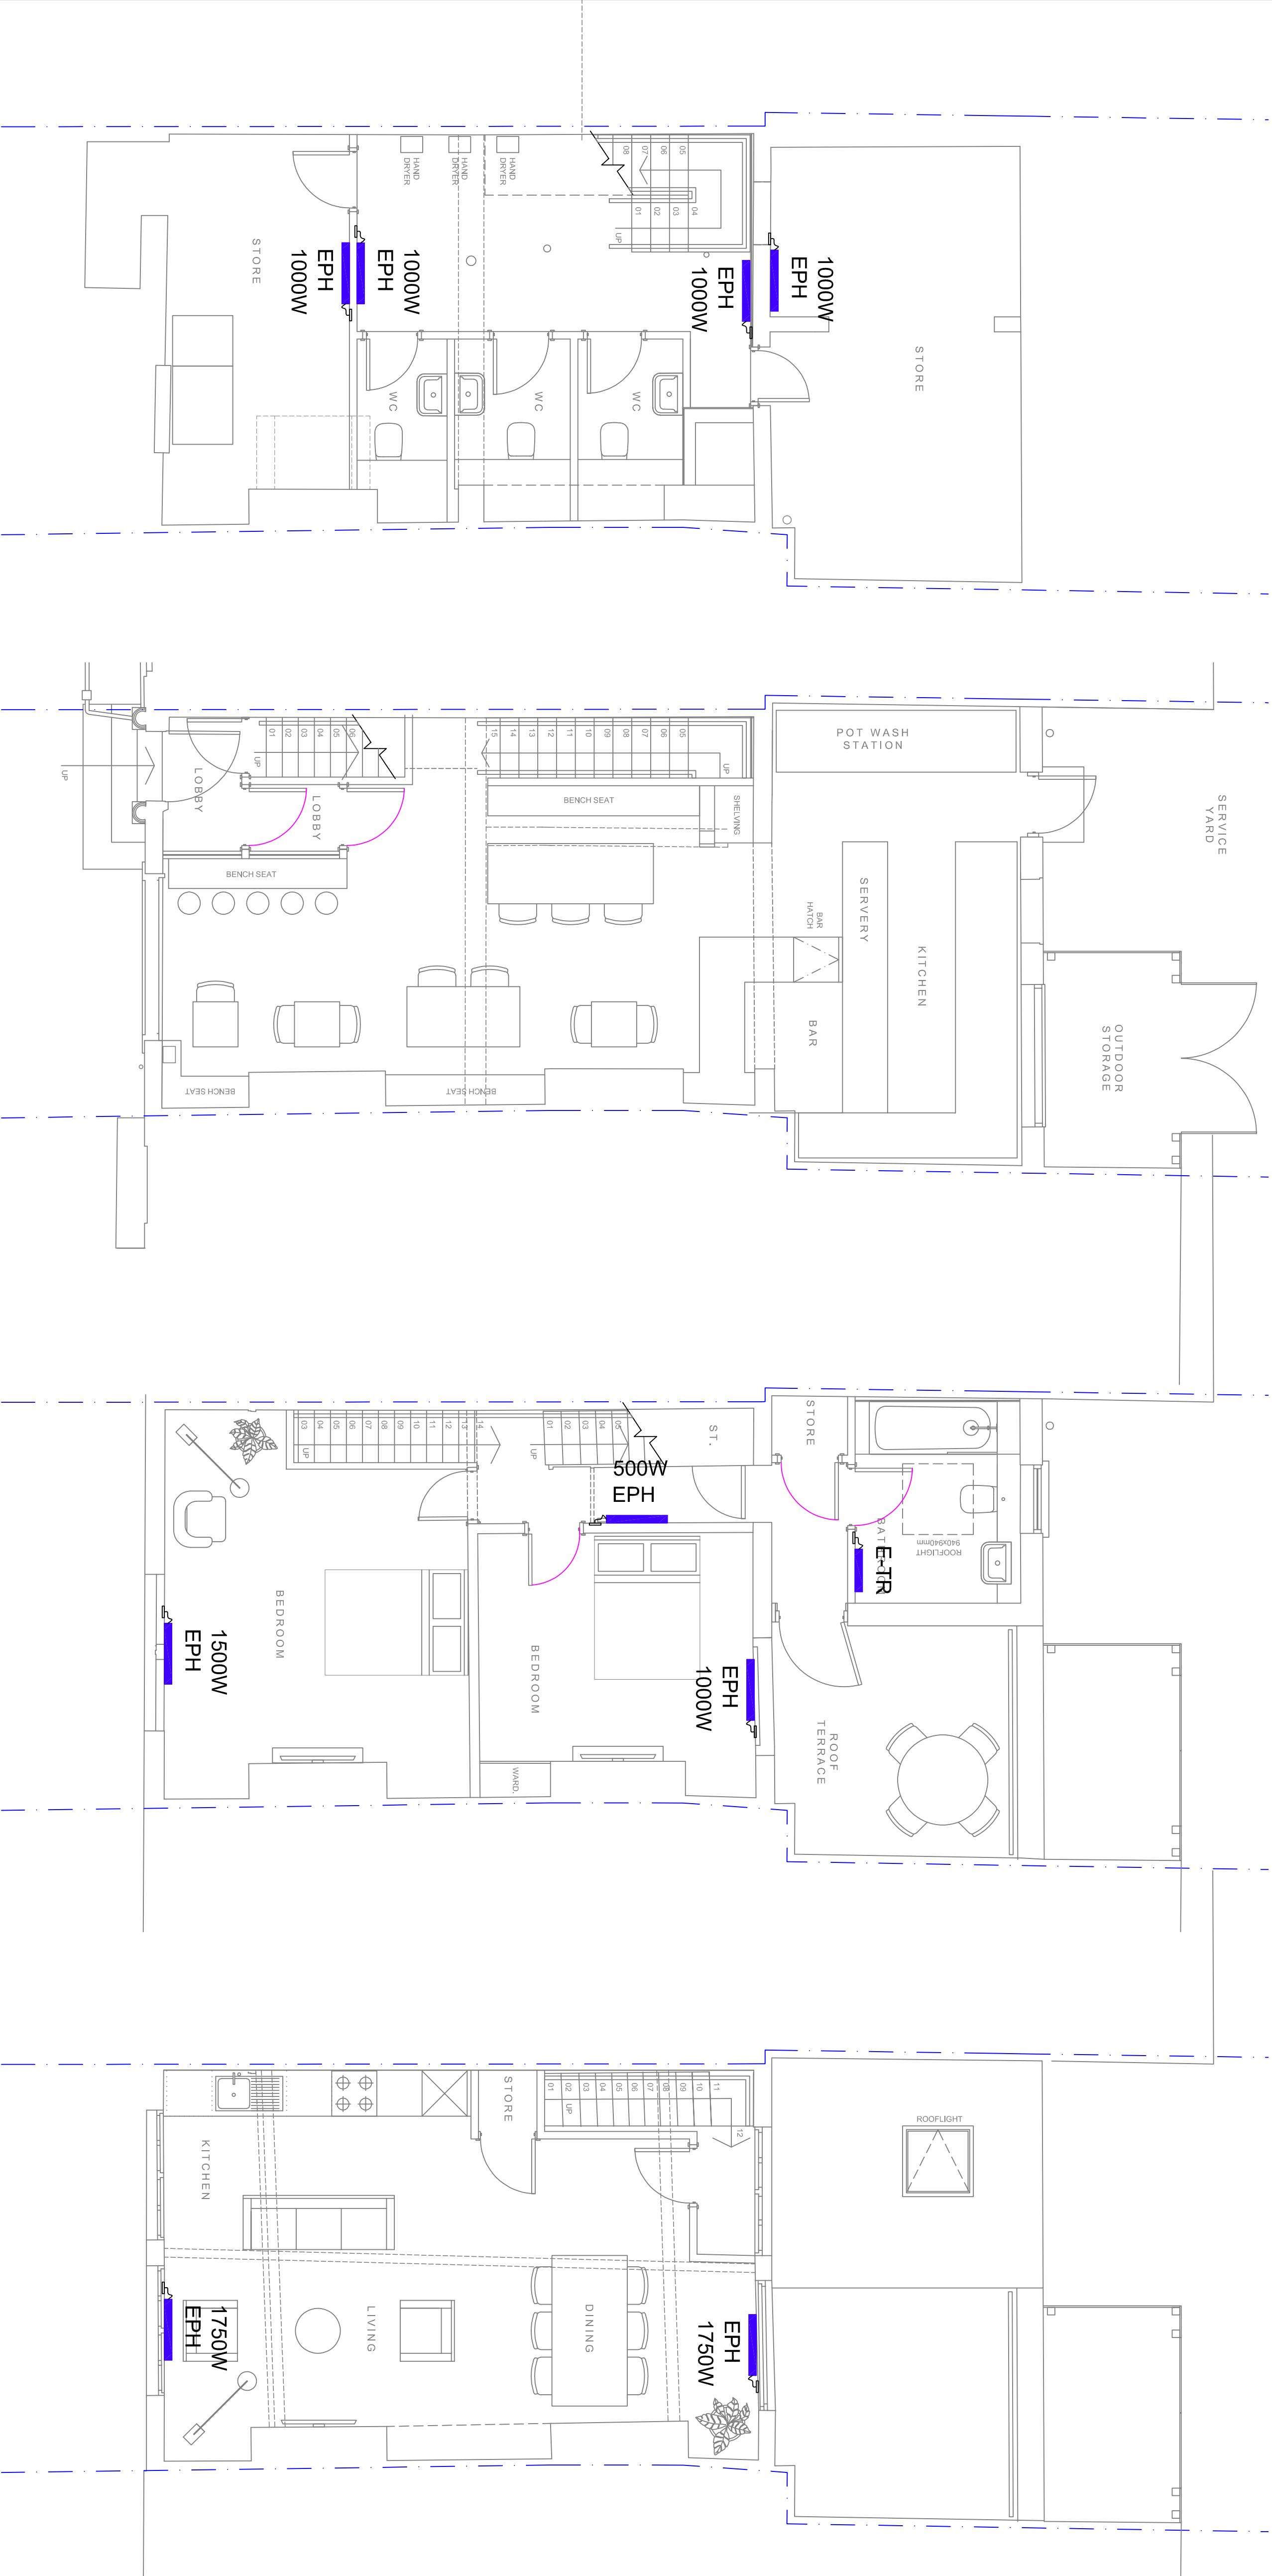


GENERAL NOTES

- POSITION OF HEATINGS INDICATIVE ONLY.
- THIS DRAWING IS TO BE READ IN CONJUNCTION WITH THE RELEVANT SPECIFICATIONS.
- EPH ELECTRIC PANEL HEATER
- E-TR ELECTRIC TOWEL RAIL

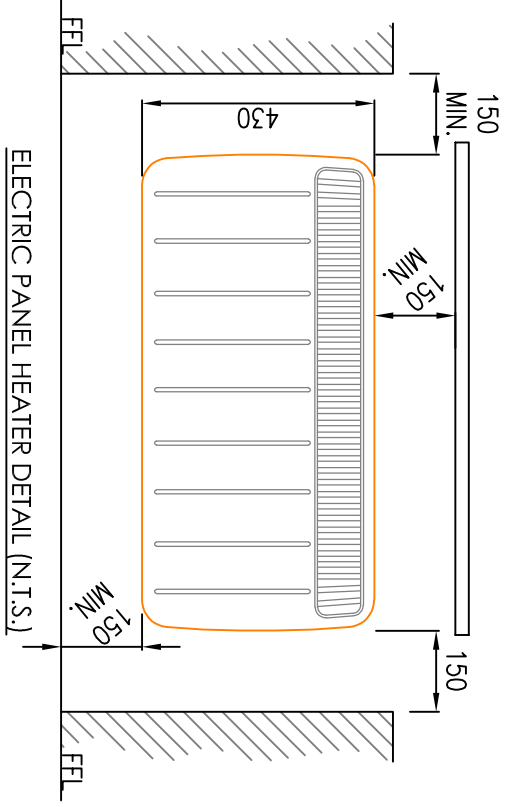

BASEMENT

GROUND FLOOR

FIRST FLOOR

SECOND FLOOR

REV/CHK	DATE	DESCRIPTION
02	ST	01.03.23
01	ST	15.02.23



AURA Technical Services Ltd.
97 Alderley Road
Wilmslow
SK9 1PT

www.auratechnicalservices.co.uk

DwgN:	DC	CHKd:	ST	App:	RC
Date:	FEB23	Scale:	1:50		

Project:
33 THOMAS STREET

Drawing Title:
MECHANICAL SERVICES
HEATING LAYOUT
ALL FLOORS

Drawing No: BAC001-AUR-ZZ-ZZ-DR-5601

Rev: P02