



GENERAL NOTES


- DO NOT SCALE FROM THIS DRAWING.
 - POSITIONS OF ALL FITTINGS ARE INDICATIVE ONLY.
 - THIS DRAWING IS TO BE READ IN CONJUNCTION WITH THE RELEVANT SPECIFICATIONS.
 - ELECTRICAL OUTLETS MOUNTED TO EXISTING WALLS ARE TO BE SURFACE MOUNTED SUPPLIED BY GALVANIZED CONDUIT.
-
- ⊗ RECESSED LED DOWN LIGHT 3000K
 - ⊗ SURFACE MOUNTED CAN STYLE LED DOWN LIGHT 3000K MOUNTED TO GALVANISED CONDUIT SECONDARY CONTAINMENT SYSTEM
 - 230V LED LIGHTING TRACK WITH ADJUSTABLE / MOVABLE LED LIGHTS
 - IP65 RATED NON CORROSIVE BATON FITTING
 - ⊕ IP65 RATED EXTERNAL WALL LIGHT
 - ⊗ PIR
 - ⊗ LIGHT SWITCH
 - ⊗ SHAVER POINT
 - ⊗ EMERGENCY EXIT SIGN
 - E DENOTES EMERGENCY
 - BOOST MVHR BOOST SWITCH
 - OS OUTSIDE LIGHT
 - INT INTERMEDIATE
 - 2G DENOTES NUMBER OF GANGS

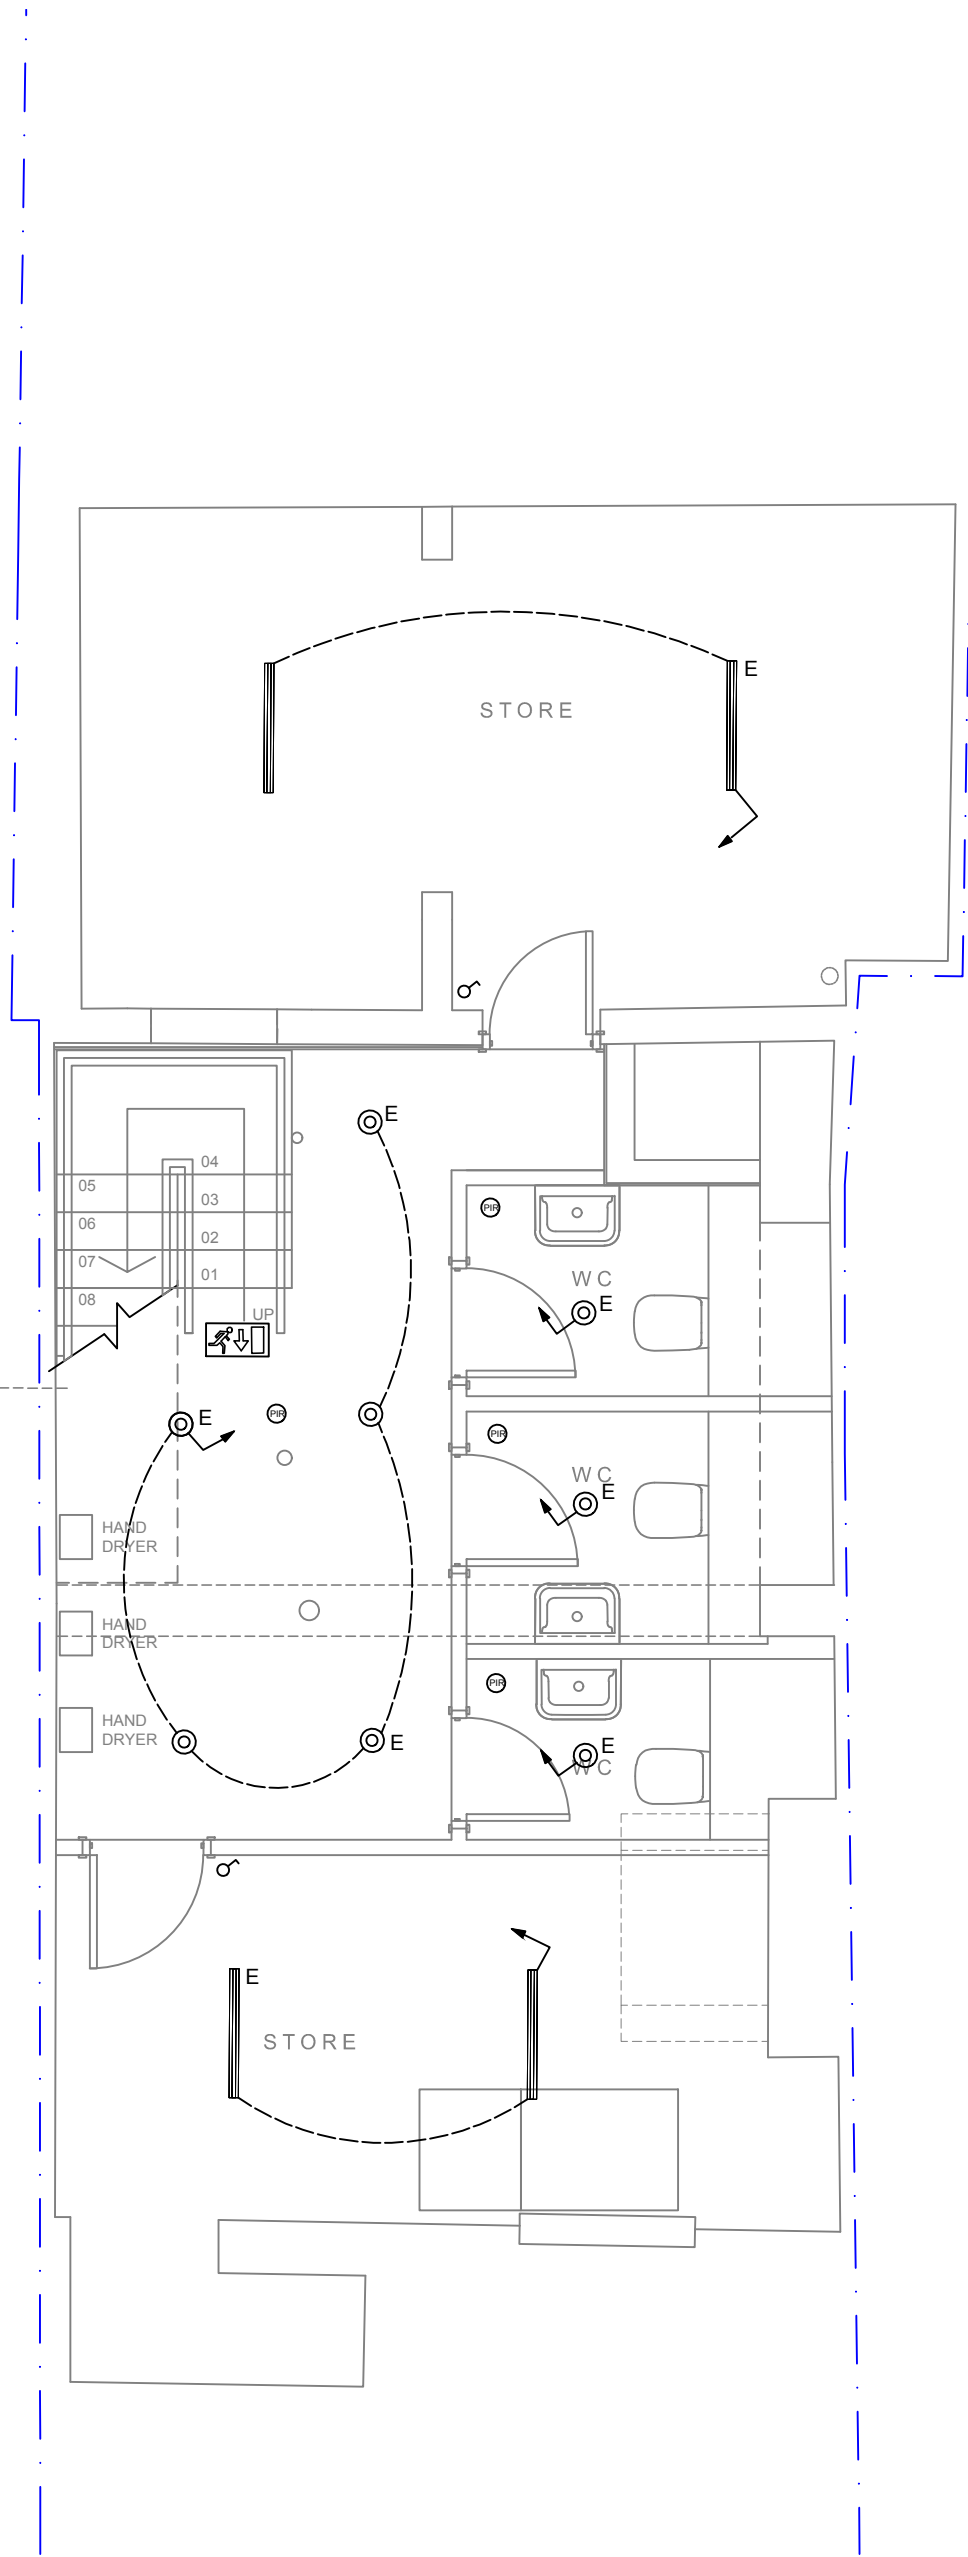


BASEMENT

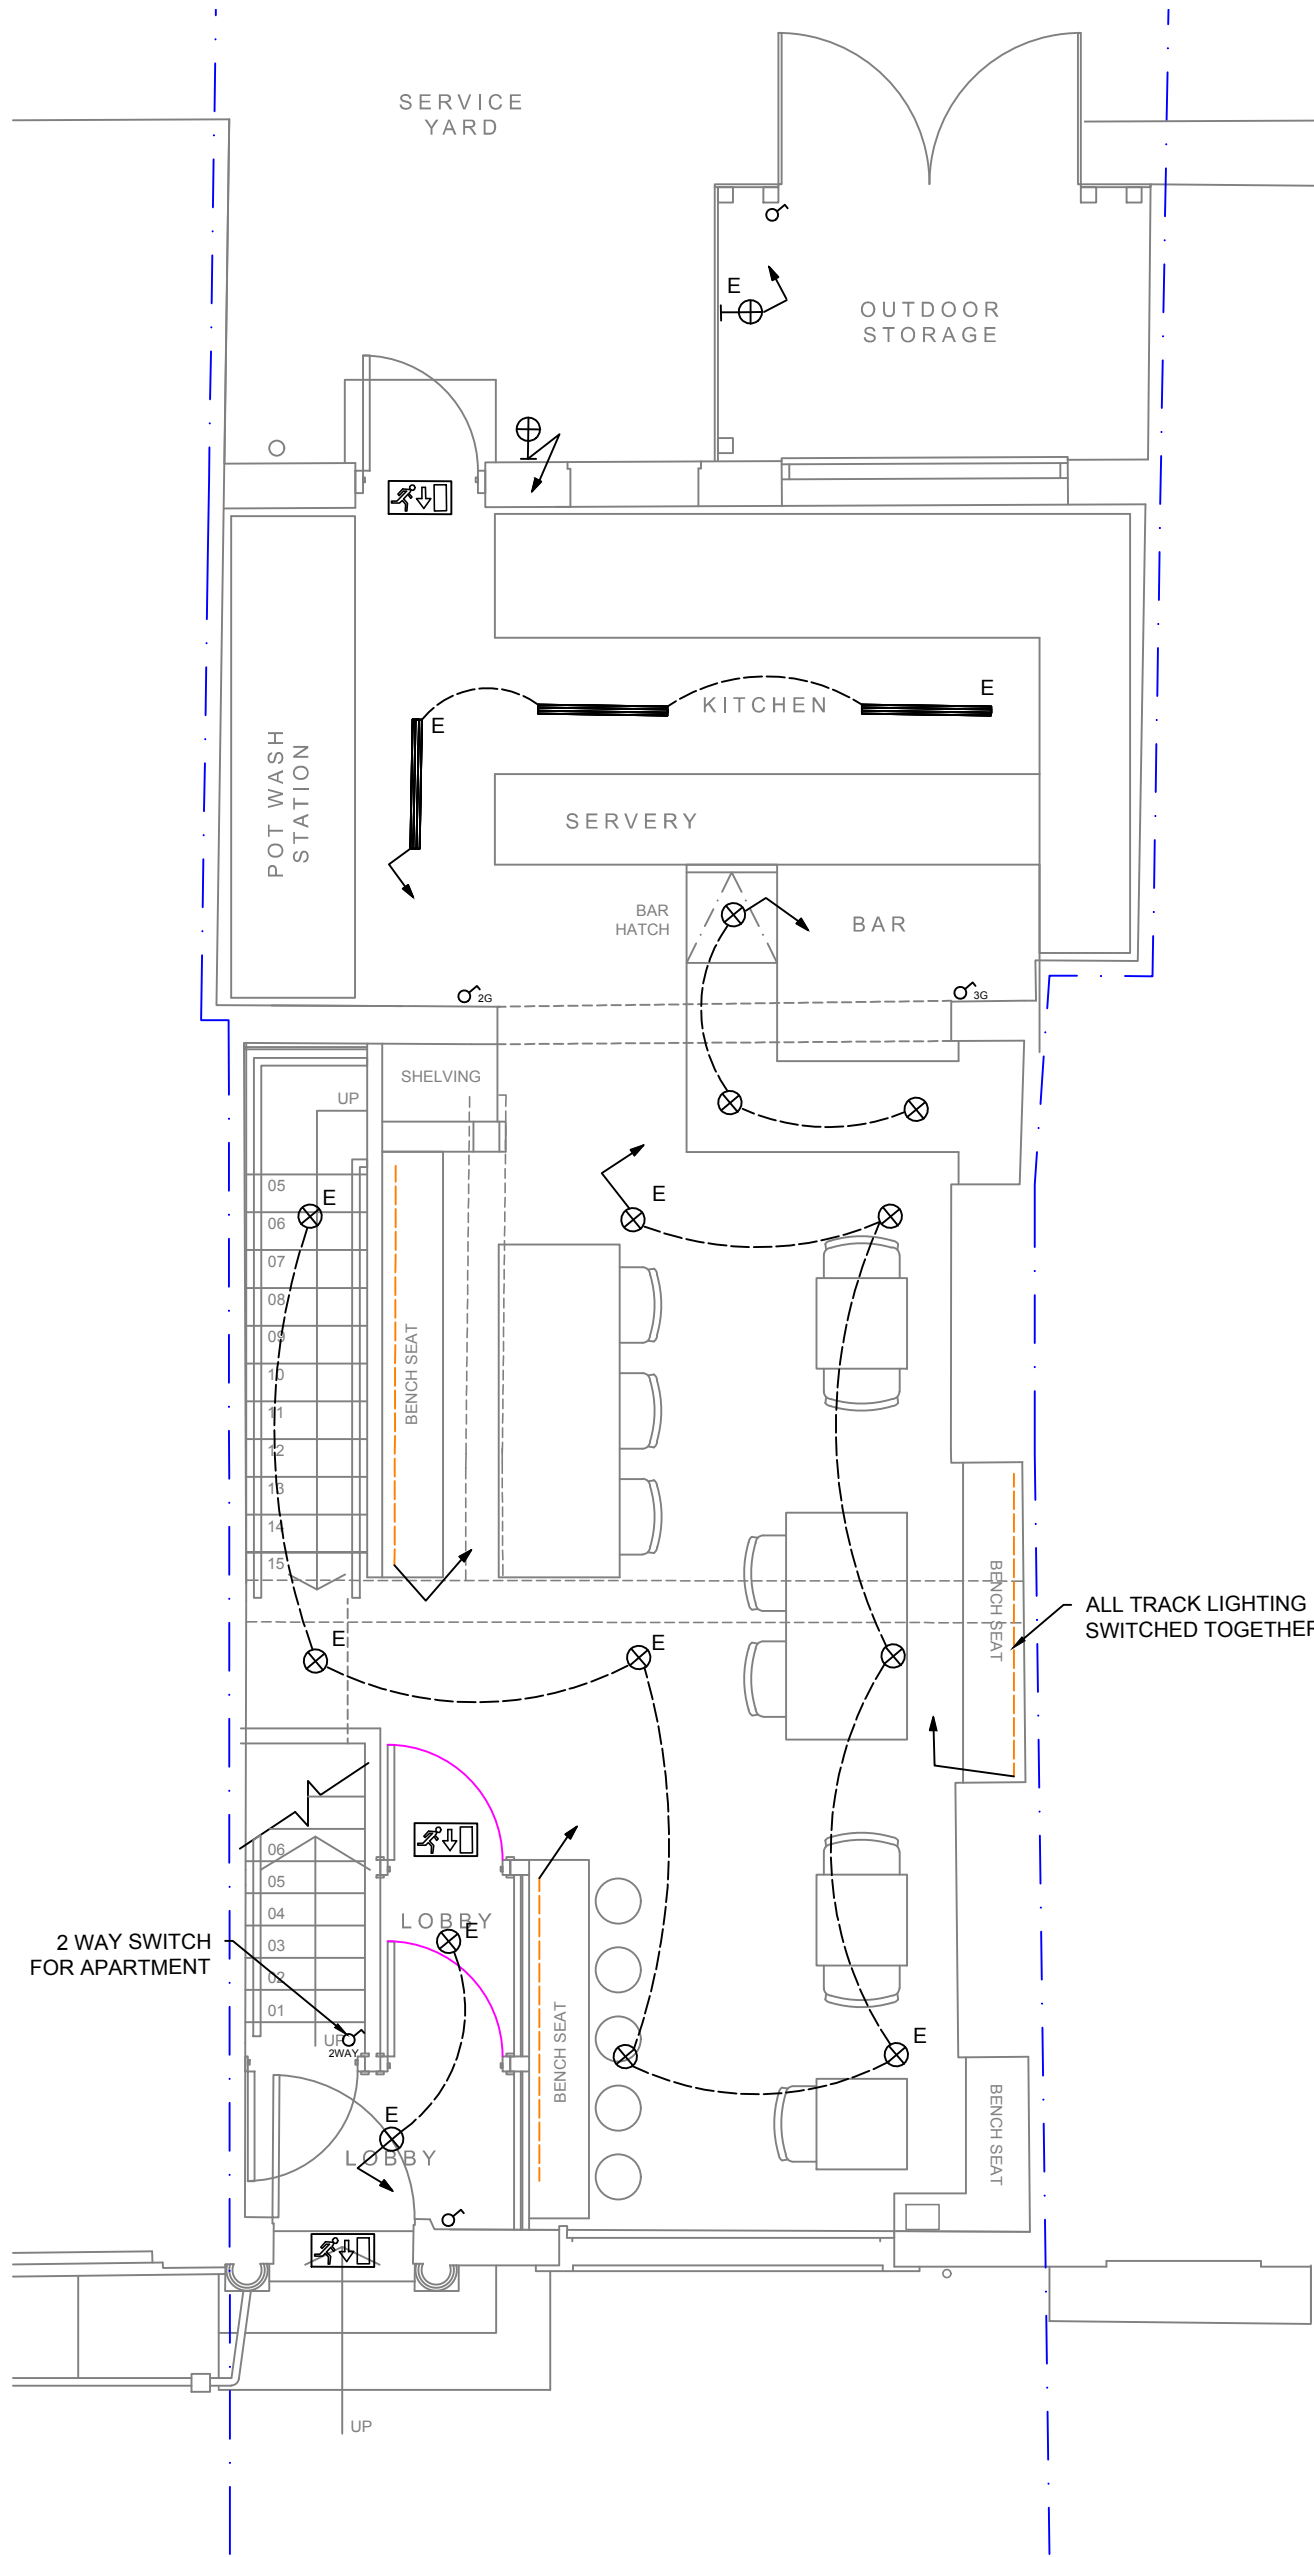

GROUND FLOOR

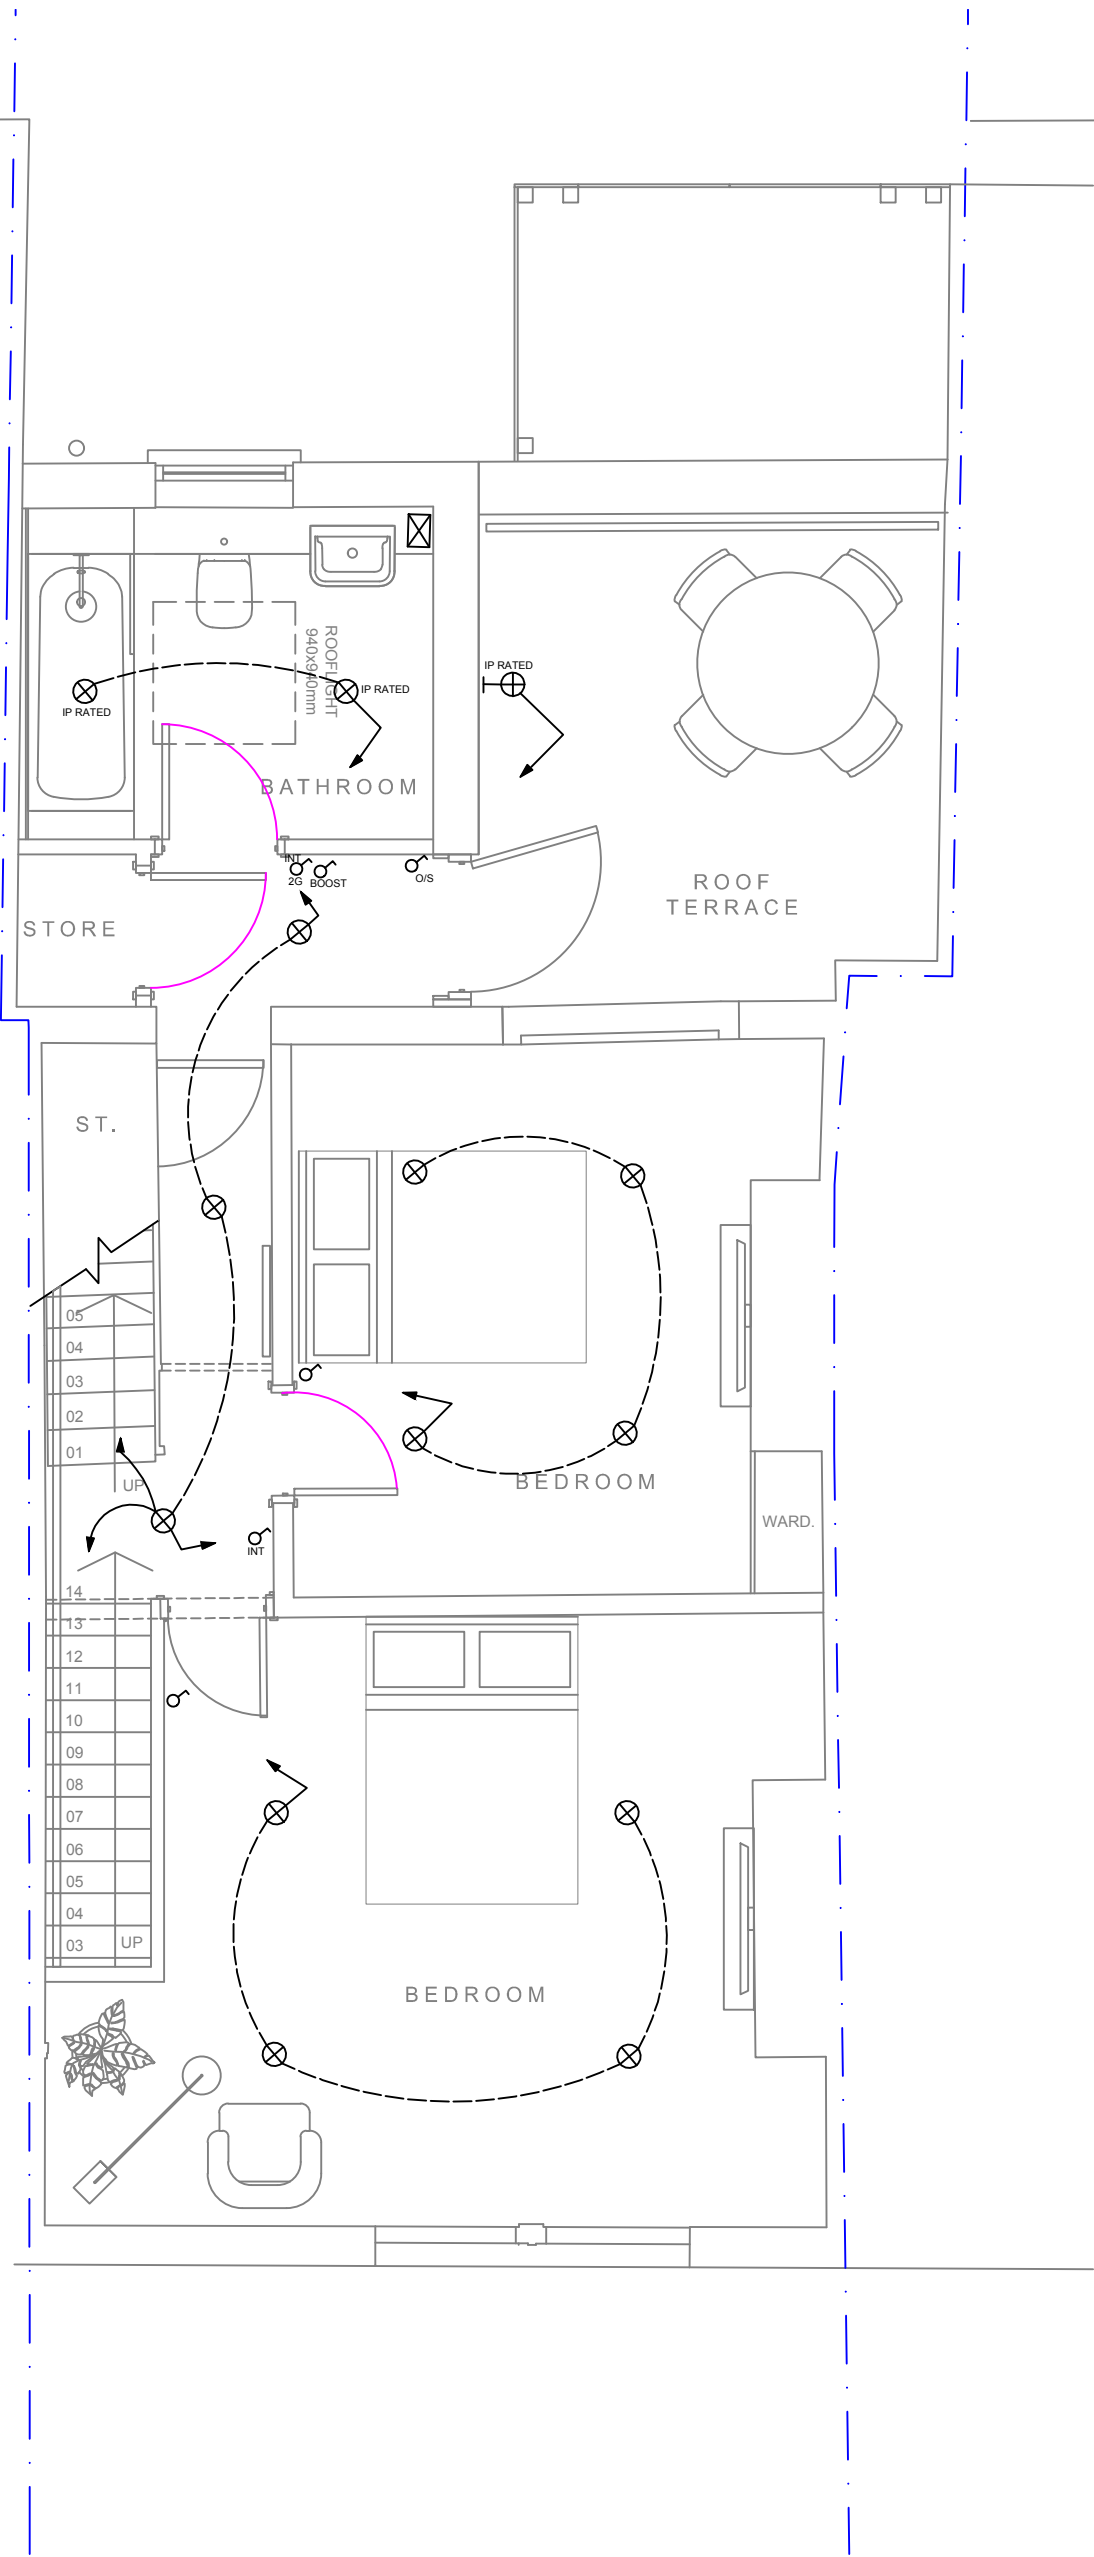

FIRST FLOOR

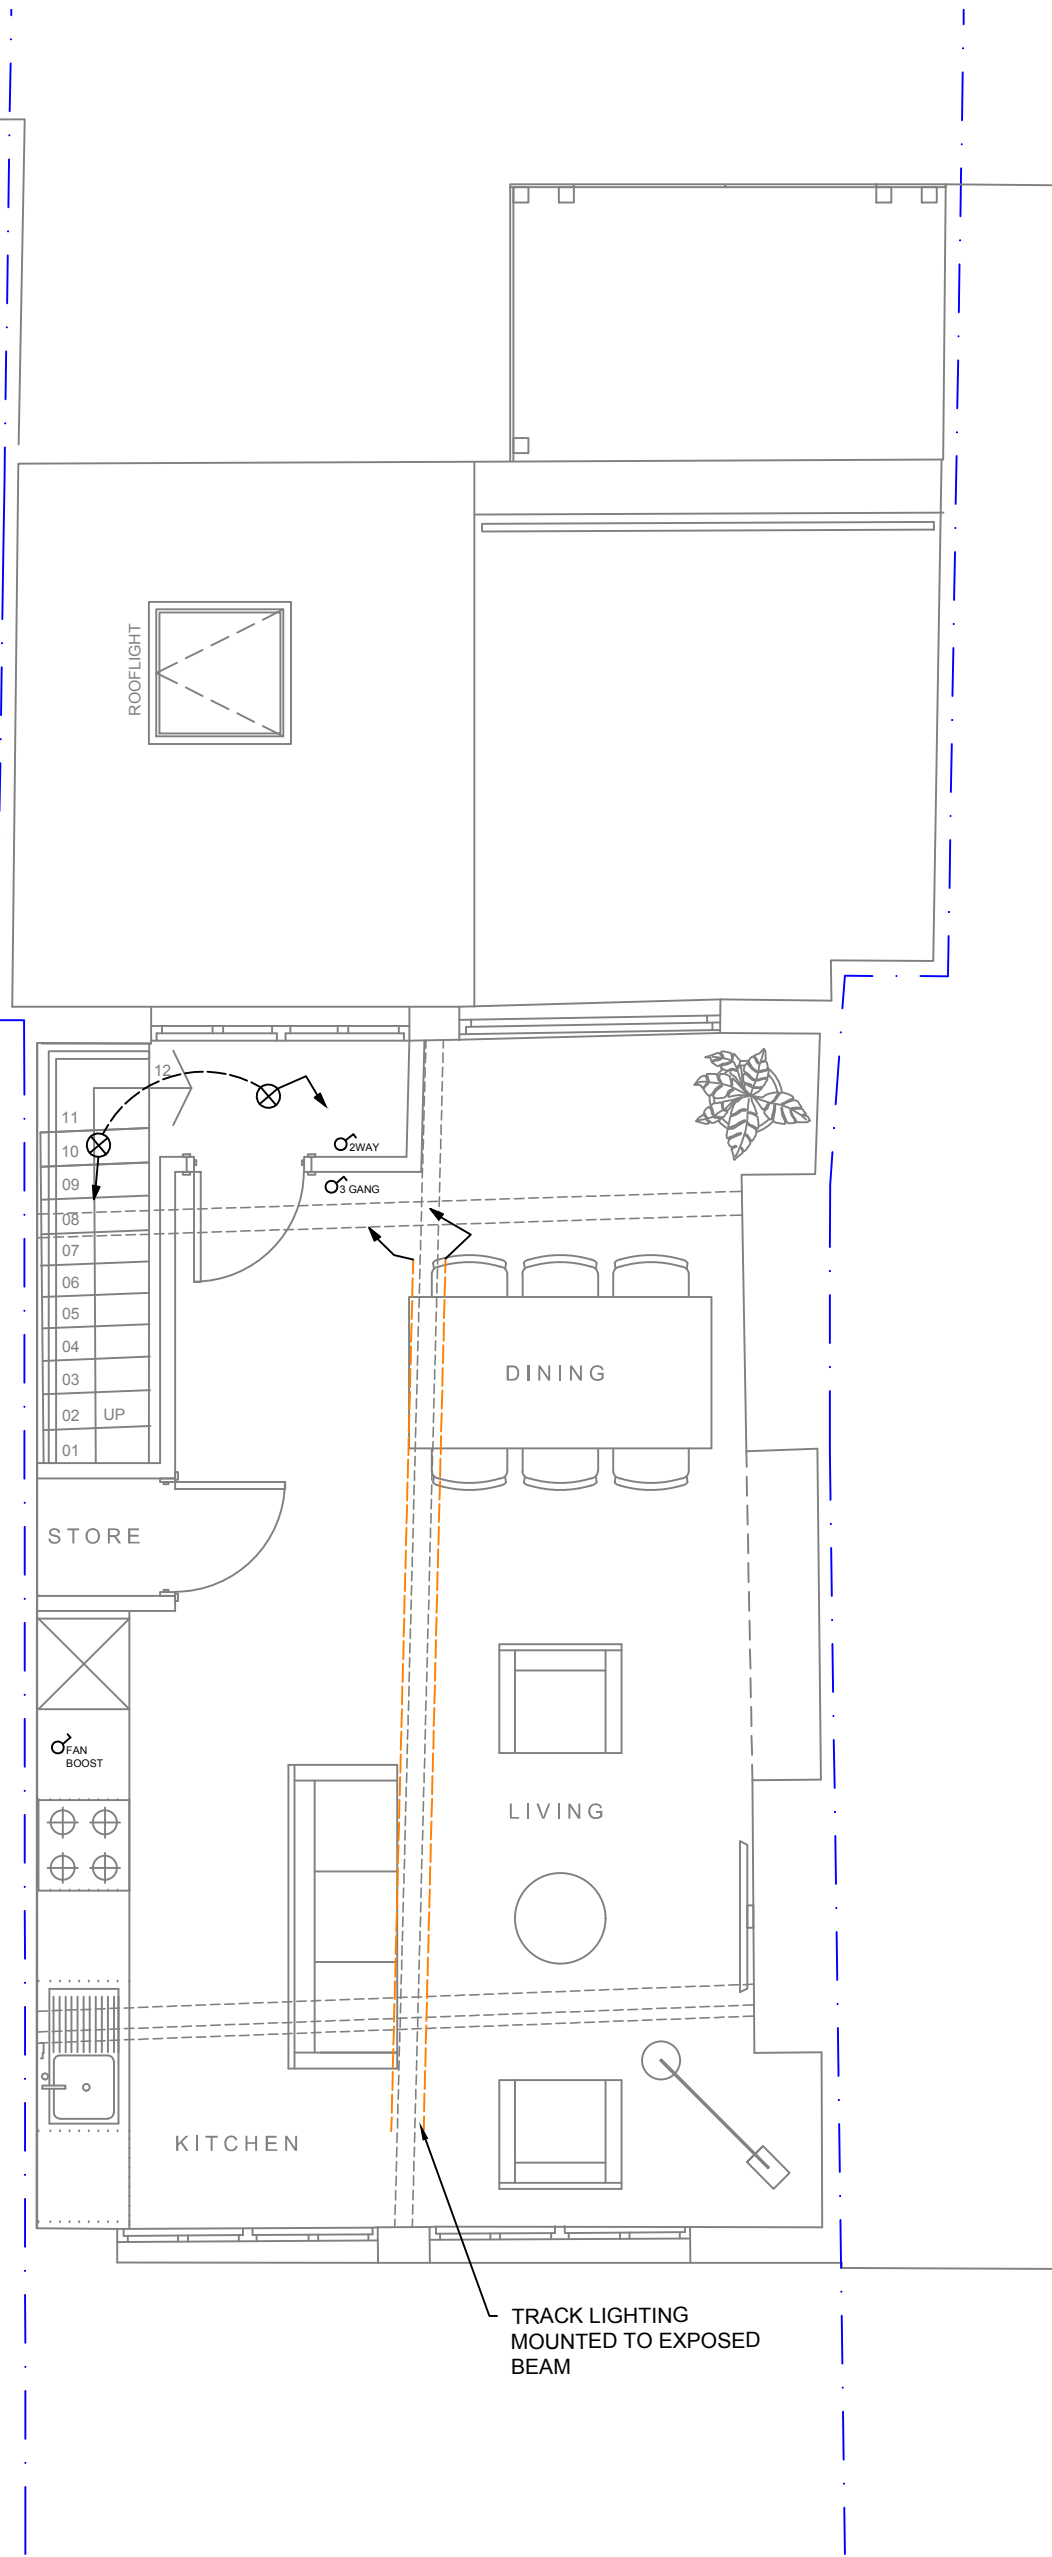

SECOND FLOOR

02	ST	06.03.23	STAGE 3 - COMMENTS INCORPORATE	
01	ST	23.02.23	STAGE 3 - PRELIMINARY	
REV/CHK	DATE	DESCRIPTION		
 AURA Technical Services Ltd. 97 Alderley Road Wilmslow SK9 1PT www.auratechnicalservices.co.uk				
Drawn: ST		Chkd: ST	App: RC	A1
Date: MAR'23		Scale: 1:50		
Project: 33 THOMAS STREET				
Drawing Title: ELECTRICAL SERVICES LIGHTING LAYOUT ALL FLOORS				
Drawing No: BAC001-AUR-ZZ-ZZ-DR-6301				Rev: P02