


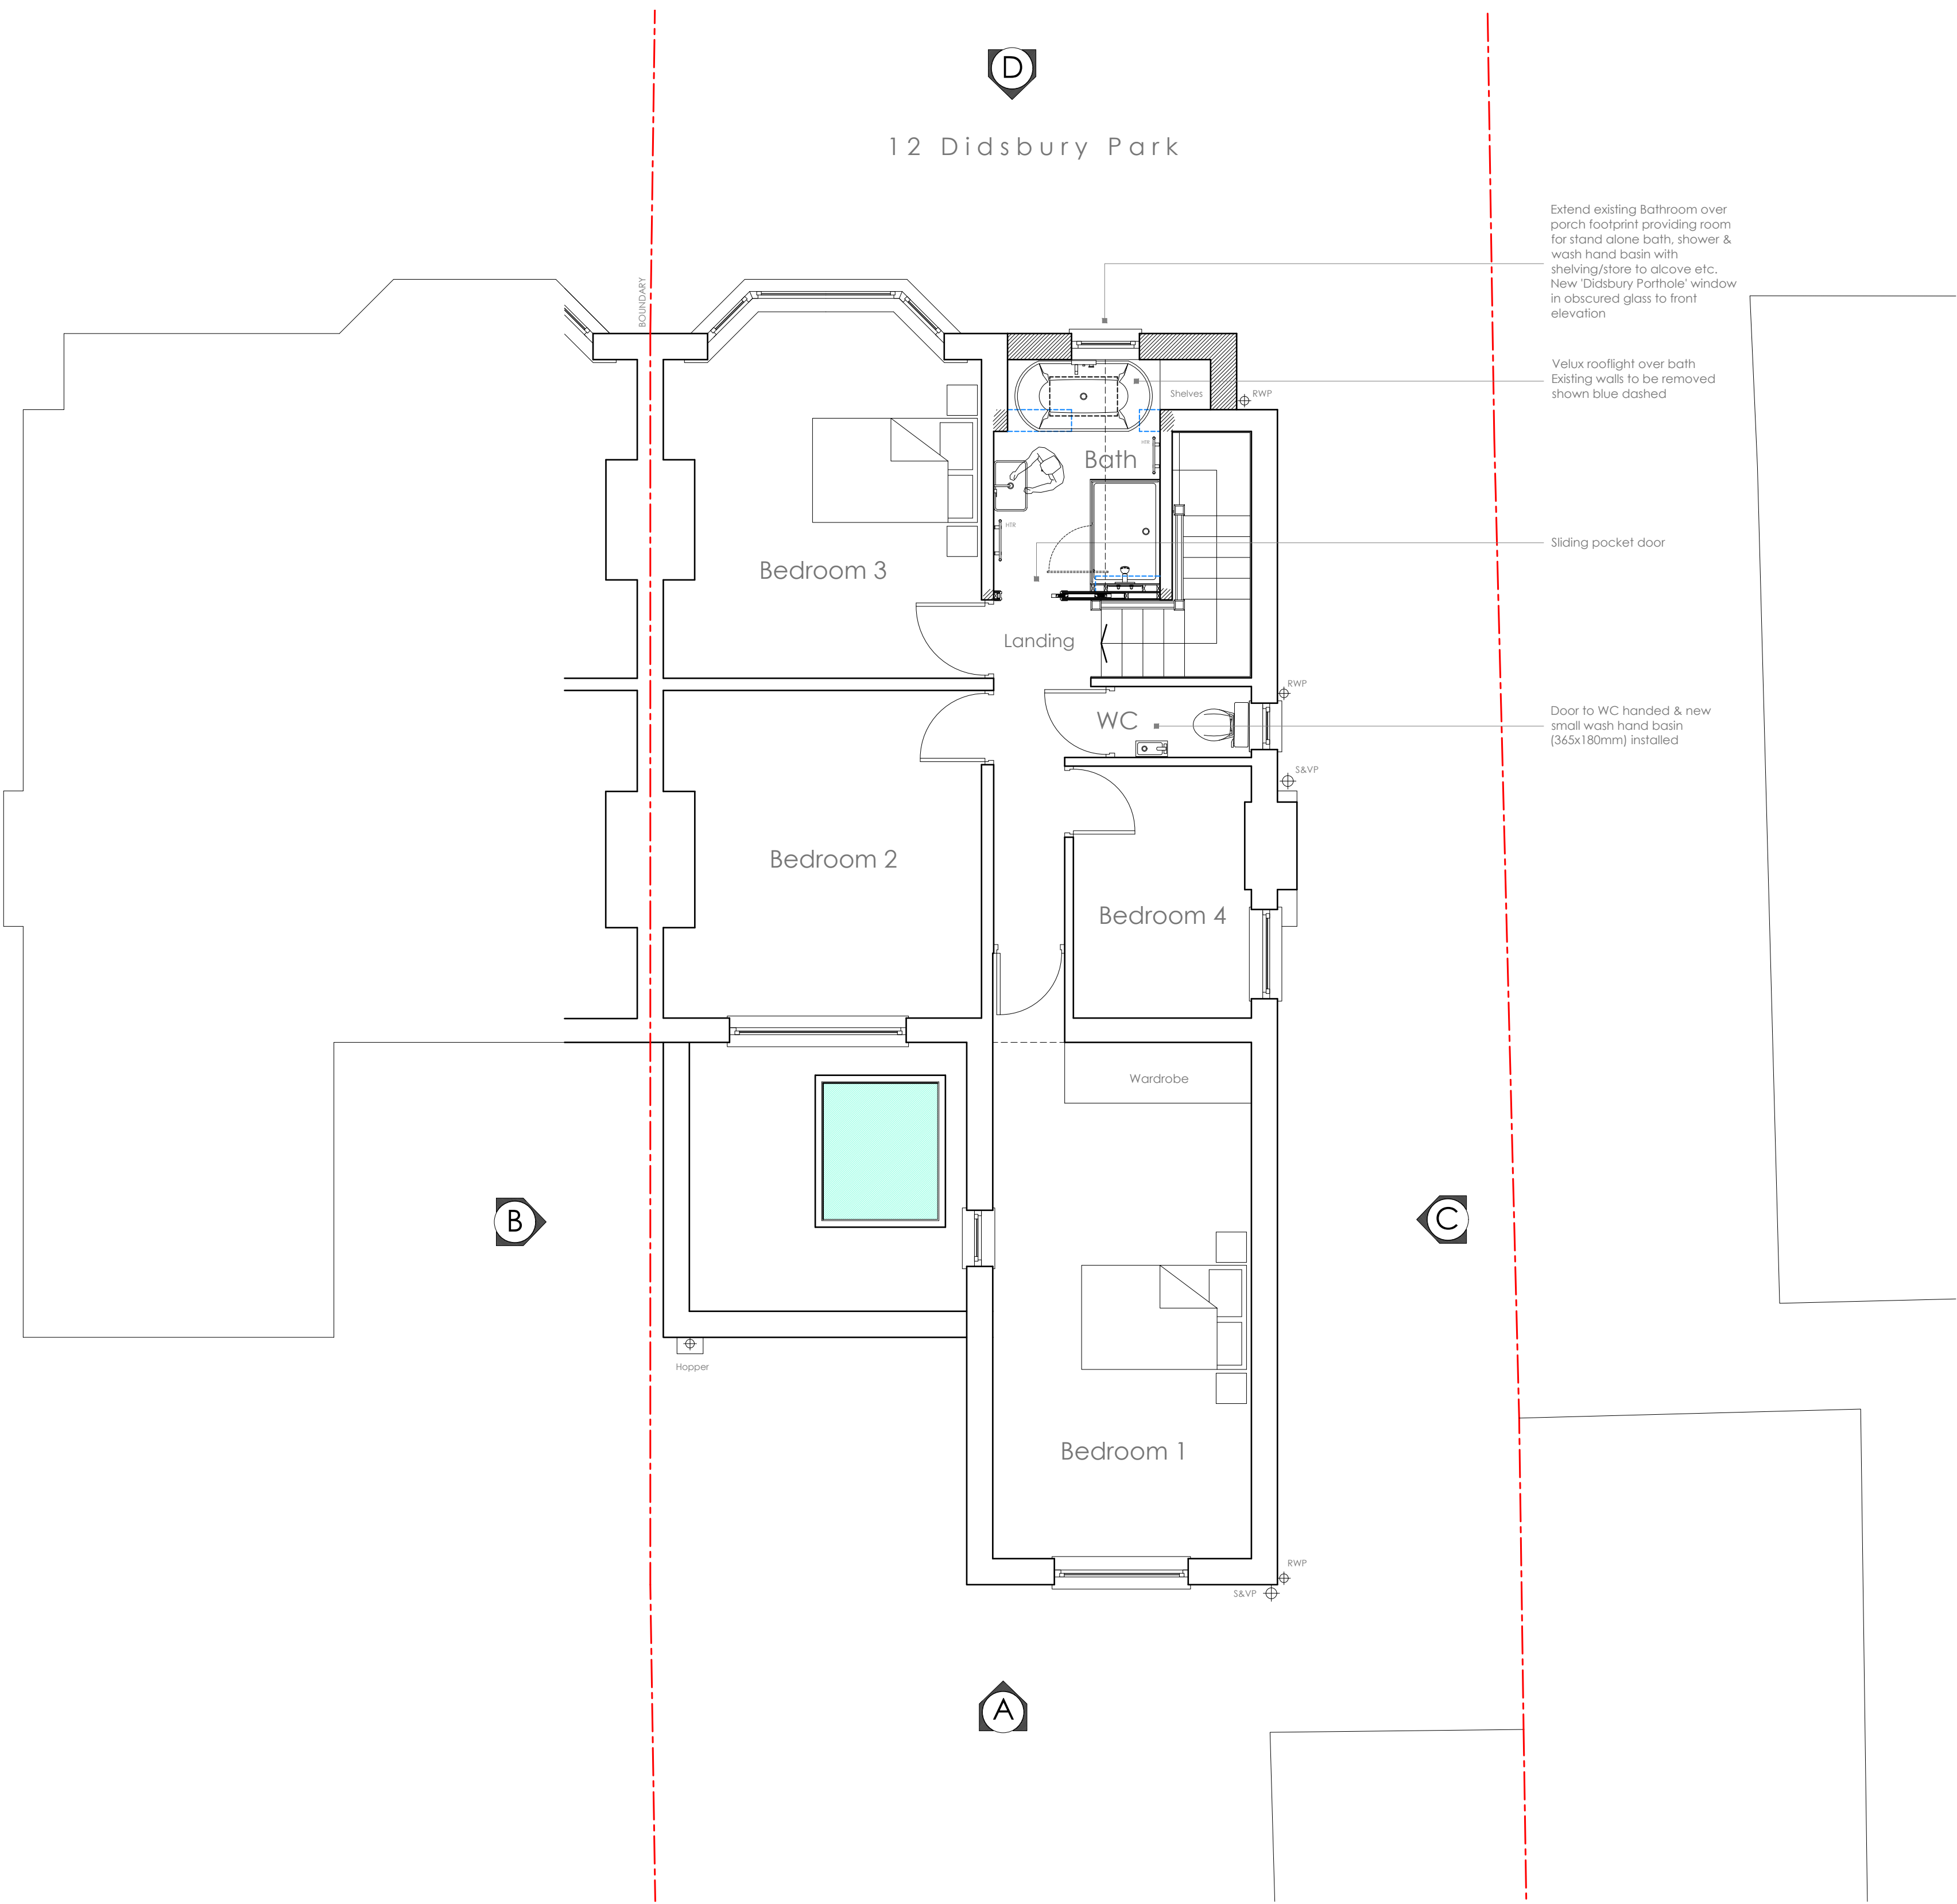

LEGEND

ELEVATION - DRAWING REFERENCE
SECTION - DRAWING REFERENCE
DETAIL LAYOUT - DRAWING REFERENCE
ASSEMBLY - DRAWING REFERENCE
ROOM NAME/ ROOMING FOR FINISHES REFER TO SCHEDULE.
LEVEL
DOOR NO. FOR TYPE/ DETAIL REFERENCES REFER SCHEDULE
WINDOW NO. FOR TYPE/ DETAIL REFERENCES REFER SCHEDULE
GRID LINE REFERENCE
WALL TYPE/ DETAIL REFERENCE. REFER TO SPECIFICATION
WARDROBE NO. FOR TYPE/ DETAIL REFERENCE REFER SCHEDULE
PANEL NO. FOR TYPE/ DETAIL REFERENCES REFER SCHEDULE
HEAT DETECTOR
SMOKE DETECTOR
MAINS OPERATED SMOKE ALARMS & ALARM SYSTEM WITH A BATTERY BACK UP IS REQUIRED TO AT LEAST GRADE D CATEGORY LD3 STANDARD IN ACCORDANCE WITH BS 5839 PART6:2004
NOTE:
ALL ELECTRICAL WORK COVERED BY PART P (ELECTRICAL SAFETY) MUST BE DESIGNED, INSTALLED, INSPECTED & TESTED BY A PERSON COMPETENT TO DO SO. THIS PERSON MUST BE REGISTERED WITH AN AUTHORISED SELF-CERTIFICATION SCHEME (eg BRE CERTIFICATION, BSI, ELECSA, NICEIC OR NAPT CERTIFICATION), PRIOR TO COMPLETION AN APPROPRIATE BS7671 ELECTRICAL INSTALLATION CERTIFICATE MUST BE PROVIDED BY THE COMPETENT PERSON.



©Crown Copyright and database right 2018
Ordnance Survey License: 100048957
Reproduction in whole or part is prohibited without the prior permission of Ordnance Survey
Serial No. 140513

LOCATION PLAN scale 1: 1250

DAMIANFIELD
ARCHITECTS

Springwood House, 4 Rose Lane, Mossley Hill, Liverpool, L18 5ED
t 07950 830844 www.damianfieldarchitects.co.uk
RIBA Membership 09128282 ARB Registration 062412H

PROPOSED WORKS TO
12 Didsbury Park
Didsbury, Manchester, M20 5LJ

TITLE
PROPOSED FIRST FLOOR PLAN
GENERAL ARRANGEMENT

DRAWING NO.

PROJECT	TYPE	(CATEGORY)	NUMBER	REVISION
401	L	(--)	04	-

SCALE 1:50 @ A1

DATE 12/04/2023

DO NOT SCALE FROM THIS DRAWING
ANY DISCREPANCIES BETWEEN DRAWINGS OR BETWEEN DRAWINGS & ACTUAL SITE CONDITIONS SHOULD BE IMMEDIATELY BE BROUGHT TO THE ATTENTION OF THE ARCHITECTS.