



SHIP CANAL HOUSE


TYPICAL WASHROOMS - CEILING + FEATURE LIGHTING LAYOUT

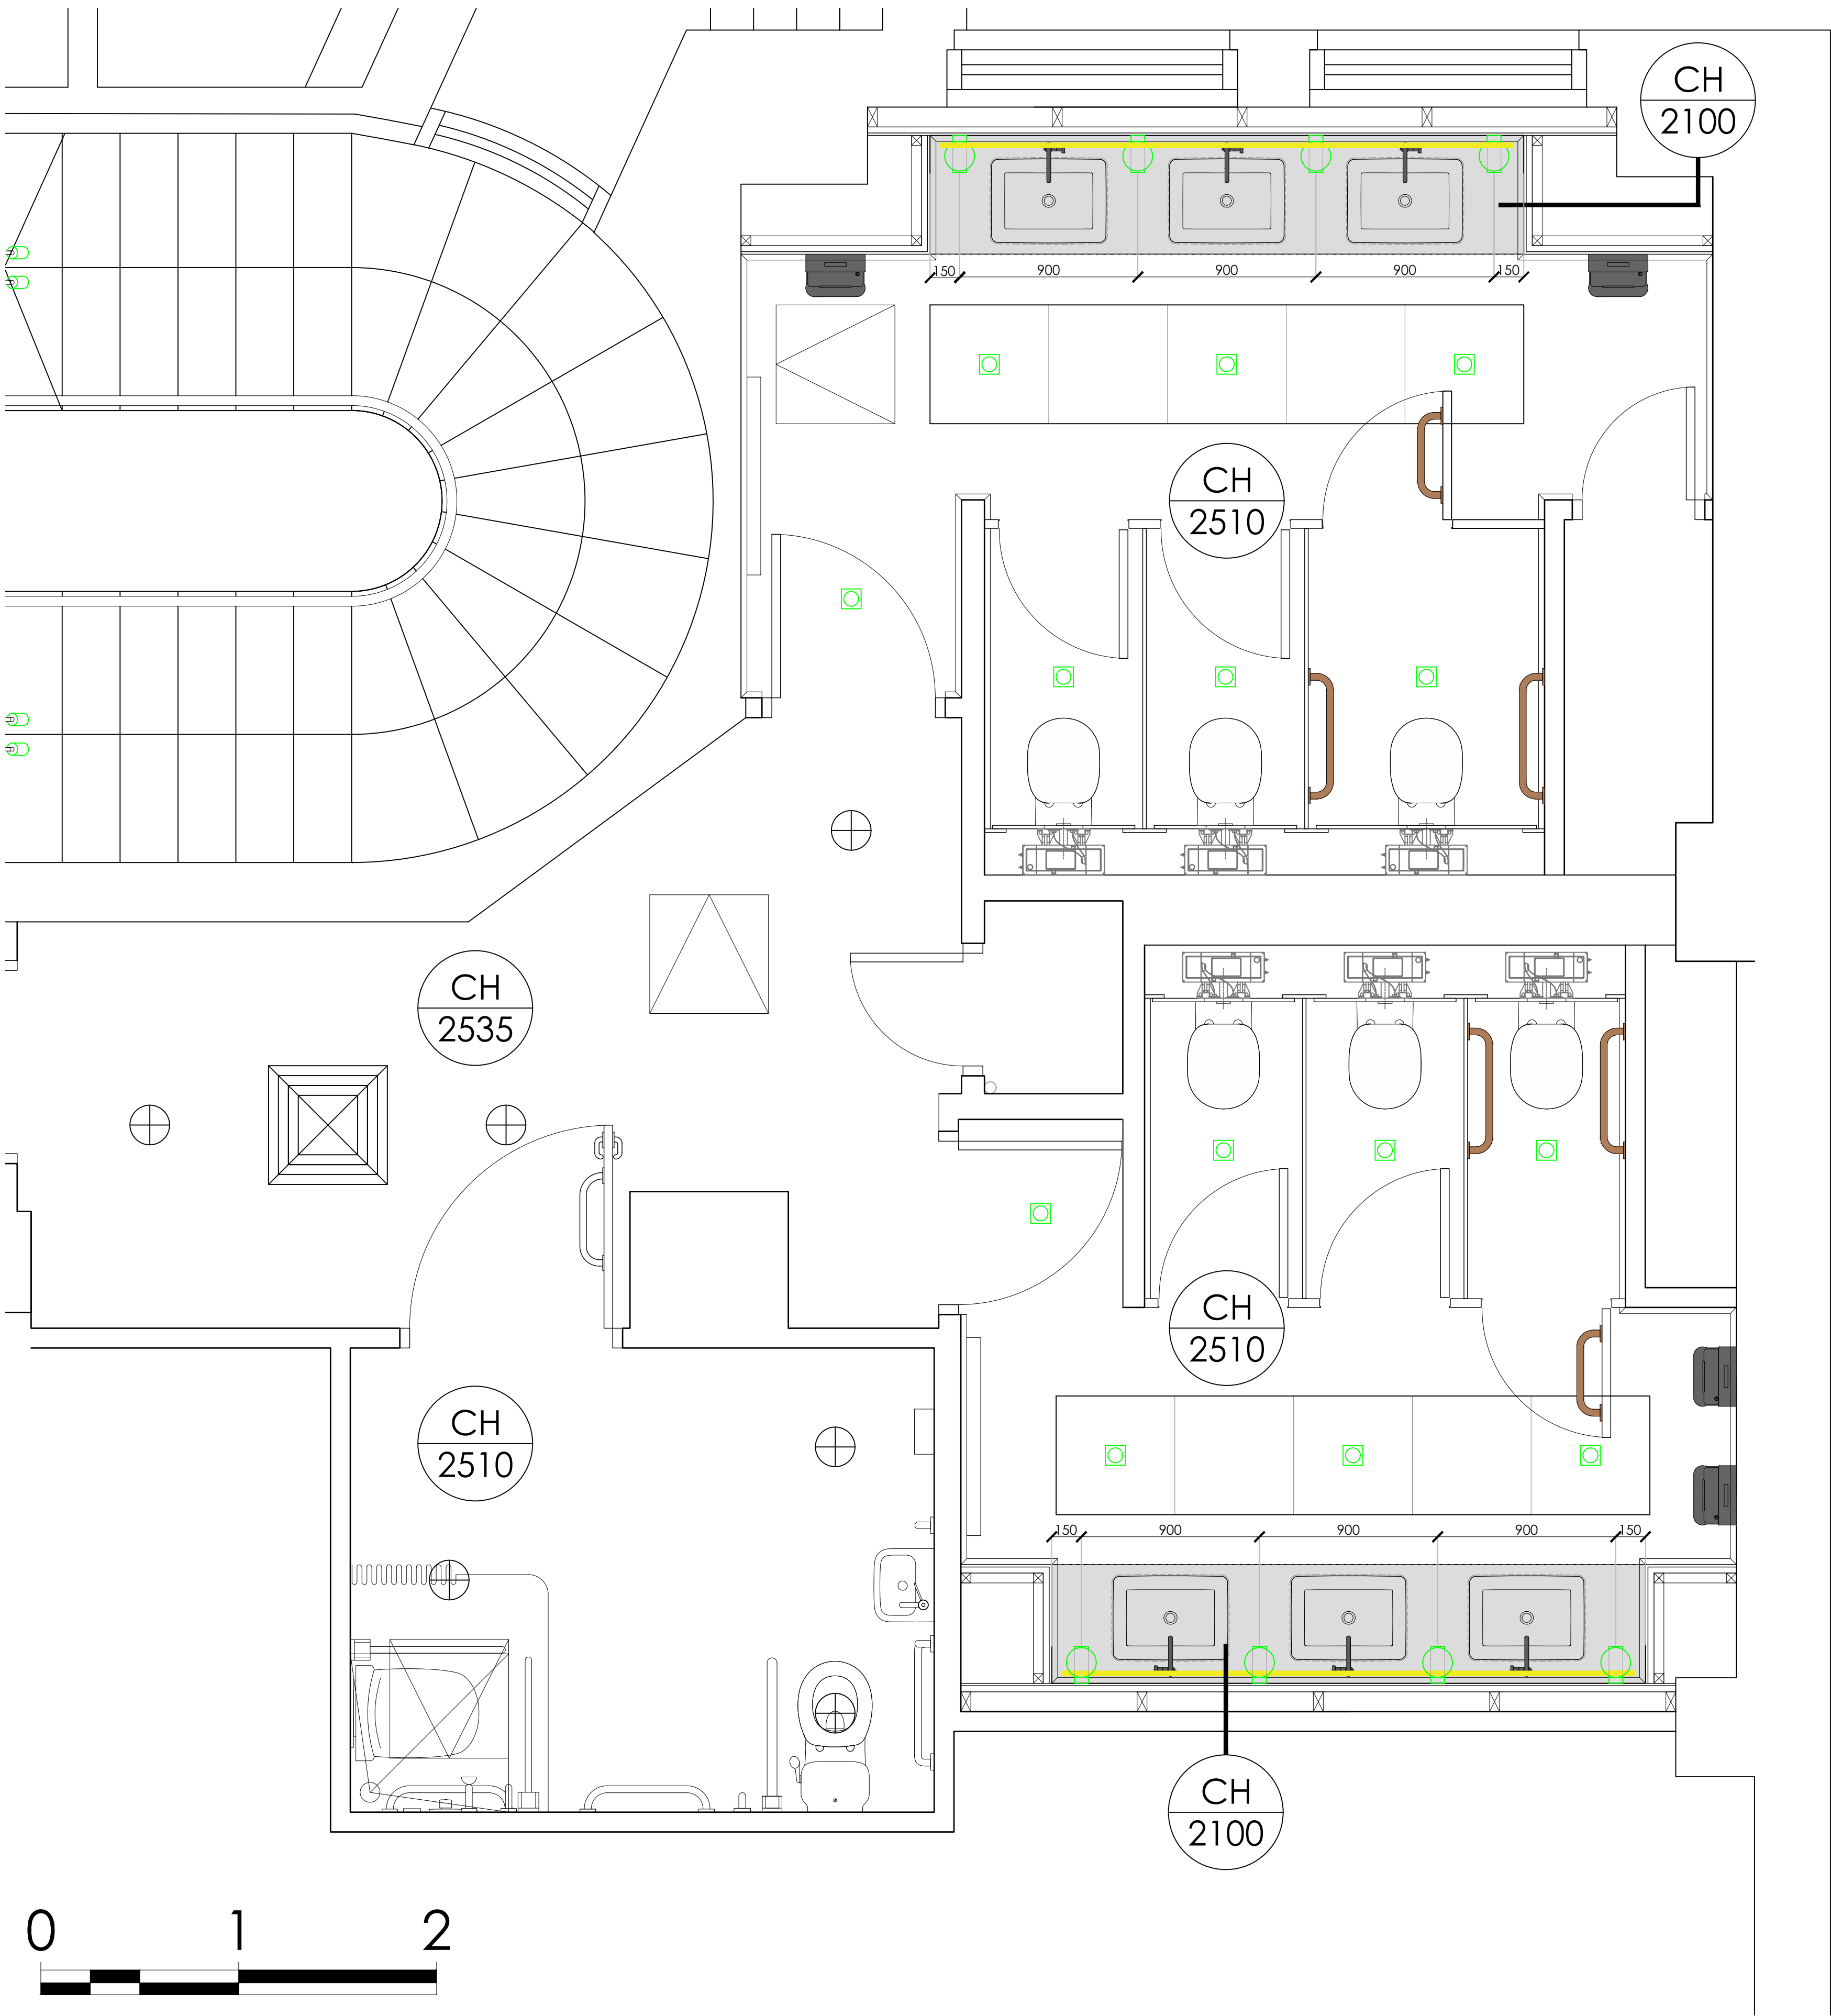

FEATURE CEILINGS KEY

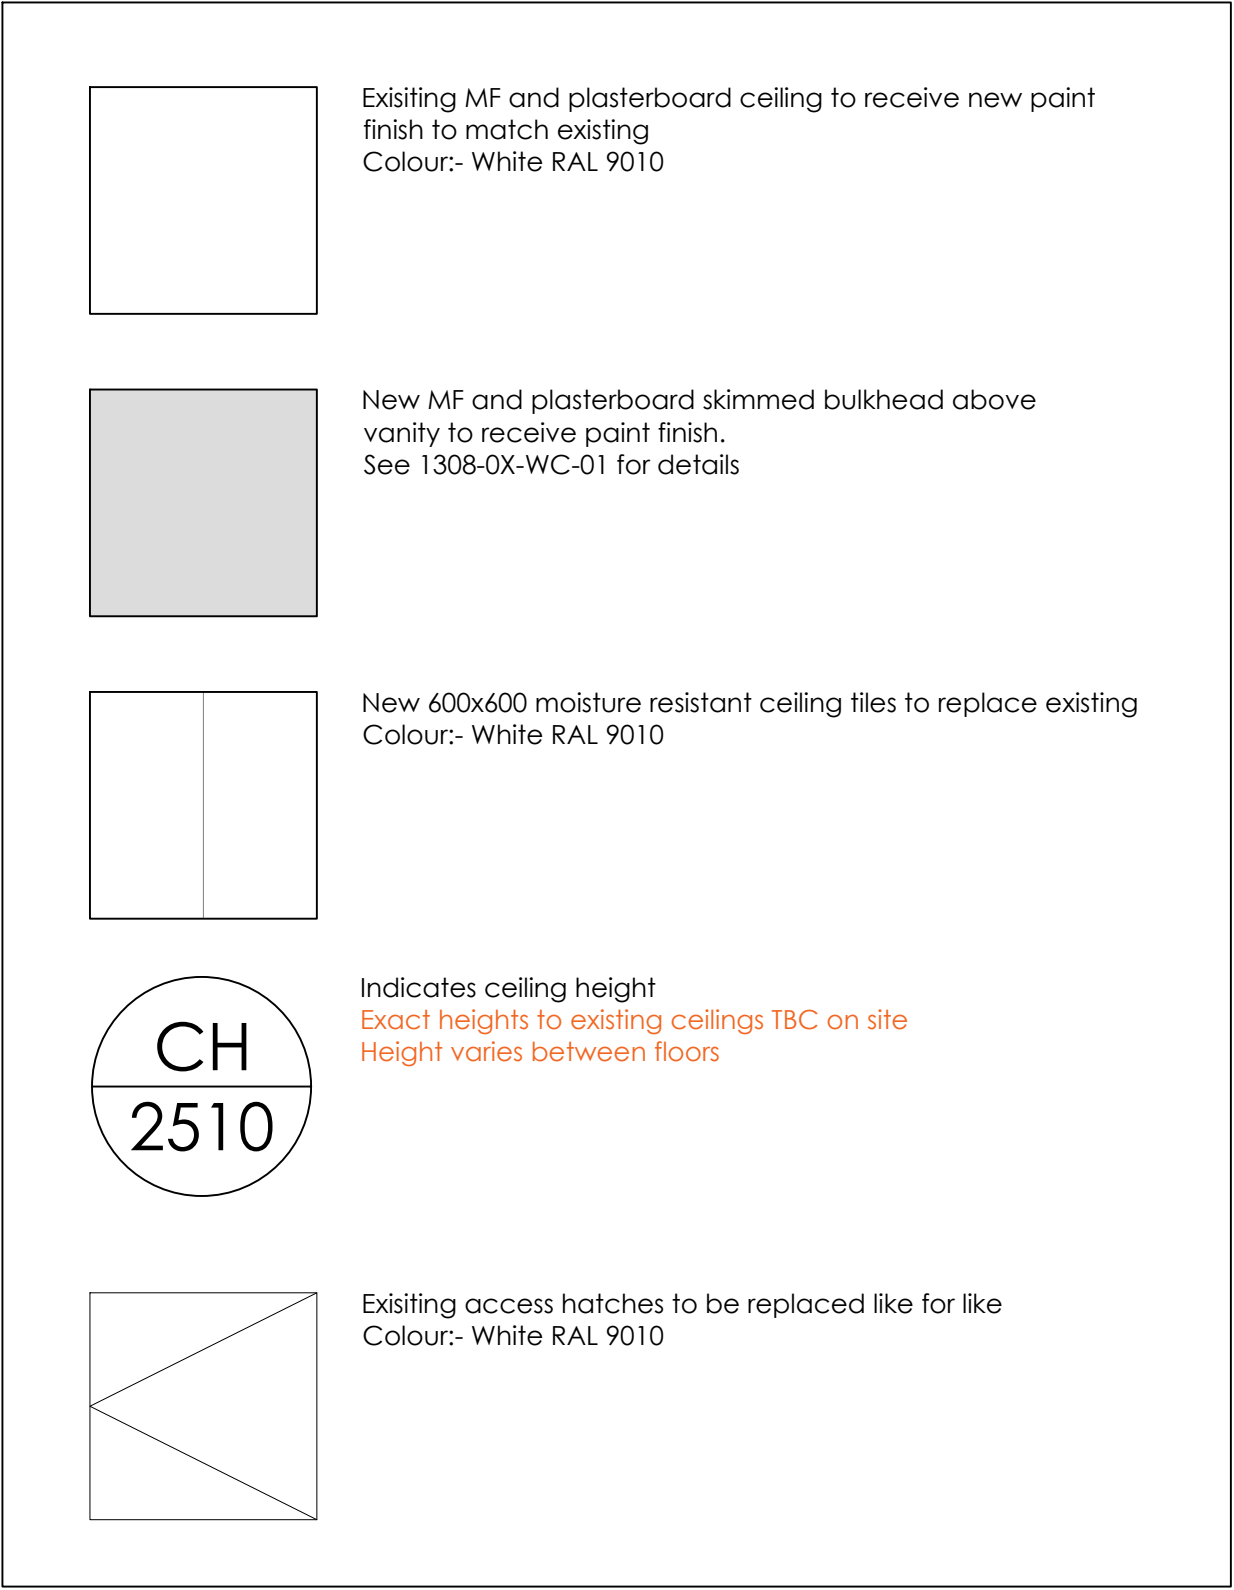

FEATURE LIGHTING KEY

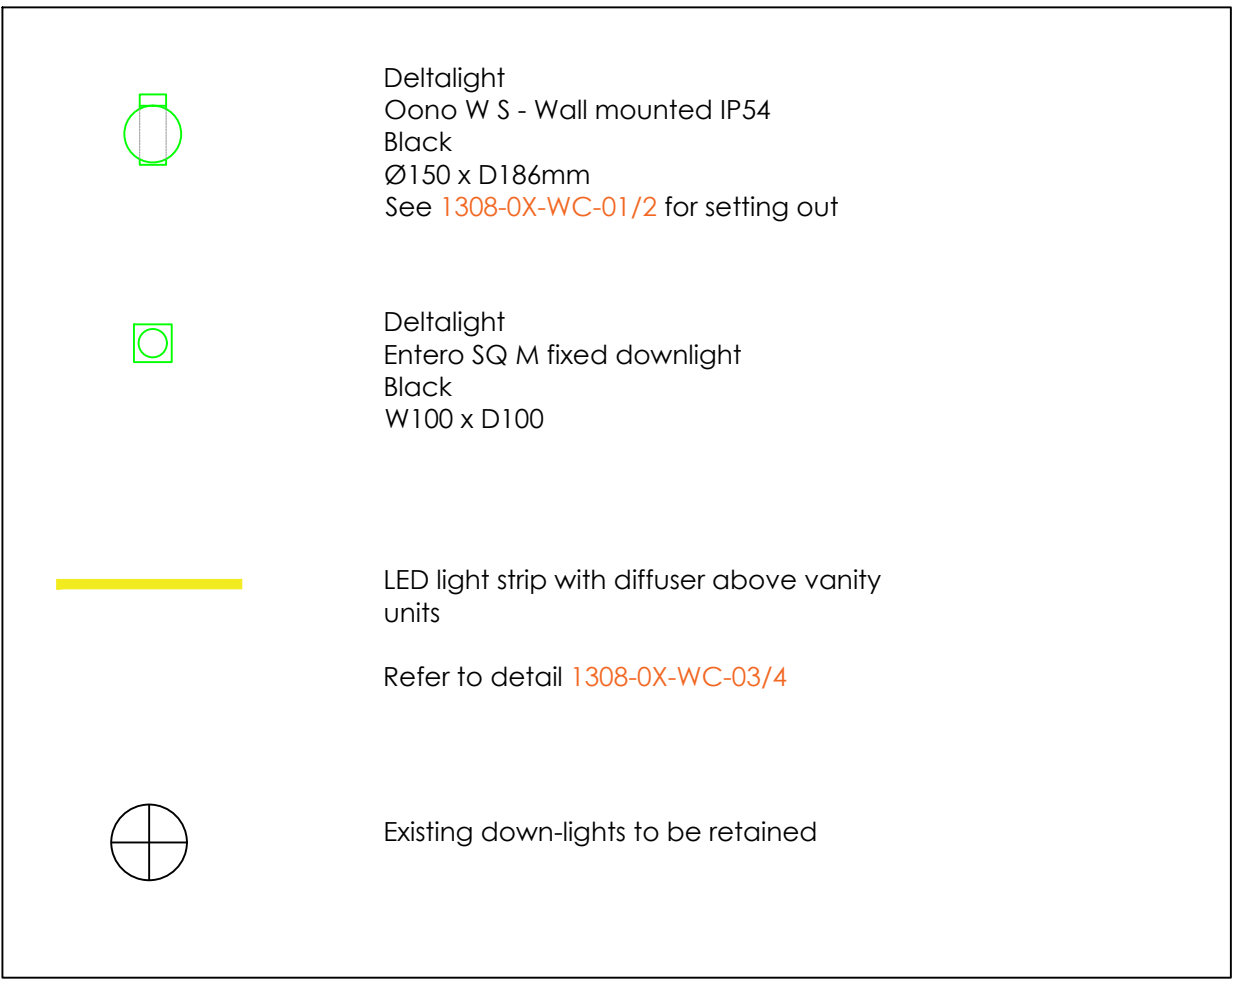

NOTES:
M&E LIGHTING CONSULTANT TO APPROVE ALL LIGHTING LEVELS AND POWER OUTPUTS.
FOR FULL M&E PROPOSALS, REFER TO M&E CONSULTANTS SPECIFICATION FOR ALL SERVICES RUNS, LIGHTING & ELECTRICAL LAYOUTS
THIS DRAWING SHOWS LIGHTING DESIGN INTENT ONLY FOR FEATURE LIGHTING SETTING OUT TO BE COORDINATED WITH M&E CONSULTANT'S LAYOUT

This drawing is the property of **bluesky** Design and must not be copied or otherwise reproduced. All dimensions must be checked on site before commencing work. This drawing was produced using AutoCAD 2019.

**NOTE: ALL DRAWING INFORMATION
SUBJECT TO SITE SURVEY AND DRAWING
UPDATES POST STRIP-OUT**

Rev	Date	Description	Initials
A	13.12.22	HERITAGE ISSUE	ST

Client:	GROSVENOR
Project:	SHIP CANAL HOUSE
Address:	SHIP CANAL HOUSE, KING STREET
Drawing Title:	TYPICAL WASHROOMS - CEILING + FEATURE LIGHTING LAYOUT
Date:	25.11.2022
Project Number:	1308
Scale:	1:20 @A1
Drawn by:	CEB
Drawing Number:	1308-0X-CL-02