

INDICATIVE SPRINKLER PLANT ROOM

1. SPRINKLER TANK (VOLUME TBC BY FIRE SPECIALIST)
2. SPRINKLER PUMP SET
3. CONTROL PANEL WITH FIRE ALARM INTERFACE


SPACE FOR METER POSITIONS

9-WAY BEMCO TYPE FUSE DB 535mm WIDE

LUCY CUTOUT 500mm WIDE, 200mm DEEP

2500

DUCT THROUGH TO CUTOUT POSITION

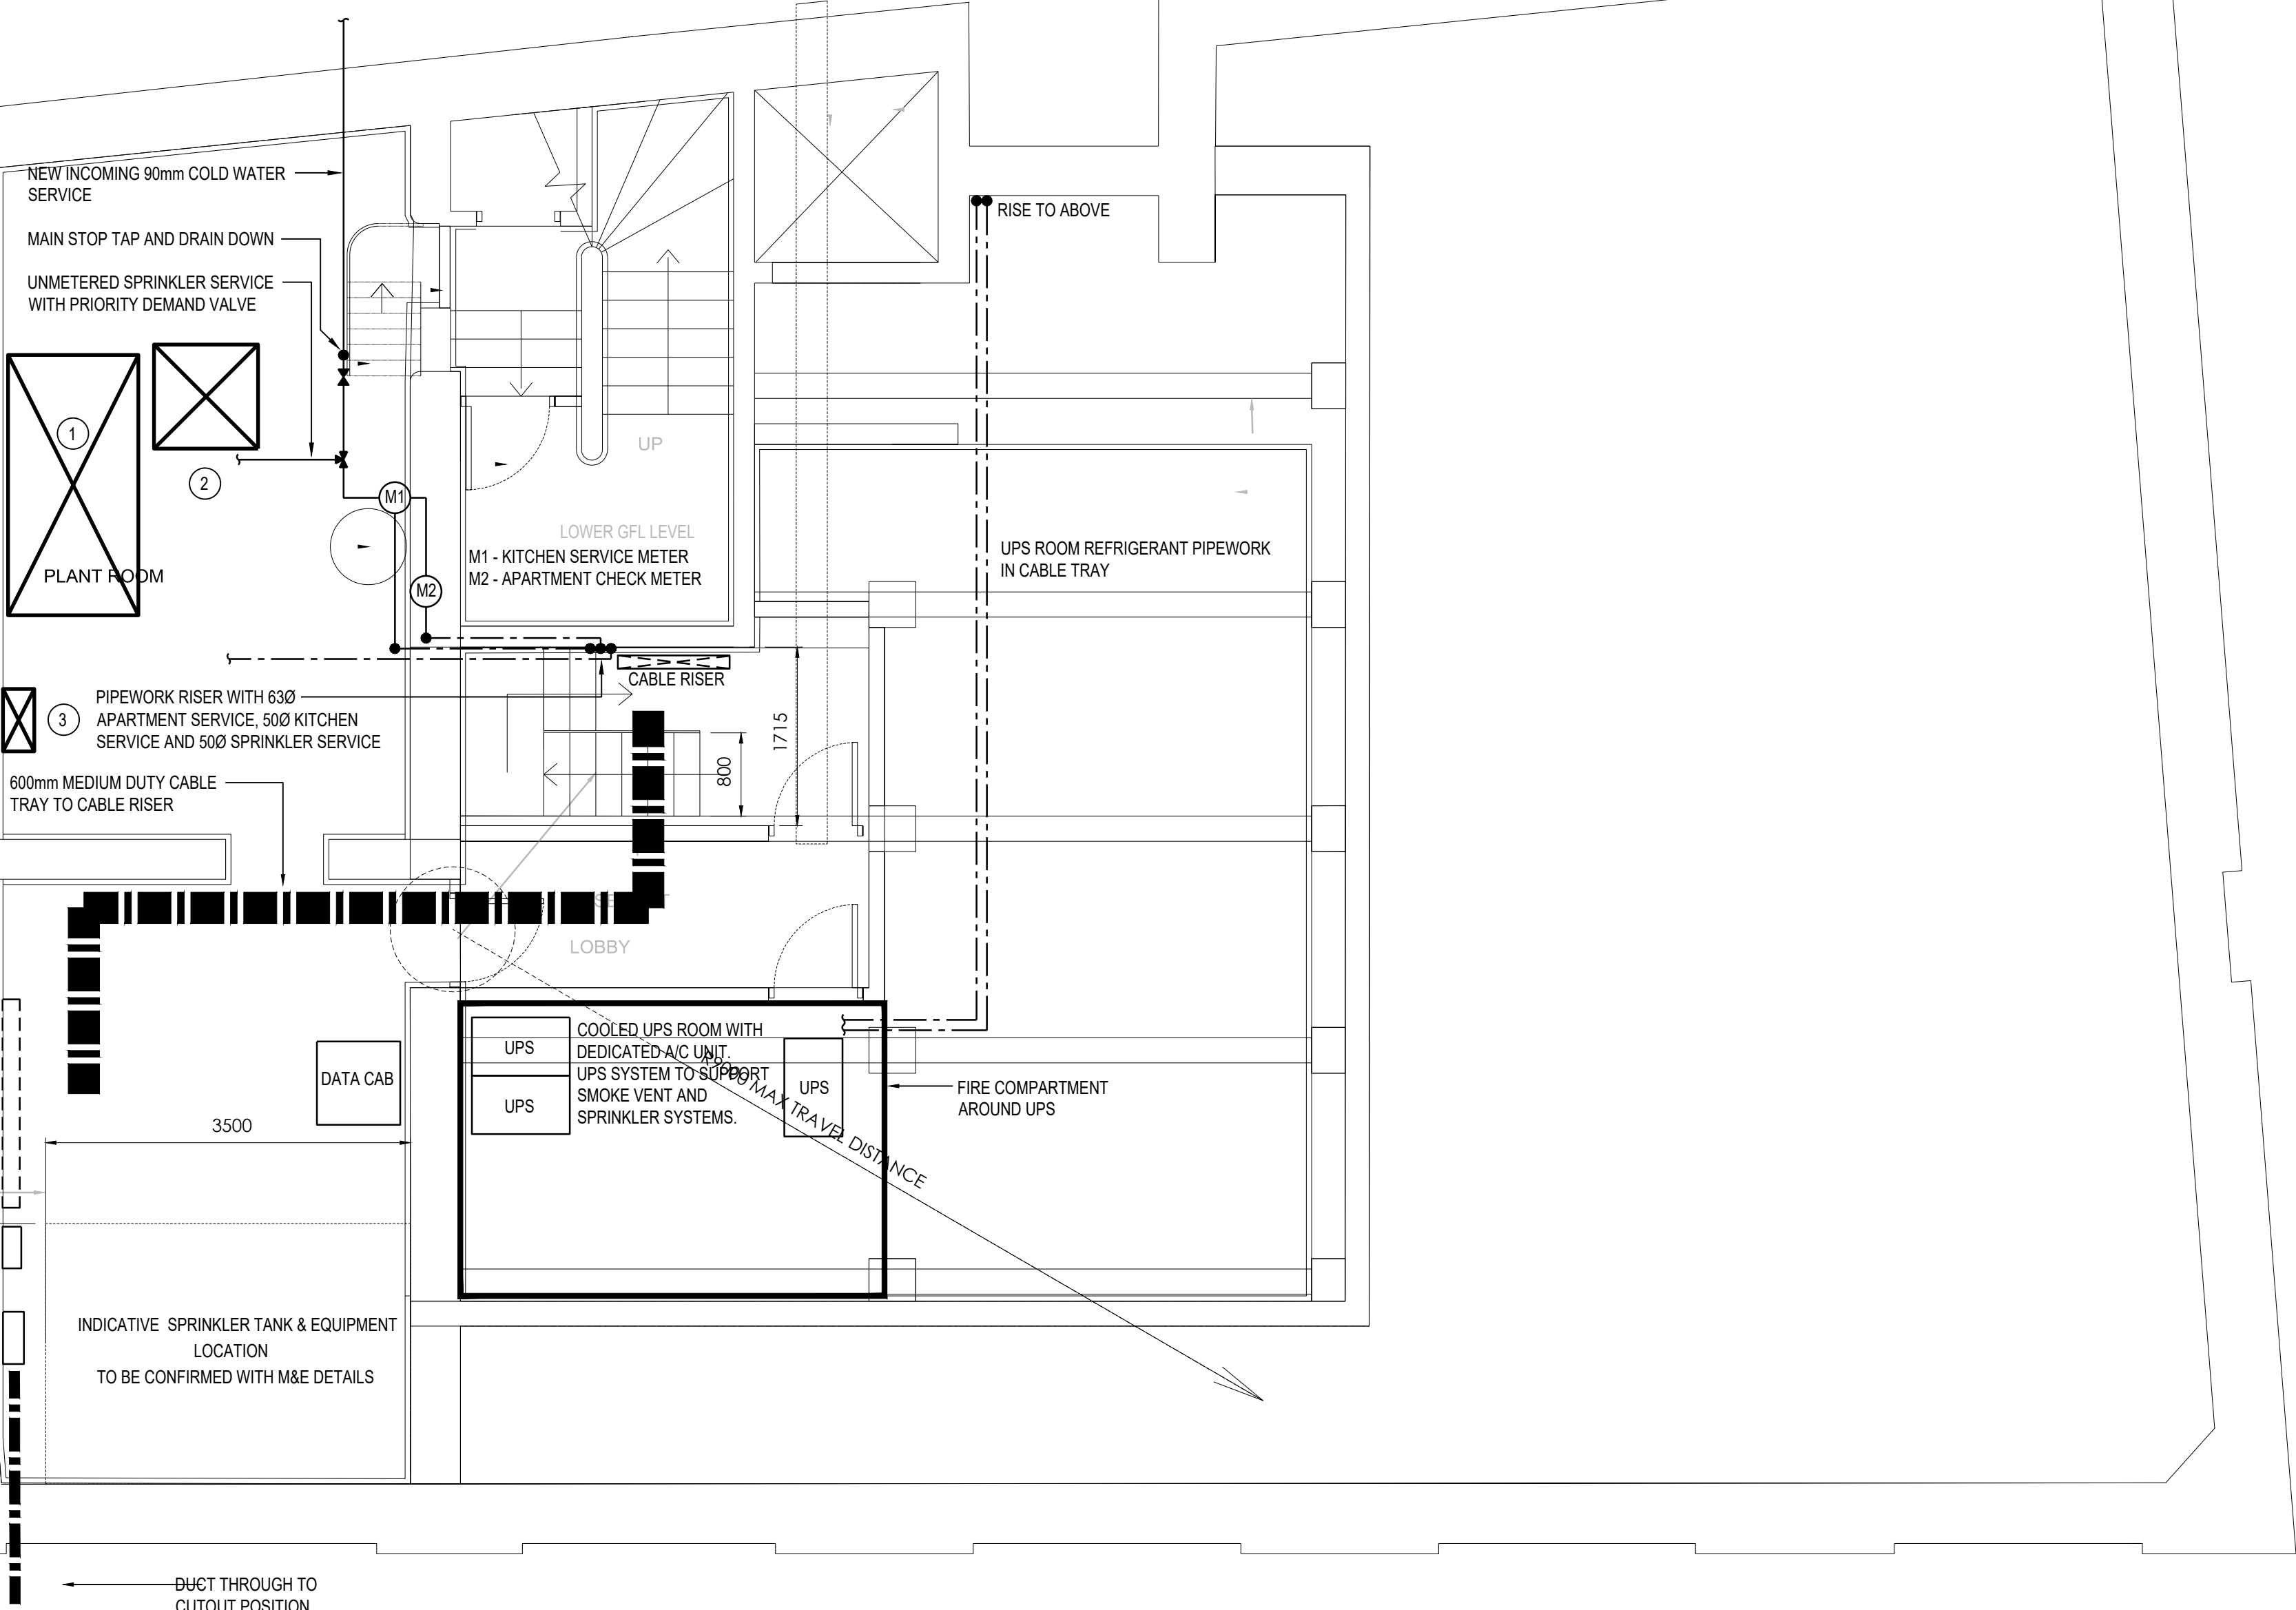

NOTES

1. ALL SERVICE ROUTES DETAILED ARE APPROXIMATE. THE CONTRACTOR SHALL BE RESPONSIBLE FOR DETERMINING THE EXACT ROUTES AND POSITIONS OF ALL INSTALLED SERVICES AND EQUIPMENT.
2. THE EXACT POSITION OF ALL SERVICES AND EQUIPMENT SHALL BE AGREED BY THE CONTRACT ADMINISTRATOR.
3. THE CONTRACTOR SHALL BE RESPONSIBLE FOR FULLY CO-ORDINATING ANY SERVICES INSTALLED WITH THE BUILDING FABRIC AND SERVICES INSTALLED BY OTHERS.
4. THIS DRAWING SHALL BE READ IN CONJUNCTION WITH ALL MECHANICAL, ELECTRICAL, ARCHITECTURAL AND STRUCTURAL DRAWINGS, CONTRACT DOCUMENTATION AND SPECIFICATION FOR THE WORKS.
5. THIS DRAWING FORMS PART OF THE SPECIFICATION FOR THE WORKS.
6. ALL DIMENSIONS SHOWN ARE IN MILLIMETRES.
7. DO NOT SCALE FROM THIS DRAWING.
8. EXISTING SERVICES SHOWN FAINT.

READ IN CONJUNCTION WITH
PWC REPORT: 4193-SSR-001

P5	12-05-23	ISSUED FOR INFORMATION
P4	25-04-23	ISSUED FOR INFORMATION
P3	21-12-22	ISSUED FOR INFORMATION
P2	02-12-22	ISSUED FOR INFORMATION
P1	29-11-22	ISSUED FOR INFORMATION
REV	DATE	REVISION DESCRIPTION

CLIENT
THE SPACE STUDIO

PROJECT
FRASER HOUSE
36 CHARLOTTE STREET
MANCHESTER

TITLE
MECHANICAL AND ELECTRICAL SERVICES -
BASEMENT LEVEL



■ Burnham House, 373 Bury New Road,
Manchester, M25 1AW
T: 0161 773 1177 F: 0161 773 9977
manchester@parker-wilson.co.uk

□ 2nd Floor, 72, Cannon Street,
London EC4N 6AE
T: 0207 251 4500
london@parker-wilson.co.uk

www.parker-wilson.co.uk

DRAWN BY J.F.	CHECKED B.P.	APPROVED BY P.G.
SCALE 1:50	SIZE A1	DATE November 2022

DRAWING No 4193-B-SK102	REV P5
----------------------------	-----------

PRELIMINARY