



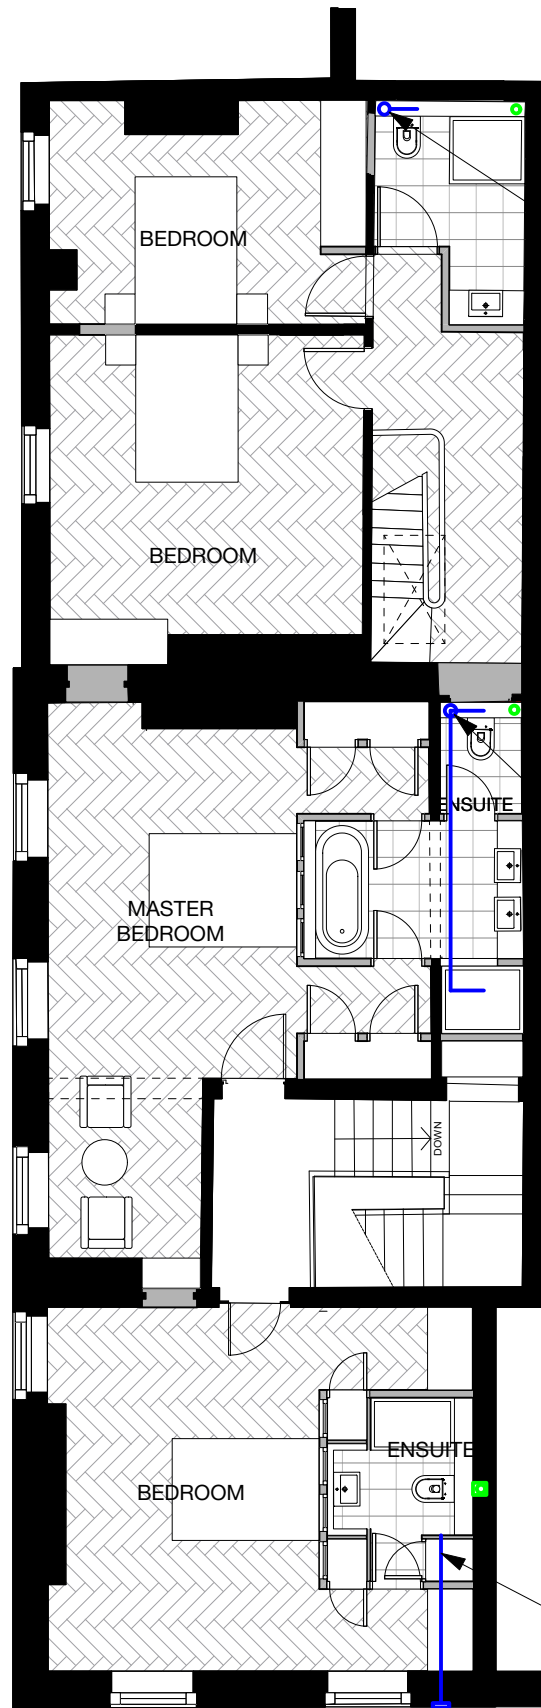

Vertical extract duct picking up extract from shower room.

Vertical extract duct picking up extract from ensuite

Extract duct from ensuite taken down into raised floor and positioned to run to outside wall between joists, within depth of existing floor. Bespoke wall terminal to outside.

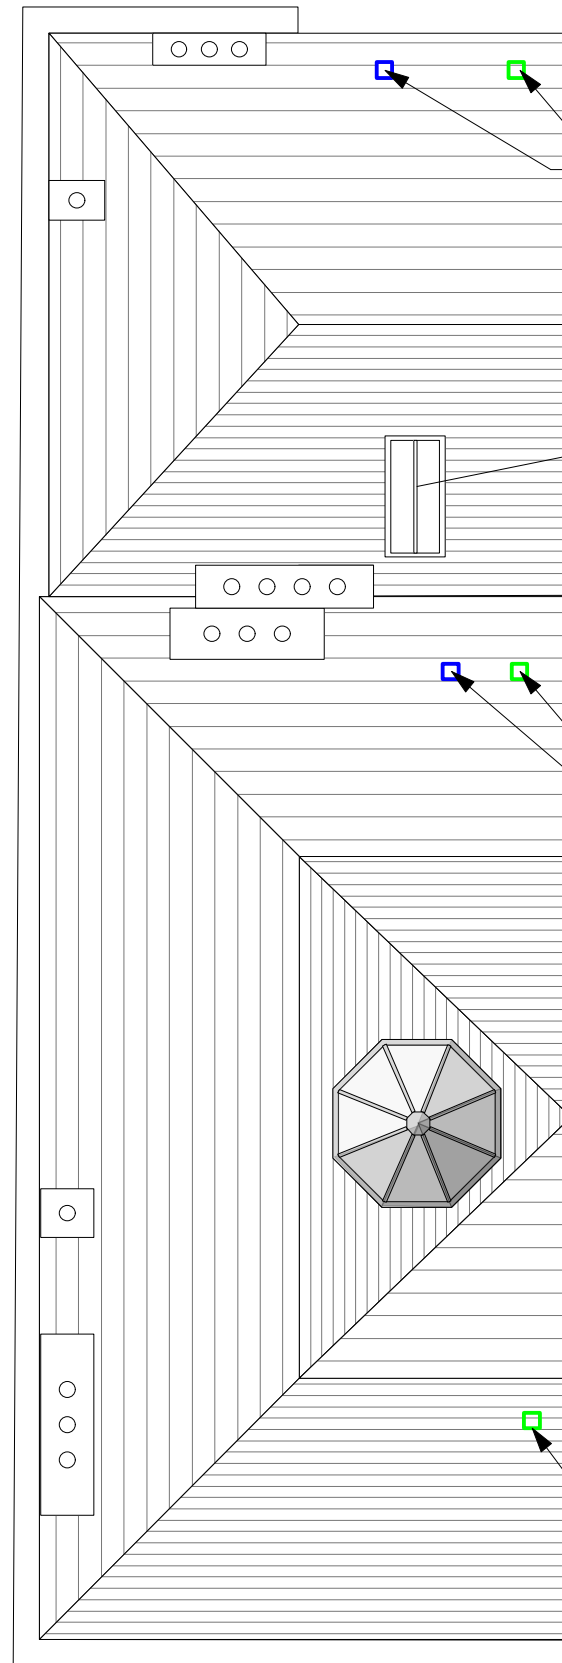

In-line slate ventilator terminal to vertical extract duct & svp

NEW CONSERVATION ROOFLIGHT

In-line slate ventilator terminal to vertical extract duct & svp

In-line slate ventilator terminal to svp

PROPOSED 2ND FLOOR PLAN

PROPOSED SECOND FLOOR PLAN

0 1 2 3 4 5 M

PROPOSED MECHANICAL VENTILATION & SOIL PIPE SCHEMATIC PLANS 2ND FLOOR & ROOF PLAN

1:100 @ A3



© Copyright Ollier Smurthwaite Architects

PLANNING

KEY:

- DENOTES NEW WALLS
- MECHANICAL EXTRACT DUCT RUN
- VERTICAL EXTRACT DUCT
- SOIL PIPE

REVISION	DATE	DESCRIPTION

CLIENT: LEASING OPTIONS LTD	
PROJECT: PROPOSED RESIDENTIAL DEVELOPMENT	
ADDRESS: 28 ST JOHN STREET	
DRAWING TITLE: PROPOSED MECH VENT & SOIL PIPE SCHEMATIC 2 of 2	
SCALE: 1:100 @A3	DATE: DECEMBER 2022
DRAWING NO: A665_P_3007	

OLLIER SMURTHWAITE ARCHITECTS

40 King Street, Manchester, M2 6BA
T 0161 883 0838
F 0161 883 0839
E mail@olliersmurthwaite.com